

ISSUE NOTES (CONTINUED)					ISSUE NOTES (CONTINUED)					ISSUE NOTES				
SHT C15 ISS WAS CORRECTED ON SHT TO AGREE WITH SHT INDEX. ORIG ISS: 02/20/86 CHANGE CLASS: MF					GROUPS 145A, 145B, 145C, 146A, 146B, AND 146C ADDED. ORIG ISS: 02/20/86 CHANGE CLASS: B					GROUP 241A-248A ADDED. GROUP 251A-266A (64 PRS CA ISLU) ADDED. ORIG ISS: 02/20/86 CHANGE CLASS: B				
DRAFT: REW	ENGR: REW	SUPV:	CERTIFIED: 11/15/91	ISSUE: 30	DRAFT: TFL	ENGR: IDK	SUPV:	CERTIFIED: 02/27/90	ISSUE: 23	DRAFT: DSL	ENGR: IDK	SUPV:	CERTIFIED: 03/17/88	ISSUE: 14
MANUF. NOTE 9 ADDED.GRS 1A,3A 1249A CABLE CHGD. POINT CHGS APPLIED TO DWG FROM OC. ORIG ISS: 02/20/86 CHANGE CLASS: MF					REMOVE NRTO RATING FROM GROUP 124A. ORIG ISS: 02/20/86 CHANGE CLASS: M					GROUP 1A,3A ADDED. IN GROUPS 5-15 (ODD) IN SL ID 900451188 CHGD TO 900714981 PER POINT ISSUE. ORIG ISS: 02/20/86 CHANGE CLASS: B				
DRAFT: REW	ENGR: REW	SUPV:	CERTIFIED: 08/14/92	ISSUE: 31	DRAFT: REW	ENGR: WJV	SUPV:	CERTIFIED: 02/27/90	ISSUE: 24	DRAFT: DSL	ENGR: IDK	SUPV:	CERTIFIED: 04/21/88	ISSUE: 15
GROUP 901A,B,C,D THRU 908A,B,C,D ADDED FOR ISLU. (32 PAIRS PLENUM CABLES). ORIG ISS: 02/20/86 CHANGE CLASS: B					GROUP 138A ADDED. CHGS MADE TO CA DIM PER P.I. 24.1 ON SHEETS C12,C13,C14 & C16. ORIG ISS: 02/20/86 CHANGE CLASS: M					S.L. ITEMS 3650,3652,3653,3655,3657 & 3658 ADDED. GROUP 137,138 ADDED. SH C81 AND TABLE 'D' ADDED. REF TO 'SEE MANF' NOTE ADDED TO TABLE 'S'. ORIG ISS: 02/20/86 CHANGE CLASS: B				
DRAFT: HZP	ENGR: HZP	SUPV:	CERTIFIED: 08/20/92	ISSUE: 32	DRAFT: HZP	ENGR: JJK	SUPV:	CERTIFIED: 10/17/90	ISSUE: 25	DRAFT: DSL	ENGR: HDM	SUPV:	CERTIFIED: 07/13/88	ISSUE: 16
GROUP 124B ADDED FOR OSPTS VDT.GROUPS 650 & 651 ADDED TO TABLE"S" ON SHT C4.REF TO DW8A MODULAR PLUG RMVD ON SHTS C84,C85 & C94 AND REPLACED WITH 940-SP-014-3088-031-2P. ORIG ISS: 02/20/86 CHANGE CLASS: B					GROUP 221C THRU 224C & 221D THRU 224D ADDED. SL ITEM 1070 LINED OUT AND SL ITEMS 1301,1302 AND 1303 ADDED. ORIG ISS: 02/20/86 CHANGE CLASS: B					GROUP 143 ADDED. SYMBOL 'S' ADDED TO SL ITEMS 3650, 3652,3653,3655,3657,3658. ORIG ISS: 02/20/86 CHANGE CLASS: B				
DRAFT: REW	ENGR: REW	SUPV:	CERTIFIED: 10/08/92	ISSUE: 33	DRAFT: HZP	ENGR: JJK	SUPV:	CERTIFIED: 01/21/91	ISSUE: 26	DRAFT: DSL	ENGR: IDK	SUPV:	CERTIFIED: 01/11/89	ISSUE: 17
GROUP 17A AND 19A ADDED. ORIG ISS: 02/20/86 CHANGE CLASS: B					GROUP 140 ADDED FOR BCP VERSION 4. REF TO GR 138A AND 138B ADDED TO SHT C5.SL ITEM 3765 & 3810 COM CODE CHGD. MANUF NOTE 8 ADDED. ORIG ISS: 02/20/86 CHANGE CLASS: B					GROUP 144 ADDED. SYMBOL 'S' RMVD FROM SL ITEMS 3650,3652,3653, 3655,3657,3658. ORIG ISS: 02/20/86 CHANGE CLASS: B				
DRAFT: REW	ENGR: WJV	SUPV:	CERTIFIED: 10/16/92	ISSUE: 34	DRAFT: REW	ENGR: REW	SUPV:	CERTIFIED: 03/20/91	ISSUE: 27	DRAFT: DSL	ENGR: IDK	SUPV:	CERTIFIED: 03/09/89	ISSUE: 18
GROUPS 219A & 220A RATED "DA". NEW GROUPS 219B & 220B ADDED. GROUPS 652 & 653 ADDED FOR OSPTS. GROUP 140 ON SHT C5 "D" AND "E" DIM ADDED. SHT C94 NOTE ADDED ON SHT. ORIG ISS: 02/20/86 CHANGE CLASS: B					DWG UPDATED FOR 963T TYPE CONNECTORS. GROUPS 219A AND 220A ADDED (ISLUZ MTB). ORIG ISS: 02/20/86 CHANGE CLASS: B					GROUP 139 (MANUFACTURED IN PHOENIX) ADDED. G135 RATED 'DA' (WAS RPLC'D BY G138). ORIG ISS: 02/20/86 CHANGE CLASS: B				
DRAFT: REW	ENGR: REW	SUPV:	CERTIFIED: 11/30/92	ISSUE: 35	DRAFT: REW	ENGR: REW	SUPV:	CERTIFIED: 09/12/91	ISSUE: 28	DRAFT: DSL	ENGR: IDK	SUPV:	CERTIFIED: 06/01/89	ISSUE: 19
GR 219N & 220N ADDED FOR GLOBAL DOC. OCW POINT ISSUES APPLIED. GROUPS 170 & 170A ADDED FOR RUB CABINET. ORIG ISS: 02/20/86 CHANGE CLASS: B					ERRORS IN SHEET NUMBERING CORRECTED. ORIG ISS: 02/20/86 CHANGE CLASS: M					GROUPS 65A,65B,65C & 65D ADDED. IN SL ITEM 3371 ADDED, ITEM 3455, 3525 AND 3595 RMVD. ORIG ISS: 02/20/86 CHANGE CLASS: B				
DRAFT: HZP	ENGR: HZP	SUPV:	CERTIFIED: 04/30/93	ISSUE: 36	DRAFT: REW	ENGR: REW	SUPV:	CERTIFIED: 09/17/91	ISSUE: 29	DRAFT: DSL	ENGR: IDK	SUPV:	CERTIFIED: 06/27/89	ISSUE: 20
										GROUP 124A & 145 ADDED. SL ITEM 3349 WAS CHANGED FROM 104309471 TO READ 105410245, ITEMS 1580,1610 AND 1650 WERE CHANGED FROM 842362899 TO READ 996975918, ITEMS 1581, 1611, 1651 ADDED PER P.I.,IN SL ALL SYMBOLS '**' WERE REPLC'D BY SYMBOL 'S'. ORIG ISS: 02/20/86 CHANGE CLASS: B				
										DRAFT: LMK ENGR: IDK SUPV: CERTIFIED: 10/20/89 ISSUE: 21				
										GROUP 123B 'DA', DIRECTLY RPL'D BY GROUP 123A. ORIG ISS: 02/20/86 CHANGE CLASS: AC				
										DRAFT: TFL ENGR: IDK SUPV: CERTIFIED: 02/27/90 ISSUE: 22				

SHEET INDEX											
SHT NBR	A1 THRU A11 ISSUE 53										
ISSUE											
SHT NBR	D1 THRU D18 ISSUE 53										
ISSUE											
SHT NBR	B1	B2	B3	B4	B5	B6	B7	B8	B9	B10	B11
ISSUE	49	49	49	49	49	49	49	49	53	53	49
SHT NBR	B12	B13									
ISSUE	49	49									
SHT NBR	C1	C2	C3	C4	C5	C6	C7	C8	C9	C10	C11
ISSUE	49	49	49	49	49	49	49	49	49	49	49
SHT NBR	C12	C13	C14	C15	C16	C17	C18	C19	C20	C21	C22
ISSUE	49	49	49	49	49	49	49	49	49	49	49
SHT NBR	C23	C24	C25	C26	C27	C28	C29	C30	C31	C32	C33
ISSUE	49	49	49	49	49	49	49	49	49	49	49
SHT NBR	C34	C35	C36	C37	C38	C39	C40	C41	C42	C43	C44
ISSUE	49	49	49	49	49	49	49	49	49	49	49
SHT NBR	C45	C46	C47	C48	C49	C50	C51	C52	C53	C54	C55
ISSUE	49	49	49	49	49	49	49	49	49	49	49
SHT NBR	C56	C57	C58	C59	C60	C61	C62	C63	C64	C65	C66
ISSUE	49	49	49	49	49	49	49	49	49	49	49
SHT NBR	C67	C68	C69	C70	C71	C72	C73	C74	C75	C76	C77
ISSUE	49	49	49	49	49	49	53	49	49	53	
SHT NBR	C78	C79	C80	C81	C82	C83	C84	C85	C86	C87	C88
ISSUE	49	49	49	49	49	49	49	49	53	49	49
SHT NBR	C89	C90	C91	C92	C93	C94	C95	C96	C97	C98	C99
ISSUE	49	49	49	49	49	49	49	49	49	47	53
SHT NBR											
ISSUE											

TABLE D-LIST OF ASSOCIATED REFERENCES	
NUMBER	TITLE
=ED4C251-10	FASTECH WIRING & CABLING
=ED5D621-11	INTERCABINET CABLING ORDERING SP EC
=ED5D621-22	INTERCABINET CABLING ORDERING SP EC
=RLED5D621-35	RUNNING LIST
=TCED5D621-35	TABULAR CA CONN DWG
=DENOTES NOT REQD BY INSTALLER	

TABLE OF CONTENTS	
DESCRIPTION	SHT
SHEET INDEX	A1
ASSOCIATED REFERENCES	A1
ISSUE NOTES	A1
ENGINEERING-NOTES	A3
TABLE A	A4
B SECTION GRAPHICS	B1
C SECTION GRAPHICS	C1
MANUFACTURING NOTES	D1
STOCKLIST	D1

LUCENT TECHNOLOGIES - PROPRIETARY USE PURSUANT TO COMPANY INSTRUCTIONS		
		XT13
5ESS (R) SWITCHING EQUIPMENT CABLE ASSEMBLIES FOR INTEGRATED SERVICES DATA NETWORK		
DWG SIZE	ISSUE	
C2	53	
LUCENT TECHNOLOGIES INC ED5D621-35		SHEET A1 OF 141

ED5D621-35

ISSUE NOTES (CONTINUED)					ISSUE NOTES (CONTINUED)					ISSUE NOTES (CONTINUED)				
TO CORRECT PRO-E GRAPHIC SHEET DRAWING ERROR. ORIG ISS: 02/20/86 CHANGE CLASS: MF					GRP 124D ADDED FOR OSPS-COMBINE SERVICE TERM OR VISTA TERM. GRP 124A DA'D. ORIG ISS: 02/20/86 CHANGE CLASS: B					GROUPS 300 THRU 313 ADDED FOR NSI SOFTWARE TRIAL. GROUPS ADDED FOR AMP CONN CHANGE. GRAPHICS SHALL BE UPDATED IN A LATER ISSUE. ORIG ISS: 02/20/86 CHANGE CLASS: MF				
DRAFT: SLB	ENGR: SLB	SUPV:	CERTIFIED: 02/11/99	ISSUE: 52	DRAFT: WJD	ENGR: WJD	SUPV:	CERTIFIED: 09/18/95	ISSUE: 45	DRAFT: WJD	ENGR: WJD	SUPV:	CERTIFIED: 07/30/93	ISSUE: 37
(H09286) ST ITEMS 3617, 3655, 3670, 3850, 8320 READ "406756361". SHEET B9 GROUPS 547A, 548A, 551A, 553A, 555A, 557A, 552A CABLE CODE 810AS. SHEET B9 GROUPS 551A, 553A, 555A, 557A, 552A CABLE DESIG READ "JX139, JX140, JX143, JX144, JX145" RESPECTIVELY. SHEET B10 GROUP 561A READ "810A". SHEET C74, C86, C99 MOD PLUG READ "940-SP-014-3088-031-2P". SHEET C77 CC READ "406756361". PER PI 52.1. ORIG ISS: 02/20/86 CHANGE CLASS: ME					ENG. NT 53 GRP 505A C98 READ C30, GRP 555A C98 READ C25. SHEET C98 ADDED PER OCW PI 45.1. GRPS 211A-218A, 221A-224D, 231A-266A, 501A-564A, 901A-908D DA'ED IN TBL A. H7828 ORIG ISS: 02/20/86 NDD NBR: NDD5D621NW-16 CHANGE CLASS: B					GROUP 145D ADDED FOR RISLU E/W MFFU (J5D003FJ-1) POWER PLANT ALARM. GROUP 170 & 170A MODIFIED IN TBL S. GROUPS 137,140,145A, 145B,145C,146A,146B,146C,905A THRU 905D AND 902A THRU 902D GRAPHICS MODIFIED. STOCKLIST ITEMS 3650,3811 & 3812 MODIFIED, ITEMS 3653,3658,3667 & 3672 REMOVED. ORIG ISS: 02/20/86 CHANGE CLASS: B				
DRAFT: JEP	ENGR: JEP	SUPV:	CERTIFIED: 03/08/01	ISSUE: 53	DRAFT: JAS	ENGR: JAS	SUPV: PK	CERTIFIED: 08/15/96	ISSUE: 46	DRAFT: TFL	ENGR: TFL	SUPV:	CERTIFIED: 08/24/93	ISSUE: 38
					(H7925)GROUPS 211A-218A,221A-224A,221C-224C,221D-224D,231A-238A, 241A-248A,251A-266A,501A-508A,511A-518A,521A-524A,531A-534A, 541A-548A,551A-558A,561A-564A,901A-908A,901B-908B,901C-908C AND 901D-908D WERE PREVIOUSLY RATED DA.OCW POINT ISSUE 46.1 & 46.2 APPLIED. IN STOCKLIST ITEM 3648 REMOVED. ITEM 3650 COMCODE CHG'D FROM 845028570 TO 407027374. SHEET C74 CHG'D ACCORDINGLY. SHEET C98 CHG'D TO SHOW GROUPS 505A OR 555A INSTEAD OF GROUP 513A. PIM 960C0082 APPLIED. STOCKLIST ITEMS 1580,1610,1650,3300,3766, 3845,3226,3263,3341 LINED OUT. ITEMS 3227,3267,3344,1579, 1609,1649,3301,3767,3846,3861,8421 ADDED. SL ITEM 4575 QTY 2 REMOVED. ORIG ISS: 02/20/86 NDD NBR: NDD5D621NW-19 CHANGE CLASS: ME					SHT C4 CODE FOR GROUP 653 CHANGED. STOCK LIST ITEM 1015, 1075, 1085, 3465, 3470, 3535, 3540, 3605, 3610, 3660 THRU 3668, 4537, 4720, 5850, 5920, 5990, 6060, 7130, 7200, 7270, 7340, 7410, 7480, 7550, 7620, 7690, 7760, 7830, 7900, 8200 AND 8475 CHANGED. GROUP 70 ADDED, SHEET C104 AND SL 9140 AND 8145. SHT C82 MODULER PLUG CHGD. S.L ITEMS 3650,3655 CHGD. S.L ITEMS 3648 & 6654 ADDED. ORIG ISS: 02/20/86 CHANGE CLASS: B				
					DRAFT: WJV ENGR: WJV SUPV: CERTIFIED: 10/10/96 ISSUE: 47					GR172 ADDED FOR RUB E/W MFFU AND DLTU-R AT 062. GR 174 ADDED FOR RISLUL/2 E/W CLASSIC FPU RISLUL AT 019 AND RISLUZ AT 062. ORIG ISS: 02/20/86 CHANGE CLASS: AC				
GROUPS 300 THRU 309, 310 THRU 313 AND 304A DA'ED IN TABLE A. ORIG ISS: 02/20/86 NDD NBR: NDD5D621NW-20 CHANGE CLASS: ME					DRAFT: JAS ENGR: JAS SUPV: CERTIFIED: 11/22/96 ISSUE: 48					STOCKLIST ITEMS 1205,1275,1315,1365,1415 AND 1455 COM-CODE CHGD FROM 402150767 TO 407138718. SL ITEM 4440 CHD FROM 847101292 TO 400890067. ORIG ISS: 02/20/86 CHANGE CLASS: MF				
(H7912) ENG NOTE 52 AND 53 MODIFIED. GROUPS 147A,147B AND 147C ADDED. SL ITEMS 3850,3855,3865,3870 AND 3875 ADDED. SHEET C99 ADDED. SL ITEM 3654 CC 844041442 REMOVED, 3655 READ 845028588 SHT C74 GRP 138,138B MOD PLUG READ 845028588. SL ITEM 3650,3652 "S" REMOVED FROM NOTE SYM COLUM. TITLE READ AT&T ALL GRAPHIC SHEETS. ORIG ISS: 02/20/86 NDD NBR: NDD5D522NW-67 CHANGE CLASS: B					DRAFT: JAS ENGR: JAS SUPV: CERTIFIED: 03/26/97 ISSUE: 49					DRAWING UPDATED FOR GPI (METRICS). ORIG ISS: 02/20/86 CHANGE CLASS: ME				
***** CHANGE TAG GR134 ***** NEW CABLE FOR ETHERNET LINE FROM TSIU4-2 TO ETHERNET HUB. GROUP 134 (FOR ETHERNET HUB)ADDED. STOCKLIST ITEMS 3617 AND 3618 ADDED. SHEET B7 UPDATED AND NEW SHEET C100 ADDED. GROUP INDEX(ENG NOTE 53)UPDATED. ***** TAG H8345 NDD5D621NW-26 ***** SH C77. CHG DIMENSIONS, AND GRD STRAP CONNECTION. SH D14, RESTORE SL 8420. DELETE SL 8421 * 8300. CHG CC#, SL 8320, & 8280. SH B6, REMOVE GRPS 124 & 124A FROM TABLES S. SH D3 REINSTATE SL 3226, 3263 & 3341. DELETE SL 3227, 3267 & 3344. SH D4, SL 3371, RMV G124B. SH D14, REINSTATE SL 8420. CHANGES MADE TO CORRECT PREVIOUS ISSUE 50W0, SHT B6 TABLS 124, 124B CA CODE READ 1002002C. GRP 124A & 124D RMVED. ORIG ISS: 02/20/86 CHANGE CLASS: B					DRAFT: WJV ENGR: WJV SUPV: CERTIFIED: 09/15/98 ISSUE: 50					IN STOCKLIST GROUPS 219, 219A, 219B, 220, 220A, & 220B, 982SS CONNECTORS REPLACED WITH 963T2-6. SHEET B7 "D" & "E" DIM CHANGE ACCORDINGLY. ORIG ISS: 02/20/86 CHANGE CLASS: B				
GROUP 65E ADDED TO TABLE A, TABLE S (GRAPHIC SHEET B6), STOCKLIST (ITEMS 1661-1664) AND ENGINEERING NOTE 53. ORIG ISS: 02/20/86 CHANGE CLASS: B					DRAFT: SLB ENGR: SLB SUPV: CERTIFIED: 02/03/99 ISSUE: 51					ADDED GRP 204. STOCKLIST ITEMS 1488 & 1527 COM-CODE CHGD FROM 406827121 TO 406966747. SHEET B6 CHANGED PER POINT ISSUE. ENG 53 REVISED TO CORRECT SHEET LOCATION FOR GROUP REF. DIM ON SHTS B1,B2,B5,B6,B7 & B10 CHG'D. ORIG ISS: 02/20/86 CHANGE CLASS: ME				

SEE PROPRIETARY NOTICE ON SHEET ONE

XT13

5ESS (R) SWITCHING EQUIPMENT
CABLE ASSEMBLIES
FOR
INTEGRATED SERVICES DATA NETWORK

DWG SIZE C2 ISSUE 53

LUCENT TECHNOLOGIES INC ED5D621-35 SHEET A2 OF 141

ENGINEERING NOTES

***** CONTINUED *****

127A	309
145	310
170	311
170A	312
701	313
111	304A

ENGINEERING NOTES

***** CONTINUED *****

246A	B4,C56
247A	B4,C55
248A	B4,C57
251A	B11,C58
252A	B11,C59
253A	B11,C60
254A	B11,C61
255A	B11,C62
256A	B11,C63
257A	B11,C64
258A	B11,C65
259A	B11,C66
260A	B11,C67
261A	B11,C68
262A	B11,C69
263A	B11,C70
264A	B11,C71
265A	B11,C72
266A	B11,C73
501A	B8,C22
502A	B8,C25
503A	B8,C23
504A	B8,C26
505A	B8,C98
506A	B8,C27
507A	B8,C24
508A	B8,C28
511A	B8,C29
512A	B8,C33
513A	B8,C30
514A	B8,C34
515A	B8,C31
516A	B8,C35
517A	B8,C32
518A	B8,C36
521A	B8,C37
522A	B8,C39
523A	B8,C38
524A	B8,C40
531A	B9,C41
532A	B9,C43
533A	B9,C42
534A	B9,C44
541A	B9,C45
542A	B9,C47
543A	B9,C46
544A	B9,C48
545A	B9,C49
546A	B9,C51
547A	B9,C50
548A	B9,C52
551A	B9,C22
552A	B9,C25
553A	B9,C23
554A	B10,C26
555A	B9,C98
556A	B10,C27
557A	B9,C24
558A	B10,C28
561A	B10,C37
562A	B10,C39
563A	B10,C38
564A	B10,C40
601 THRU 623	B2
(ODD)	
650,651,652,653	B5
70	C96
701	B10,C53
901A THRU 901D	B12,C87
902A THRU 902D	B12,C92
903A THRU 903D	B12,C88
904A THRU 904D	B13,C93
905A THRU 905D	B12,C90
906A THRU 906D	B13,C94
907A THRU 907D	B12,C91
908A THRU 908D	B13,C95

54. THE FOLLOWING GROUPS ARE EQUIVALENT BUT HAVE DIFFERENT CONNECTORS:

T-TYPE	AMP TYPE
101	300
103	301
105	302
105A	303
109	304
113	305
115	306
123A	307
126	308

----- CONTINUED TO THE LEFT -----

ENGINEERING NOTES

51. RESERVED

52. THIS DOCUMENT CONTAINS NO ENGINEERING INFORMATIONS. ALL ORDERING INFORMATION IS SHOWN ON ED5D621-11; ED5D621-22; ED5D726-11 OR ED5D500-21.
THIS DRAWING IS FOR A SHOP ASSIST ONLY.

53.

GROUP INDEX	
GROUP	SH NO.
1,1A,3,3A,5,7,9	B1
11,13,15	
17,17A,19,19A	B5
65A,65B,65C,65D	B6
65E	B6
101,103	B1
105,105A	B1,C1
109,111,113,115	B1
122,122A,122B,	B6
123,123A,123B,	
124,124A,124B,	
124D,126,127,	
127A,128,	
129A	B2
131,132,133	B7
134	B7,C100
135	B2
136	B7
137,138	B7,C74
138A	B7,C77
138B	B7,C74
139	B7,C75
140	B7,C86
141,142	B2
143,144,145,	B7
145D	
145A,145B,145C,	C76
146A,146B,146C	
147A,147B,147C	C99
148	B7,C74
170,170A	B7
172,174	B7
204	C97
211A	B3,C2
212A	B3,C6
213A	B3,C3
214A	B3,C7
215A	B3,C4
216A	B3,C8
217A	B3,C5
218A	B3,C9
219,219A,219B	B7
220,220A,220B	
220A	
219N,220N	B5
221A	B3,C10
221C	B3,C78
221D	B3,C79
222C	B3,C82
222D	B3,C83
223C	B3,C80
223D	B3,C81
224C	B3,C84
224D	B3,C85
222A	B3,C12
223A	B3,C11
224A	B3,C13
231A	B3,C14
232A	B3,C16
233A	B3,C15
234A	B3,C17
235A	B3,C18
236A	B3,C20
237A	B3,C19
238A	B3,C21
241A	B4,C54
242A	B4,C56
243A	B4,C55
244A	B4,C57
245A	B4,C54

----- CONTINUED TO THE LEFT -----

SEE PROPRIETARY NOTICE ON SHEET ONE

XT13

5ESS (R) SWITCHING EQUIPMENT
CABLE ASSEMBLIES
FOR
INTEGRATED SERVICES DATA NETWORK

DWG SIZE C2	ISSUE 53
----------------	-------------

LUCENT TECHNOLOGIES INC ED5D621-35

SHEET A3
OF 141

TABLE A-FEATURES											
EQUIPMENT		EQUIPMENT OR CIRCUIT DATA							SD EQUIVALENT		
DESCRIPTION	REF NOTE	RAT-ING	LIST OR GROUP	QTY	EQUIPMENT OR CIRCUIT	L/G OR FIG	WRG	APP	SCHEMATIC	FIG	OPT
CONNECTORIZED SWBD CABLE ASSEMBLY REQUIRED FROM DLTU-R TO DSX. (INPUT).			1								
CONNECTORIZED SWBD CABLE ASSEMBLY REQUIRED FROM DLTUR TO DSX (INPUT) USING 1249016C CABLE. MAX 450 FT.			1A								
CONNECTORIZED CABLE ASSEMBLY REQUIRED FROM DLTU-R TO DSX (OUTPUT).			3								
CONNECTORIZED SWBD CABLE ASSEMBLY REQUIRED FROM DLTUR TO DSX (OUTPUT) USING 1249016C CABLE. MAX 450 FT.			3A								
CONNECTORIZED CABLE ASSEMBLY REQUIRED FROM DLTU-R TO DSX (INPUT).			5								
CONNECTORIZED CABLE ASSEMBLY REQUIRED FROM DLTU-R TO DSX (INPUT).			7								
CONNECTORIZED CABLE ASSEMBLY REQUIRED FROM DLTU-R TO DSX (INPUT).			9								
CONNECTORIZED CABLE ASSEMBLY REQUIRED FROM DLTU-R TO DSX (OUTPUT).			11								
CONNECTORIZED CABLE ASSEMBLY REQUIRED FROM DLTU-R TO DSX (OUTPUT).			13								
CONNECTORIZED CABLE ASSEMBLY REQUIRED FROM DLTU-R TO DSX (OUTPUT).			15								
CONNECTORIZED COAX CABLE ASSEMBLY REQUIRED FROM DLTU-R TO DSX (OUTPUT).			17								
CONNECTORIZED COAX CABLE ASSEMBLY REQUIRED FROM DLTU-R TO DSX (OUTPUT). (735A COAXIAL CABLE)EXPORT ONLY			17A								
CONNECTORIZED COAX CABLE ASSEMBLY REQUIRED FROM DLTU-R TO DSX (INPUT).			19								
CONNECTORIZED COAX CABLE ASSEMBLY REQUIRED FROM DLTU-R TO DSX (INPUT). (735A COAXIAL CABLE)EXPORT ONLY			19A								
RS232 INTERFACE CABLE FOR DISDNI 7A TO MODEM (SYNC). OAP,DAS/C, RTRS,AP,CNO,SRA OR VENDER DTE EQPT.			65A						SD1C963-01		Z
RS232 INTERFACE CABLE FOR DISDNI 7A TO MODEM (ASYNC). OAP,HOBIS/HOBIC OR VENDER DTE EQPT.			65B						SD1C963-01		Y
RS232 INTERFACE CABLE FOR DISDNI 7A TO DTE (SYNC) (NO MODEM). AP, CNO,SRA OR VENDER EQPT.			65C						SD1C963-01		X
RS232 INTERFACE CABLE FOR DISDNI 7A TO MODEM. AUTOQUOTE,PCDA OR VENDER DTE EQPT.			65D						SD1C963-01		W
RS232 INTERFACE CABLE FOR DISDNI 7A/7B TO TELEBIT OR PARADYNE MODEM.			65E								
CONNECTORIZED SWBD CABLE ASSEMBLY REQUIRED FOR BCP VER.4 REQUIRING 50 PIN FEMALE (KS16690,L3) CONN.			70								
CONNECTORIZED CABLE ASSEMBLY REQUIRED FROM LAU TO DF. E/W 963 T-TYPE CONNECTORS.			101								

TABLE-A CONTINUED

TABLE A-FEATURES (CONTINUED)											
EQUIPMENT		EQUIPMENT OR CIRCUIT DATA							SD EQUIVALENT		
DESCRIPTION	REF NOTE	RAT-ING	LIST OR GROUP	QTY	EQUIPMENT OR CIRCUIT	L/G OR FIG	WRG	APP	SCHEMATIC	FIG	OPT
CONNECTORIZED CABLE ASSEMBLY REQUIRED FROM LAU TO DF. E/W 963 T-TYPE CONNECTORS.			103								
CONNECTORIZED SWBD CABLE ASSEMBLY REQUIRED FROM LAU INSTALLED IN RISLU (1-4) TO DF. E/W T-TYPE CONNECTORS.			105								
CONNECTORIZED SWBD CABLE ASSEMBLY REQUIRED FOR LAU INSTALLED IN LTP (TA PACKS) TO DF. E/W T-TYPE CONNECTORS.			105A								
CONNECTORIZED SWBD CABLE ASSEMBLY REQUIRED FROM LAU TO DF. E/W T-TYPE CONNECTORS.			109								
CONNECTORIZED SWBD CABLE ASSEMBLY REQUIRED FROM LAU TO DF. E/W T-TYPE CONNECTORS.			111								
CONNECTORIZED SWBD CABLE ASSEMBLY REQUIRED FROM LAU TO DF. E/W T-TYPE CONNECTORS.			113								
CONNECTORIZED SWBD CABLE ASSEMBLY REQUIRED FROM LAU TO DF. E/W T-TYPE CONNECTORS.			115								
CONNECTORIZED SWBD CABLE ASSEMBLY REQUIRED FROM LAU TO DATA SET CAB. (ASYNCH).			122								
CONNECTORIZED SWBD CABLE ASSEMBLY FROM LAU TO DS TERMINAL (AT&T 2096A OR GANDALF RM3120) ARRANGED FOR A ASSYNC OPERATION. (1200 BPS).			122A								
CONNECTORIZED SWBD CABLE ASSEMBLY FROM LAU TO DS TERMINAL (AT&T 4000) ARRANGED FOR A ASSYNC OPERATION. (110 BPS).			122B								
CONNECTORIZED SWBD CABLE ASSEMBLY REQUIRED FROM LAU TO DATA SET CAB. (SYNCH).			123								
CONNECTORIZED SWBD CABLE ASSEMBLY FROM LAU TO DS TERMINAL (GANDALF 3309) ARRANGED FOR A SYNC OPERATION. (19.2K BPS). E/W T-TYPE CONNECTORS.			123A								
CONNECTORIZED SWBD CABLE ASSEMBLY FROM LAU TO DS TERMINAL (GANDALF 3309) ARRANGED FOR A SYNC OPERATION. (9.6K BPS). (THIS GROUP IS DIRECTLY RPL'D BY GROUP 123A). FE:ED5D621-35,G123A DA EFF:02/27/90		DA	123B								
CONNECTORIZED SWBD CABLE ASSEMBLY REQUIRED FROM VDT OR BST TO OPERATOR HEAD SET.			124								

TABLE-A CONTINUED

SEE PROPRIETARY NOTICE ON SHEET ONE

XT13

5ESS (R) SWITCHING EQUIPMENT
CABLE ASSEMBLIES
FOR
INTEGRATED SERVICES DATA NETWORK

DWG SIZE
C2

ISSUE
53

ED5D621-35

LUCENT TECHNOLOGIES INC ED5D621-35

SHEET A4
OF 141

PRINTED IN U.S.A.

TABLE A-FEATURES (CONTINUED)

EQUIPMENT		EQUIPMENT OR CIRCUIT DATA							SD EQUIVALENT		
DESCRIPTION	REF NOTE	RAT-ING	LIST OR GROUP	QTY	EQUIPMENT OR CIRCUIT	L/G OR FIG	WRG	APP	SCHEMATIC	FIG	OPT
CONNECTORIZED CABLE ASSEMBLY REQUIRED FROM VDT OR BST TO A OPERATOR HEAD SET. (6 POSITION MODULAR PLUG CABLE). DA EFF:09/20/95 FE/RA:NONE		DA	124A								
CONNECTORIZED SWDB CABLE ASSEMBLY FROM VDT TO OPERATOR HEAD SET TO PROVIDE IMPEDANCE MATCHING FEATURE ON PORT WITH PRS-300.			124B								
CONNECTORIZED SWITCHBOARD CABLE ASSEMBLIES (2 CABLES REQUIRED) FOR CST/OSPS OPERATOR WORK-STATION (OWS) OR IPIB BASED EQUIV TERMINALS CONNECTED TO OPERATOR HEAD SET USED WITH OR WITHOUT "PRS-300".			124D								
CONNECTORIZED SWDB CABLE ASSEMBLY FOR OSPS DS ALARMS FROM INVERTER TO DF. E/W T-TYPE CONNECTORS.			126								
CONNECTORIZED SWDB CABLE ASSEMBLY FOR OSPS LTP ALARMS FROM FAN UNIT TO DF.			127								
CONNECTORIZED SWDB CABLE ASSEMBLY FOR OSPS LTP ALARMS FROM FUSE/FILTER UNIT TO DF. E/W T-TYPE CONNECTORS.			127A								
POWER CABLE ASSEMBLY REQUIRED FROM VDT OR BST TO JCTR BOX.			128								
RESERVED.			129								
CONNECTORIZED SWDB CABLE ASSEMBLY EQPT WITH RV2217 TERMINALS FOR DATA SET TO DATA SET 4-WIRE CONNECTION.			129A								
RESERVED.			130								
CONNECTORIZED SWDB CABLE ASSEMBLY REQUIRED FROM BST TO CCI.			131								
CONNECTORIZED SWDB CABLE ASSEMBLY REQUIRED FROM BST TO CCI.			132								
CONNECTORIZED SWDB CABLE ASSEMBLY REQUIRED FROM BST TO CCI.			133								
CONNECTORIZED SWDB CABLE ASSEMBLY REQUIRED FOR SMPU4/5 TO ETHERNET HUB.(10 BASE T) (8 PIN MOD PLUG TERMINATION) MAX LENGTH 300 FT.			134								
CONNECTORIZED SWDB CABLE ASSEMBLY REQUIRED FOR EACH VDT/BST CONNECTED TO A DF (SWC). (REPLC'D WITH G138) FE:ED5D621-35,G138 DA EFF:06/01/89		DA	135								
CONNECTORIZED SWDB CABLE ASSEMBLY REQUIRED FOR AT&T 4000 TERMINAL CONNECTED TO A DF. (2-WIRE ONLY).			136								
CONNECTORIZED SWDB CABLE ASSEMBLY REQUIRED FOR EQUIPMENT REQUIRING A (6) POSITION MODULAR PLUG WIRED TO A DISTRIBUTING FRAME (SWC).			137								
CONNECTORIZED SWDB CABLE ASSEMBLY REQUIRED FOR EQUIPMENT REQUIRING A (8) POSITION MODULAR PLUG WIRED TO A DISTRIBUTING FRAME (SWC).			138								

TABLE-A CONTINUED

ED5D621-35

TABLE A-FEATURES (CONTINUED)

EQUIPMENT		EQUIPMENT OR CIRCUIT DATA							SD EQUIVALENT		
DESCRIPTION	REF NOTE	RAT-ING	LIST OR GROUP	QTY	EQUIPMENT OR CIRCUIT	L/G OR FIG	WRG	APP	SCHEMATIC	FIG	OPT
CONNECTORIZED SWDB CABLE ASSEMBLY REQUIRED FOR EQUIPMENT REQUIRING A (8) POSITION MODULAR PLUG E/W A GROUND WIRE.			138A								
CONNECTORIZED SWDB CABLE ASSEMBLY REQUIRED FOR EQUIPMENT REQUIRING A (8) POSITION MODULAR PLUG WIRED TO A DISTRIBUTING FRAME (SWC).			138B								
DATA SET CORD EQPT WITH 8 PIN MODULAR PLUG AND RS232 25 PIN FEMALE CONN.(MANUF. LOC PHOENIX)			139								
CONNECTORIZED SWDB CABLE ASSEMBLY REQUIRED FOR BCP VER.4 REQUIRING 8-PIN MODULAR PLUG AND 50 PIN FEMALE (KS16690L3).			140								
CONNECTORIZED SWDB CABLE ASSEMBLY REQUIRED FROM RTAU J1C249A-1 TO DF.			141								
CONNECTORIZED SWDB CABLE ASSEMBLY REQUIRED FROM RTAU J1C249A-1 TO GANDALF LDS 309A DATA SET.			142								
CONNECTORIZED SWDB CABLE ASSEMBLY REQUIRED FROM 7A DISDNI DS TO 2096A DS. (NULL MODEM CABLE).			143								
CONNECTORIZED SWDB CABLE ASSEMBLY REQD TO EXTEND 7A DISDNI TO AP WHEN DISTANCE IS GREATER THAN 7'. (MAX 43 FEET).			144								
CONNECTORIZED CABLE ASSEMBLY FROM BT F/F (J5D003BT-1) ALARM CKT IN RISLU TO A PWR PLANT. (ALARM BAT CABLE) E/W T-TYPE CONNECTORS.			145								
TELECOMMUNICATIONS RESOURCE MANAGEMENT SYSTEM (TERMS). CONNECTORIZED CABLE ASSEMBLY REQUIRED FOR AT&T 615 TERMINAL (7 FEET).			145A								
TELECOMMUNICATIONS RESOURCE MANAGEMENT SYSTEM (TERMS). CONNECTORIZED CABLE ASSEMBLY REQUIRED FOR AT&T 615 TERMINAL (25 FEET).			145B								
TELECOMMUNICATIONS RESOURCE MANAGEMENT SYSTEM (TERMS). CONNECTORIZED CABLE ASSEMBLY REQUIRED FOR AT&T 615 TERMINAL (50 FEET).			145C								
CONNECTORIZED CABLE ASSEMBLY FROM DLTU-R ALM CKT IN RISLU E/W MFFU F/F (J5D003FJ-1) TO A PWR PLANT. (ALARM BAT CABLE) E/W T-TYPE CONNECTORS.			145D								

TABLE-A CONTINUED

SEE PROPRIETARY NOTICE ON SHEET ONE

XT13

5ESS (R) SWITCHING EQUIPMENT
CABLE ASSEMBLIES
FOR
INTEGRATED SERVICES DATA NETWORK

DWG SIZE C2 ISSUE 53

LUCENT TECHNOLOGIES INC ED5D621-35

SHEET A5 OF 141

TABLE A-FEATURES (CONTINUED)											
EQUIPMENT		EQUIPMENT OR CIRCUIT DATA							SD EQUIVALENT		
DESCRIPTION	REF NOTE	RAT-ING	LIST OR GROUP	QTY	EQUIPMENT OR CIRCUIT	L/G OR FIG	WRG	APP	SCHEMATIC	FIG	OPT
TELECOMMUNICATIONS RESOURCE MANAGEMENT SYSTEM (TERMS). CONNECTORIZED CABLE ASSEMBLY REQUIRED FOR AT&T MODEM (7 FEET).			146A								
TELECOMMUNICATIONS RESOURCE MANAGEMENT SYSTEM (TERMS). CONNECTORIZED CABLE ASSEMBLY REQUIRED FOR AT&T MODEM (25 FEET).			146B								
TELECOMMUNICATIONS RESOURCE MANAGEMENT SYSTEM (TERMS). CONNECTORIZED CABLE ASSEMBLY REQUIRED FOR AT&T MODEM (50 FEET).			146C								
CONNECTORIZED SWITCHBOARD CABLE ASSEMBLY REQUIRED FOR ONE KS23996 TERMINAL TO 572 PRINTER (RJ45 TO DP25) INTERFACE. (7 FEET).			147A								
CONNECTORIZED SWITCHBOARD CABLE ASSEMBLY REQUIRED FOR ONE KS23996 TERMINAL TO 572 PRINTER (RJ45 TO DP25) INTERFACE. (25 FEET).			147B								
CONNECTORIZED SWITCHBOARD CABLE ASSEMBLY REQUIRED FOR ONE KS23996 TERMINAL TO 572 PRINTER (RJ45 TO DP25) INTERFACE. (50 FEET).			147C								
CONNECTORIZED CABLE ASSEMBLY FROM F/F (J5D003FM-1) ALM CKT WITHIN RUB CAB TO A PWR PLANT. (ALARM BAT CABLE) E/W T-TYPE CONNECTORS.			170								
CONNECTORIZED CABLE ASSEMBLY FROM DLTU-R WITHIN RUB CAB E/W MFFU (J5D003FJ-1). FOR ALM CKT FROM RUB CAB TO A PWR PLANT. (ALARM BAT CABLE) E/W T-TYPE CONNECTORS.			170A								
CONNECTORIZED CABLE ASSEMBLY FOR A RUB CABINET E/W MFFU AND DLTU-R AT 062 (DLTU-R E/W TN1410)			172								
CONNECTORIZED CABLE ASSEMBLY FOR A RISLU1/2 CAB E/W A CLASSIC FFU WITH DLTU-R AT 019 FOR RISLU1 AND 062 FOR RISLU2. (DLTU-R E/W TN1410)			174								
CONNECTORIZED SWBD CABLE ASSEMBLY REQUIRED FOR REMOTE TERMINALS. (10 T BASE CROSSOVER) (ETHERNET)			204								
CONNECTORIZED SWBD CABLE ASSEMBLY REQUIRED FROM ISLU TO DF. (4-WIRES) (LG 00,01).			211A								
CONNECTORIZED SWBD CABLE ASSEMBLY REQUIRED FROM ISLU TO DF. (4-WIRES) (LG 08,09).			212A								
CONNECTORIZED SWBD CABLE ASSEMBLY REQUIRED FROM ISLU TO DF. (4-WIRES) (LG 02,03).			213A								
CONNECTORIZED SWBD CABLE ASSEMBLY REQUIRED FROM ISLU TO DF. (4-WIRES) (LG 10,11).			214A								
CONNECTORIZED SWBD CABLE ASSEMBLY REQUIRED FROM ISLU TO DF. (4-WIRES) (LG 04,05).			215A								
CONNECTORIZED SWBD CABLE ASSEMBLY REQUIRED FROM ISLU TO DF. (4-WIRES) (LG 12,13).			216A								

TABLE-A CONTINUED

ED5D621-35

TABLE A-FEATURES (CONTINUED)											
EQUIPMENT		EQUIPMENT OR CIRCUIT DATA							SD EQUIVALENT		
DESCRIPTION	REF NOTE	RAT-ING	LIST OR GROUP	QTY	EQUIPMENT OR CIRCUIT	L/G OR FIG	WRG	APP	SCHEMATIC	FIG	OPT
CONNECTORIZED SWBD CABLE ASSEMBLY REQUIRED FROM ISLU TO DF. (4-WIRES) (LG 06,07).			217A								
CONNECTORIZED SWBD CABLE ASSEMBLY REQUIRED FROM ISLU TO DF. (4-WIRES) (LG 14,15).			218A								
CONNECTORIZED SWBD CABLE ASSEMBLY REQUIRED FROM ISLU TO MMSU. (MTB CABLE). (CABLE EQUIPPED WITH 963T CONN)			219								
CONNECTORIZED SWBD CABLE ASSEMBLY REQUIRED FROM ISLU2 TO MMSU (MTB CABLE) FE:ED5D621-35,G219B DA EFF:11/18/92		DA	219A								
CONNECTORIZED SWBD CABLE ASSEMBLY REQUIRED FROM ISLU2 TO MMSU (MTB CABLE)			219B								
CONNECTORIZED SWBD CABLE ASSEMBLY REQUIRED FROM ISLU TO MMSU. (MTB CABLE). (CABLE EQUIPPED WITH AMP CONN)			219N								
CONNECTORIZED SWBD CABLE ASSEMBLY REQUIRED FROM ISLU TO MMSU. (MTB CABLE). (CABLE EQUIPPED WITH 963T CONN)			220								
CONNECTORIZED SWBD CABLE ASSEMBLY REQUIRED FROM ISLU2 TO MMSU (MTB CABLE) FE:ED5D621-35,G220B DA EFF:11/18/92		DA	220A								
CONNECTORIZED SWBD CABLE ASSEMBLY REQUIRED FROM ISLU2 TO MMSU (MTB CABLE)			220B								
CONNECTORIZED SWBD CABLE ASSEMBLY REQUIRED FROM ISLU TO MMSU. (MTB CABLE). (CABLE EQUIPPED WITH AMP CONN)			220N								
CONNECTORIZED SWBD CABLE ASSEMBLY REQUIRED FROM ISLU TO DF. TWO WIRE - 128 PAIR CABLE (LG 00,01,02,03).			221A								
CONNECTORIZED SWBD CABLE ASSEMBLY REQUIRED FROM ISLU TO DF. TWO WIRE - 64 PAIR CABLE (LG 00,01).			221C								
CONNECTORIZED SWBD CABLE ASSEMBLY REQUIRED FROM ISLU TO DF. TWO WIRE - 64 PAIR CABLE (LG 02,03).			221D								
CONNECTORIZED SWBD CABLE ASSEMBLY REQUIRED FROM ISLU TO DF. TWO WIRE - 128 PAIR CABLE (LG 08,09,10,11).			222A								

TABLE-A CONTINUED

SEE PROPRIETARY NOTICE ON SHEET ONE	
XT13	
5ESS (R) SWITCHING EQUIPMENT CABLE ASSEMBLIES FOR INTEGRATED SERVICES DATA NETWORK	
DWG SIZE C2	ISSUE 53
LUCENT TECHNOLOGIES INC	ED5D621-35
SHEET A6 OF 141	

TABLE A-FEATURES (CONTINUED)											
EQUIPMENT		RAT-ING	LIST OR GROUP	EQUIPMENT OR CIRCUIT DATA					SD EQUIVALENT		
DESCRIPTION	REF NOTE			QTY	EQUIPMENT OR CIRCUIT	L/G OR FIG	WRG	APP	SCHEMATIC	FIG	OPT
CONNECTORIZED SWBD CABLE ASSEMBLY REQUIRED FROM ISLU TO DF. TWO WIRE - 64 PAIR CABLE (LG 08,09).			222C								
CONNECTORIZED SWBD CABLE ASSEMBLY REQUIRED FROM ISLU TO DF. TWO WIRE - 64 PAIR CABLE (LG 10,11).			222D								
CONNECTORIZED SWBD CABLE ASSEMBLY REQUIRED FROM ISLU TO DF. TWO WIRE - 128 PAIR CABLE (LG 04,05,06,07).			223A								
CONNECTORIZED SWBD CABLE ASSEMBLY REQUIRED FROM ISLU TO DF. TWO WIRE - 64 PAIR CABLE (LG 04,05).			223C								
CONNECTORIZED SWBD CABLE ASSEMBLY REQUIRED FROM ISLU TO DF. TWO WIRE - 64 PAIR CABLE (LG 06,07).			223D								
CONNECTORIZED SWBD CABLE ASSEMBLY REQUIRED FROM ISLU TO DF. TWO WIRE - 128 PAIR CABLE (LG 12,13,14,15).			224A								
CONNECTORIZED SWBD CABLE ASSEMBLY REQUIRED FROM ISLU TO DF. TWO WIRE - 64 PAIR CABLE (LG 12,13).			224C								
CONNECTORIZED SWBD CABLE ASSEMBLY REQUIRED FROM ISLU TO DF. TWO WIRE - 64 PAIR CABLE (LG 14,15).			224D								
CONNECTORIZED SWBD CABLE ASSEMBLY REQUIRED FROM ISLU TO DF. FOUR WIRE OSPS SUB-LINE GROUP A (LC 16,18,20,22). (LG 00,01,02,03).			231A								
CONNECTORIZED SWBD CABLE ASSEMBLY REQUIRED FROM ISLU TO DF. FOUR WIRE OSPS SUB-LINE GROUP A (LC 16,18,20,22). (LG 08,09,10,11).			232A								
CONNECTORIZED SWBD CABLE ASSEMBLY REQUIRED FROM ISLU TO DF. FOUR WIRE OSPS SUB-LINE GROUP A (LC 16,18,20,22). (LG 04,05,06,07).			233A								
CONNECTORIZED SWBD CABLE ASSEMBLY REQUIRED FROM ISLU TO DF. FOUR WIRE OSPS SUB-LINE GROUP A (LC 16,18,20,22). (LG 12,13,14,15).			234A								
CONNECTORIZED SWBD CABLE ASSEMBLY REQUIRED FROM ISLU TO DF 4-WIRE OSPS (SUB-LINE GROUPS A,B,C,D) LG00-03.			235A								
CONNECTORIZED SWBD CABLE ASSEMBLY REQUIRED FROM ISLU TO DF 4-WIRE OSPS (SUB-LINE GROUPS A,B,C,D) LG08-11.			236A								
CONNECTORIZED SWBD CABLE ASSEMBLY REQUIRED FROM ISLU TO DF 4-WIRE OSPS (SUB-LINE GROUPS A,B,C,D) LG04-07.			237A								
CONNECTORIZED SWBD CABLE ASSEMBLY REQUIRED FROM ISLU TO DF 4-WIRE OSPS (SUB-LINE GROUPS A,B,C,D) LG12-15.			238A								
CONNECTORIZED SWBD CABLE ASSEMBLY REQUIRED FROM ISLU TO DF 4-WIRE OSPS (SUB-LINE GROUPS A,C) LG00-03.			241A								

TABLE-A CONTINUED

ED5D621-35

TABLE A-FEATURES (CONTINUED)											
EQUIPMENT		RAT-ING	LIST OR GROUP	EQUIPMENT OR CIRCUIT DATA					SD EQUIVALENT		
DESCRIPTION	REF NOTE			QTY	EQUIPMENT OR CIRCUIT	L/G OR FIG	WRG	APP	SCHEMATIC	FIG	OPT
CONNECTORIZED SWBD CABLE ASSEMBLY REQUIRED FROM ISLU TO DF 4-WIRE OSPS (SUB-LINE GROUPS A,C) LG08-11.			242A								
CONNECTORIZED SWBD CABLE ASSEMBLY REQUIRED FROM ISLU TO DF 4-WIRE OSPS (SUB-LINE GROUPS A,C) LG04-07.			243A								
CONNECTORIZED SWBD CABLE ASSEMBLY REQUIRED FROM ISLU TO DF 4-WIRE OSPS (SUB-LINE GROUPS A,C) LG12-15.			244A								
CONNECTORIZED SWBD CABLE ASSEMBLY REQUIRED FROM ISLU TO DF 4-WIRE OSPS (SUB-LINE GROUPS B,D) LG00-03.			245A								
CONNECTORIZED SWBD CABLE ASSEMBLY REQUIRED FROM ISLU TO DF 4-WIRE OSPS (SUB-LINE GROUPS B,D) LG08-11.			246A								
CONNECTORIZED SWBD CABLE ASSEMBLY REQUIRED FROM ISLU TO DF 4-WIRE OSPS (SUB-LINE GROUPS B,D) LG04-07.			247A								
CONNECTORIZED SWBD CABLE ASSEMBLY REQUIRED FROM ISLU TO DF 4-WIRE OSPS (SUB-LINE GROUPS B,D) LG12-15.			248A								
CONNECTORIZED SWBD CABLE ASSEMBLY REQUIRED FROM ISLU TO DF (SWC) 4-WIRE (LG00) USING 64 PAIR CABLE.			251A								
CONNECTORIZED SWBD CABLE ASSEMBLY REQUIRED FROM ISLU TO DF (SWC) 4-WIRE (LG01) USING 64 PAIR CABLE.			252A								
CONNECTORIZED SWBD CABLE ASSEMBLY REQUIRED FROM ISLU TO DF (SWC) 4-WIRE (LG02) USING 64 PAIR CABLE.			253A								
CONNECTORIZED SWBD CABLE ASSEMBLY REQUIRED FROM ISLU TO DF (SWC) 4-WIRE (LG03) USING 64 PAIR CABLE.			254A								
CONNECTORIZED SWBD CABLE ASSEMBLY REQUIRED FROM ISLU TO DF (SWC) 4-WIRE (LG04) USING 64 PAIR CABLE.			255A								
CONNECTORIZED SWBD CABLE ASSEMBLY REQUIRED FROM ISLU TO DF (SWC) 4-WIRE (LG05) USING 64 PAIR CABLE.			256A								
CONNECTORIZED SWBD CABLE ASSEMBLY REQUIRED FROM ISLU TO DF (SWC) 4-WIRE (LG06) USING 64 PAIR CABLE.			257A								

TABLE-A CONTINUED

SEE PROPRIETARY NOTICE ON SHEET ONE

XT13

5ESS (R) SWITCHING EQUIPMENT
CABLE ASSEMBLIES
FOR
INTEGRATED SERVICES DATA NETWORK

DWG SIZE
C2

ISSUE
53

LUCENT TECHNOLOGIES INC

ED5D621-35

SHEET A7
OF 141

TABLE A-FEATURES (CONTINUED)											
EQUIPMENT		EQUIPMENT OR CIRCUIT DATA							SD EQUIVALENT		
DESCRIPTION	REF NOTE	RAT-ING	LIST OR GROUP	QTY	EQUIPMENT OR CIRCUIT	L/G OR FIG	WRG	APP	SCHEMATIC	FIG	OPT
CONNECTORIZED SWBD CABLE ASSEMBLY REQUIRED FROM ISLU TO DF (SWC) 4-WIRE (LG07) USING 64 PAIR CABLE.			258A								
CONNECTORIZED SWBD CABLE ASSEMBLY REQUIRED FROM ISLU TO DF (SWC) 4-WIRE (LG08) USING 64 PAIR CABLE.			259A								
CONNECTORIZED SWBD CABLE ASSEMBLY REQUIRED FROM ISLU TO DF (SWC) 4-WIRE (LG09) USING 64 PAIR CABLE.			260A								
CONNECTORIZED SWBD CABLE ASSEMBLY REQUIRED FROM ISLU TO DF (SWC) 4-WIRE (LG10) USING 64 PAIR CABLE.			261A								
CONNECTORIZED SWBD CABLE ASSEMBLY REQUIRED FROM ISLU TO DF (SWC) 4-WIRE (LG11) USING 64 PAIR CABLE.			262A								
CONNECTORIZED SWBD CABLE ASSEMBLY REQUIRED FROM ISLU TO DF (SWC) 4-WIRE (LG12) USING 64 PAIR CABLE.			263A								
CONNECTORIZED SWBD CABLE ASSEMBLY REQUIRED FROM ISLU TO DF (SWC) 4-WIRE (LG13) USING 64 PAIR CABLE.			264A								
CONNECTORIZED SWBD CABLE ASSEMBLY REQUIRED FROM ISLU TO DF (SWC) 4-WIRE (LG14) USING 64 PAIR CABLE.			265A								
CONNECTORIZED SWBD CABLE ASSEMBLY REQUIRED FROM ISLU TO DF (SWC) 4-WIRE (LG15) USING 64 PAIR CABLE.			266A								
CONNECTORIZED CABLE ASSEMBLY REQUIRED FROM LAU LAN TO DF. E/W AMP TYPE CONNECTORS. DA EFF:11/30/96 FE/RA:NONE		DA	300								
CONNECTORIZED CABLE ASSEMBLY REQUIRED FROM LAU TO DF. E/W AMP TYPE CONNECTORS DA EFF:11/30/96 FE/RA:NONE		DA	301								
CONNECTORIZED SWBD CABLE ASSEMBLY REQUIRED FROM LAU INSTALLED IN RISLU (1-4) TO DF. E/W AMP TYPE CONNECTORS. DA EFF:11/30/96 FE/RA:NONE		DA	302								
CONNECTORIZED SWBD CABLE ASSEMBLY REQUIRED FOR LAU INSTALLED IN LTP (TA PACKS) TO DF. E/W AMP TYPE CONNECTORS. DA EFF:11/30/96 FE/RA:NONE		DA	303								
CONNECTORIZED SWBD CABLE ASSEMBLY REQUIRED FROM LAU TO DF. E/W AMP TYPE CONNECTORS. DA EFF:11/30/96 FE/RA:NONE		DA	304								
CONNECTORIZED SWBD CABLE ASSEMBLY REQUIRED FROM LAU TO DF. E/W AMP TYPE CONNECTORS. DA EFF:11/30/96 FE/RA:NONE		DA	304A								
CONNECTORIZED SWBD CABLE ASSEMBLY REQUIRED FROM LAU TO DF. E/W AMP TYPE CONNECTORS. DA EFF:11/30/96 FE/RA:NONE		DA	305								
TABLE-A CONTINUED											

TABLE A-FEATURES (CONTINUED)											
EQUIPMENT		EQUIPMENT OR CIRCUIT DATA							SD EQUIVALENT		
DESCRIPTION	REF NOTE	RAT-ING	LIST OR GROUP	QTY	EQUIPMENT OR CIRCUIT	L/G OR FIG	WRG	APP	SCHEMATIC	FIG	OPT
CONNECTORIZED SWBD CABLE ASSEMBLY REQUIRED FROM LAU TO DF. E/W AMP TYPE CONNECTORS. DA EFF:11/30/96 FE/RA:NONE		DA	306								
CONNECTORIZED SWBD CABLE ASSEMBLY FROM LAU TO DS TERMINAL (GANDALF 3309) ARRANGED FOR A SYNC OPERATION. (19.2K BPS). E/W AMP TYPE CONNECTORS. DA EFF:11/30/96 FE/RA:NONE		DA	307								
CONNECTORIZED SWBD CABLE ASSEMBLY FOR OSPS DS ALARMS FROM INVERTER TO DF. E/W AMP TYPE CONNECTORS. DA EFF:11/30/96 FE/RA:NONE		DA	308								
CONNECTORIZED SWBD CABLE ASSEMBLY FOR OSPS LTP ALARMS FROM FUSE/FILTER UNIT TO DF. E/W AMP TYPE CONNECTORS. DA EFF:11/30/96 FE/RA:NONE		DA	309								
CONNECTORIZED CABLE ASSEMBLY FROM BT F/F (J5D003BT-1) ALARM CKT IN RISLU TO A PWR PLANT. (ALARM BAT CABLE) E/W AMP TYPE CONNECTORS. DA EFF:11/30/96 FE/RA:NONE		DA	310								
CONNECTORIZED CABLE ASSEMBLY FROM F/F (J5D003FM-1) ALM CKT WITHIN RUB CAB TO A PWR PLANT. (ALARM BAT CABLE) E/W AMP TYPE CONNECTORS. DA EFF:11/30/96 FE/RA:NONE		DA	311								
CONNECTORIZED CABLE ASSEMBLY FROM DLTU-R WITHIN RUB CAB E/W FMMFU (J5D003FJ-1). FOR ALM CKT FROM RUB CAB TO A PWR PLANT. (ALARM BAT CABLE) E/W AMP TYPE CONNECTORS. DA EFF:11/30/96 FE/RA:NONE		DA	312								
CONNECTORIZED SWBD CABLE ASSEMBLY REQUIRED FOR LAU (J5D003FG) CONNECTED TO A DF (SWC). PBX APPL ONLY. E/W AMP TYPE CONNECTORS. DA EFF:11/30/96 FE/RA:NONE		DA	313								
CONNECTORIZED SWBD CABLE ASSEMBLY REQUIRED FROM 1ST ISLU MOUNTED IN A SM() TO DF (SWC). 4-WIRE; LG00,01 PBX APPL ONLY.			501A								
CONNECTORIZED SWBD CABLE ASSEMBLY REQUIRED FROM 1ST ISLU MOUNTED IN A SM() TO DF (SWC). 4-WIRE; LG08,09 PBX APPL ONLY.			502A								
TABLE-A CONTINUED											

SEE PROPRIETARY NOTICE ON SHEET ONE	
XT13	
5ESS (R) SWITCHING EQUIPMENT CABLE ASSEMBLIES FOR INTEGRATED SERVICES DATA NETWORK	
DWG SIZE C2	ISSUE 53
LUCENT TECHNOLOGIES INC	ED5D621-35
SHEET A8 OF 141	

TABLE A-FEATURES (CONTINUED)											
EQUIPMENT		EQUIPMENT OR CIRCUIT DATA							SD EQUIVALENT		
DESCRIPTION	REF NOTE	RAT-ING	LIST OR GROUP	QTY	EQUIPMENT OR CIRCUIT	L/G OR FIG	WRG	APP	SCHEMATIC	FIG	OPT
CONNECTORIZED SWBD CABLE ASSEMBLY REQUIRED FROM 1ST ISLU MOUNTED IN A SM() TO DF (SWC). 4-WIRE; LG02,03 PBX APPL ONLY.			503A								
CONNECTORIZED SWBD CABLE ASSEMBLY REQUIRED FROM 1ST ISLU MOUNTED IN A SM() TO DF (SWC). 4-WIRE; LG10,11 PBX APPL ONLY.			504A								
CONNECTORIZED SWBD CABLE ASSEMBLY REQUIRED FROM 1ST ISLU MOUNTED IN A SM() TO DF (SWC). 4-WIRE; LG04,05 PBX APPL ONLY.			505A								
CONNECTORIZED SWBD CABLE ASSEMBLY REQUIRED FROM 1ST ISLU MOUNTED IN A SM() TO DF (SWC). 4-WIRE; LG12,13 PBX APPL ONLY.			506A								
CONNECTORIZED SWBD CABLE ASSEMBLY REQUIRED FROM 1ST ISLU MOUNTED IN A SM() TO DF (SWC). 4-WIRE; LG06,07 PBX APPL ONLY.			507A								
CONNECTORIZED SWBD CABLE ASSEMBLY REQUIRED FROM 1ST ISLU MOUNTED IN A SM() TO DF (SWC). 4-WIRE; LG14,15 PBX APPL ONLY.			508A								
CONNECTORIZED SWBD CABLE ASSEMBLY REQUIRED FROM ISLU MOUNTED IN A RISLU() TO DF (SWC). 4-WIRE; LG00,01 PBX APPL ONLY.			511A								
CONNECTORIZED SWBD CABLE ASSEMBLY REQUIRED FROM ISLU MOUNTED IN A RISLU() TO DF (SWC). 4-WIRE; LG08,09 PBX APPL ONLY.			512A								
CONNECTORIZED SWBD CABLE ASSEMBLY REQUIRED FROM ISLU MOUNTED IN A RISLU() TO DF (SWC). 4-WIRE; LG02,03 PBX APPL ONLY.			513A								
CONNECTORIZED SWBD CABLE ASSEMBLY REQUIRED FROM ISLU MOUNTED IN A RISLU() TO DF (SWC). 4-WIRE; LG10,11 PBX APPL ONLY.			514A								
CONNECTORIZED SWBD CABLE ASSEMBLY REQUIRED FROM ISLU MOUNTED IN A RISLU() TO DF (SWC). 4-WIRE; LG04,05 PBX APPL ONLY.			515A								
CONNECTORIZED SWBD CABLE ASSEMBLY REQUIRED FROM ISLU MOUNTED IN A RISLU() TO DF (SWC). 4-WIRE; LG12,13 PBX ONLY.			516A								
CONNECTORIZED SWBD CABLE ASSEMBLY REQUIRED FROM ISLU MOUNTED IN A RISLU() TO DF (SWC). 4-WIRE; LG06,07 PBX APPL ONLY.			517A								
CONNECTORIZED SWBD CABLE ASSEMBLY REQUIRED FROM ISLU MOUNTED IN A RISLU() TO DF (SWC). 4-WIRE; LG14,15 PBX APPL ONLY.			518A								
CONNECTORIZED SWBD CABLE ASSEMBLY REQUIRED FROM 1ST ISLU MOUNTED IN A SM() TO DF (SWC). 2-WIRE; LG00-03 PBX APPL ONLY.			521A								
CONNECTORIZED SWBD CABLE ASSEMBLY REQUIRED FROM 1ST ISLU MOUNTED IN A SM() TO DF (SWC). 2-WIRE; LG08-11 PBX APPL ONLY.			522A								
CONNECTORIZED SWBD CABLE ASSEMBLY REQUIRED FROM 1ST ISLU MOUNTED IN A SM() TO DF (SWC). 2-WIRE; LG04-07 PBX APPL ONLY.			523A								

TABLE-A CONTINUED

ED5D621-35

TABLE A-FEATURES (CONTINUED)											
EQUIPMENT		EQUIPMENT OR CIRCUIT DATA							SD EQUIVALENT		
DESCRIPTION	REF NOTE	RAT-ING	LIST OR GROUP	QTY	EQUIPMENT OR CIRCUIT	L/G OR FIG	WRG	APP	SCHEMATIC	FIG	OPT
CONNECTORIZED SWBD CABLE ASSEMBLY REQUIRED FROM 1ST ISLU MOUNTED IN A SM() TO DF (SWC). 2-WIRE; LG12-15 PBX APPL ONLY.			524A								
CONNECTORIZED SWBD CABLE ASSEMBLY REQUIRED FROM ISLU MOUNTED IN A RISLU() TO DF (SWC). 2-WIRE; LG00-03 PBX APPL ONLY.			531A								
CONNECTORIZED SWBD CABLE ASSEMBLY REQUIRED FORM ISLU MOUNTED IN A RISLU() TO DF (SWC). 2-WIRE; LG08-11 PBX APPL ONLY.			532A								
CONNECTORIZED SWBD CABLE ASSEMBLY REQUIRED FROM ISLU MOUNTED IN A RISLU() TO DF (SWC). 2-WIRE; LG04-07 PBX APPL ONLY.			533A								
CONNECTORIZED SWBD CABLE ASSEMBLY REQUIRED FROM ISLU MOUNTED IN A RISLU() TO DF (SWC). 2-WIRE; LG12-15 PBX APPL ONLY.			534A								
CONNECTORIZED SWBD CABLE ASSEMBLY REQUIRED FROM ISLU MOUNTED IN A RISLU/OSPS TO DF (SWC). 4-WIRE; LG00-03 PBX APPL ONLY. SUB-LINE GROUP A (LC 16, 18,20,22).			541A								
CONNECTORIZED SWBD CABLE ASSEMBLY REQUIRED FROM ISLU MOUNTED IN A RISLU/OSPS TO DF (SWC). 4-WIRE; LG08-11 PBX APPL ONLY. SUB-LINE GROUP A (LC 16, 18,20,22).			542A								
CONNECTORIZED SWBD CABLE ASSEMBLY REQUIRED FROM ISLU MOUNTED IN A RISLU/OSPS TO DF (SWC). 4-WIRE; LG04-07 PBX APPL ONLY. SUB-LINE GROUP A (LC 16, 18,20,22).			543A								
CONNECTORIZED SWBD CABLE ASSEMBLY REQUIRED FROM ISLU MOUNTED IN A RISLU/OSPS TO DF (SWC). 4-WIRE; LG12-15 PBX APPL ONLY. SUB-LINE GROUP A (LC 16, 18,20,22).			544A								
CONNECTORIZED SWBD CABLE ASSEMBLY REQUIRED FROM ISLU TO DF 4-WIRE OSPS (SUB-LINE GROUPS A,B,C,D) LG00-03 PBX APPL ONLY.			545A								
CONNECTORIZED SWBD CABLE ASSEMBLY REQUIRED FROM ISLU TO DF 4-WIRE OSPS (SUB-LINE GROUPS A,B,C,D) LG08-11 PBX APPL ONLY.			546A								
CONNECTORIZED SWBD CABLE ASSEMBLY REQUIRED FROM ISLU TO DF 4-WIRE OSPS (SUB-LINE GROUPS A,B,C,D) LG04-07 PBX APPL ONLY.			547A								

TABLE-A CONTINUED

SEE PROPRIETARY NOTICE ON SHEET ONE	
XT13	
5ESS (R) SWITCHING EQUIPMENT CABLE ASSEMBLIES FOR INTEGRATED SERVICES DATA NETWORK	
DWG SIZE C2	ISSUE 53
LUCENT TECHNOLOGIES INC	ED5D621-35
SHEET OF	A9 141

TABLE A-FEATURES (CONTINUED)											
EQUIPMENT		EQUIPMENT OR CIRCUIT DATA							SD EQUIVALENT		
DESCRIPTION	REF NOTE	RAT-ING	LIST OR GROUP	QTY	EQUIPMENT OR CIRCUIT	L/G OR FIG	WRG	APP	SCHEMATIC	FIG	OPT
CONNECTORIZED SWBD CABLE ASSEMBLY REQUIRED FROM ISLU TO DF 4-WIRE OSPS (SUB-LINE GROUPS A,B,C,D) LG12-15 PBX APPL ONLY.			548A								
CONNECTORIZED SWBD CABLE ASSEMBLY REQUIRED FROM 2ND ISLU MOUNTED IN A SM() TO DF (SWC). 4-WIRE; LG00,01 PBX APPL ONLY.			551A								
CONNECTORIZED SWBD CABLE ASSEMBLY REQUIRED FROM 2ND ISLU MOUNTED IN A SM() TO DF (SWC). 4-WIRE; LG08,09 PBX APPL ONLY.			552A								
CONNECTORIZED SWBD CABLE ASSEMBLY REQUIRED FROM 2ND ISLU MOUNTED IN A SM() TO DF (SWC). 4-WIRE; LG02,03 PBX APPL ONLY.			553A								
CONNECTORIZED SWBD CABLE ASSEMBLY REQUIRED FROM 2ND ISLU MOUNTED IN A SM() TO DF (SWC). 4-WIRE; LG10,11 PBX APPL ONLY.			554A								
CONNECTORIZED SWBD CABLE ASSEMBLY REQUIRED FROM 2ND ISLU MOUNTED IN A SM() TO DF (SWC). 4-WIRE; LG04,05 PBX APPL ONLY.			555A								
CONNECTORIZED SWBD CABLE ASSEMBLY REQUIRED FROM 2ND ISLU MOUNTED IN A SM() TO DF (SWC). 4-WIRE; LG12,13 PBX APPL ONLY.			556A								
CONNECTORIZED SWBD CABLE ASSEMBLY REQUIRED FROM 2ND ISLU MOUNTED IN A SM() TO DF (SWC). 4-WIRE; LG06,07 PBX APPL ONLY.			557A								
CONNECTORIZED SWBD CABLE ASSEMBLY REQUIRED FROM 2ND ISLU MOUNTED IN A SM() TO DF (SWC). 4-WIRE; LG14,15 PBX APPL ONLY.			558A								
CONNECTORIZED SWBD CABLE ASSEMBLY REQUIRED FROM 2ND ISLU MOUNTED IN A SM() TO DF (SWC). 2-WIRE; LG00-03 PBX APPL ONLY.			561A								
CONNECTORIZED SWBD CABLE ASSEMBLY REQUIRED FROM 2ND ISLU MOUNTED IN A SM() TO DF (SWC). 2-WIRE; LG08-11 PBX APPL ONLY.			562A								
CONNECTORIZED SWBD CABLE ASSEMBLY REQUIRED FROM 2ND ISLU MOUNTED IN A SM() TO DF (SWC). 2-WIRE; LG04-07 PBX APPL ONLY.			563A								
CONNECTORIZED SWBD CABLE ASSEMBLY REQUIRED FROM 2ND ISLU MOUNTED IN A SM() TO DF (SWC). 2-WIRE; LG12-15 PBX APPL ONLY.			564A								
CONNECTORIZED SWBD CABLE ASSEMBLY REQUIRED FOR DLTU-R (INPUT). MTG POS 1. PBX APPL ONLY.			601								
CONNECTORIZED SWBD CABLE ASSEMBLY REQUIRED FOR DLTU-R (OUTPUT). MTG POS 1. PBX APPL ONLY.			603								
CONNECTORIZED SWBD CABLE ASSEMBLY REQUIRED FOR DLTU-R (INPUT). MTG POS 2. PBX APPL ONLY.			605								
CONNECTORIZED SWBD CABLE ASSEMBLY REQUIRED FOR DLTU-R (OUTPUT). MTG POS 2. PBX APPL ONLY.			607								
CONNECTORIZED SWBD CABLE ASSEMBLY REQUIRED FOR DLTU-R (INPUT). MTG POS 3. PBX APPL ONLY.			609								
TABLE-A CONTINUED											

ED5D621-35

TABLE A-FEATURES (CONTINUED)											
EQUIPMENT		EQUIPMENT OR CIRCUIT DATA							SD EQUIVALENT		
DESCRIPTION	REF NOTE	RAT-ING	LIST OR GROUP	QTY	EQUIPMENT OR CIRCUIT	L/G OR FIG	WRG	APP	SCHEMATIC	FIG	OPT
CONNECTORIZED SWBD CABLE ASSEMBLY REQUIRED FOR DLTU-R (OUTPUT). MTG POS 3. PBX APPL ONLY.			611								
CONNECTORIZED SWBD CABLE ASSEMBLY REQUIRED FOR DLTU-R (INPUT). MTG POS 4. PBX APPL ONLY.			613								
CONNECTORIZED SWBD CABLE ASSEMBLY REQUIRED FOR DLTU-R (OUTPUT). MTG POS 4. PBX APPL ONLY.			615								
CONNECTORIZED SWBD CABLE ASSEMBLY REQUIRED FOR DLTU-R (INPUT). MTG POS 5. PBX APPL ONLY.			617								
CONNECTORIZED SWBD CABLE ASSEMBLY REQUIRED FOR DLTU-R (OUTPUT). MTG POS 5. PBX APPL ONLY.			619								
CONNECTORIZED SWBD CABLE ASSEMBLY REQUIRED FOR DLTU-R (INPUT). MTG POS 6. PBX APPL ONLY.			621								
CONNECTORIZED SWBD CABLE ASSEMBLY REQUIRED FOR DLTU-R (OUTPUT). MTG POS 6. PBX APPL ONLY.			623								
CONNECTORIZED SWBD CABLE ASSEMBLY REQUIRED FOR OSPS INTERNATIONAL. RS232 INTERFACE CABLE FROM THE DII9A TO THE CONVERTER. (50FT MAX)			650								
CONNECTORIZED SWBD CABLE ASSEMBLY REQUIRED FOR OSPS INTERNATIONAL RS422 INTERFACE CABLE FROM THE CONVERTER TO THE BT-AVR. (4000FT MAX)			651								
CONNECTORIZED SWBD CABLE ASSEMBLY REQUIRED FOR OSPS INTERNATIONAL. RS232 INTERFACE CABLE FROM THE 7B D2 TO THE CONVERTER. (50FT MAX)			652								
CONNECTORIZED SWBD CABLE ASSEMBLY REQUIRED FOR OSPS INTERNATIONAL RS422 INTERFACE CABLE FROM THE CONVERTER TO THE SUN HSI CARD. (4000FT MAX)			653								
CONNECTORIZED SWBD CABLE ASSEMBLY REQUIRED FOR LAU (J5D003FG) CONNECTED TO A DF (SWC). PBX APPL ONLY. E/W T-TYPE CONNECTORS.			701								
TABLE-A CONTINUED											

SEE PROPRIETARY NOTICE ON SHEET ONE	
XT13	
5ESS (R) SWITCHING EQUIPMENT CABLE ASSEMBLIES FOR INTEGRATED SERVICES DATA NETWORK	
DWG SIZE C2	ISSUE 53
LUCENT TECHNOLOGIES INC	ED5D621-35
SHEET OF	A10 141

TABLE A-FEATURES (CONTINUED)

EQUIPMENT		REF NOTE	RAT-ING	LIST OR GROUP	EQUIPMENT OR CIRCUIT DATA				SD EQUIVALENT		
DESCRIPTION	QTY				EQUIPMENT OR CIRCUIT	L/G OR FIG	WRG	APP	SCHEMATIC	FIG	OPT
CONNECTORIZED SWBD CABLE ASSEMBLY REQUIRED FROM ISLU TO DF. (4-WIRES) (LG 00).				901A							
CONNECTORIZED SWBD CABLE ASSEMBLY REQUIRED FROM ISLU TO DF. (4-WIRES) (LG 00).				901B							
CONNECTORIZED SWBD CABLE ASSEMBLY REQUIRED FROM ISLU TO DF. (4-WIRES) (LG 01).				901C							
CONNECTORIZED SWBD CABLE ASSEMBLY REQUIRED FROM ISLU TO DF. (4-WIRES) (LG 01).				901D							
CONNECTORIZED SWBD CABLE ASSEMBLY REQUIRED FROM ISLU TO DF. (4-WIRES) (LG 08).				902A							
CONNECTORIZED SWBD CABLE ASSEMBLY REQUIRED FROM ISLU TO DF. (4-WIRES) (LG 08).				902B							
CONNECTORIZED SWBD CABLE ASSEMBLY REQUIRED FROM ISLU TO DF. (4-WIRES) (LG 09).				902C							
CONNECTORIZED SWBD CABLE ASSEMBLY REQUIRED FROM ISLU TO DF. (4-WIRES) (LG 09).				902D							
CONNECTORIZED SWBD CABLE ASSEMBLY REQUIRED FROM ISLU TO DF. (4-WIRES) (LG 02).				903A							
CONNECTORIZED SWBD CABLE ASSEMBLY REQUIRED FROM ISLU TO DF. (4-WIRES) (LG 02).				903B							
CONNECTORIZED SWBD CABLE ASSEMBLY REQUIRED FROM ISLU TO DF. (4-WIRES) (LG 03).				903C							
CONNECTORIZED SWBD CABLE ASSEMBLY REQUIRED FROM ISLU TO DF. (4-WIRES) (LG 03).				903D							
CONNECTORIZED SWBD CABLE ASSEMBLY REQUIRED FROM ISLU TO DF. (4-WIRES) (LG 10).				904A							
CONNECTORIZED SWBD CABLE ASSEMBLY REQUIRED FROM ISLU TO DF. (4-WIRES) (LG 10).				904B							
CONNECTORIZED SWBD CABLE ASSEMBLY REQUIRED FROM ISLU TO DF. (4-WIRES) (LG 11).				904C							
CONNECTORIZED SWBD CABLE ASSEMBLY REQUIRED FROM ISLU TO DF. (4-WIRES) (LG 11).				904D							
CONNECTORIZED SWBD CABLE ASSEMBLY REQUIRED FROM ISLU TO DF. (4-WIRES) (LG 04).				905A							
CONNECTORIZED SWBD CABLE ASSEMBLY REQUIRED FROM ISLU TO DF. (4-WIRES) (LG 04).				905B							
CONNECTORIZED SWBD CABLE ASSEMBLY REQUIRED FROM ISLU TO DF. (4-WIRES) (LG 05).				905C							
CONNECTORIZED SWBD CABLE ASSEMBLY REQUIRED FROM ISLU TO DF. (4-WIRES) (LG 05).				905D							
CONNECTORIZED SWBD CABLE ASSEMBLY REQUIRED FROM ISLU TO DF. (4-WIRES) (LG 12).				906A							
CONNECTORIZED SWBD CABLE ASSEMBLY REQUIRED FROM ISLU TO DF. (4-WIRES) (LG 12).				906B							
CONNECTORIZED SWBD CABLE ASSEMBLY REQUIRED FROM ISLU TO DF. (4-WIRES) (LG 13).				906C							

TABLE-A CONTINUED

ED5D621-35

TABLE A-FEATURES (CONTINUED)

EQUIPMENT		REF NOTE	RAT-ING	LIST OR GROUP	EQUIPMENT OR CIRCUIT DATA				SD EQUIVALENT		
DESCRIPTION	QTY				EQUIPMENT OR CIRCUIT	L/G OR FIG	WRG	APP	SCHEMATIC	FIG	OPT
CONNECTORIZED SWBD CABLE ASSEMBLY REQUIRED FROM ISLU TO DF. (4-WIRES) (LG 13).				906D							
CONNECTORIZED SWBD CABLE ASSEMBLY REQUIRED FROM ISLU TO DF. (4-WIRES) (LG 06).				907A							
CONNECTORIZED SWBD CABLE ASSEMBLY REQUIRED FROM ISLU TO DF. (4-WIRES) (LG 06).				907B							
CONNECTORIZED SWBD CABLE ASSEMBLY REQUIRED FROM ISLU TO DF. (4-WIRES) (LG 07).				907C							
CONNECTORIZED SWBD CABLE ASSEMBLY REQUIRED FROM ISLU TO DF. (4-WIRES) (LG 07).				907D							
CONNECTORIZED SWBD CABLE ASSEMBLY REQUIRED FROM ISLU TO DF. (4-WIRES) (LG 14).				908A							
CONNECTORIZED SWBD CABLE ASSEMBLY REQUIRED FROM ISLU TO DF. (4-WIRES) (LG 14).				908B							
CONNECTORIZED SWBD CABLE ASSEMBLY REQUIRED FROM ISLU TO DF. (4-WIRES) (LG 15).				908C							
CONNECTORIZED SWBD CABLE ASSEMBLY REQUIRED FROM ISLU TO DF. (4-WIRES) (LG 15).				908D							

END OF TABLE-A

SEE PROPRIETARY NOTICE ON SHEET ONE

XT13

5ESS (R) SWITCHING EQUIPMENT
CABLE ASSEMBLIES
FOR
INTEGRATED SERVICES DATA NETWORK

DWG SIZE C2 ISSUE 53

LUCENT TECHNOLOGIES INC ED5D621-35


SHEET 111 OF 141




THE "A" DIM IS THE LENGTH OF SWBD CABLE FRONT OF CONN TO FRONT OF CONN.
THE "D" AND "E" DIM ARE THE DIM FROM BUTT OF CABLE TO THE FRONT OF CONN.

SK.A
(SEE TABLE S)

GROUP	CABLE CODE	CABLE DESIG	"A" DIM	LENGTH FROM CABLE BUTT TO FRONT OF CONN				SK
				"D" DIM		"E" DIM		
				CM	FT-IN	CM	FT-IN	
1	608C	JX1	X DIM	17.1 [6 3/4]				A
1A	1249016A	JX1A	X DIM	17.1 [6 3/4]				
3	608C	JX3	X DIM	17.1 [6 3/4]				
3A	1249016A	JX3A	X DIM	17.1 [6 3/4]				
5	752A	JX5	X DIM	13.3 [5 1/4]		121.9 [4-0] & FIG.A1		
7	752A	JX7	X DIM	13.3 [5 1/4]		121.9 [4-0] & FIG.A1		
9	758A	JX9	X DIM	17.1 [6 3/4]		121.9 [4-0] & FIG.A1		
11	752A	JX11	X DIM	13.3 [5 1/4]		121.9 [4-0] & FIG.A1		
13	752A	JX13	X DIM	13.3 [5 1/4]		121.9 [4-0] & FIG.A1		
15	758A	JX15	X DIM	17.1 [6 3/4]		121.9 [4-0] & FIG.A1		
101	800A	JX101	X DIM	15.2 [6]				A
103	800A	JX103	X DIM	15.2 [6]				
105	808A	JX105	X DIM	66.0 [2-2]				
105A	808A	JX105A	X DIM	66.0 [2-2]				
109	801A	JX109	X DIM	11.4 [4 1/2]				
111	801A	JX111	X DIM	15.2 [6]				
113	801A	JX113	X DIM	11.4 [4 1/2]				
115	801A	JX115	X DIM	15.2 [6]				

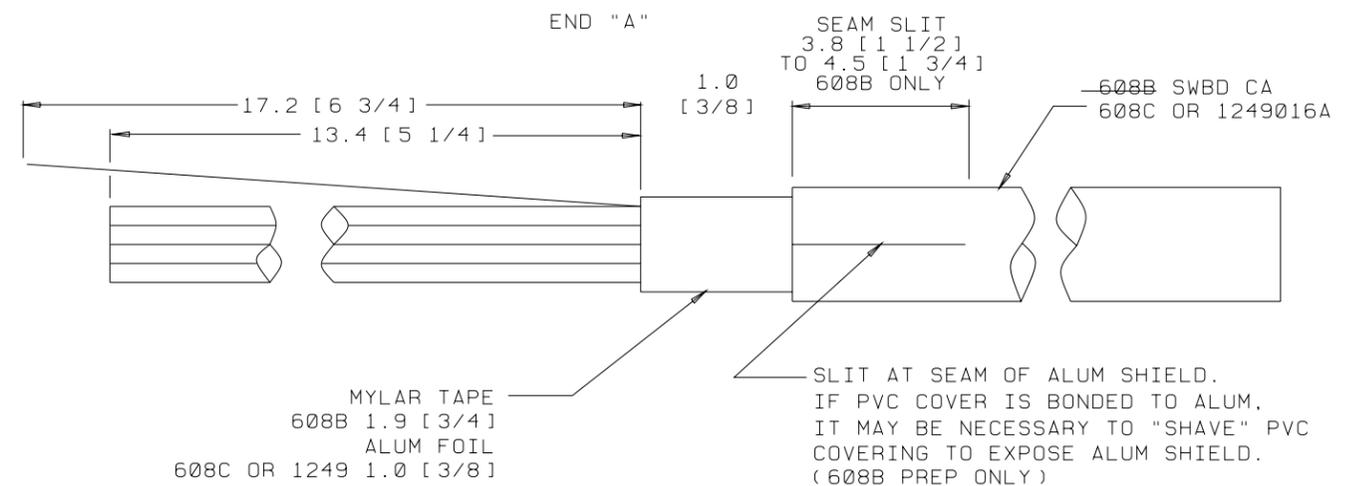

GROUP 1.3.1A.3A
FIG.A

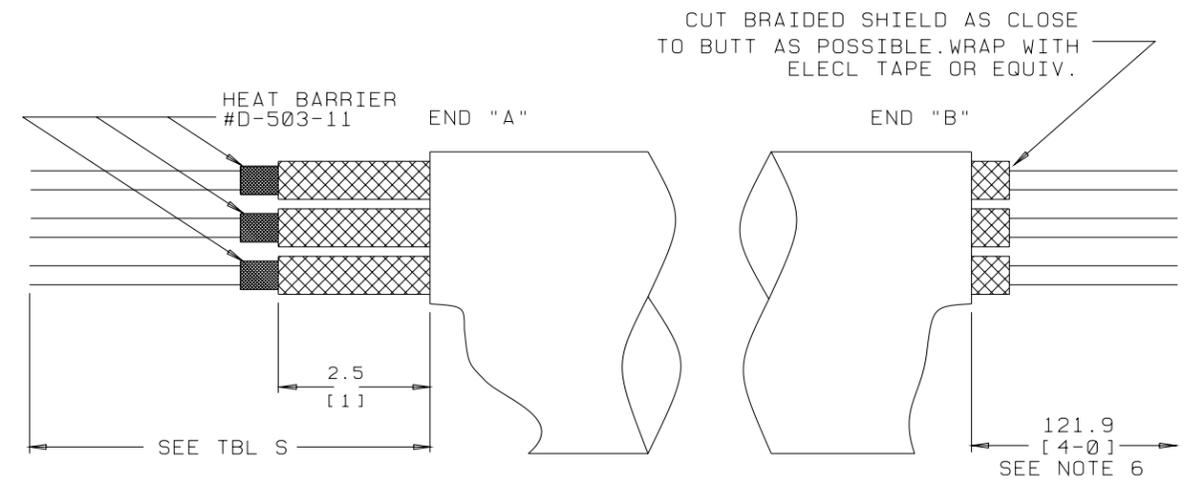

GROUP 5 THRU 15
PREPARATION OF 752A & 758A CABLE
FIG.A1

USE AMP #46121-N TOOL
W/26-22GA DIE OR
EQUIVALENT FOR CRIMP

SEE PROPRIETARY NOTICE ON SHEET ONE

CONNECTORIZED SWITCHBOARD
CABLE ASSEMBLIES

DWG SIZE
c2

ISSUE
49

LUCENT
TECHNOLOGIES INC.

ED5D621-35


SHEET
B1



THE "A" DIM IS THE LENGTH OF SWBD CABLE FRONT OF CONN TO FRONT OF CONN.
 THE "D" AND "E" DIM ARE THE DIM FROM BUTT OF CABLE TO THE FRONT OF CONN.

SK.A
 (SEE TABLE S)

GROUP	CABLE CODE	CABLE DESIG	"A" DIM	LENGTH FROM CABLE BUTT TO FRONT OF CONN				SK
				"D" DIM		"E" DIM		
				CM	FT-IN	CM	FT-IN	
129A	812A	JX129A	X DIM		7.6 [3"] & FIG.A2	7.6 [3"] & FIG.A2	A	
135	812A	JX135			5.1 [2]			
141	812A	JX141			5.1 [2]			
142	812A	JX142			5.1 [2]			
601	608B	JX601	X DIM		13.3 [5 1/4]			
603		JX603						
605		JX605						
607		JX607						
609		JX609						
611		JX611						
613		JX613						
615		JX615						
617		JX617						
619		JX619						
621		JX621						
623		JX623						

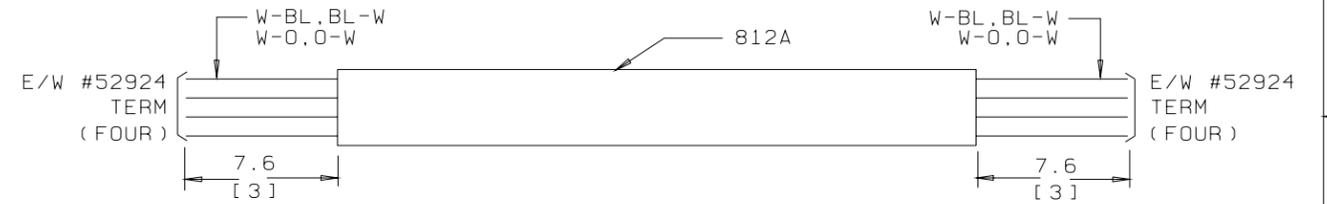

USE AMP #46121-N TOOL
 W/26-22GA DIE OR
 EQUIVALENT FOR CRIMP

SEE PROPRIETARY NOTICE ON SHEET ONE		
CONNECTORIZED SWITCHBOARD CABLE ASSEMBLIES		DWG SIZE C2
LUCENT TECHNOLOGIES INC.		ISSUE 49
ED5D621-35		SHEET B2



THE "A" DIM IS THE LENGTH OF SWBD CABLE FRONT OF CONN TO FRONT OF CONN.
 THE "D" AND "E" DIM ARE THE DIM FROM BUTT OF CABLE TO THE FRONT OF CONN.

SK.A
 (SEE TABLE S)

TABLE S								
GROUP	CABLE CODE	CABLE DESIG	"A" DIM	LENGTH FROM CABLE BUTT TO FRONT OF CONN				
				"D" DIM		"E" DIM		SK
				CM	FT-IN	CM	FT-IN	
211A	810A	JX211A	X DIM	62.2 [2-1/2]				A
212A		JX212A	X DIM	83.8 [2-9]				
213A		JX213A	X DIM	71.1 [2-4]				
214A		JX214A	X DIM	74.9 [2-5 1/2]				
215A		JX215A	X DIM	82.6 [2-8 1/2]				
216A		JX216A	X DIM	63.5 [2-1]				
217A		JX217A	X DIM	91.4 [3-0]				
218A		JX218A	X DIM	54.6 [1-9 1/2]				
221A	810A	JX221A	X DIM	69.9 [2-3 1/2]				
222A		JX222A	X DIM	82.6 [2-8 1/2]				
223A		JX223A	X DIM	85.1 [2-9 1/2]				
224A		JX224A	X DIM	62.2 [2-0 1/2]				
221C	809A	JX221C	X DIM	62.2 [2-0 1/2]				
221D		JX221D	X DIM	69.9 [2-3 1/2]				
223C		JX223C	X DIM	82.6 [2-8 1/2]				
223D		JX223D	X DIM	90.2 [2-11 1/2]				
222C		JX222C	X DIM	82.6 [2-8 1/2]				

(SEE TABLE S)

TABLE S								
GROUP	CABLE CODE	CABLE DESIG	"A" DIM	LENGTH FROM CABLE BUTT TO FRONT OF CONN				
				"D" DIM		"E" DIM		SK
				CM	FT-IN	CM	FT-IN	
222D	809A	JX222D	X DIM	74.9 [2-5 1/2]				A
224C		JX224C	X DIM	62.2 [2-0 1/2]				
224D		JX224D	X DIM	54.6 [1-9 1/2]				
231A	808A	JX231A	X DIM	71.1 [2-4]				
232A		JX232A	X DIM	83.8 [2-9]				
233A		JX233A	X DIM	91.4 [3-0]				
234A		JX234A	X DIM	68.6 [2-3]				
235A	810A	JX235A	X DIM	64.8 [2-1 1/2]				
236A		JX236A	X DIM	78.7 [2-7]				
237A		JX237A	X DIM	85.1 [2-9 1/2]				
238A		JX238A	X DIM	58.4 [1-11]				

SEE PROPRIETARY NOTICE ON SHEET ONE

CONNECTORIZED SWITCHBOARD
 CABLE ASSEMBLIES

DWG SIZE
 C2

ISSUE
 49

LUCENT
 TECHNOLOGIES INC.

ED5D621-35


SHEET
 B3




THE "A" DIM IS THE LENGTH OF SWBD CABLE FRONT OF CONN TO FRONT OF CONN.
 THE "D" AND "E" DIM ARE THE DIM FROM BUTT OF CABLE TO THE FRONT OF CONN.

SK.A
 (SEE TABLE S)

GROUP	CABLE CODE	CABLE DESIG	"A" DIM	LENGTH FROM CABLE BUTT TO FRONT OF CONN				
				"D" DIM		"E" DIM		SK
				CM	FT-IN	CM	FT-IN	
17	KS19224 L1	JX17	X DIM	1.0 [3/8]	1.0 [3/8]	A		
17A	735A	JX17A	X DIM	1.6 [5/8]	1.6 [5/8]	A		
19	KS19224 L1	JX19	X DIM	1.0 [3/8]	1.0 [3/8]	A		
19A	735A	JX19A	X DIM	1.6 [5/8]	1.6 [5/8]	A		
219N	285A	JX219N	X DIM	55.0 [1-9 3/4]	72.5 [2-4 1/2]	A		
220N	285A	JX220N	X DIM	55.0 [1-9 3/4]	72.5 [2-4 1/2]	A		
650	812A		X DIM	25.4 [10]	25.4 [10]	A		
651	812A		X DIM	25.4 [10]	25.4 [10]	A		
652	812A		X DIM	7.0 [2 3/4]	7.0 [2 3/4]	A		
653	811A		X DIM	7.0 [2 3/4]	7.0 [2 3/4]	A		

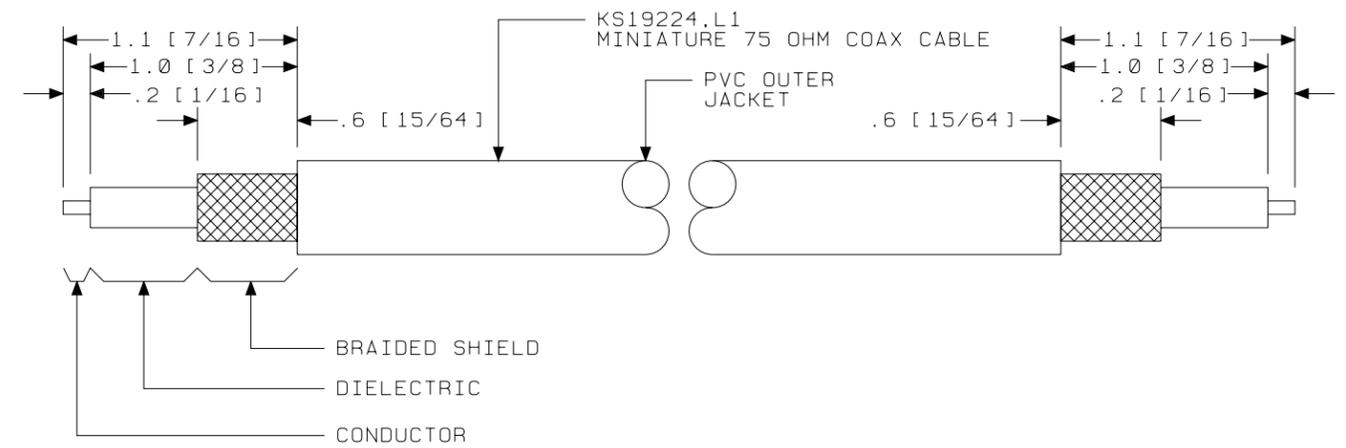

PREPARATION OF KS19224.L1 COAX CABLE
 GROUPS 17,19
 FIG. B

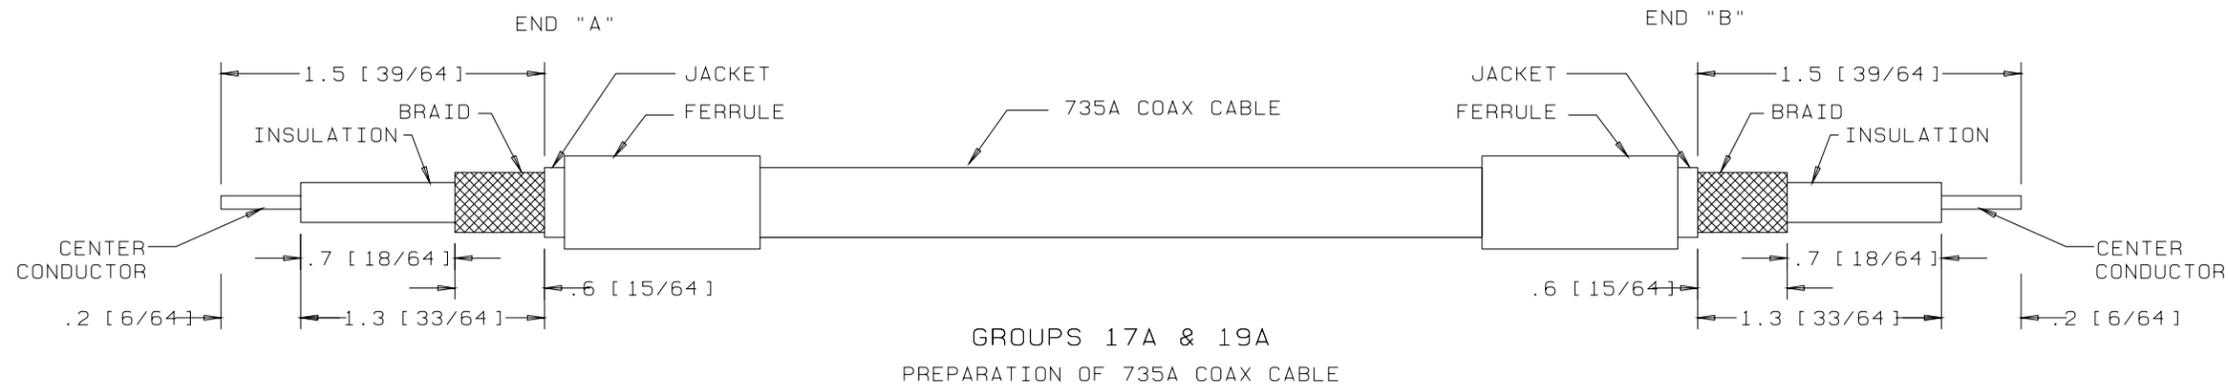


SEE PROPRIETARY NOTICE ON SHEET ONE		
CONNECTORIZED SWITCHBOARD CABLE ASSEMBLIES	DWG SIZE	ISSUE
	c2	49
LUCENT TECHNOLOGIES INC.	ED5D621-35	SHEET B5



THE "A" DIM IS THE LENGTH OF SWBD CABLE FRONT OF CONN TO FRONT OF CONN.
 THE "D" AND "E" DIM ARE THE DIM FROM BUTT OF CABLE TO THE FRONT OF CONN.

SK.A
 (SEE TABLE S)

GROUP	CABLE CODE	CABLE DESIG	"A" DIM	LENGTH FROM CABLE BUTT TO FRONT OF CONN					
				NT	"D" DIM		"E" DIM		SK
					CM	FT-IN	CM	FT-IN	
65A	812A	JX65A	X DIM		3.2 [1 1/4]	3.2 [1 1/4]	A		
65B		JX65B							
65C		JX65C							
65D		JX65D							
65E		JX65E							
122	812A	JX122	X DIM		12.7 [5]	15.2 [6]	A		
122A		JX122A	X DIM		12.7 [5]	15.2 [6]			
122B		JX122B	X DIM		12.7 [5]	15.2 [6]			
123		JX123	X DIM		12.7 [5]	3.2 [1 1/4]			
123A		JX123A	X DIM		25.4 [10]	15.2 [6]			
123B		JX123B	X DIM		25.4 [10]	15.2 [6]			
124	1024002	JX124	213.4 [7-0]		7.0 [2 3/4]	5.7 [2 1/4]			
124B	1024002	JX124B	213.4 [7-0]		7.0 [2 3/4]	5.7 [2 1/4]			
126	812A	JX126	X DIM		61.0 [2-0]		A		
127		JX127	X DIM		17.8 [7]				
127A		JX127A	X DIM		14.0 [5 1/2]				
128	19354	JX128	365.8 [12-0]		2.5 [1]				

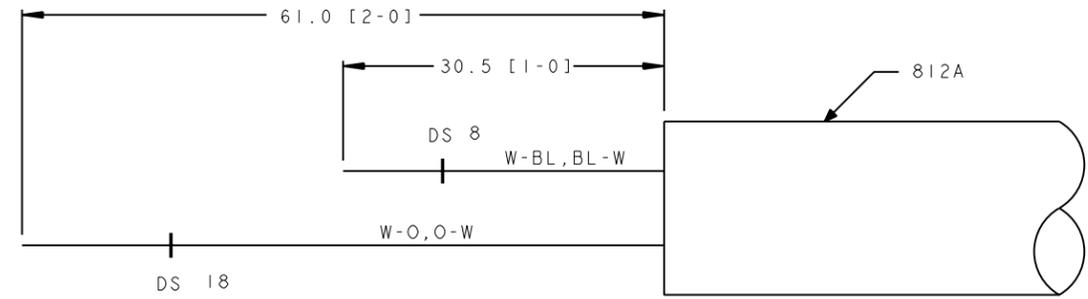


"A" END
 GROUP 126

PROJ-EQEDFORM.FRM-FEB-96

ED5D621-35

FOR PROPRIETARY NOTICE SEE SHEET A1		THIRD ANGLE PROJN	
CONNECTORIZED SWITCHBOARD			
CABLE ASSEMBLIES		DWG SIZE	ISSUE
		C2	52
LUCENT TECHNOLOGIES	ED5D621-35	SHEET NO. B6	
MODEL NAME			

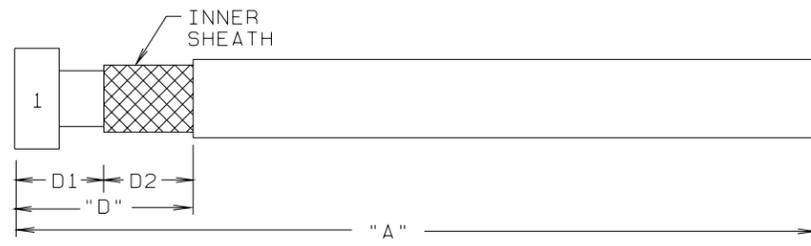


THE "A" DIM IS THE LENGTH OF SWBD CABLE FRONT OF CONN TO FRONT OF CONN.
 THE "D" AND "E" DIM ARE THE DIM FROM BUTT OF CABLE TO THE FRONT OF CONN.

SK . A

TABLE S												
GROUP	CABLE CODE	CABLE DESIG	"A" DIM	LENGTH FROM CABLE BUTT TO FRONT OF CONN						SK		
				"D" DIM		"D1" DIM		"D2" DIM			"E" DIM	
				CM	FT-IN	CM	FT-IN	CM	FT-IN		CM	FT-IN
501A	810AS	JX501A	X DIM	116.8	[3-10]	55.9	[1-10]	61.0	[2-0]		A	
503A		JX503A		127.0	[4-2]	64.8	[2-1 1/2]	62.23	[2-1/2]			
505A		JX505A		142.2	[4-8]	76.2	[2-6]	66.0	[2-2]			
507A		JX507A		152.4	[5-0]	85.1	[2-9 1/2]	67.3	[2-2 1/2]			
502A		JX502A		144.8	[4-9]	77.5	[2-6 1/2]	67.3	[2-2 1/2]			
504A		JX504A		134.6	[4-5]	68.6	[2-3]	66.0	[2-2]			
506A		JX506A		119.4	[3-11]	57.2	[1-10 1/2]	62.23	[2-1/2]			
508A		JX508A		109.2	[3-7]	48.3	[1-7]	61.0	[2-0]			
511A		JX511A		138.4	[4-6 1/2]	55.9	[1-10]	82.6	[2-8 1/2]			
513A		JX513A		148.6	[4-10 1/2]	64.8	[2-1 1/2]	83.8	[2-9]			
515A		JX515A		163.8	[5-4 1/2]	76.2	[2-6]	87.6	[2-10 1/2]			
517A		JX517A		174.0	[5-8 1/2]	85.1	[2-9 1/2]	88.9	[2-11]			
512A		JX512A		166.4	[5-5 1/2]	77.5	[2-6 1/2]	88.9	[2-11]			
514A		JX514A		156.2	[5-1 1/2]	68.6	[2-3]	87.6	[2-10 1/2]			
516A		JX516A		141.0	[4-7 1/2]	57.2	[1-10 1/2]	83.8	[2-9]			
518A		JX518A		130.8	[4-3 1/2]	48.3	[1-7]	82.6	[2-8 1/2]			
521A		JX521A		125.7	[4-1 1/2]	63.5	[2-1]	62.23	[2-1/2]			
523A		JX523A		151.1	[4-11 1/2]	83.8	[2-9]	67.3	[2-2 1/2]			
522A		JX522A		143.5	[4-8 1/2]	76.2	[2-6]	67.3	[2-2 1/2]			
524A		JX524A		118.1	[3-10 1/2]	55.9	[1-10]	62.23	[2-1/2]			

SEE PROPRIETARY NOTICE ON SHEET ONE		
CONNECTORIZED SWITCHBOARD CABLE ASSEMBLIES		DWG SIZE C2
LUCENT TECHNOLOGIES INC.		ISSUE 49 SHEET B8
ED5D621-35		

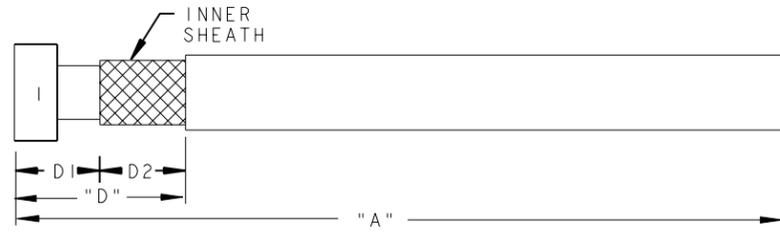

THE "A" DIM IS THE LENGTH OF SWBD CABLE FRONT OF CONN TO FRONT OF CONN.
 THE "D" AND "E" DIM ARE THE DIM FROM BUTT OF CABLE TO THE FRONT OF CONN.

SK. A

TABLE S												
GROUP	CABLE CODE	CABLE DESIG	"A" DIM	LENGTH FROM CABLE BUTT TO FRONT OF CONN						SK		
				"D" DIM		"D1" DIM		"D2" DIM			"E" DIM	
				CM	FT-IN	CM	FT-IN	CM	FT-IN		CM	FT-IN
531A	810AS	JX531A	X DIM	147.3	[4-10]	63.5	[2-1]	83.8	[2-9]	A		
533A		JX533A		172.7	[5-8]	83.8	[2-9]	88.9	[2-11]			
532A		JX532A		165.1	[5-5]	76.2	[2-6]	88.9	[2-11]			
534A		JX534A		139.7	[4-7]	55.9	[1-10]	83.8	[2-9]			
541A	808AS	JX541A		148.6 [4-10 1/2]		64.8	[2-1 1/2]	83.8	[2-9]			
543A		JX543A		174.0	[5-8 1/2]	85.1	[2-9 1/2]	88.9	[2-11]			
542A		JX542A		166.4	[5-5 1/2]	77.5	[2-6 1/2]	88.9	[2-11]			
544A		JX544A		141.0	[4-7 1/2]	57.2 [1-10 1/2]		83.8	[2-9]			
545A	810AS	JX545A		147.3	[4-10]	63.5	[2-1]	83.8	[2-9]			
546A		JX546A		166.4	[5-5 1/2]	77.5	[2-6 1/2]	88.9	[2-11]			
547A		JX547A		172.7	[5-8]	83.8	[2-9]	88.9	[2-11]			
548A	810AS	JX548A		141.0	[4-7 1/2]	57.2 [1-10 1/2]		83.8	[2-9]			
551A		JX551A		193.0	[6-4]	55.9	[1-10]	137.2	[4-6]			
553A		JX553A		203.2	[6-8]	64.8	[2-1 1/2]	138.4	[4-6 1/2]			
555A		JX555A		218.4	[7-2]	76.2	[2-6]	142.2	[4-8]			
557A		JX557A		228.6	[7-6]	85.1	[2-9 1/2]	143.5	[4-8 1/2]			
552A		JX552A		221.0	[7-3]	77.5	[2-6 1/2]	143.5	[4-8 1/2]			

PROJ-EGEDFORM. FRM-FEB 96

ED5D621-35

FOR PROPRIETARY NOTICE SEE SHEET A1		THIRD ANGLE PROJ	
CONNECTORIZED SWITCHBOARD CABLE ASSEMBLIES			
DWG SIZE C2		ISSUE 53	
LUCENT TECHNOLOGIES		SHEET NO. B9	

ED5D621-35

MODEL NAME




THE "A" DIM IS THE LENGTH OF SWBD CABLE FRONT OF CONN TO FRONT OF CONN.
 THE "D" AND "E" DIM ARE THE DIM FROM BUTT OF CABLE TO THE FRONT OF CONN.

SK.A
 (SEE TABLE S)

TABLE S								
GROUP	CABLE CODE	CABLE DESIG	"A" DIM	LENGTH FROM CABLE BUTT TO FRONT OF CONN				
				"D" DIM		"E" DIM		SK
				CM	FT-IN	CM	FT-IN	
251A	809A	JX251A	X DIM		57.2 [1-10 1/2]		A	
252A		JX252A			62.2 [2-1/2]			
253A		JX253A			66.0 [2-2]			
254A		JX254A			71.1 [2-4]			
255A		JX255A			77.5 [2-6 1/2]			
256A		JX256A			82.6 [2-8 1/2]			
257A		JX257A			86.4 [2-10]			
258A		JX258A			91.4 [3-0]			
259A		JX259A			78.7 [2-7]			
260A		JX260A			83.8 [2-9]			
261A		JX261A			69.9 [2-3 1/2]			
262A		JX262A			74.9 [2-5 1/2]			
263A		JX263A			58.4 [1-11]			
264A		JX264A			63.5 [2-1]			
265A		JX265A			49.5 [1-7 1/2]			
266A		JX266A			54.6 [1-9 1/2]			

SEE PROPRIETARY NOTICE ON SHEET ONE		
CONNECTORIZED SWITCHBOARD CABLE ASSEMBLIES		
	DWG SIZE c2	ISSUE 49
LUCENT TECHNOLOGIES INC.	ED5D621-35	SHEET B11

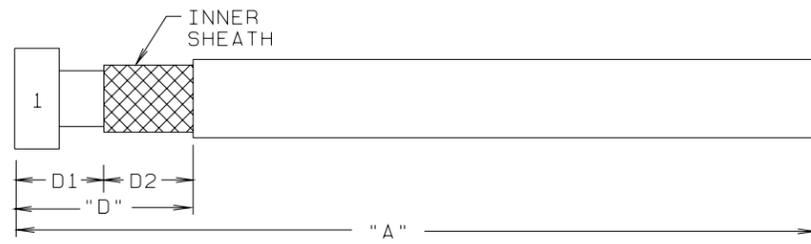


THE "A" DIM IS THE LENGTH OF SWBD CABLE FRONT OF CONN TO FRONT OF CONN.
 THE "D" AND "E" DIM ARE THE DIM FROM BUTT OF CABLE TO THE FRONT OF CONN.

SK.A

TABLE S												
GROUP	CABLE CODE	CABLE DESIG	"A" DIM	LENGTH FROM CABLE BUTT TO FRONT OF CONN					SK			
				"D" DIM		"D1" DIM DIM + 25.4 [10]		"D2" DIM		"E" DIM		
				CM	FT-IN	CM	FT-IN	CM		FT-IN	CM	FT-IN
901A	2249032	JR901A	X DIM	109.2 [3-7]		48.3 [1-7]		61.0 [2-0]		A		
901B		JR901B		111.8 [3-8]		50.8 [1-8]		61.0 [2-0]				
901C		JR901C		114.3 [3-9]		53.3 [1-9]		61.0 [2-0]				
901D		JR901D		116.8 [3-10]		55.9 [1-10]		61.0 [2-0]				
903A		JR903A		119.4 [3-11]		57.2 [1-10 1/2]		62.2 [2-1/2]				
903B		JR903B		121.9 [4-0]		59.7 [1-11 1/2]		62.2 [2-1/2]				
903C		JR903C		124.5 [4-1]		62.2 [2-0 1/2]		62.2 [2-1/2]				
903D		JR903D		127.0 [4-2]		64.8 [2-1 1/2]		62.2 [2-1/2]				
905A		JR905A		134.6 [4-5]		68.6 [2-3]		66.0 [2-2]				
905B		JR905B		137.2 [4-6]		71.1 [2-4]		66.0 [2-2]				
905C		JR905C		139.7 [4-7]		73.7 [2-5]		66.0 [2-2]				
905D		JR905D		142.2 [4-8]		76.2 [2-6]		66.0 [2-2]				
907A		JR907A		144.8 [4-9]		77.5 [2-6 1/2]		67.3 [2-2 1/2]				
907B		JR907B		147.3 [4-10]		80.0 [2-7 1/2]		67.3 [2-2 1/2]				
907C		JR907C		149.9 [4-11]		82.6 [2-8 1/2]		67.3 [2-2 1/2]				
907D		JR907D		152.4 [5-0]		85.1 [2-9 1/2]		67.3 [2-2 1/2]				
902A		JR902A		137.2 [4-6]		69.9 [2-3 1/2]		67.3 [2-2 1/2]				
902B		JR902B		139.7 [4-7]		72.4 [2-4 1/2]		67.3 [2-2 1/2]				
902C		JR902C		142.2 [4-8]		74.9 [2-5 1/2]		67.3 [2-2 1/2]				
902D		JR902D		144.8 [4-9]		77.5 [2-6 1/2]		67.3 [2-2 1/2]				

SEE PROPRIETARY NOTICE ON SHEET ONE		
CONNECTORIZED SWITCHBOARD CABLE ASSEMBLIES		DWG SIZE c2
LUCENT TECHNOLOGIES INC.		ISSUE 49 SHEET B12
ED5D621-35		

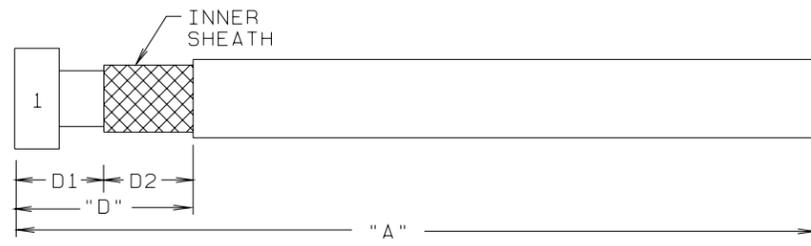

THE "A" DIM IS THE LENGTH OF SWBD CABLE FRONT OF CONN TO FRONT OF CONN.
 THE "D" AND "E" DIM ARE THE DIM FROM BUTT OF CABLE TO THE FRONT OF CONN.

SK.A

TABLE S												
GROUP	CABLE CODE	CABLE DESIG	"A" DIM	LENGTH FROM CABLE BUTT TO FRONT OF CONN						SK		
				"D" DIM		"D1" DIM DIM + 25.4 [10]		"D2" DIM			"E" DIM	
				CM	FT-IN	CM	FT-IN	CM	FT-IN		CM	FT-IN
904A	2249032	JR904A	X DIM	127.0 [4-2]		61.0 [2-0]		66.0 [2-2]		A		
904B		JR904B		129.5 [4-3]		63.5 [2-1]		66.0 [2-2]				
904C		JR904C		132.1 [4-4]		66.0 [2-2]		66.0 [2-2]				
904D		JR904D		134.6 [4-5]		68.6 [2-3]		66.0 [2-2]				
906A		JR906A		111.8 [3-8]		49.5 [1-7 1/2]		62.2 [2-1/2]				
906B		JR906B		114.3 [3-9]		52.1 [1-8 1/2]		62.2 [2-1/2]				
906C		JR906C		116.8 [3-10]		54.6 [1-9 1/2]		62.2 [2-1/2]				
906D		JR906D		119.4 [3-11]		57.2 [1-10 1/2]		62.2 [2-1/2]				
908A		JR908A		101.6 [3-4]		40.6 [1-4]		61.0 [2-0]				
908B		JR908B		104.1 [3-5]		43.2 [1-5]		61.0 [2-0]				
908C		JR908C		106.7 [3-6]		45.7 [1-6]		61.0 [2-0]				
908D		JR908D		109.2 [3-7]		48.3 [1-7]		61.0 [2-0]				

SEE PROPRIETARY NOTICE ON SHEET ONE		
CONNECTORIZED SWITCHBOARD CABLE ASSEMBLIES		
	DWG SIZE c2	ISSUE 49
LUCENT TECHNOLOGIES INC.	ED5D621-35	SHEET B13


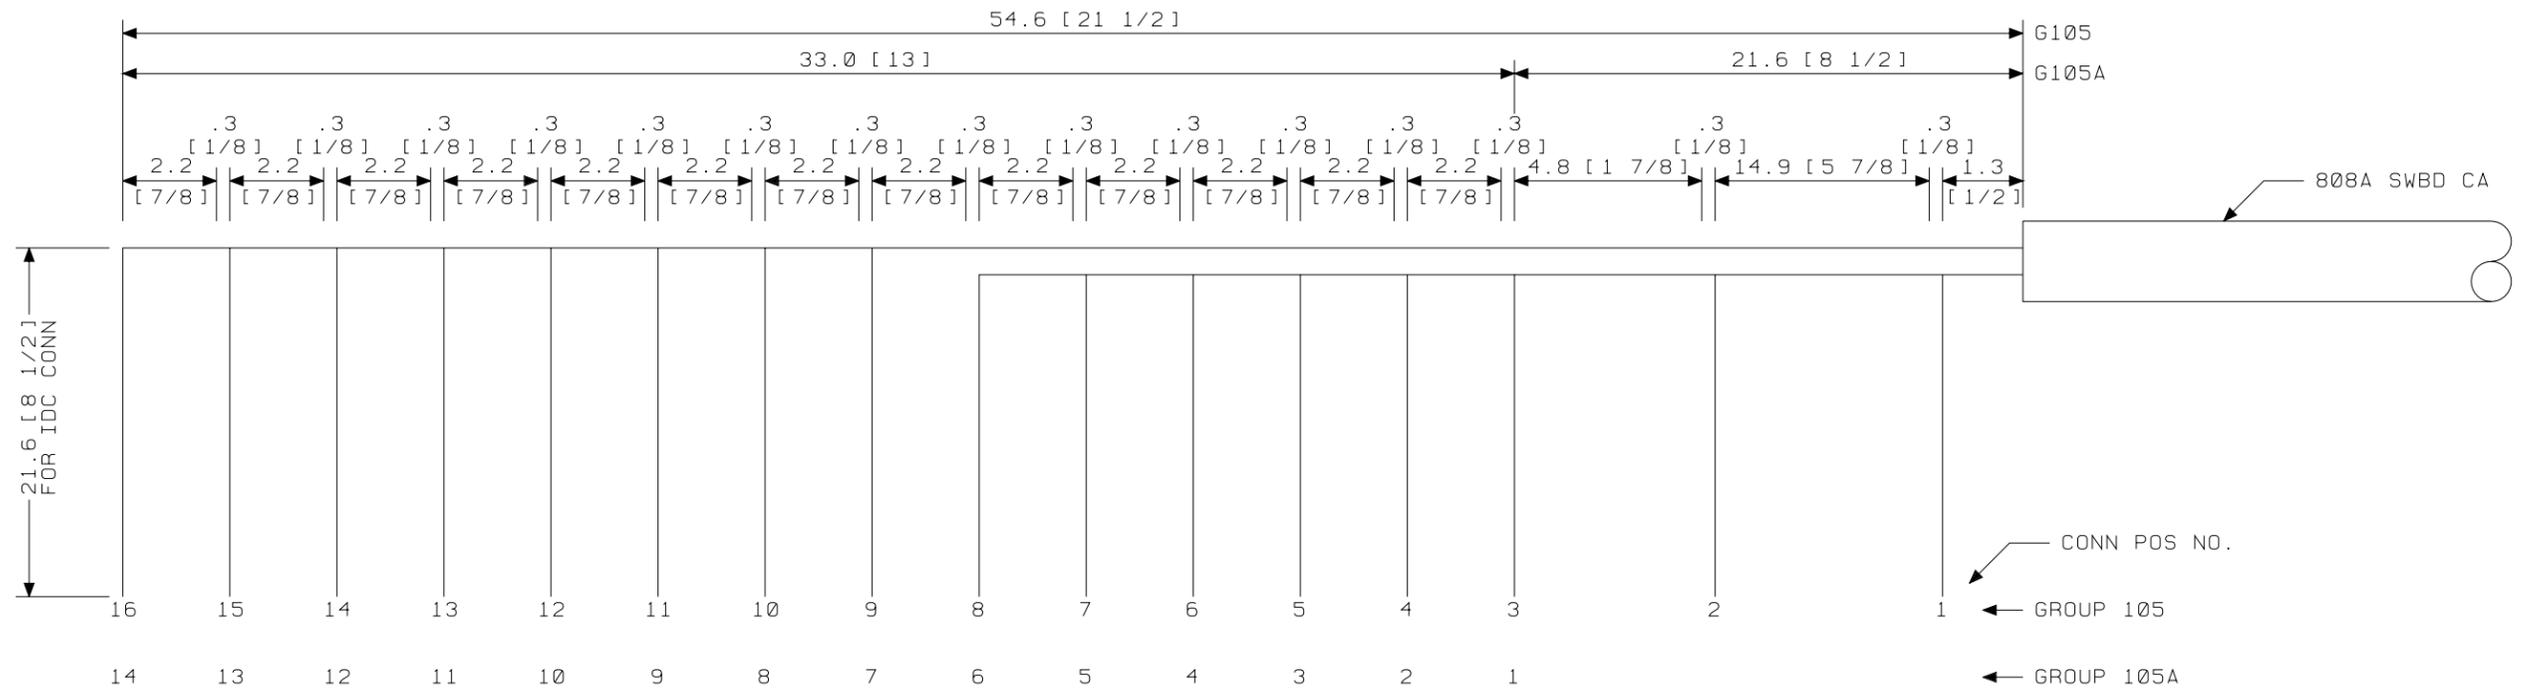


FIG. A2
GROUP 105 OR 105A FOR LAU

SEE PROPRIETARY NOTICE ON SHEET ONE		
CONNECTORIZED SWITCHBOARD CABLE ASSEMBLIES	DWG SIZE	ISSUE
	c2	49
LUCENT TECHNOLOGIES INC.	ED5D621-35	SHEET c1

SK 26.7 [10 1/2] TO ARM \varnothing (INCLUDES 25.4 [10] FOR MANUFACTURING PURPOSES)

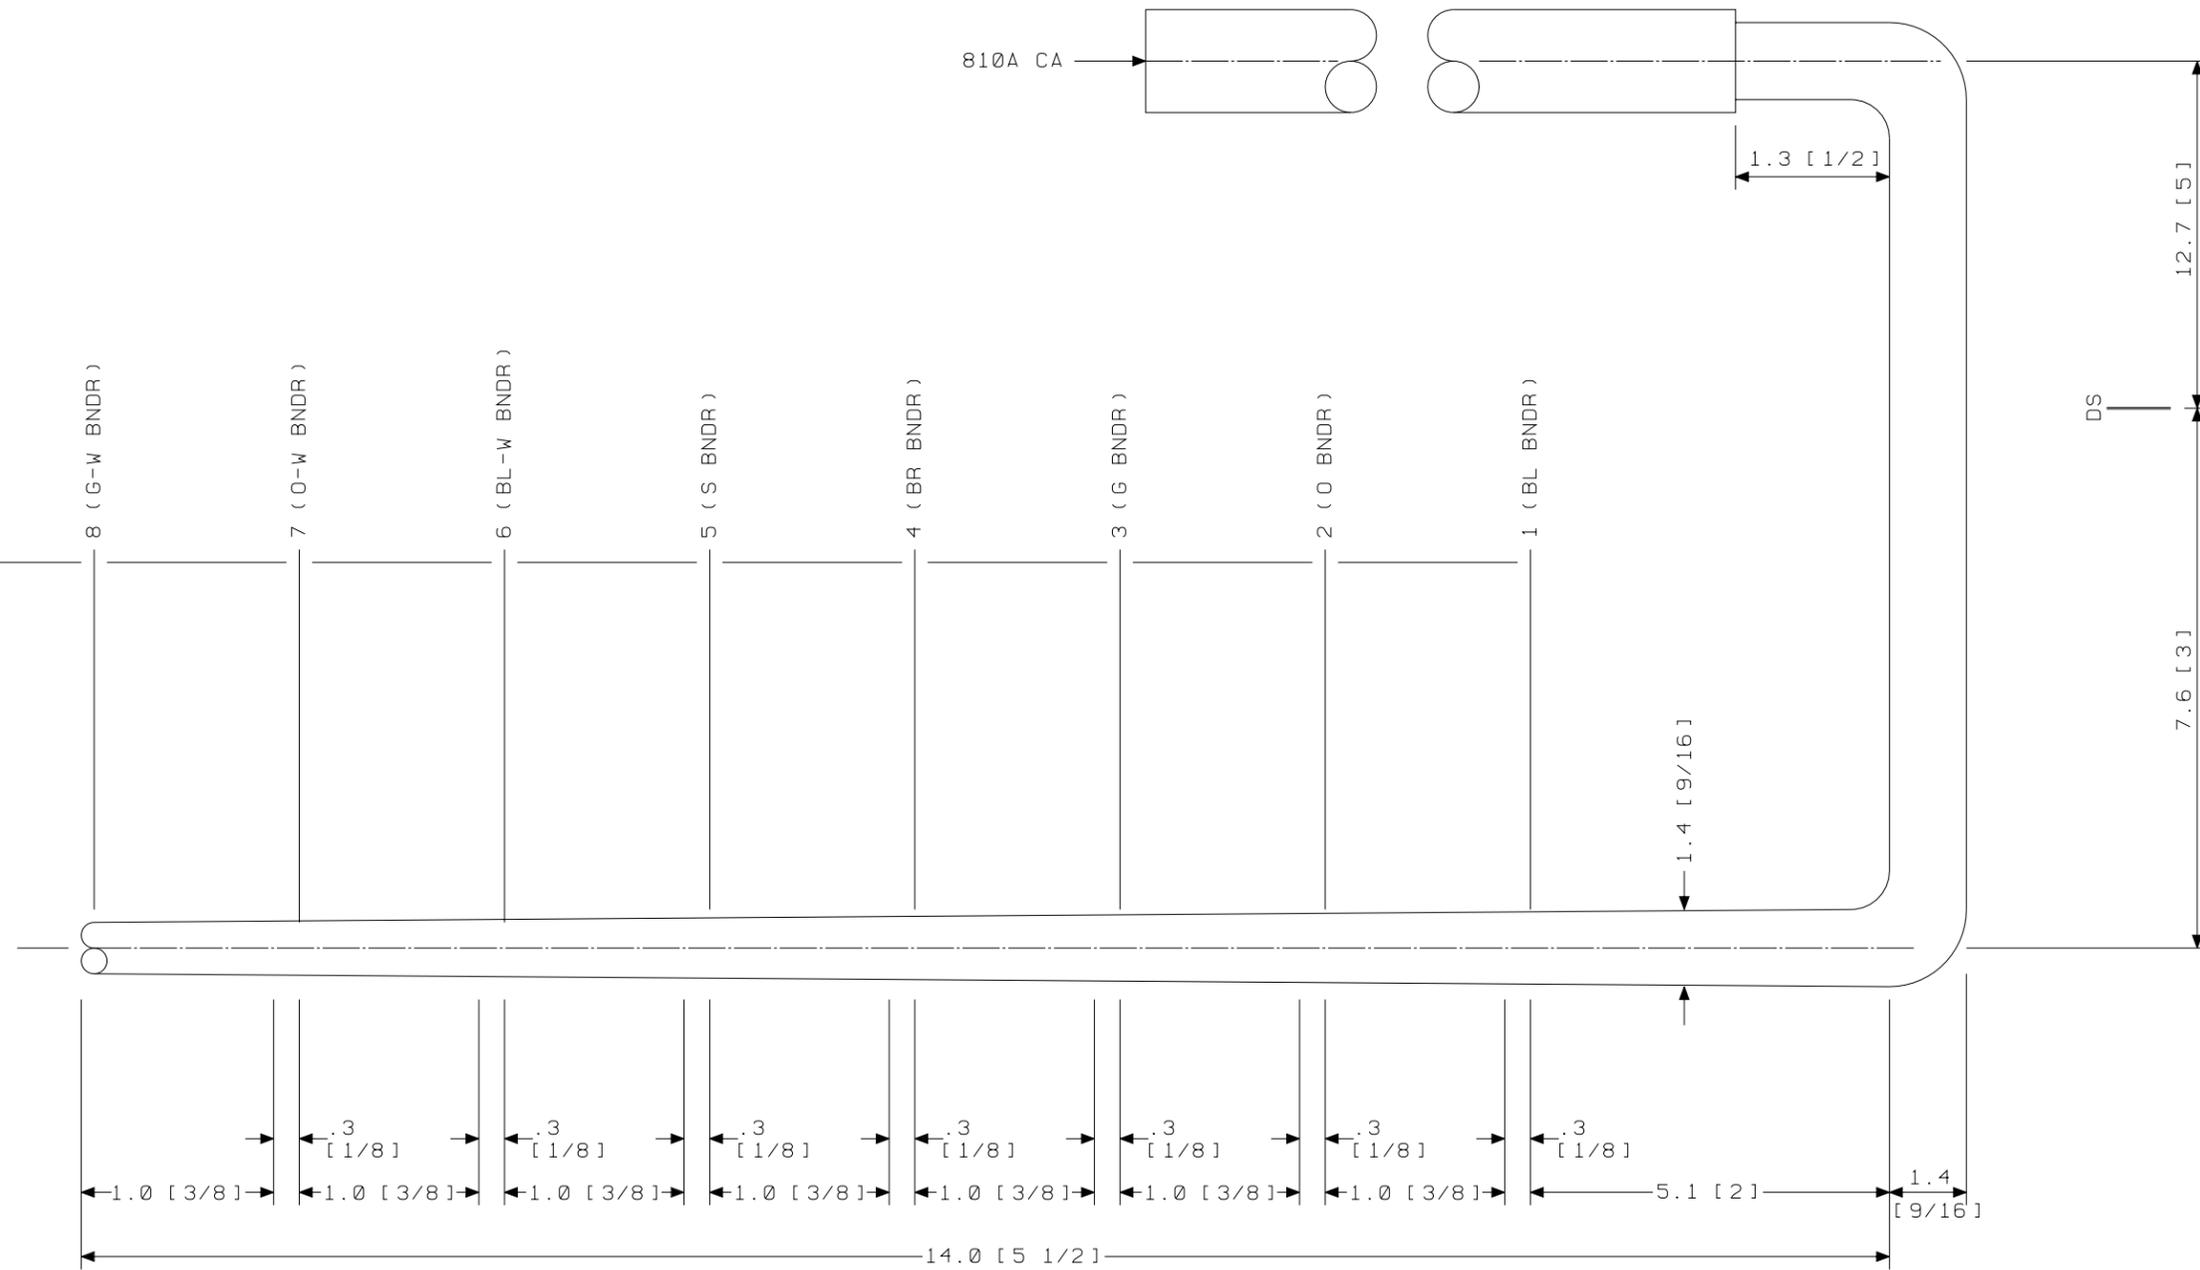


GROUP 211A
 CABLE FOR INTEGRATED SERVICES LINE UNIT (4-WIRE)
 LG 00.01
 END "A"

SEE PROPRIETARY NOTICE ON SHEET ONE		
CONNECTORIZED SWITCHBOARD CABLE ASSEMBLIES	DWG SIZE	ISSUE
	c2	49
LUCENT TECHNOLOGIES INC.	ED5D621-35	SHEET c2

ED5D621-35

SK 26.7 [10 1/2] TO ARM \varnothing (INCLUDES 25.4 [10] FOR MANUFACTURING PURPOSES)

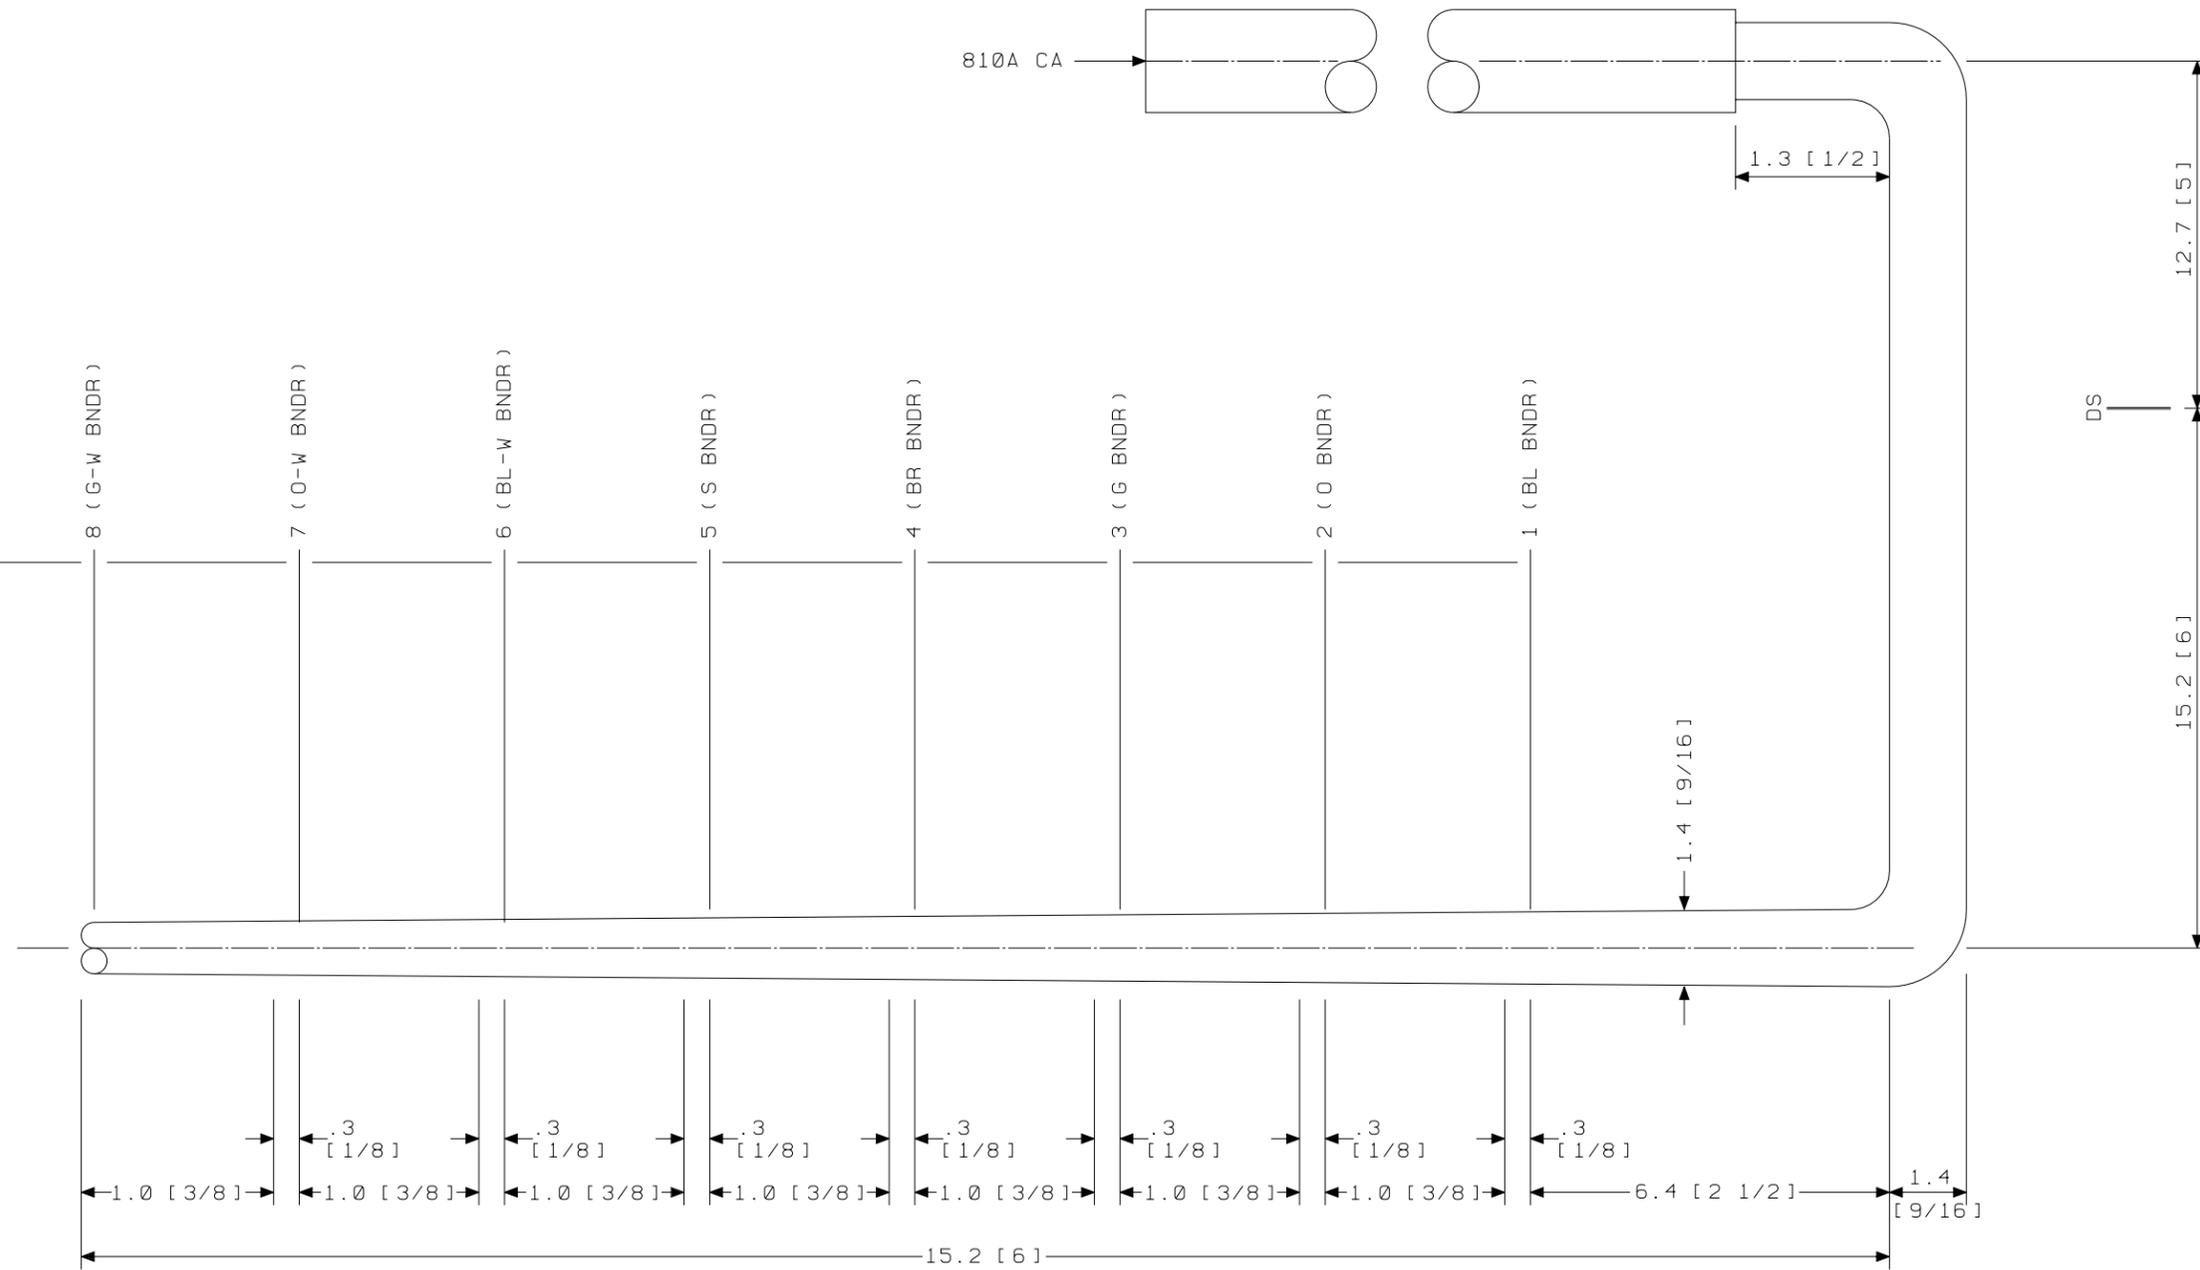


GROUP 213A
CABLE FOR INTEGRATED SERVICES LINE UNIT (4-WIRE)
LG 02.03
END "A"

SEE PROPRIETARY NOTICE ON SHEET ONE		
CONNECTORIZED SWITCHBOARD CABLE ASSEMBLIES	DWG SIZE	ISSUE
	c2	49
LUCENT TECHNOLOGIES INC.	ED5D621-35	SHEET c3

ED5D621-35


SK 26.7 [10 1/2] TO ARM \varnothing (INCLUDES 25.4 [10] FOR MANUFACTURING PURPOSES)

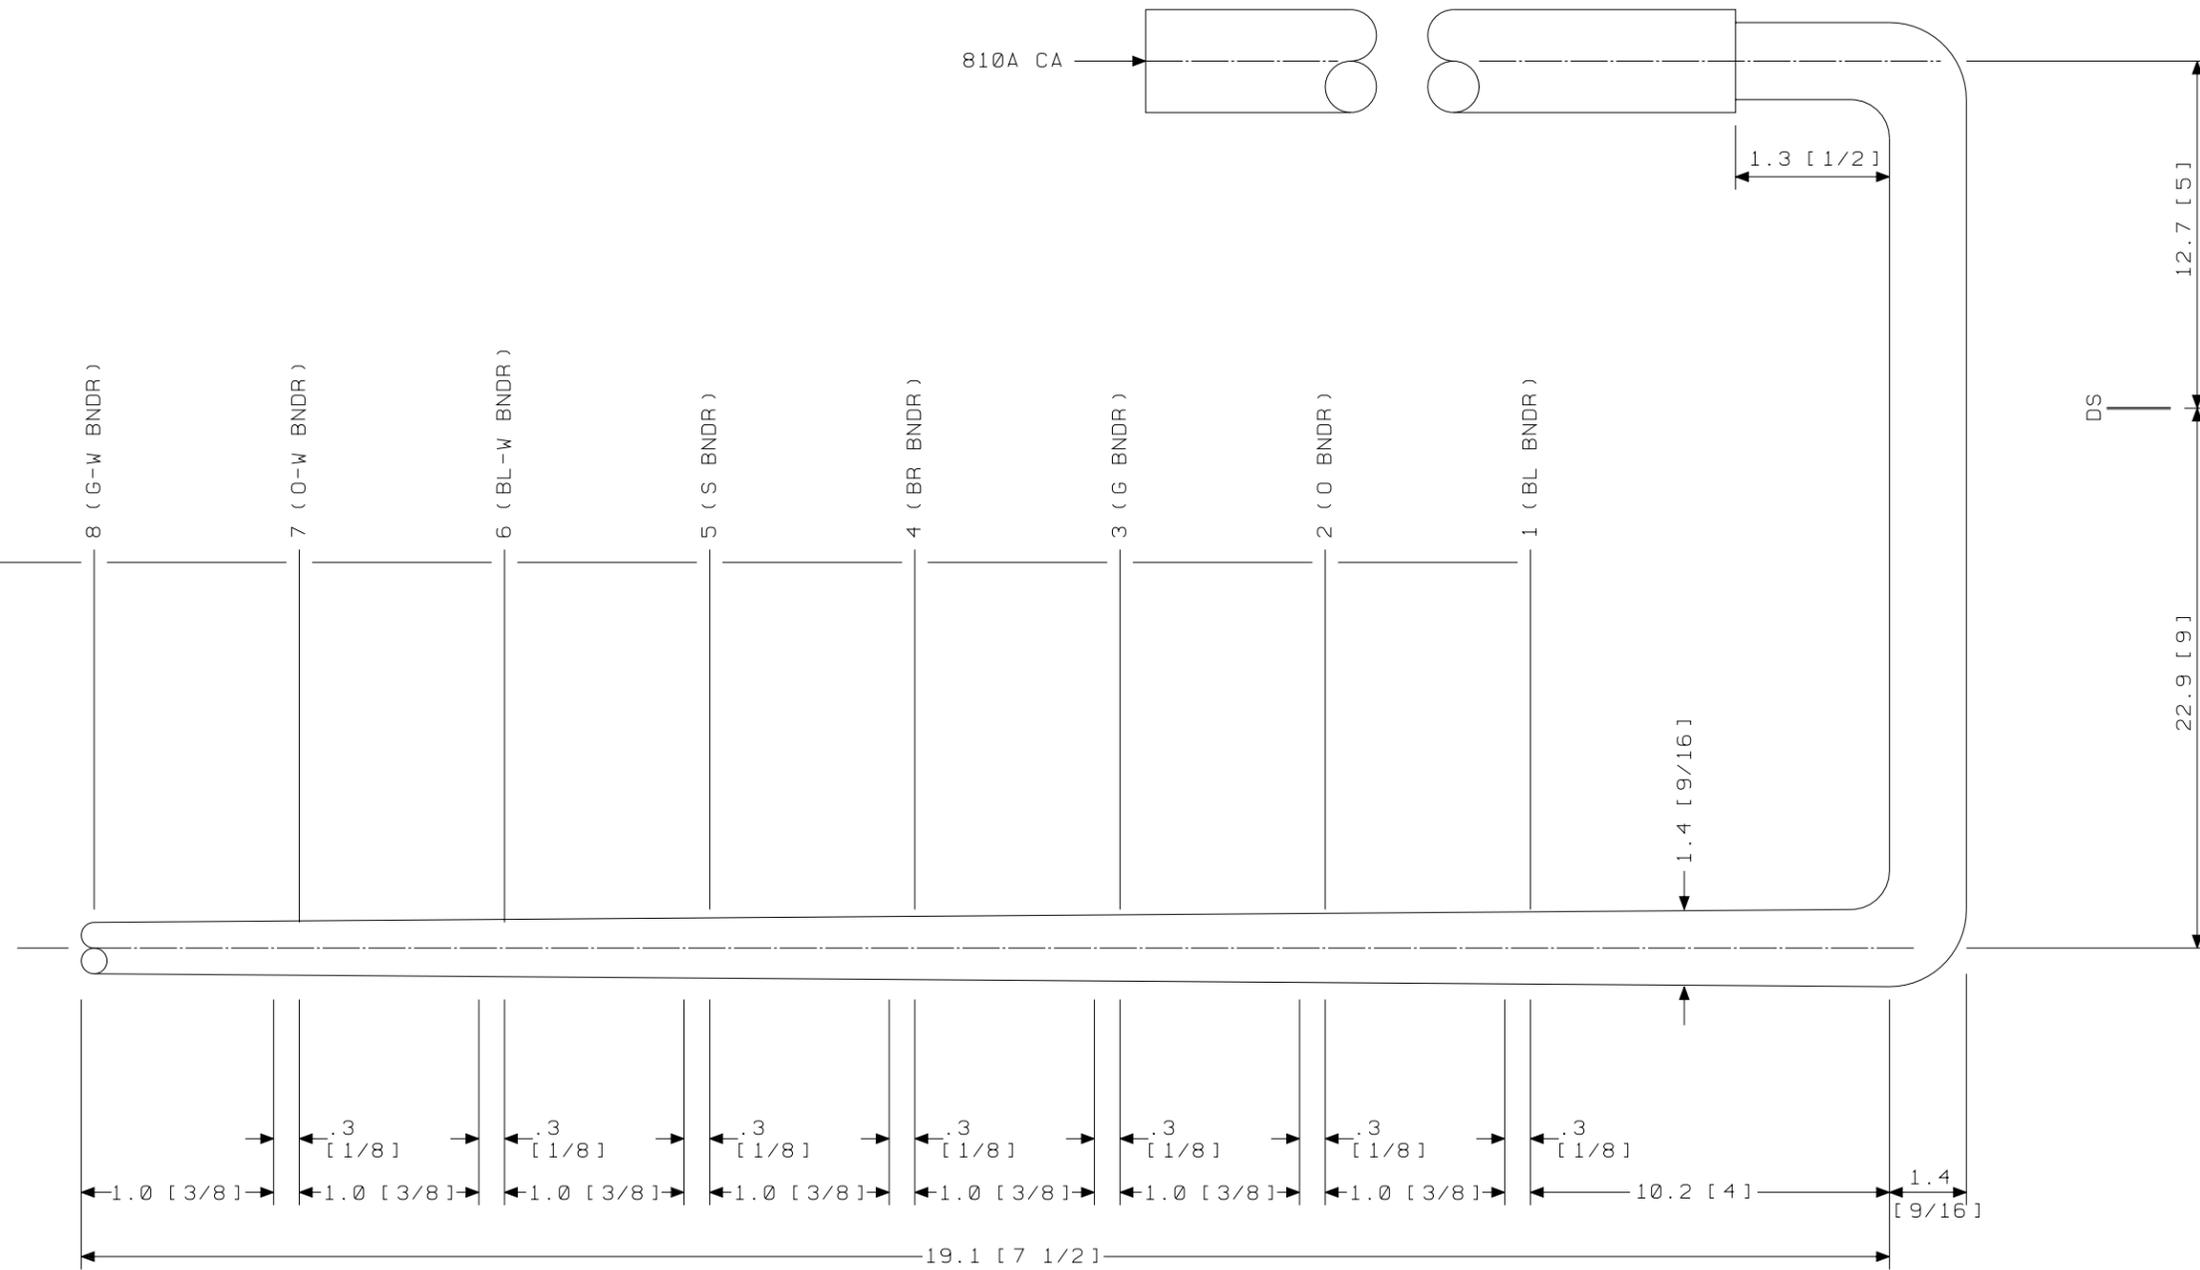


GROUP 215A
 CABLE FOR INTEGRATED SERVICES LINE UNIT (4-WIRE)
 LG 04.05
 END "A"

SEE PROPRIETARY NOTICE ON SHEET ONE		
CONNECTORIZED SWITCHBOARD CABLE ASSEMBLIES	DWG SIZE	ISSUE
	c2	49
LUCENT TECHNOLOGIES INC.	ED5D621-35	SHEET c4

ED5D621-35

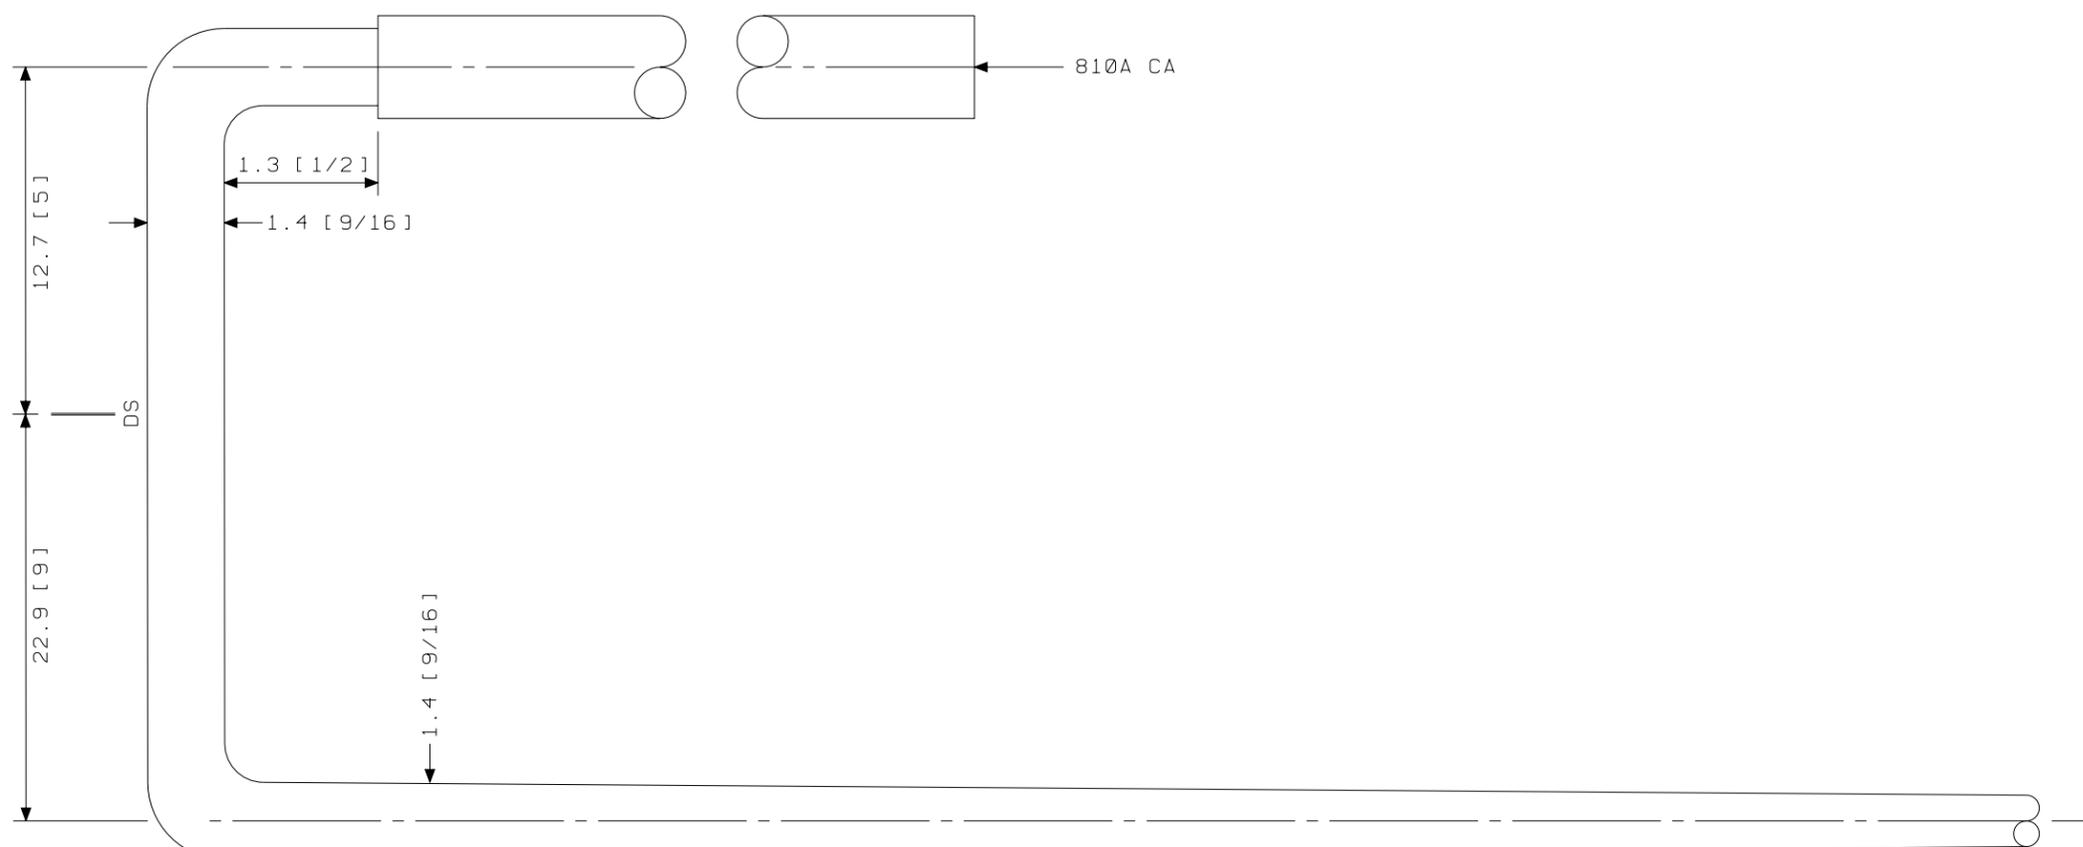

- 1 (BL BNR)
- 2 (O BNR)
- 3 (G BNR)
- 4 (BR BNR)
- 5 (S BNR)
- 6 (BL-W BNR)
- 7 (O-W BNR)
- 8 (G-W BNR)

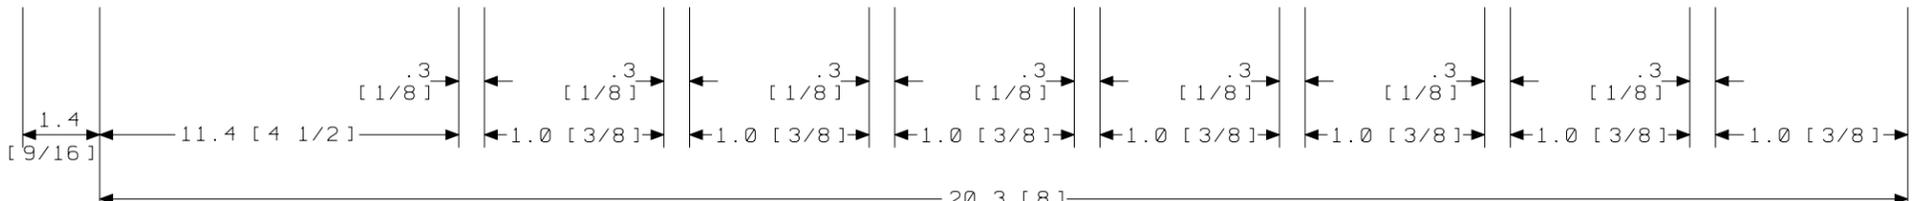


GROUP 212A
 CABLE FOR INTEGRATED SERVICES LINE UNIT (4-WIRE)
 LG 08.09
 END "A"


SK 26.7 [10 1/2] TO ARM Ø (INCLUDES 25.4 [10] FOR MANUFACTURING PURPOSES)

SEE PROPRIETARY NOTICE ON SHEET ONE		
CONNECTORIZED SWITCHBOARD CABLE ASSEMBLIES		DWG SIZE c2
		ISSUE 49
LUCENT TECHNOLOGIES INC.	ED5D621-35	SHEET c6

ED5D621-35

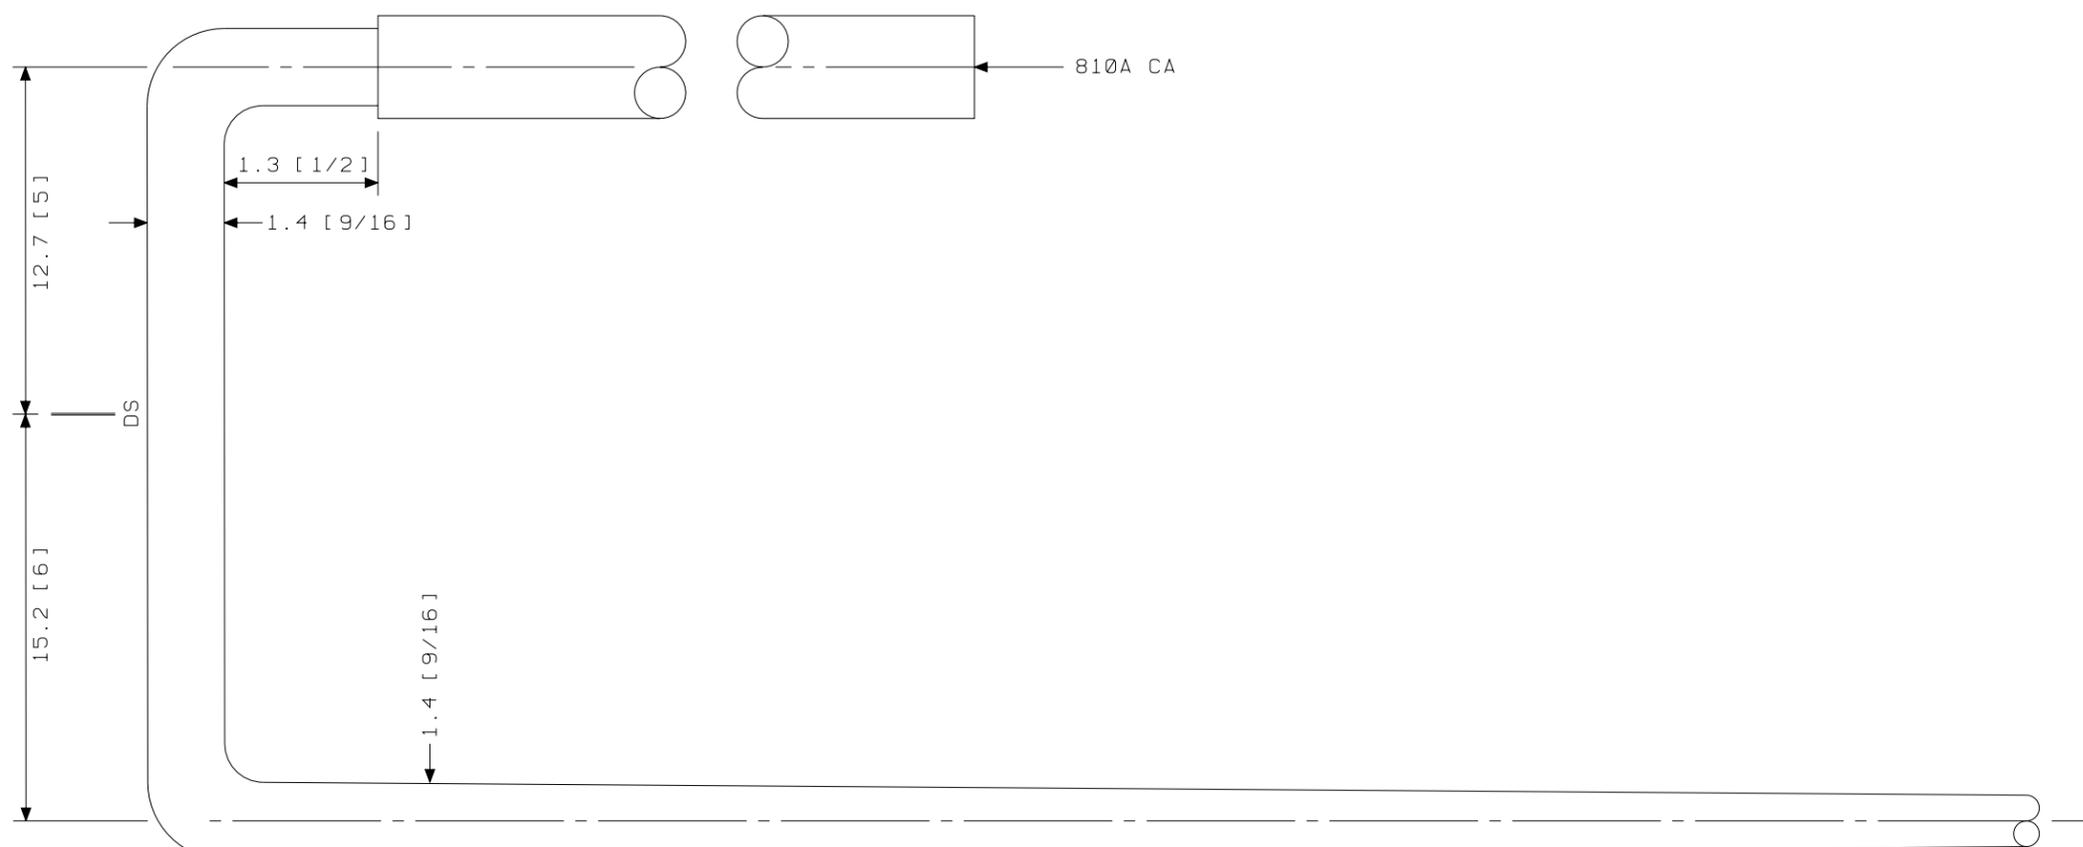

- 1 (BL BNR)
- 2 (O BNR)
- 3 (G BNR)
- 4 (BR BNR)
- 5 (S BNR)
- 6 (BL-W BNR)
- 7 (O-W BNR)
- 8 (G-W BNR)

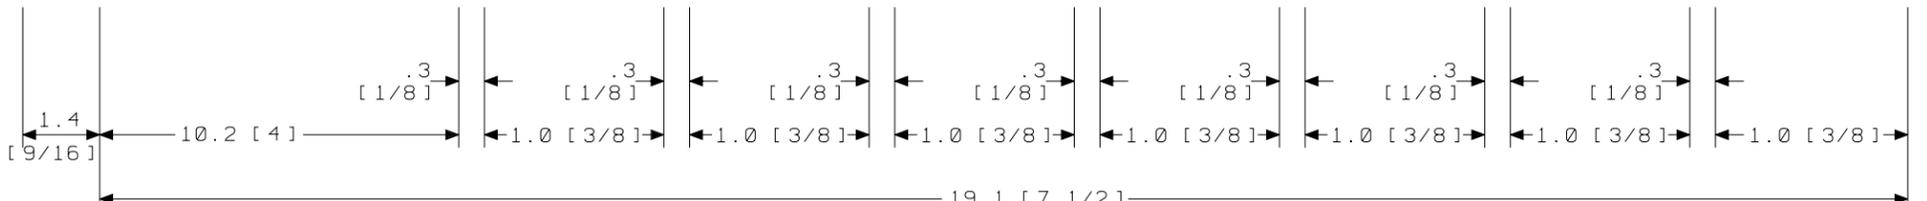


GROUP 214A
 CABLE FOR INTEGRATED SERVICES LINE UNIT (4-WIRE)
 LG 10.11
 END "A"


SK 26.7 [10 1/2] TO ARM ⌀ (INCLUDES 25.4 [10] FOR MANUFACTURING PURPOSES)

SEE PROPRIETARY NOTICE ON SHEET ONE		
CONNECTORIZED SWITCHBOARD CABLE ASSEMBLIES		DWG SIZE c2
LUCENT TECHNOLOGIES INC.		ISSUE 49
ED5D621-35		SHEET c7

ED5D621-35

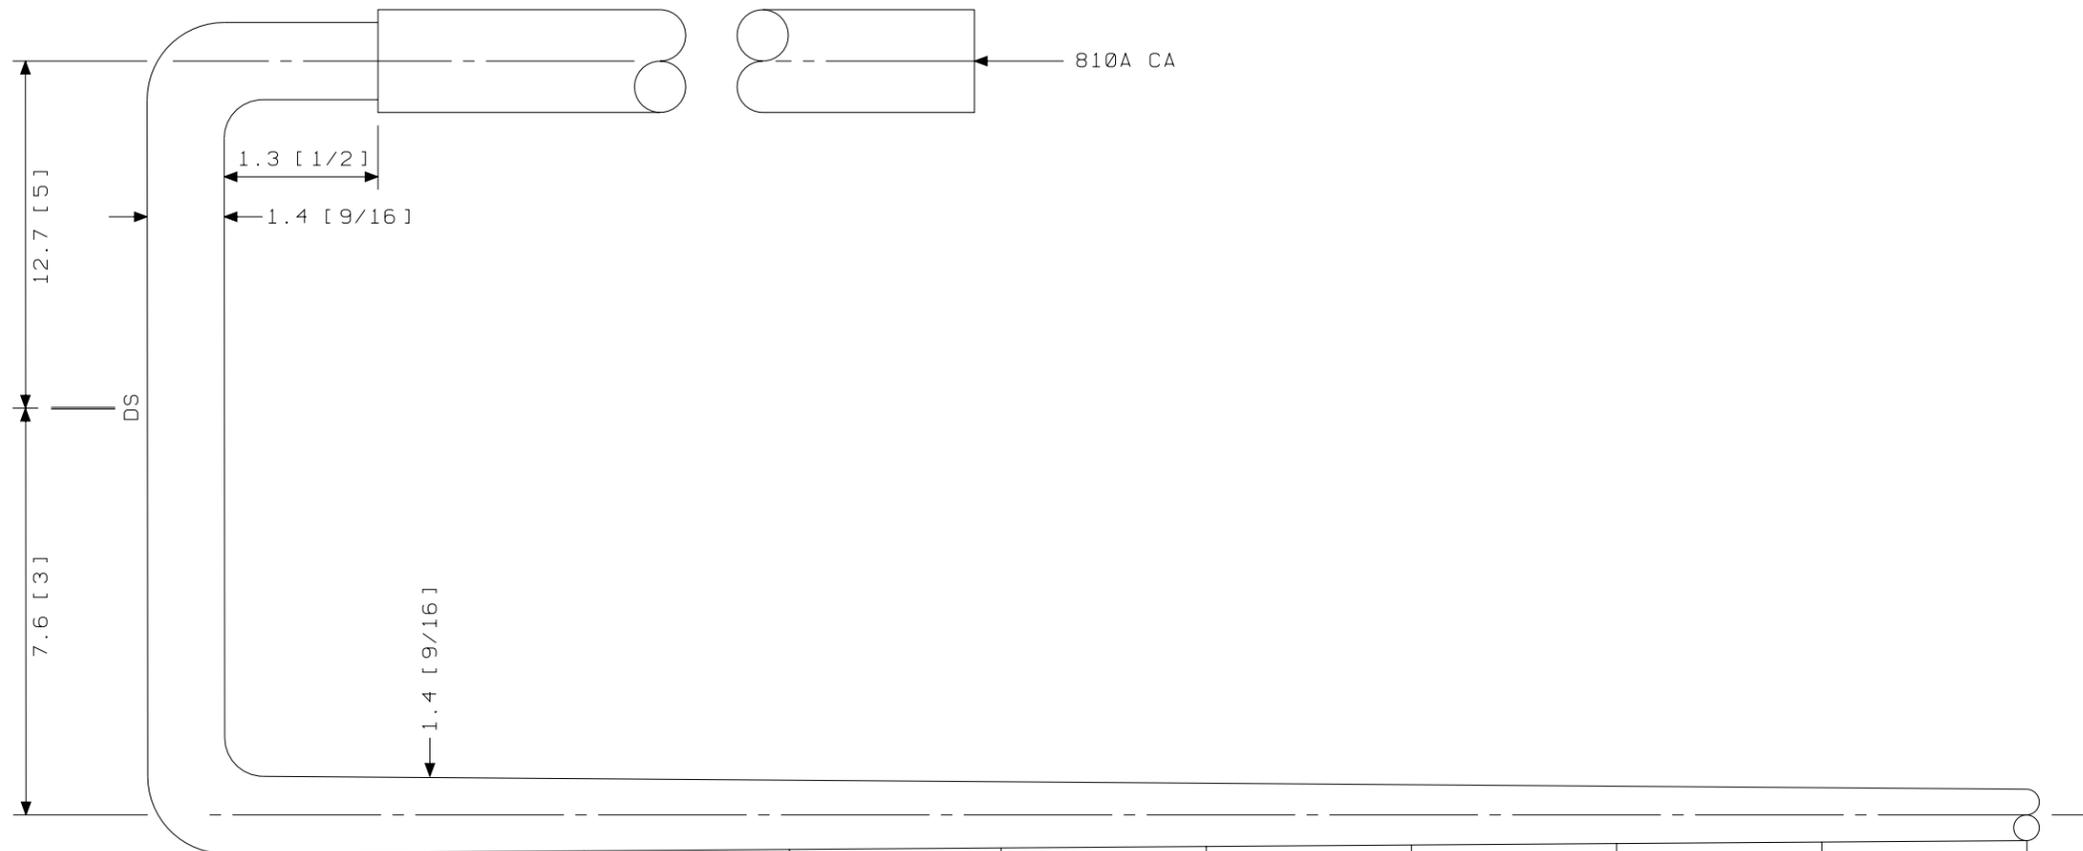

- 1 (BL BNR)
- 2 (O BNR)
- 3 (G BNR)
- 4 (BR BNR)
- 5 (S BNR)
- 6 (BL-W BNR)
- 7 (O-W BNR)
- 8 (G-W BNR)

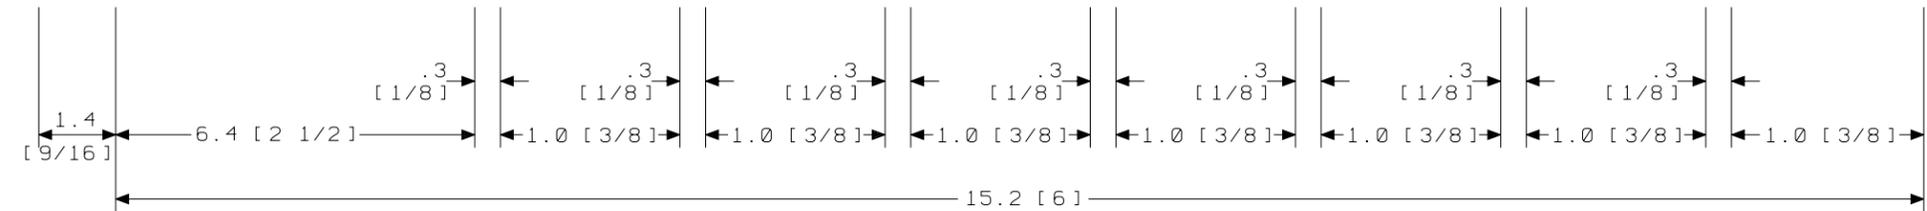


GROUP 216A
 CABLE FOR INTEGRATED SERVICES LINE UNIT (4-WIRE)
 LG 12.13
 END "A"


SK 26.7 [10 1/2] TO ARM Ø (INCLUDES 25.4 [10] FOR MANUFACTURING PURPOSES)

SEE PROPRIETARY NOTICE ON SHEET ONE		
CONNECTORIZED SWITCHBOARD CABLE ASSEMBLIES		DWG SIZE c2
		ISSUE 49
LUCENT TECHNOLOGIES INC.	ED5D621-35	SHEET c8

ED5D621-35

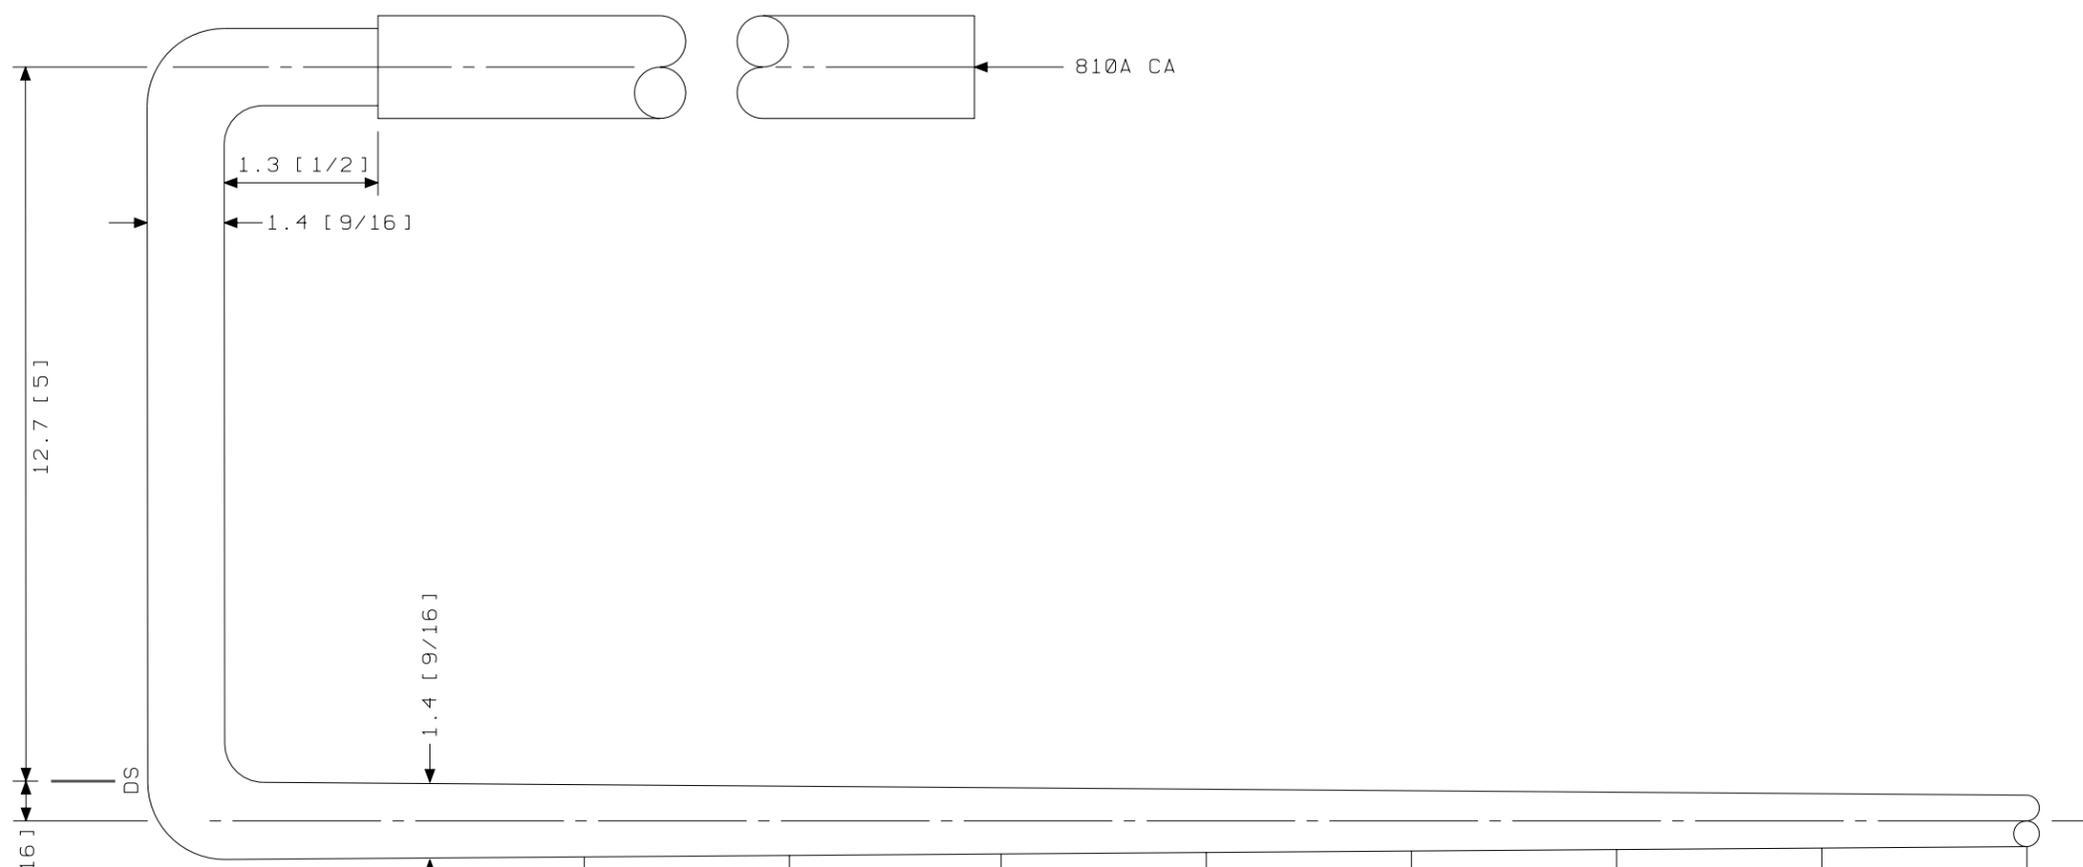

- 1 (BL BNR)
- 2 (O BNR)
- 3 (G BNR)
- 4 (BR BNR)
- 5 (S BNR)
- 6 (BL-W BNR)
- 7 (O-W BNR)
- 8 (G-W BNR)

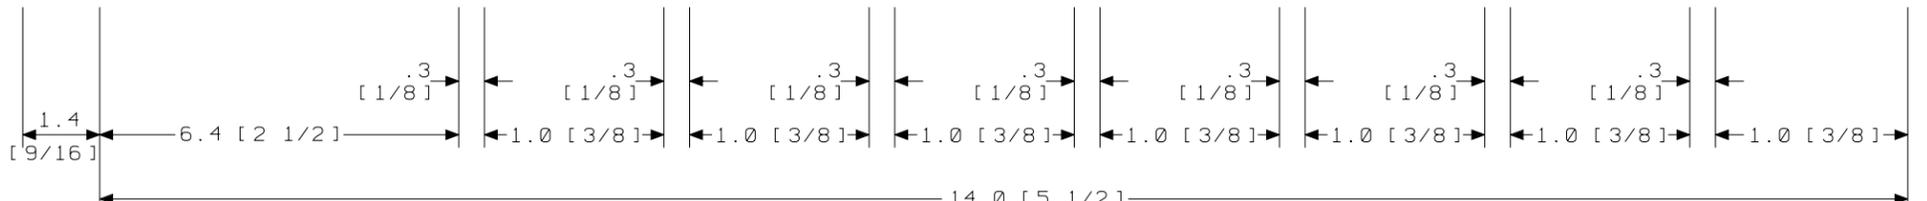

GROUP 218A
 CABLE FOR INTEGRATED SERVICES LINE UNIT (4-WIRE)
 LG 14.15
 END "A"

SK 26.7 [10 1/2] TO ARM Ø (INCLUDES 25.4 [10] FOR MANUFACTURING PURPOSES)

SEE PROPRIETARY NOTICE ON SHEET ONE		
CONNECTORIZED SWITCHBOARD CABLE ASSEMBLIES		DWG SIZE c2
LUCENT TECHNOLOGIES INC.		ISSUE 49
ED5D621-35		SHEET c9

ED5D621-35

SK 26.7 [10 1/2] TO ARM C (INCLUDES 25.4 [10] FOR MANUFACTURING PURPOSES)

810A CA

4 (BR BNR)

3 (G BNR)

2 (O BNR)

1 (BL BNR)

8 (G-W BNR)

7 (O-W BNR)

6 (BL-W BNR)

5 (S BNR)

1.3 [1/2]

1.4 [9/16]

DS

12.7 [5]

7.6 [3]

15.2 [6]

.3 [1/8]

.3 [1/8]

.3 [1/8]

2.2 [7/8]

2.2 [7/8]

2.2 [7/8]

6.4 [2 1/2]

1.4 [9/16]

GROUP 221A

CABLE FOR INTEGRATED SERVICES LINE UNIT (2-WIRE)

LG 0.1.2.3

END "A"

14.0 [5 1/2]

SEE PROPRIETARY NOTICE ON SHEET ONE

CONNECTORIZED SWITCHBOARD
CABLE ASSEMBLIES

DWG SIZE
c2

ISSUE
49

LUCENT
TECHNOLOGIES INC.

ED5D621-35

SHEET
c10

ED5D621-35

SK 26.7 [10 1/2] TO ARM 6 (INCLUDES 25.4 [10] FOR MANUFACTURING PURPOSES)

810A CA

4 (BR BNR)

3 (G BNR)

2 (O BNR)

1 (BL BNR)

8 (G-W BNR)

7 (O-W BNR)

6 (BL-W BNR)

5 (S BNR)

1.3 [1/2]

1.4 [9/16]

DS

12.7 [5]

22.9 [6]

30.5 [12]

.3 [1/8]

.3 [1/8]

.3 [1/8]

2.2 [7/8]

2.2 [7/8]

2.2 [7/8]

6.4 [2 1/2]

1.4 [9/16]

GROUP 223A

CABLE FOR INTEGRATED SERVICES LINE UNIT (2-WIRE)

LG 4,5,6,7

END "A"

14.0 [5 1/2]

SEE PROPRIETARY NOTICE ON SHEET ONE

CONNECTORIZED SWITCHBOARD
CABLE ASSEMBLIES

DWG SIZE
c2


ISSUE
49

LUCENT
TECHNOLOGIES INC.

ED5D621-35

SHEET
c11


ED5D621-35

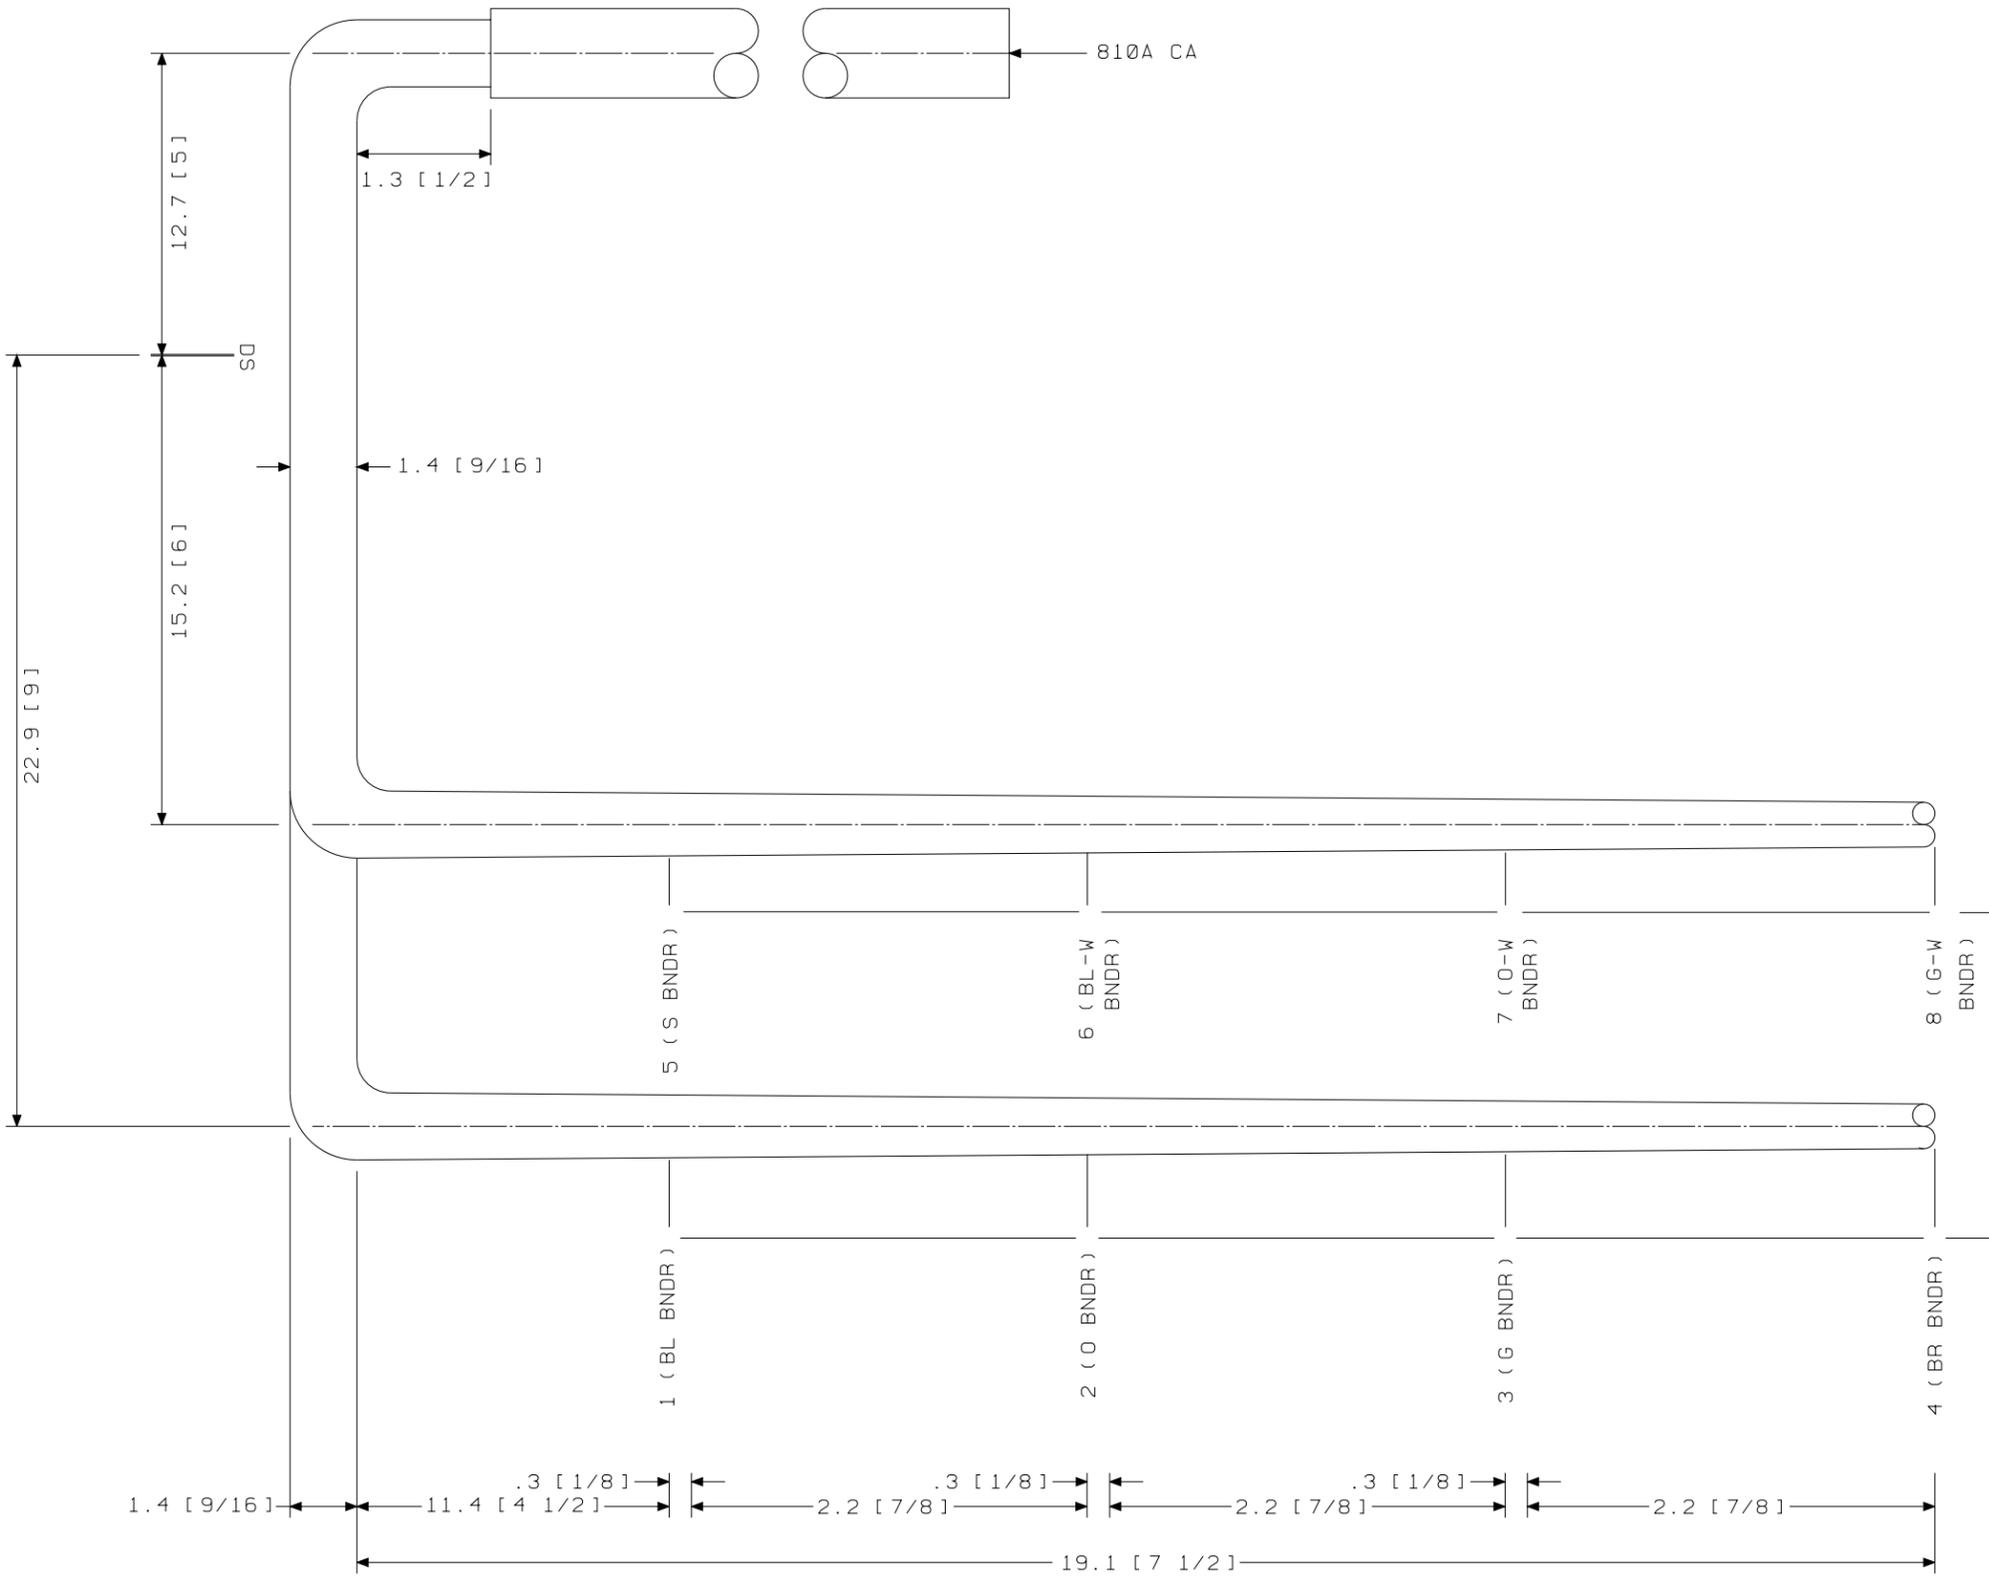

GROUP 222A
 CABLE FOR INTEGRATED SERVICES LINE UNIT (2-WIRE)
 LG 8,9,10,11
 END "A"

SEE PROPRIETARY NOTICE ON SHEET ONE		
CONNECTORIZED SWITCHBOARD CABLE ASSEMBLIES		DWG SIZE c2
LUCENT TECHNOLOGIES INC.		ISSUE 49
ED5D621-35		SHEET c12

ED5D621-35

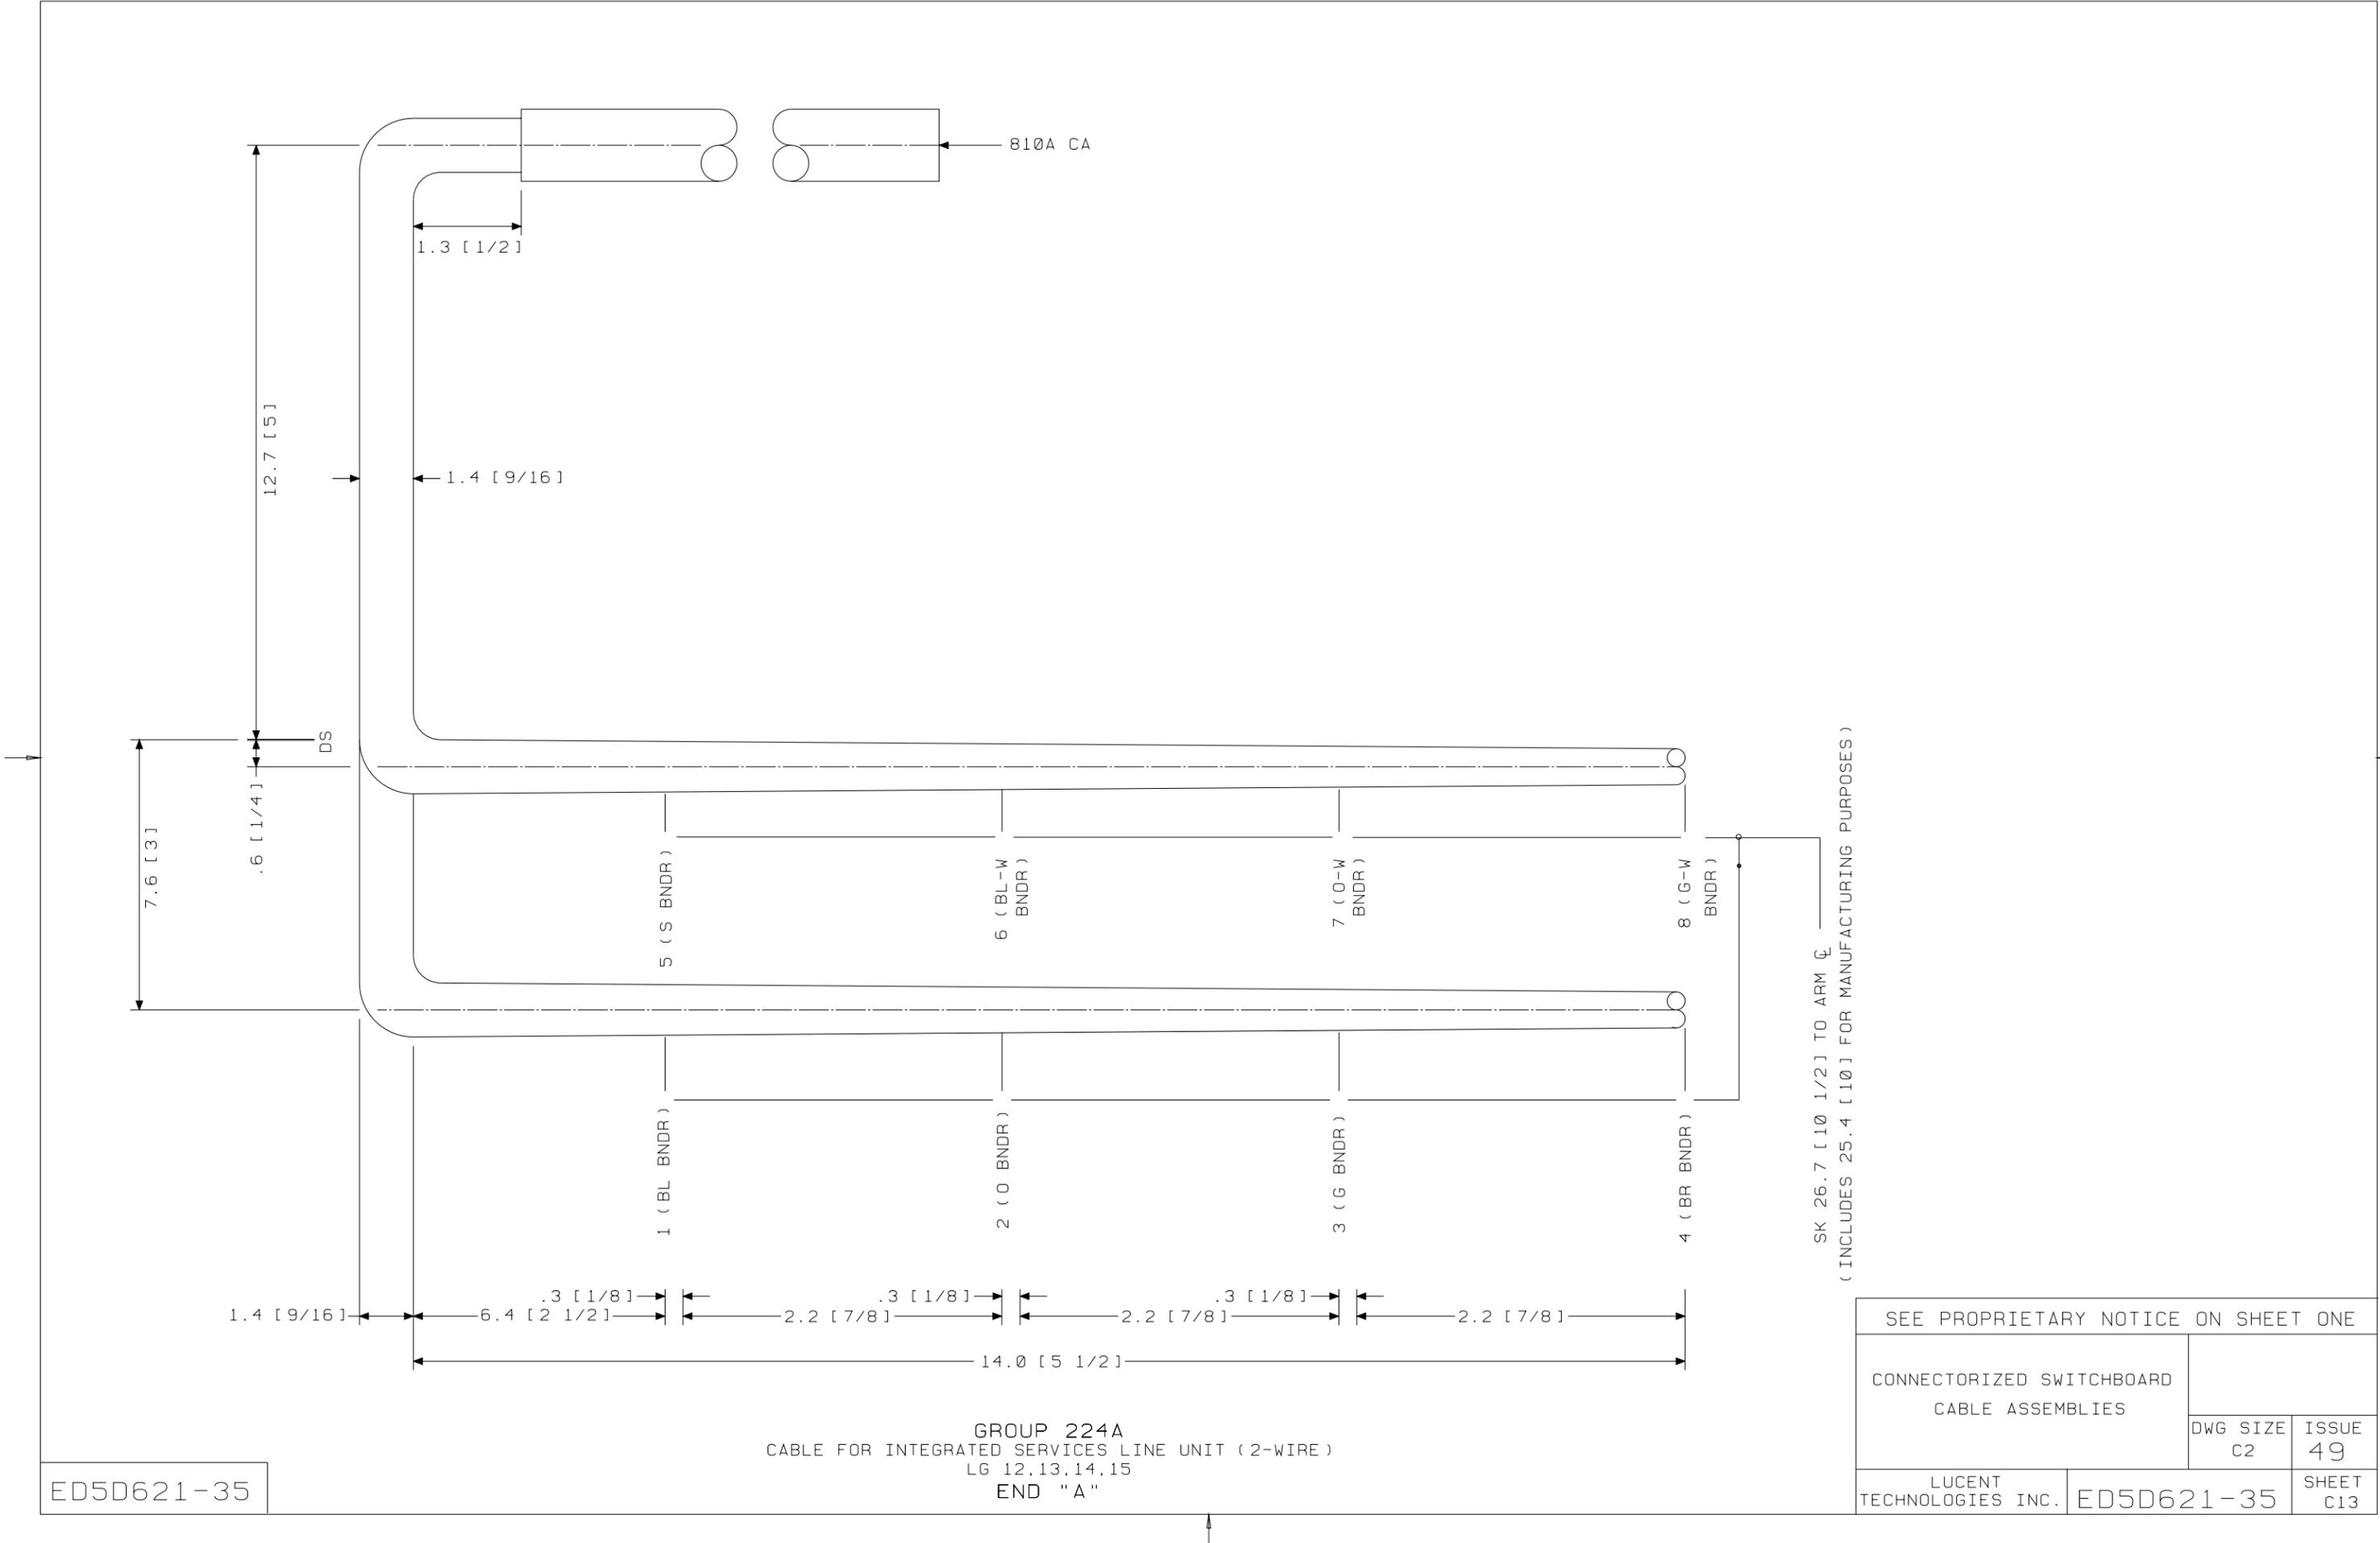

810A CA

1.3 [1/2]

1.4 [9/16]

12.7 [5]

DS

7.6 [3]

.6 [1/4]

5 (S BNR)

6 (BL-W BNR)

7 (O-W BNR)

8 (G-W BNR)

1 (BL BNR)

2 (O BNR)

3 (G BNR)

4 (BR BNR)

1.4 [9/16]

.3 [1/8]
6.4 [2 1/2]

.3 [1/8]
2.2 [7/8]

.3 [1/8]
2.2 [7/8]

.3 [1/8]
2.2 [7/8]

14.0 [5 1/2]

SK 26.7 [10 1/2] TO ARM C
(INCLUDES 25.4 [10] FOR MANUFACTURING PURPOSES)

SEE PROPRIETARY NOTICE ON SHEET ONE

CONNECTORIZED SWITCHBOARD
CABLE ASSEMBLIES

DWG SIZE c2	ISSUE 49
----------------	-------------

LUCENT
TECHNOLOGIES INC.


ED5D621-35

SHEET
c13

GROUP 224A
CABLE FOR INTEGRATED SERVICES LINE UNIT (2-WIRE)
LG 12,13,14,15
END "A"

ED5D621-35

SK 26.7 [10 1/2] TO ARM Q (INCLUDES 25.4 [10] FOR MANUFACTURING PURPOSES)

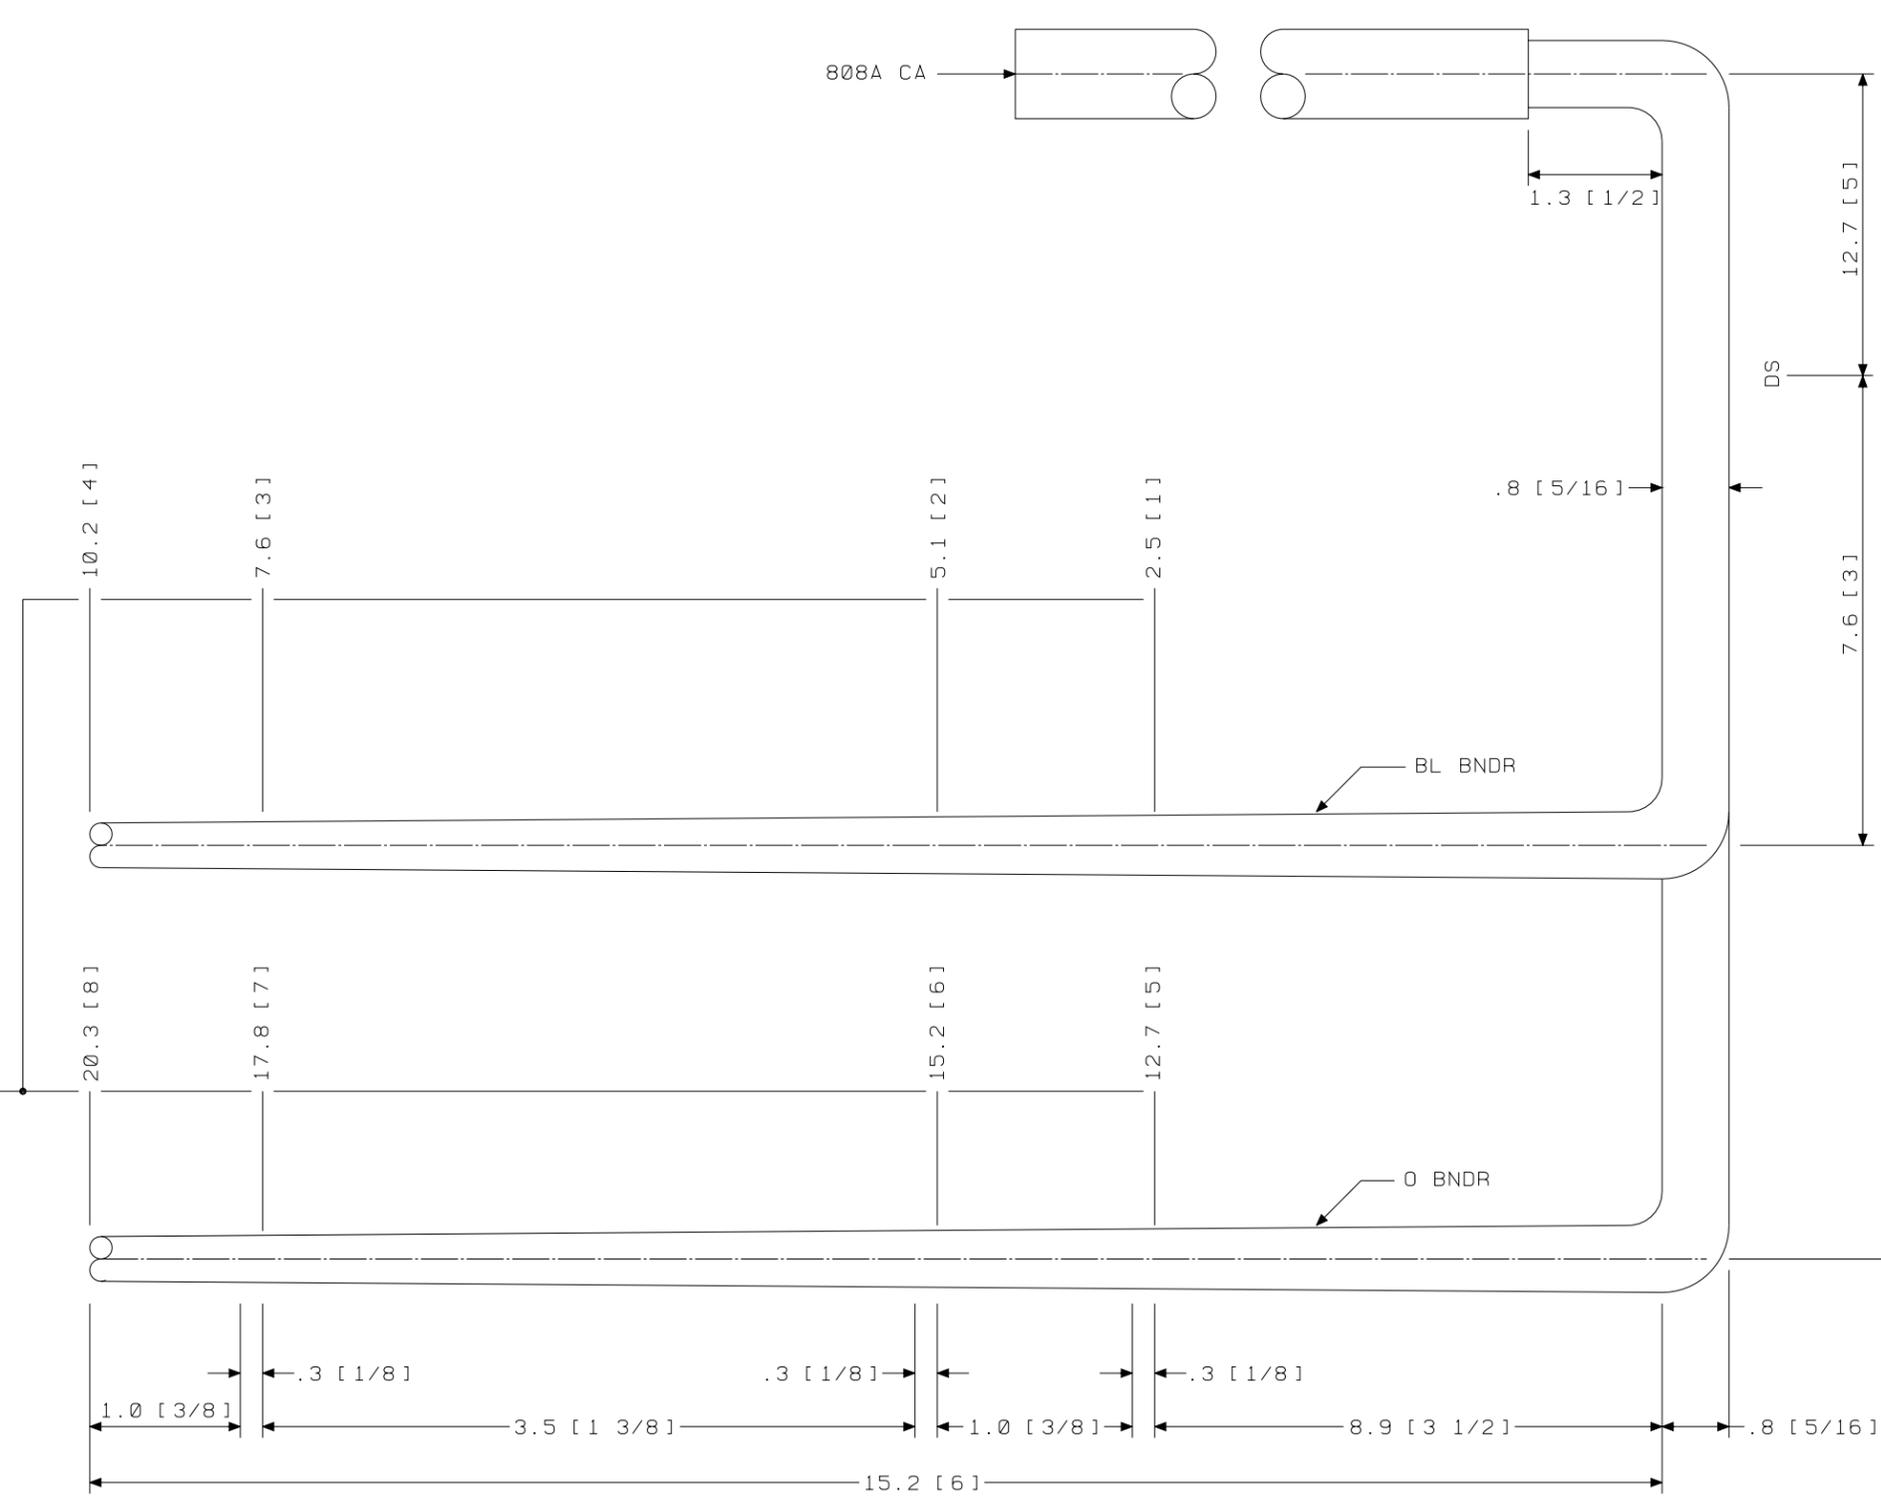


GROUP 231A
 CABLE FOR INTEGRATED SERVICES LINE UNIT (4-WIRE OSPS)
 LG 0,1,2,3
 END "A"

SEE PROPRIETARY NOTICE ON SHEET ONE		
CONNECTORIZED SWITCHBOARD CABLE ASSEMBLIES	DWG SIZE	ISSUE
	c2	49
LUCENT TECHNOLOGIES INC.	ED5D621-35	SHEET C14


ED5D621-35

SK 26.7 [10 1/2] TO ARM Q (INCLUDES 25.4 [10] FOR MANUFACTURING PURPOSES)

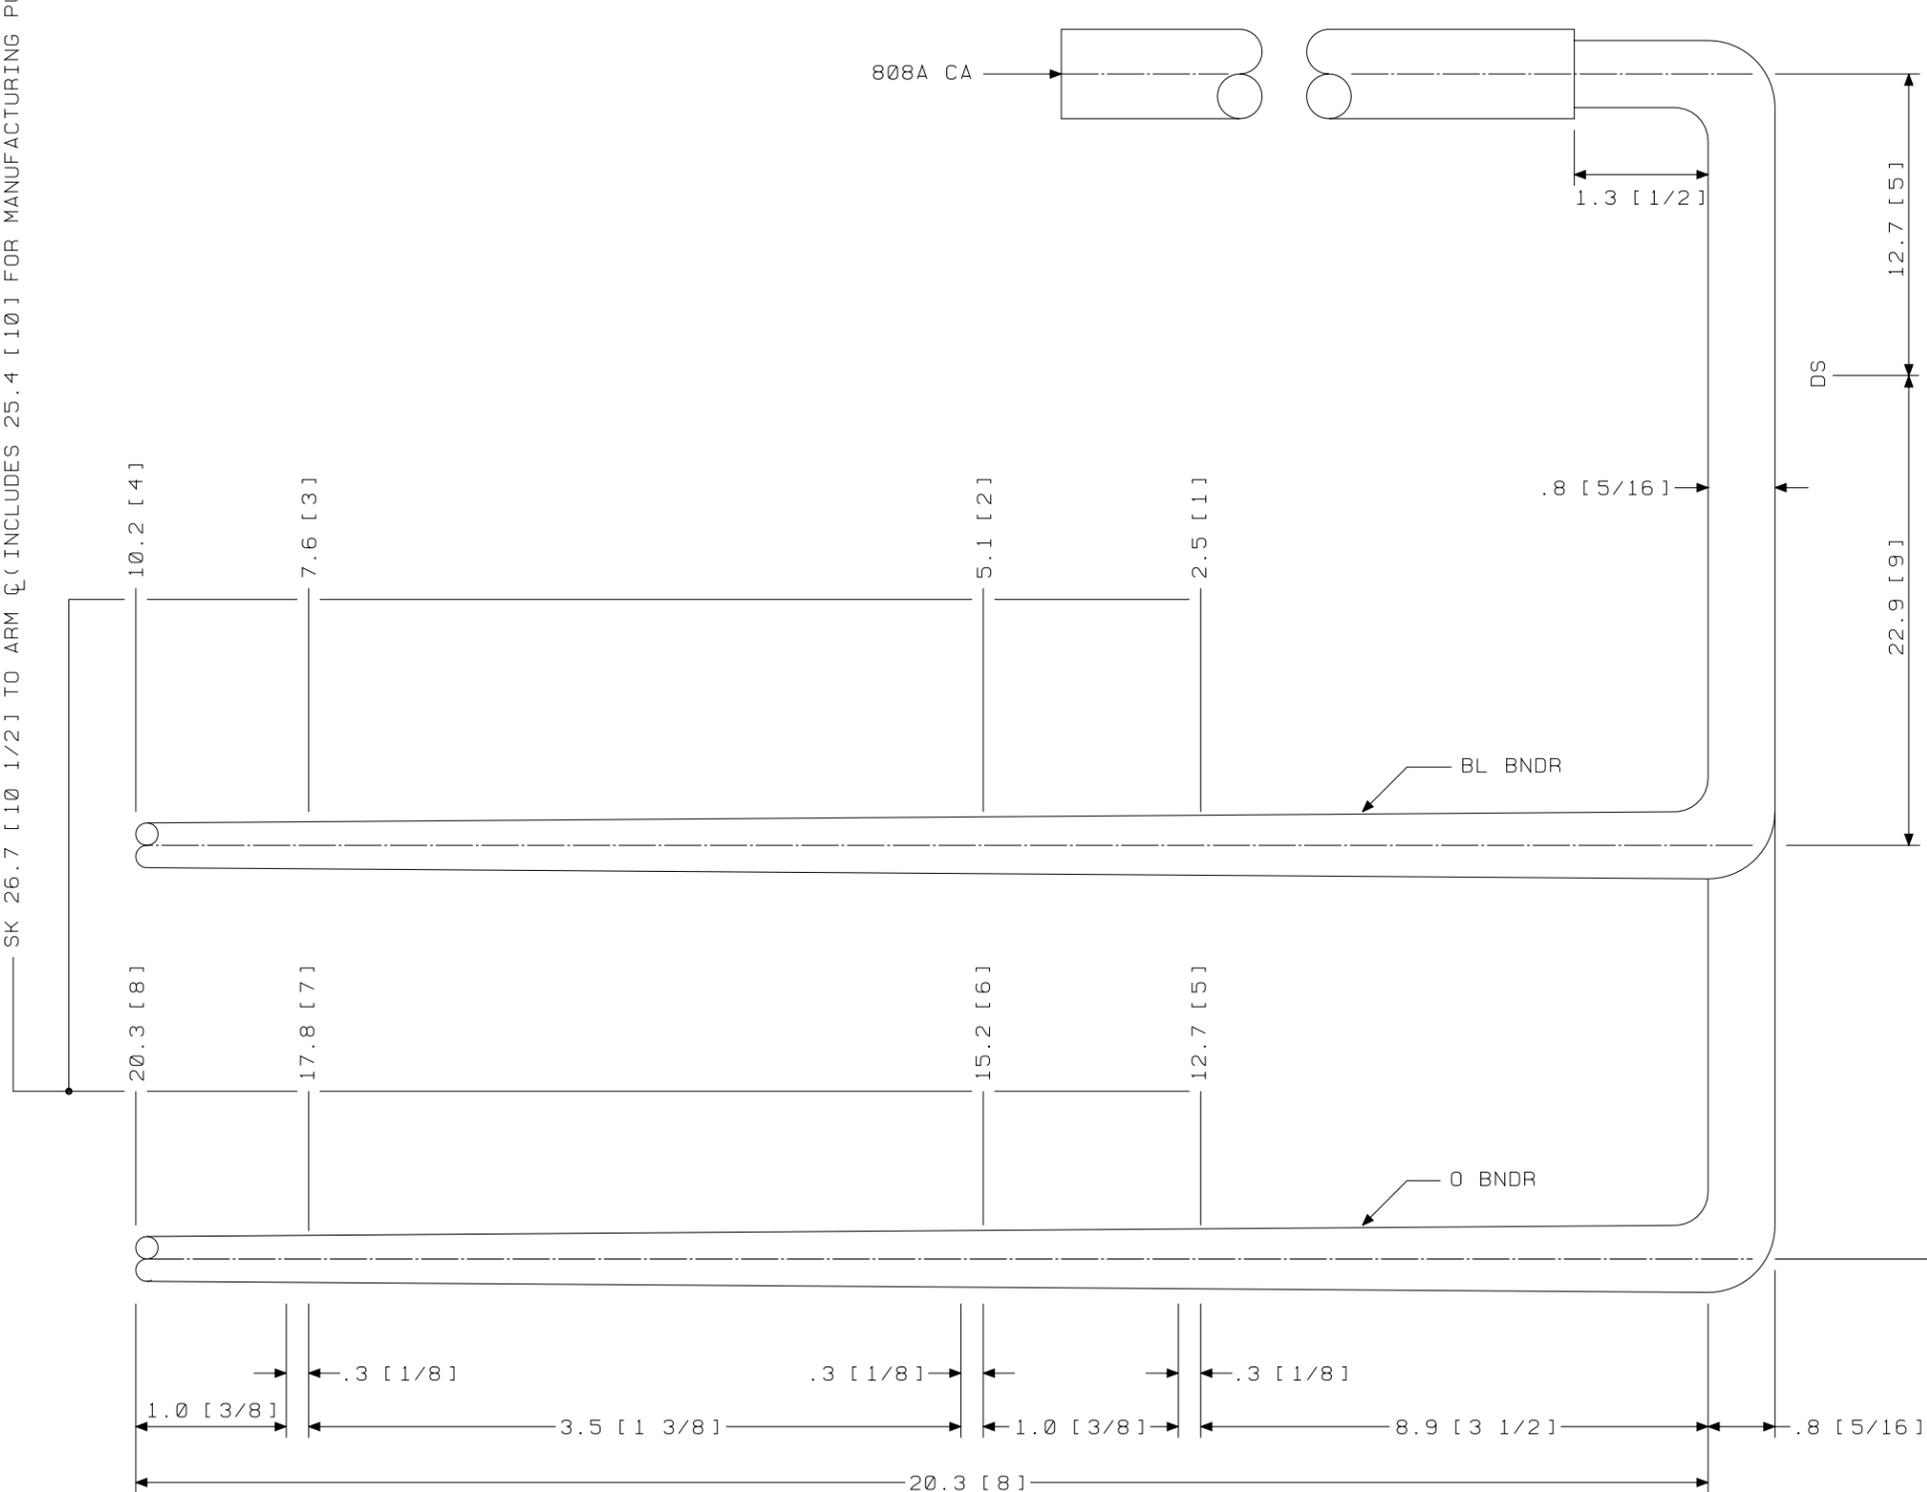

GROUP 233A
 CABLE FOR INTEGRATED SERVICES LINE UNIT (4-WIRE OSPS)
 LG 4,5,6,7
 END "A"


SEE PROPRIETARY NOTICE ON SHEET ONE		
CONNECTORIZED SWITCHBOARD CABLE ASSEMBLIES	DWG SIZE	ISSUE
	c2	49
LUCENT TECHNOLOGIES INC.	ED5D621-35	SHEET c15

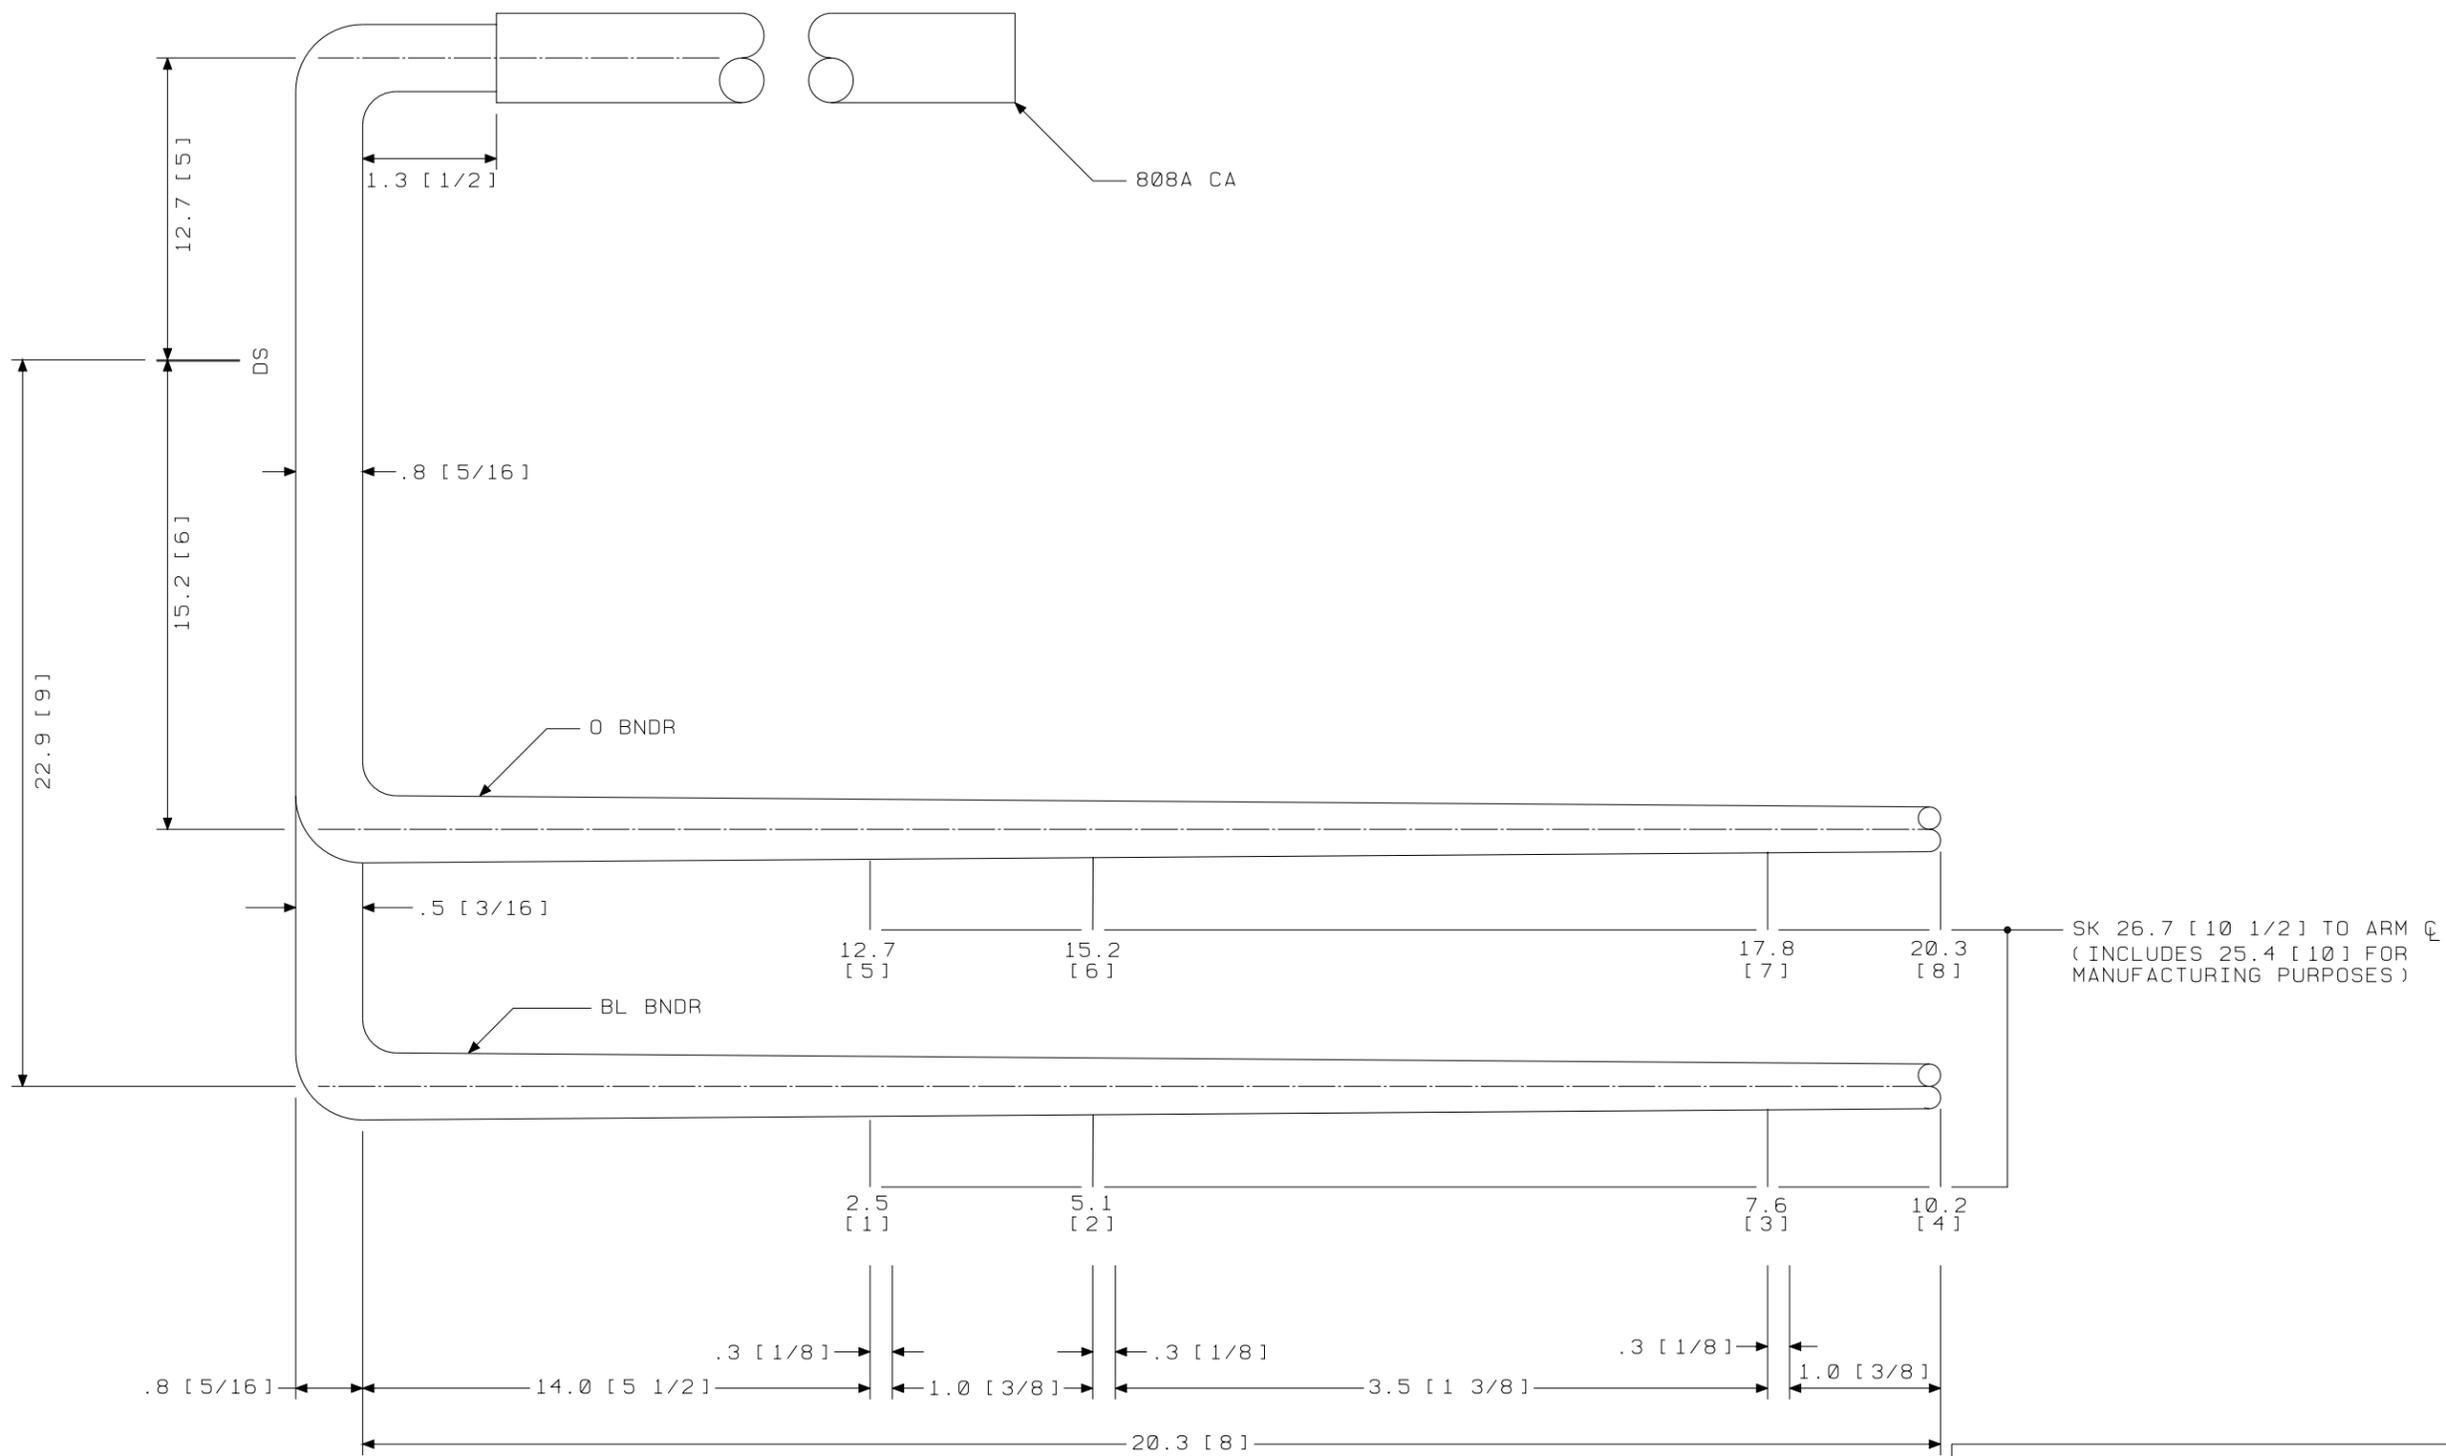

GROUP 232A
 CABLE FOR INTEGRATED SERVICES LINE UNIT (4-WIRE OSPS)
 LG 8,9,10,11
 END "A"

SEE PROPRIETARY NOTICE ON SHEET ONE		
CONNECTORIZED SWITCHBOARD CABLE ASSEMBLIES		DWG SIZE c2
LUCENT TECHNOLOGIES INC.		ISSUE 49
ED5D621-35		SHEET c16

ED5D621-35

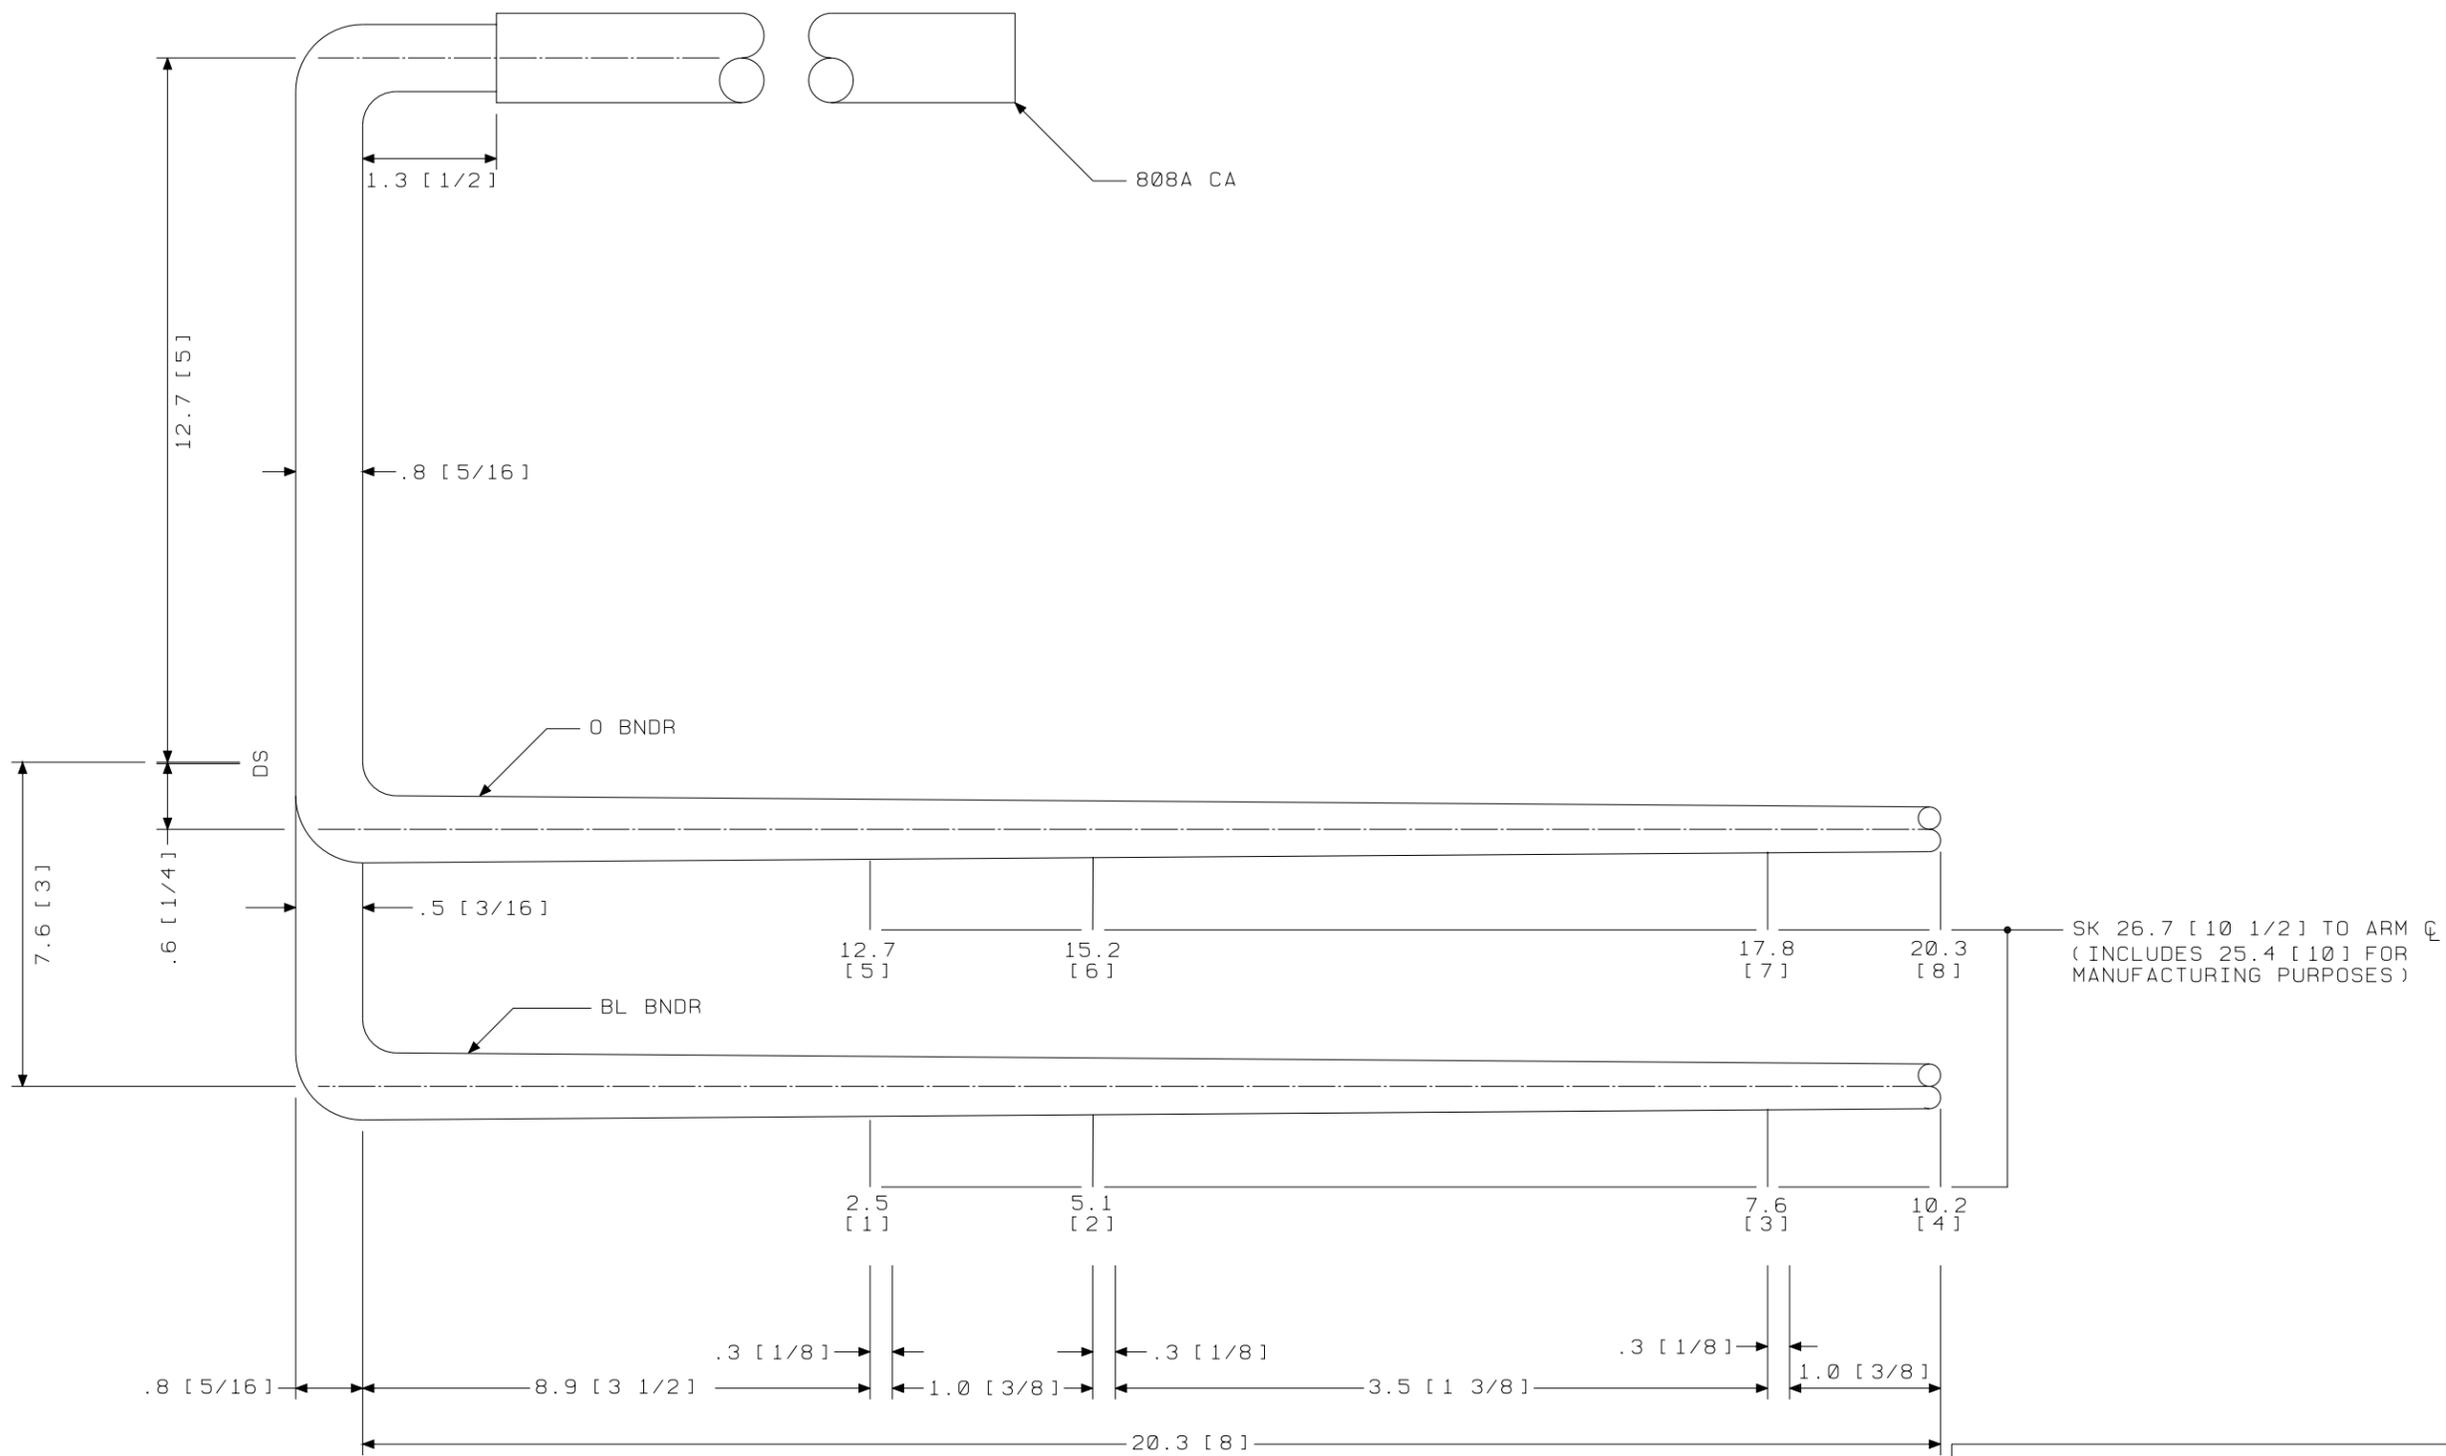

GROUP 234A
 CABLE FOR INTEGRATED SERVICES LINE UNIT (4-WIRE OSPS)
 LG 12,13,14,15
 END "A"

SEE PROPRIETARY NOTICE ON SHEET ONE

CONNECTORIZED SWITCHBOARD
 CABLE ASSEMBLIES


DWG SIZE c2	ISSUE 49
----------------	-------------

LUCENT
 TECHNOLOGIES INC.

ED5D621-35

SHEET
 c17


SK 26.7 [10 1/2] TO ARM Q (INCLUDES 25.4 [10] FOR MANUFACTURING PURPOSES)

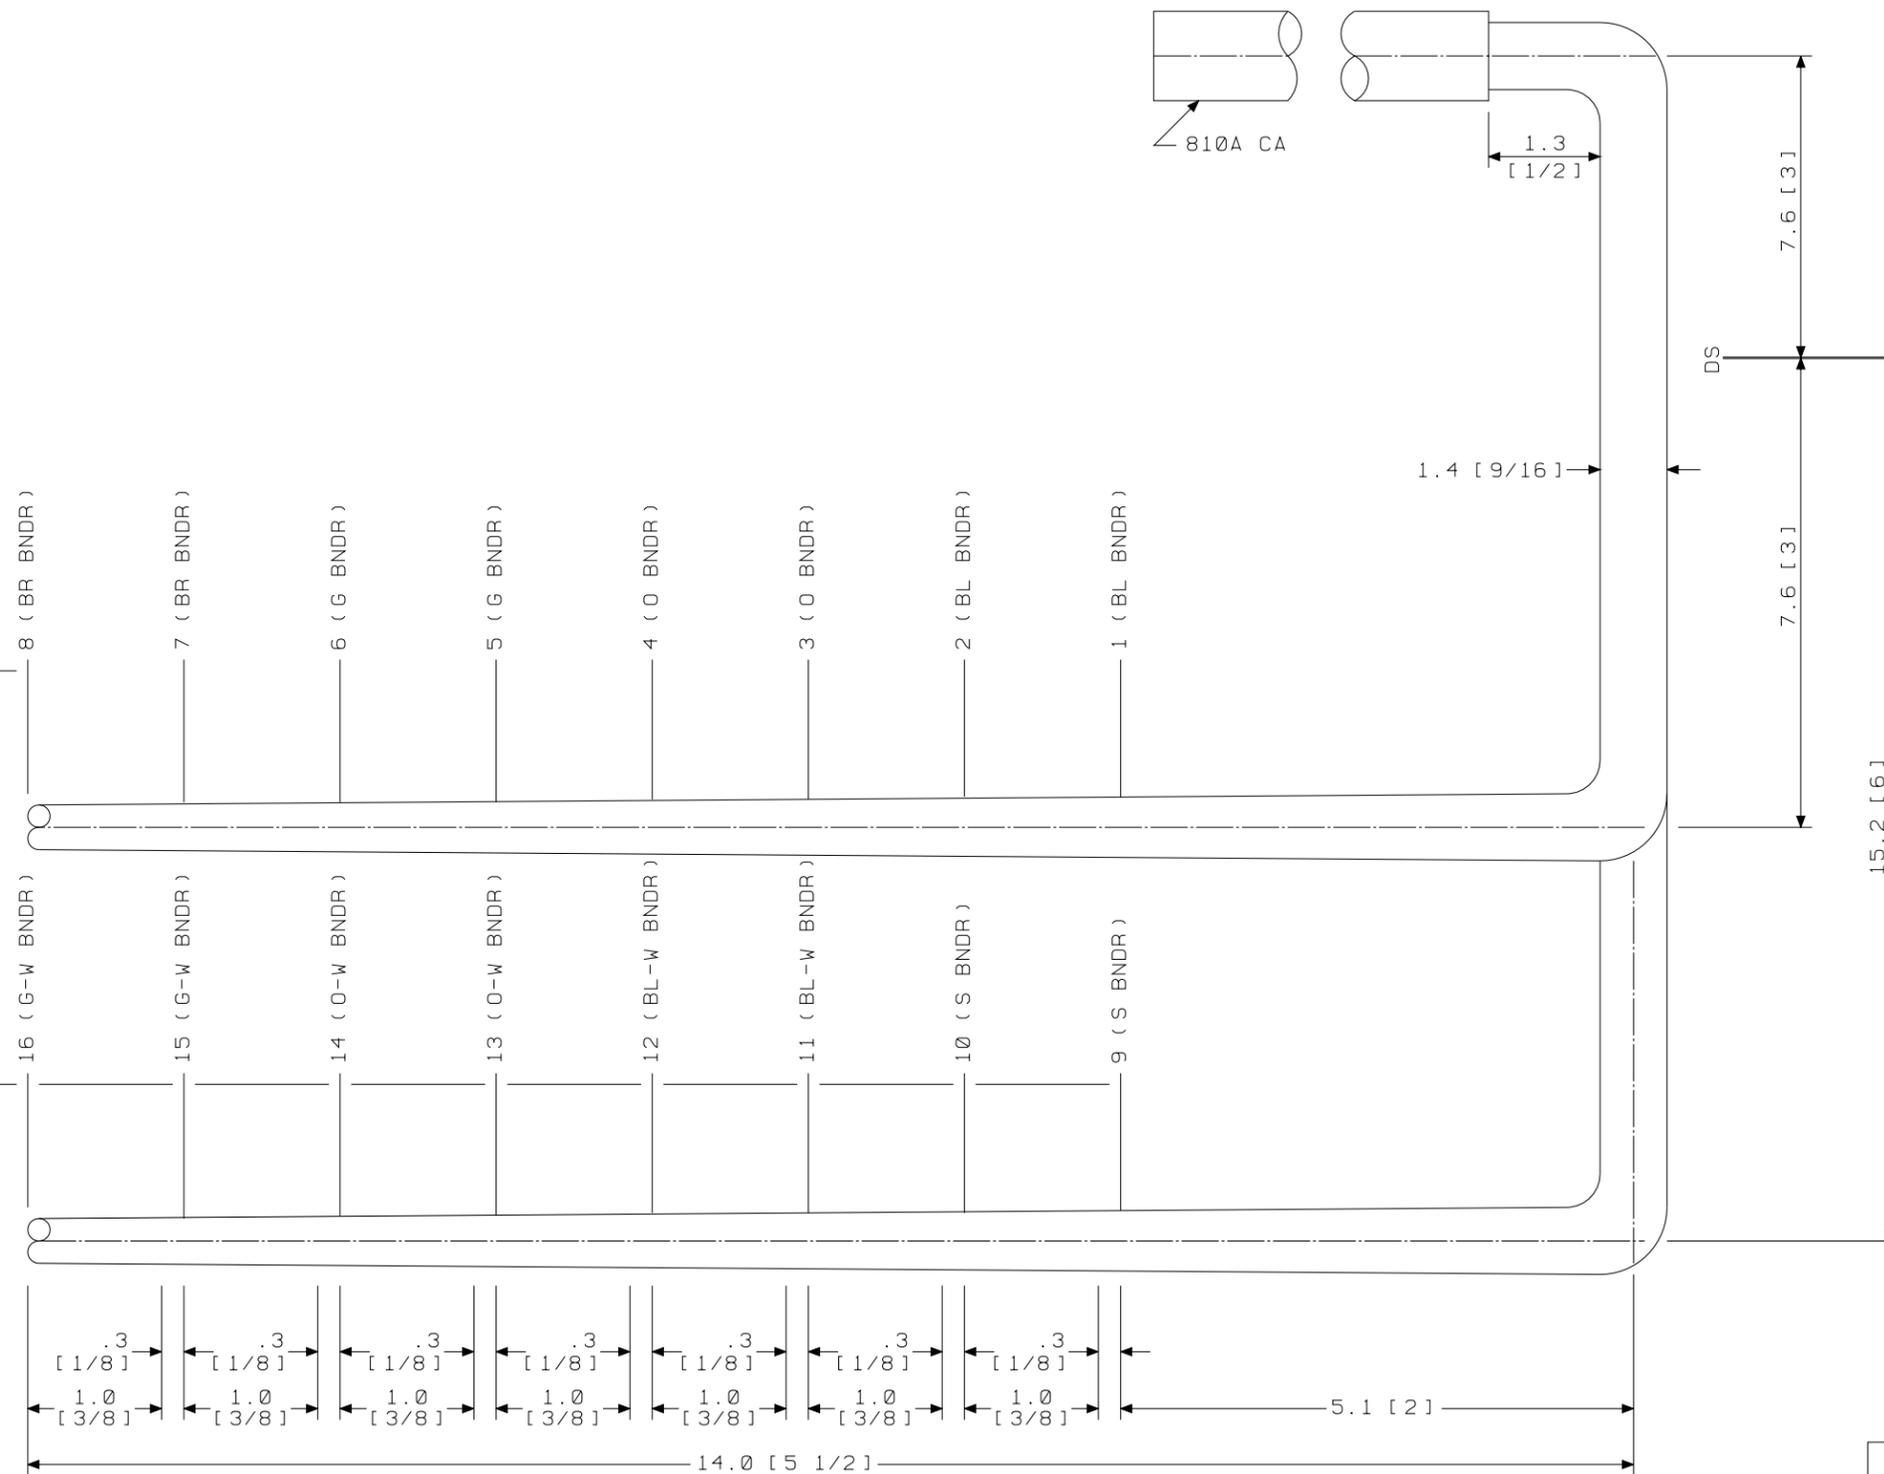

GROUP 235A
 CABLE FOR INTEGRATED SERVICES LINE UNIT (4-WIRE OSPS)
 LG 00-03
 END "A"


SEE PROPRIETARY NOTICE ON SHEET ONE		
CONNECTORIZED SWITCHBOARD CABLE ASSEMBLIES	DWG SIZE	ISSUE
	c2	49
LUCENT TECHNOLOGIES INC.	ED5D621-35	SHEET C18

SK 26.7 [10 1/2] TO ARM Q (INCLUDES 25.4 [10] FOR MANUFACTURING PURPOSES)

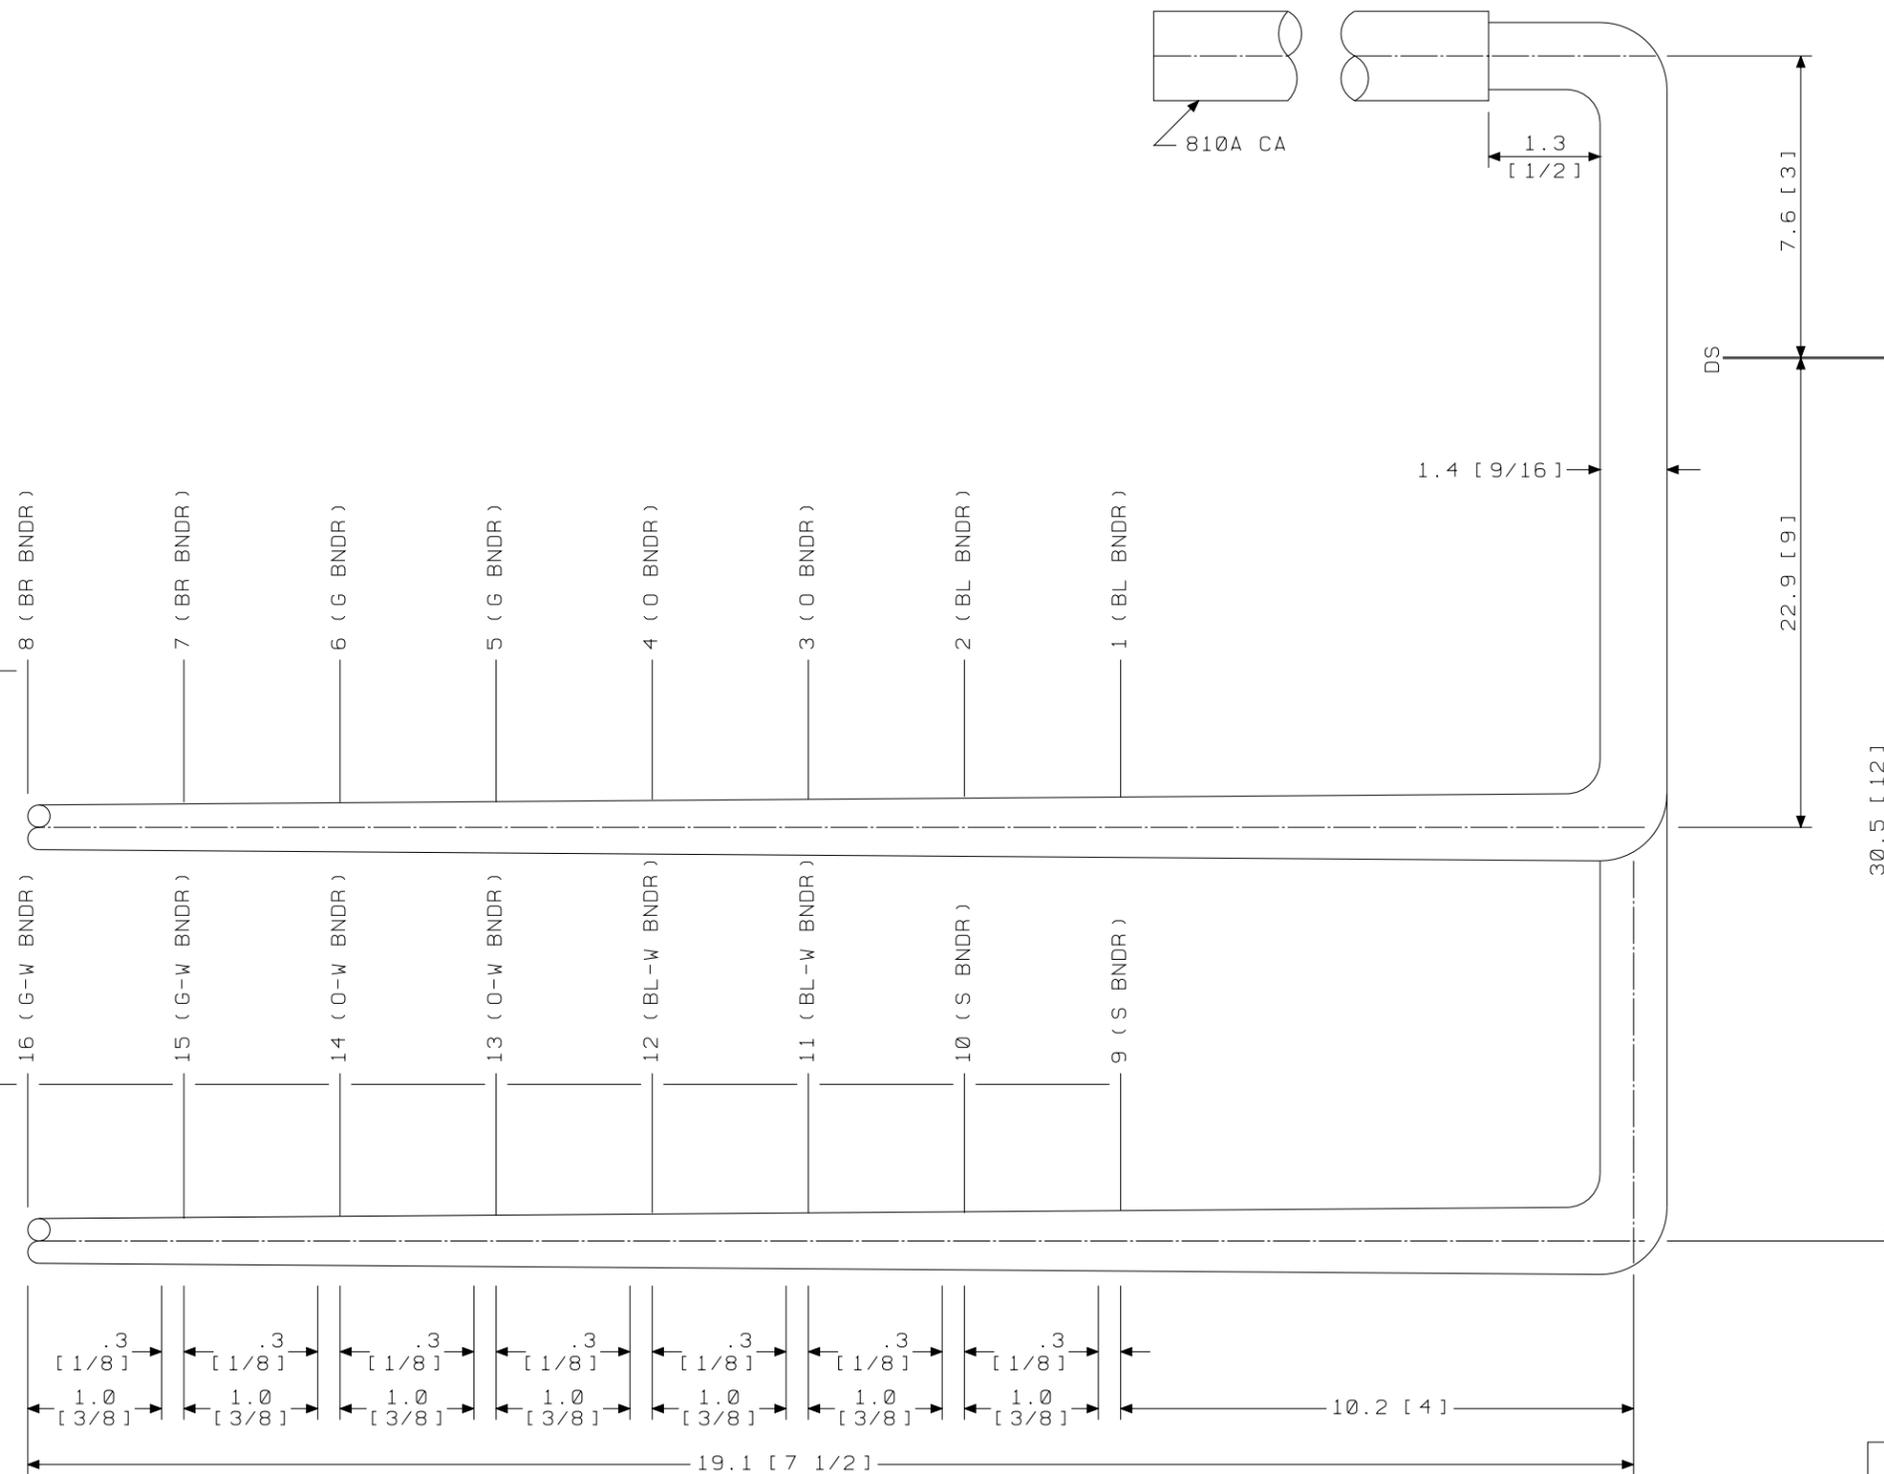


GROUP 237A
CABLE FOR INTEGRATED SERVICES LINE UNIT (4-WIRE OSPS)
LG 04-07
END "A"

SEE PROPRIETARY NOTICE ON SHEET ONE		
CONNECTORIZED SWITCHBOARD CABLE ASSEMBLIES	DWG SIZE	ISSUE
	c2	49
LUCENT TECHNOLOGIES INC.	ED5D621-35	SHEET c19

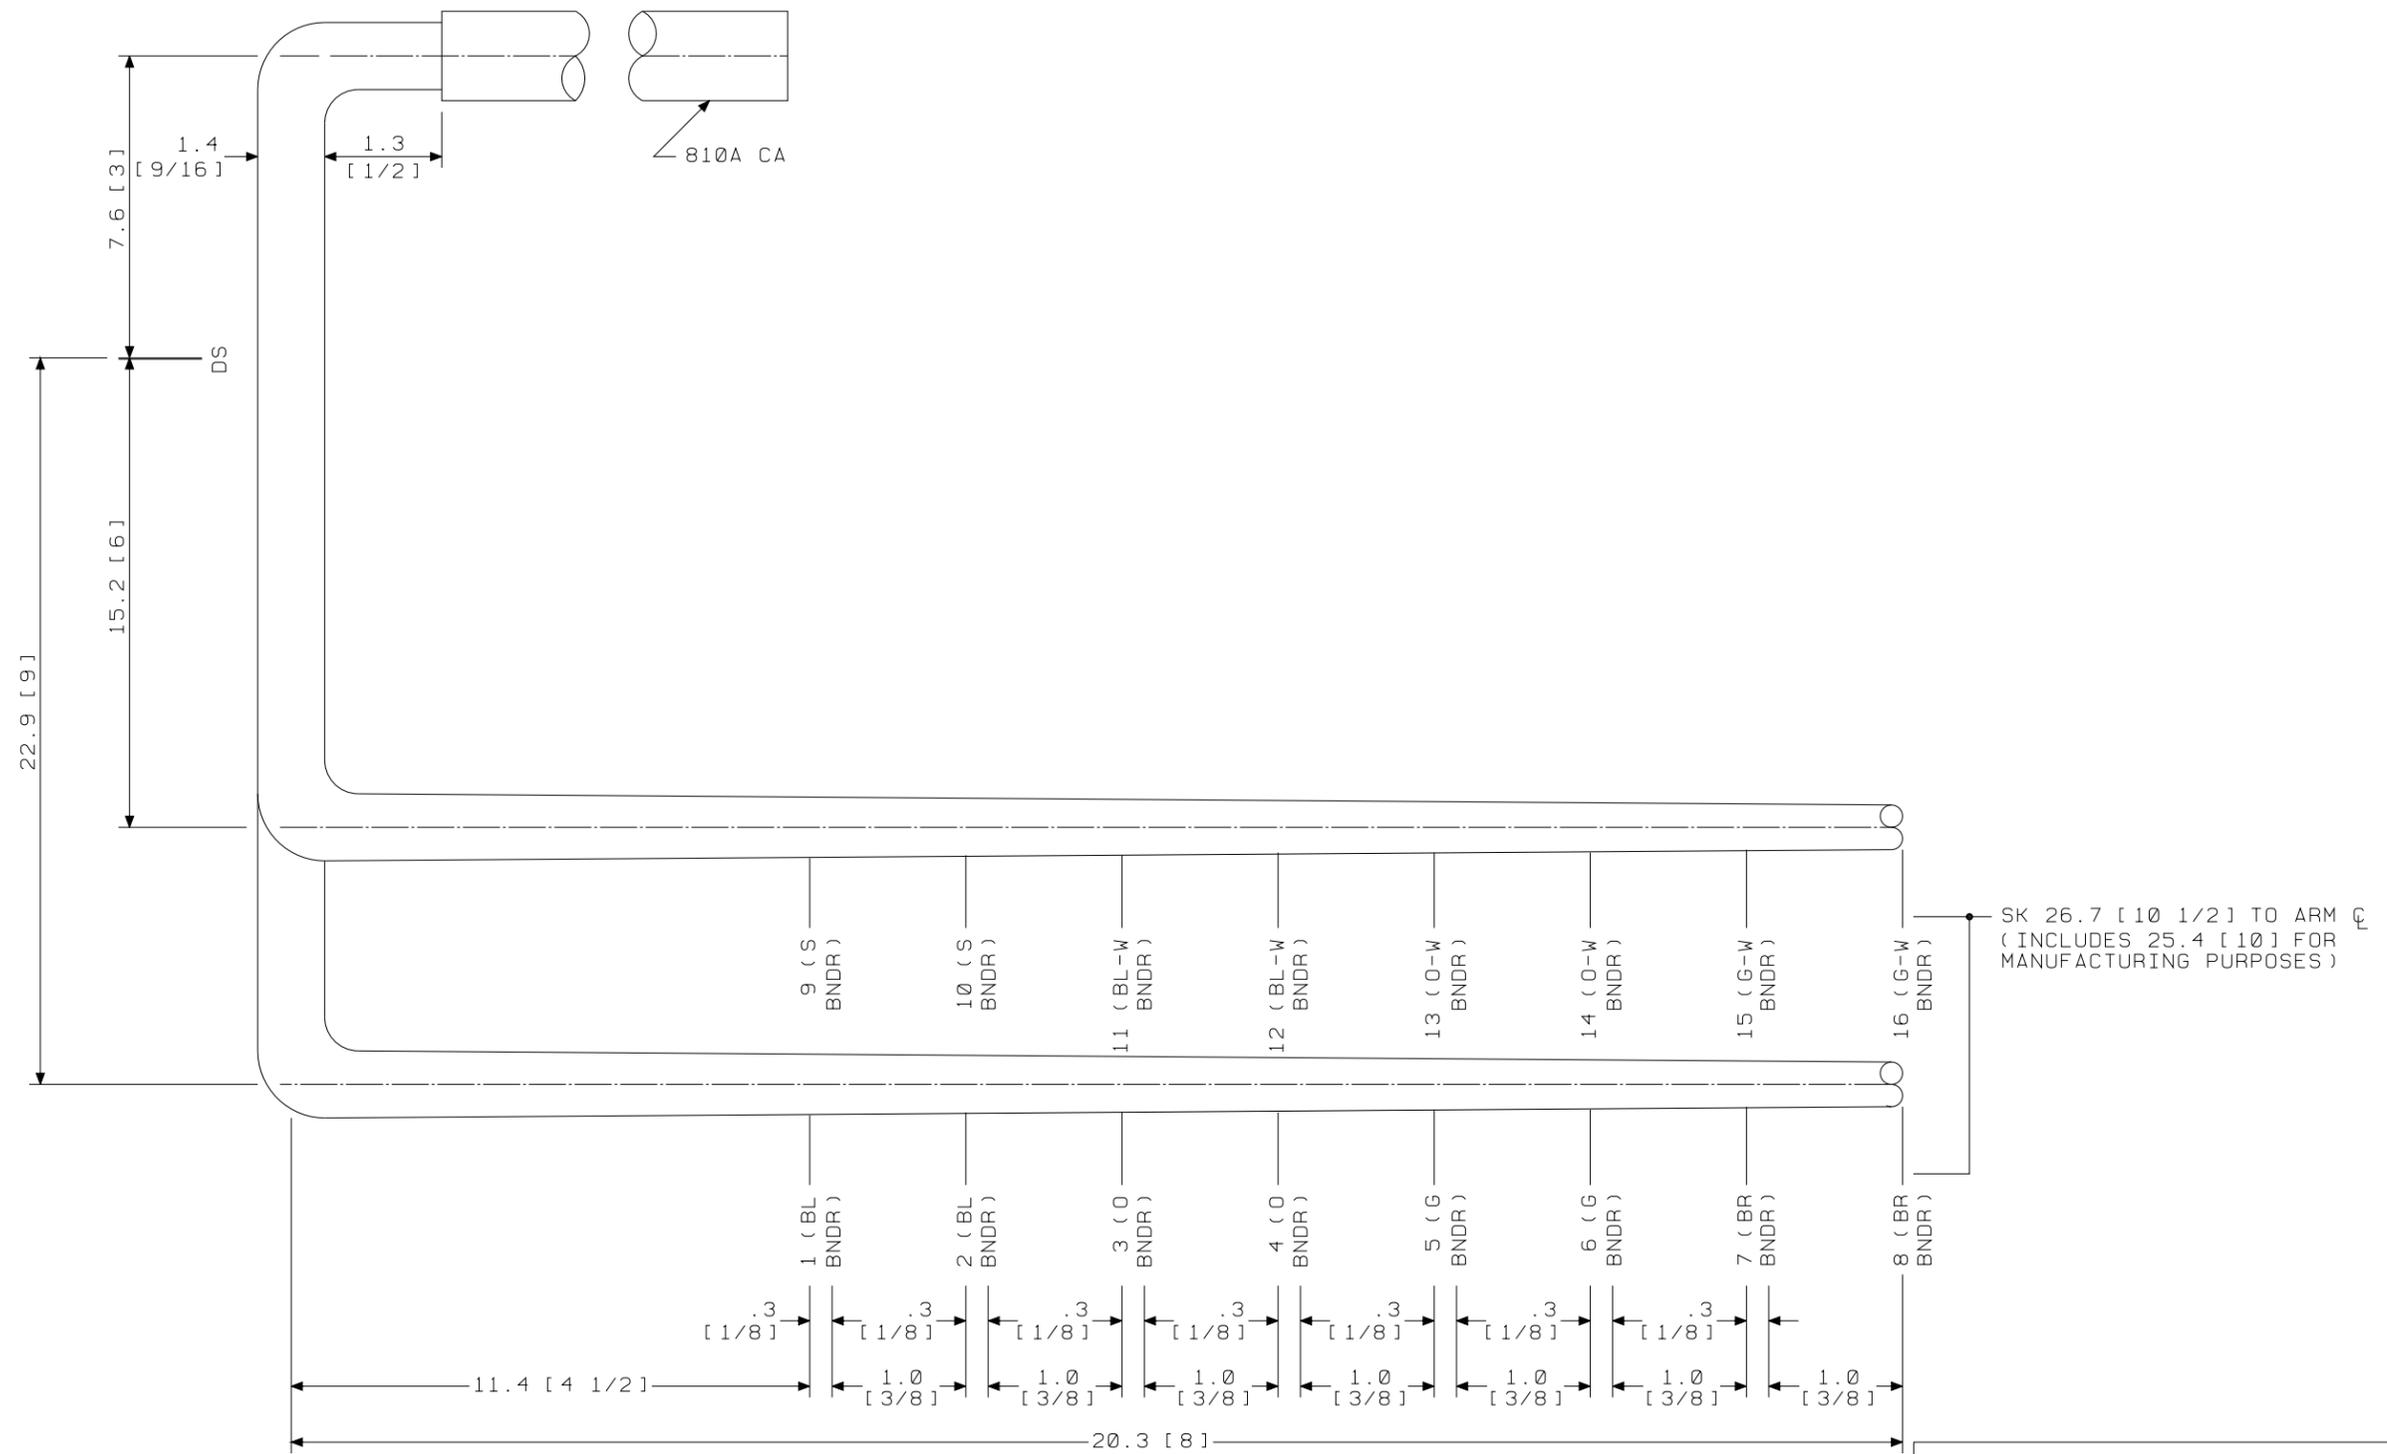

GROUP 236A
 CABLE FOR INTEGRATED SERVICES LINE UNIT (4-WIRE OSPS)
 LG 08-11
 END "A"


SEE PROPRIETARY NOTICE ON SHEET ONE		
CONNECTORIZED SWITCHBOARD CABLE ASSEMBLIES		
	DWG SIZE c2	ISSUE 49
LUCENT TECHNOLOGIES INC.	ED5D621-35	SHEET c20

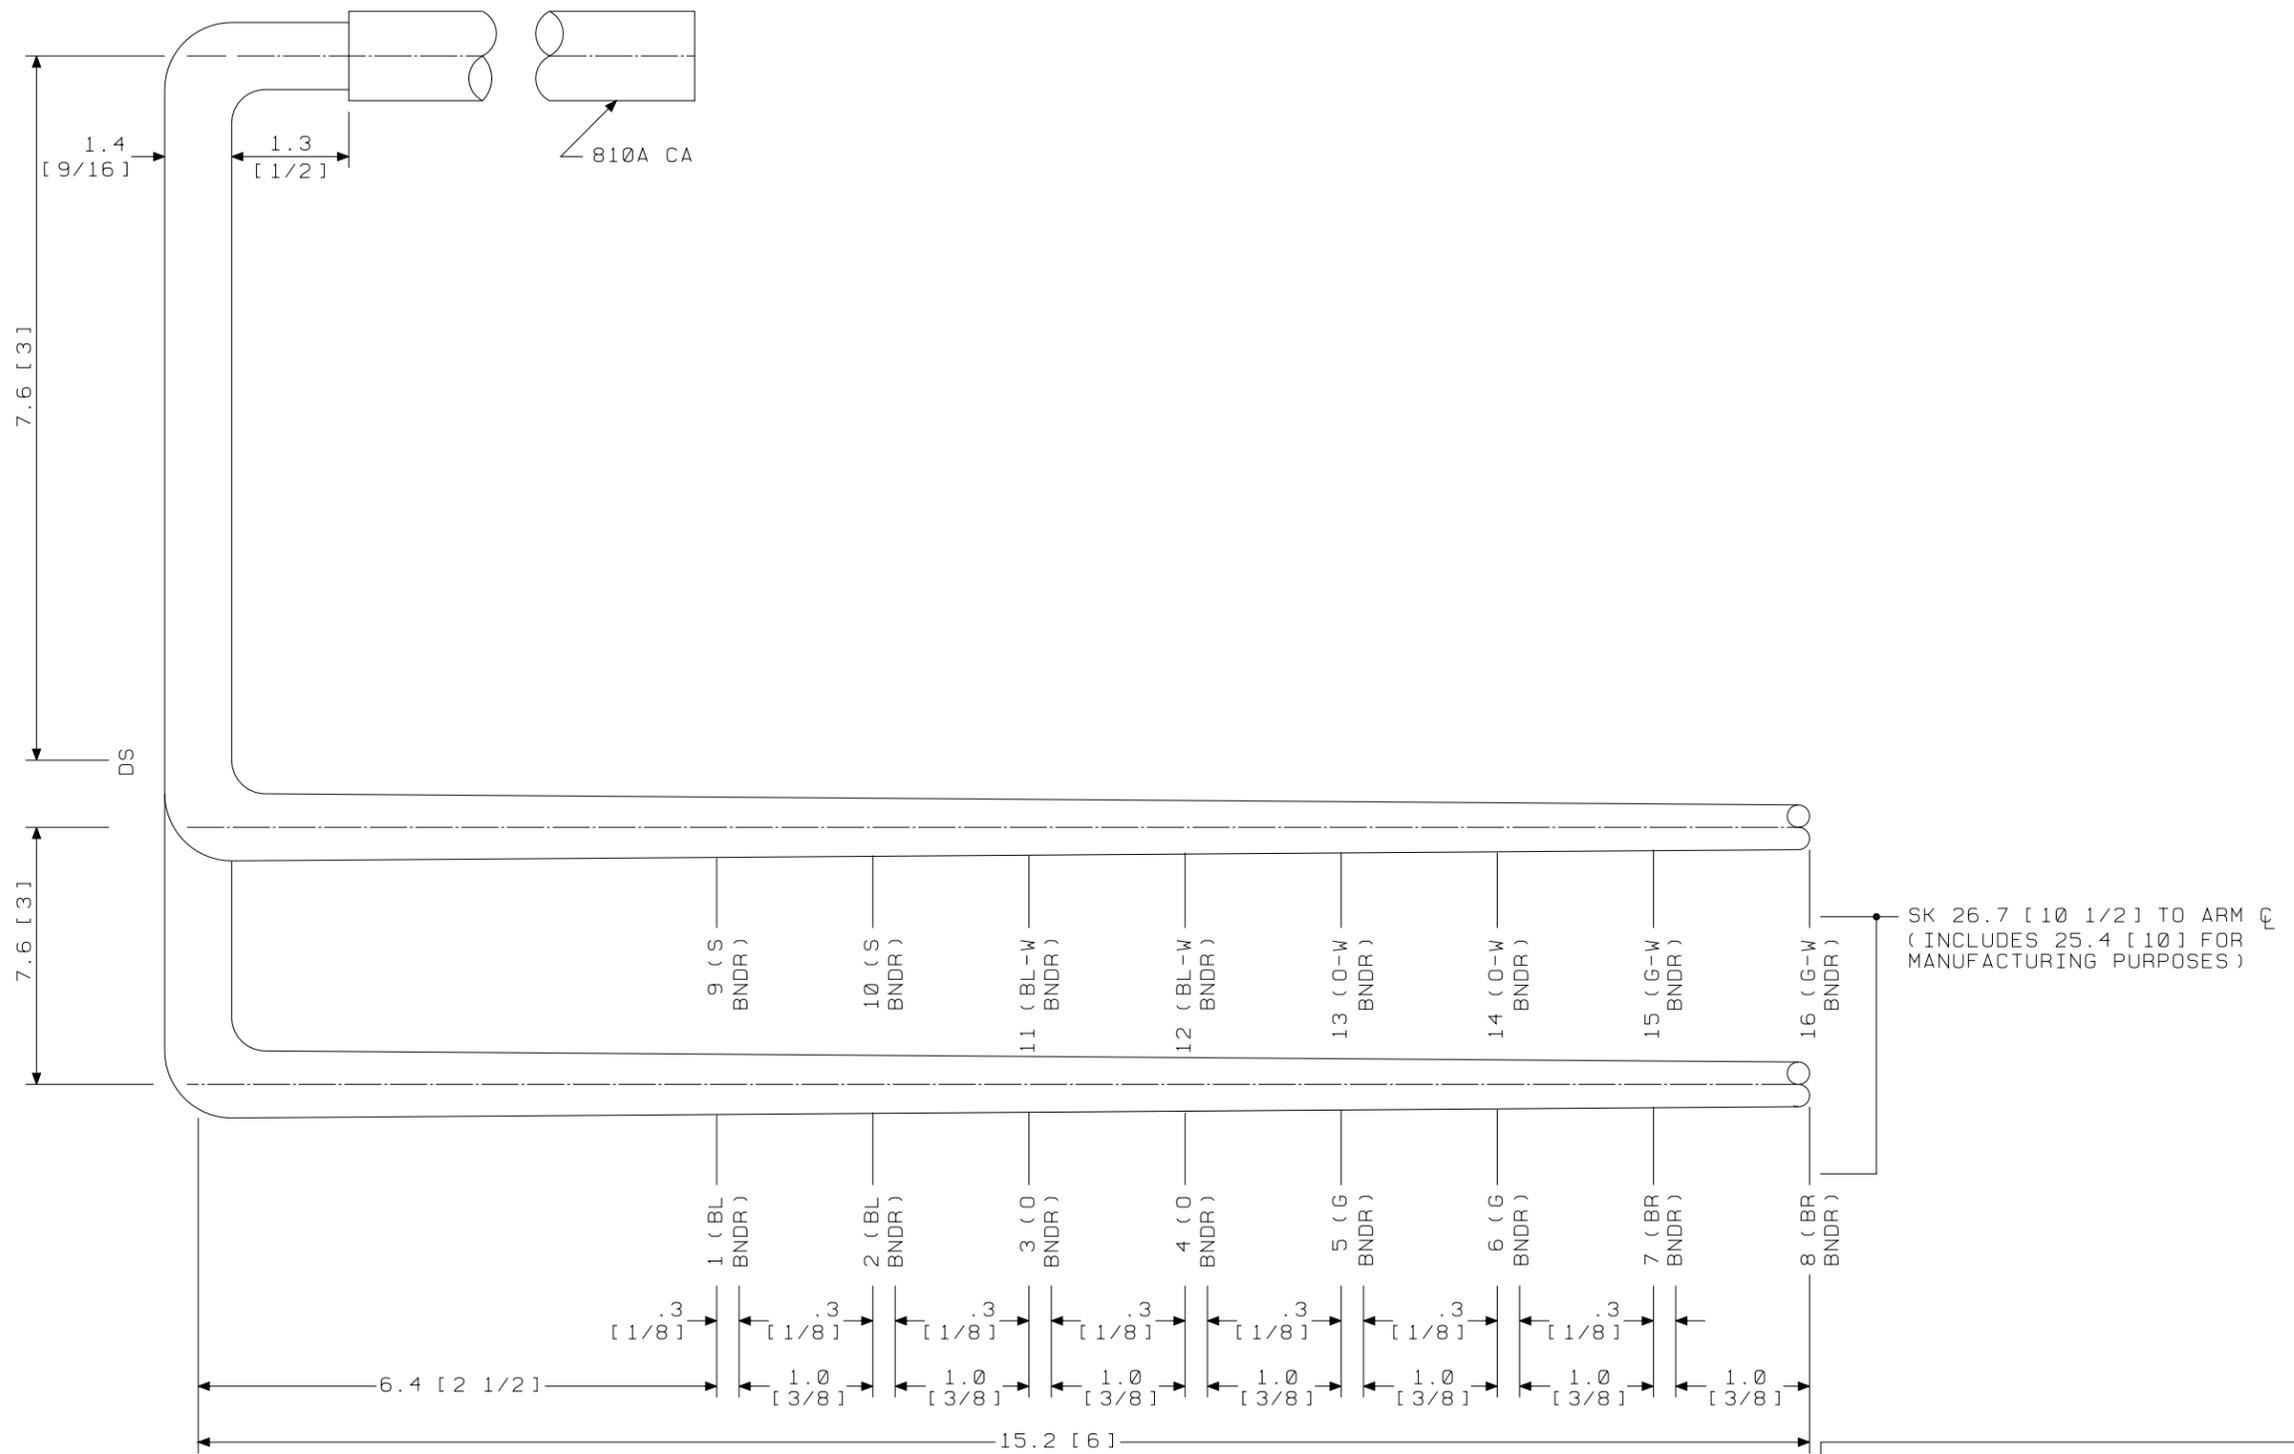

GROUP 238A
 CABLE FOR INTEGRATED SERVICES LINE UNIT (4-WIRE OSPS)
 LG 12-15
 END "A"

SEE PROPRIETARY NOTICE ON SHEET ONE		
CONNECTORIZED SWITCHBOARD CABLE ASSEMBLIES		DWG SIZE c2
LUCENT TECHNOLOGIES INC.		ISSUE 49
ED5D621-35		SHEET c21

SK 26.7 [10 1/2] TO ARM C (INCLUDES 25.4 [10] FOR MANUFACTURING PURPOSES)

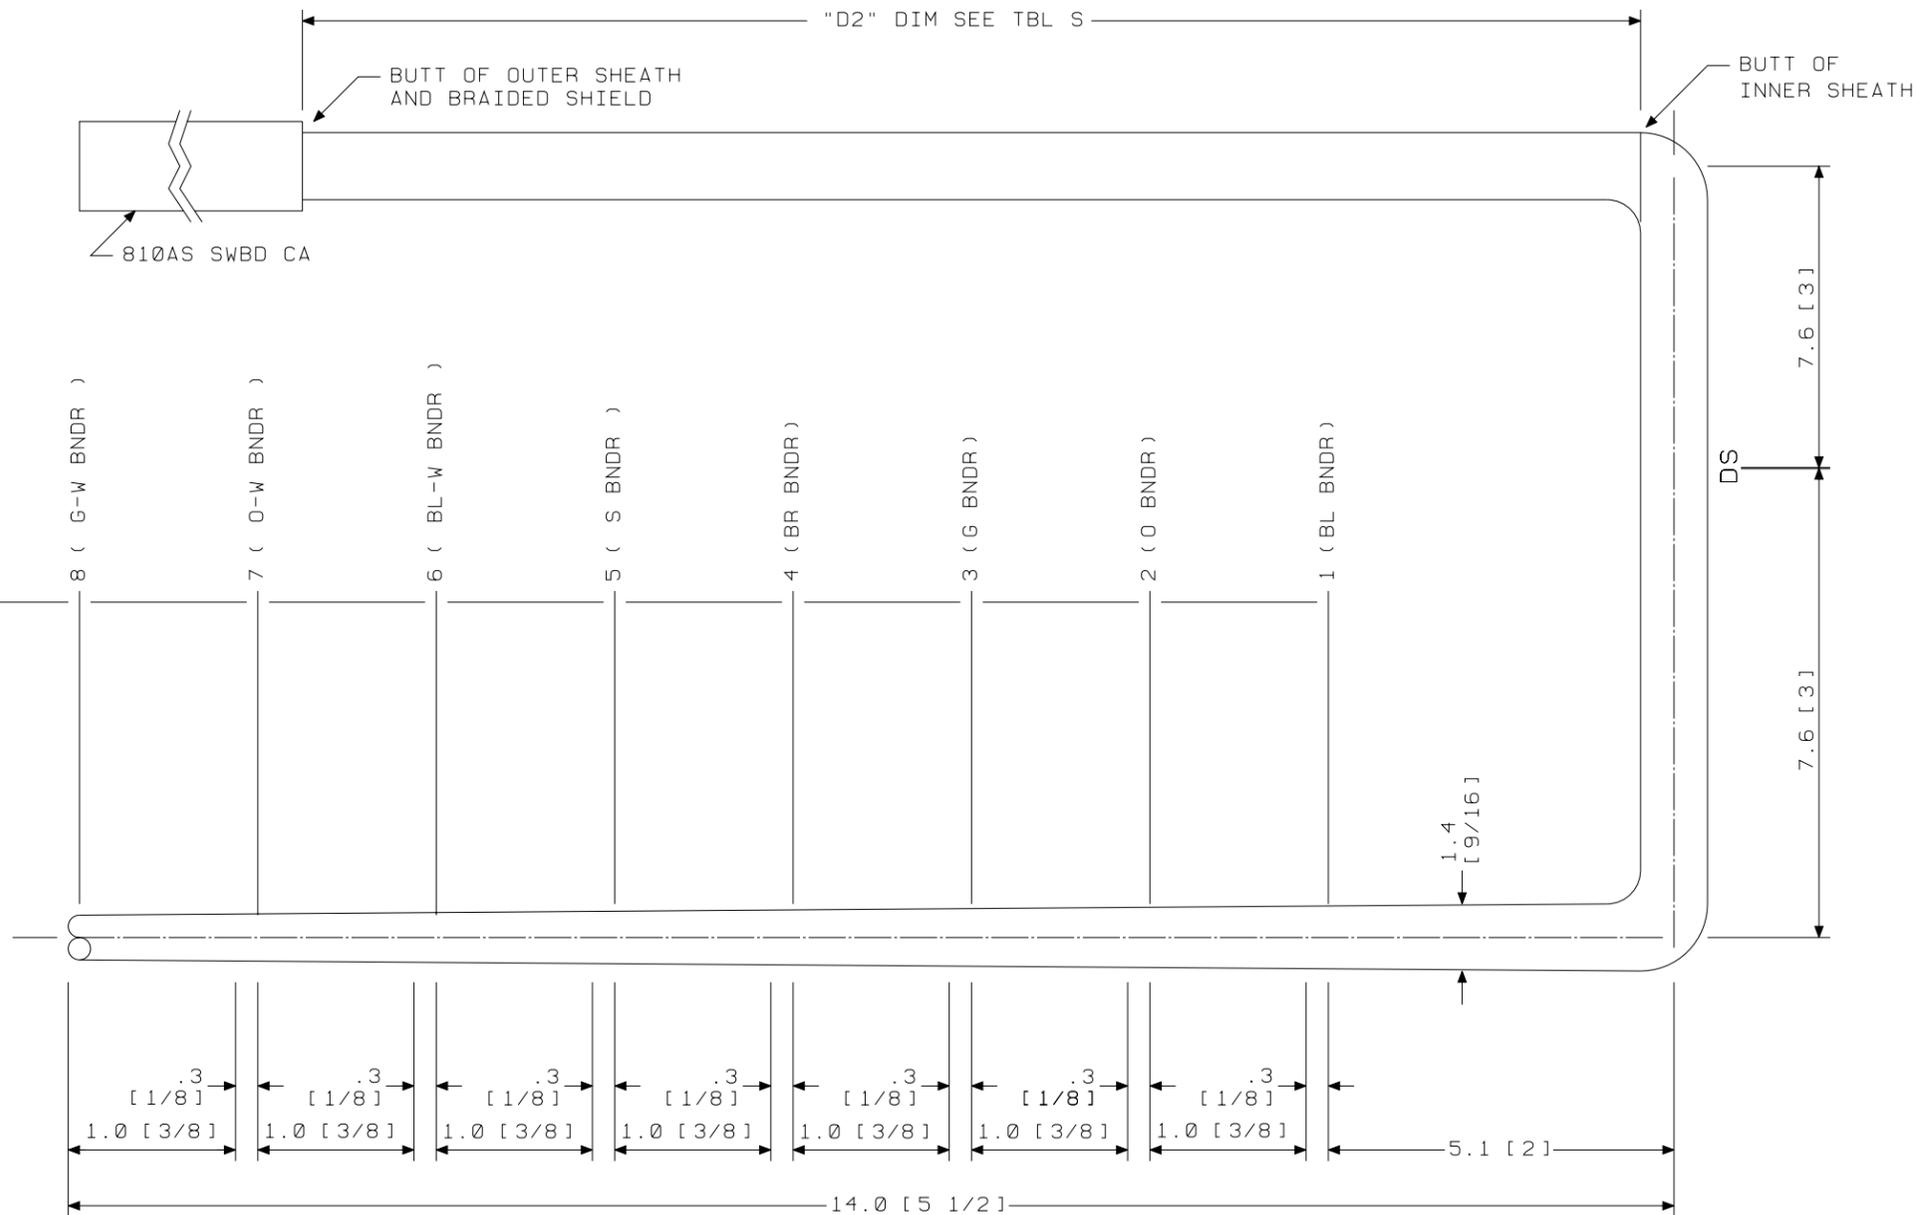


GROUP 501A OR 551A
 CABLE FOR INTERGRATED SERVICES LINE UNIT (4-WIRE) PBX APPL ONLY
 LG 00,01
 END "A"

SEE PROPRIETARY NOTICE ON SHEET ONE		
CONNECTORIZED SWITCHBOARD CABLE ASSEMBLIES	DWG SIZE	ISSUE
	c2	49
LUCENT TECHNOLOGIES INC.	ED5D621-35	SHEET C22

ED5D621-35


26.7 [10 1/2] TO ARM ϕ (INCLUDES 25.4 [10] FOR MANUFACTURING PURPOSES)

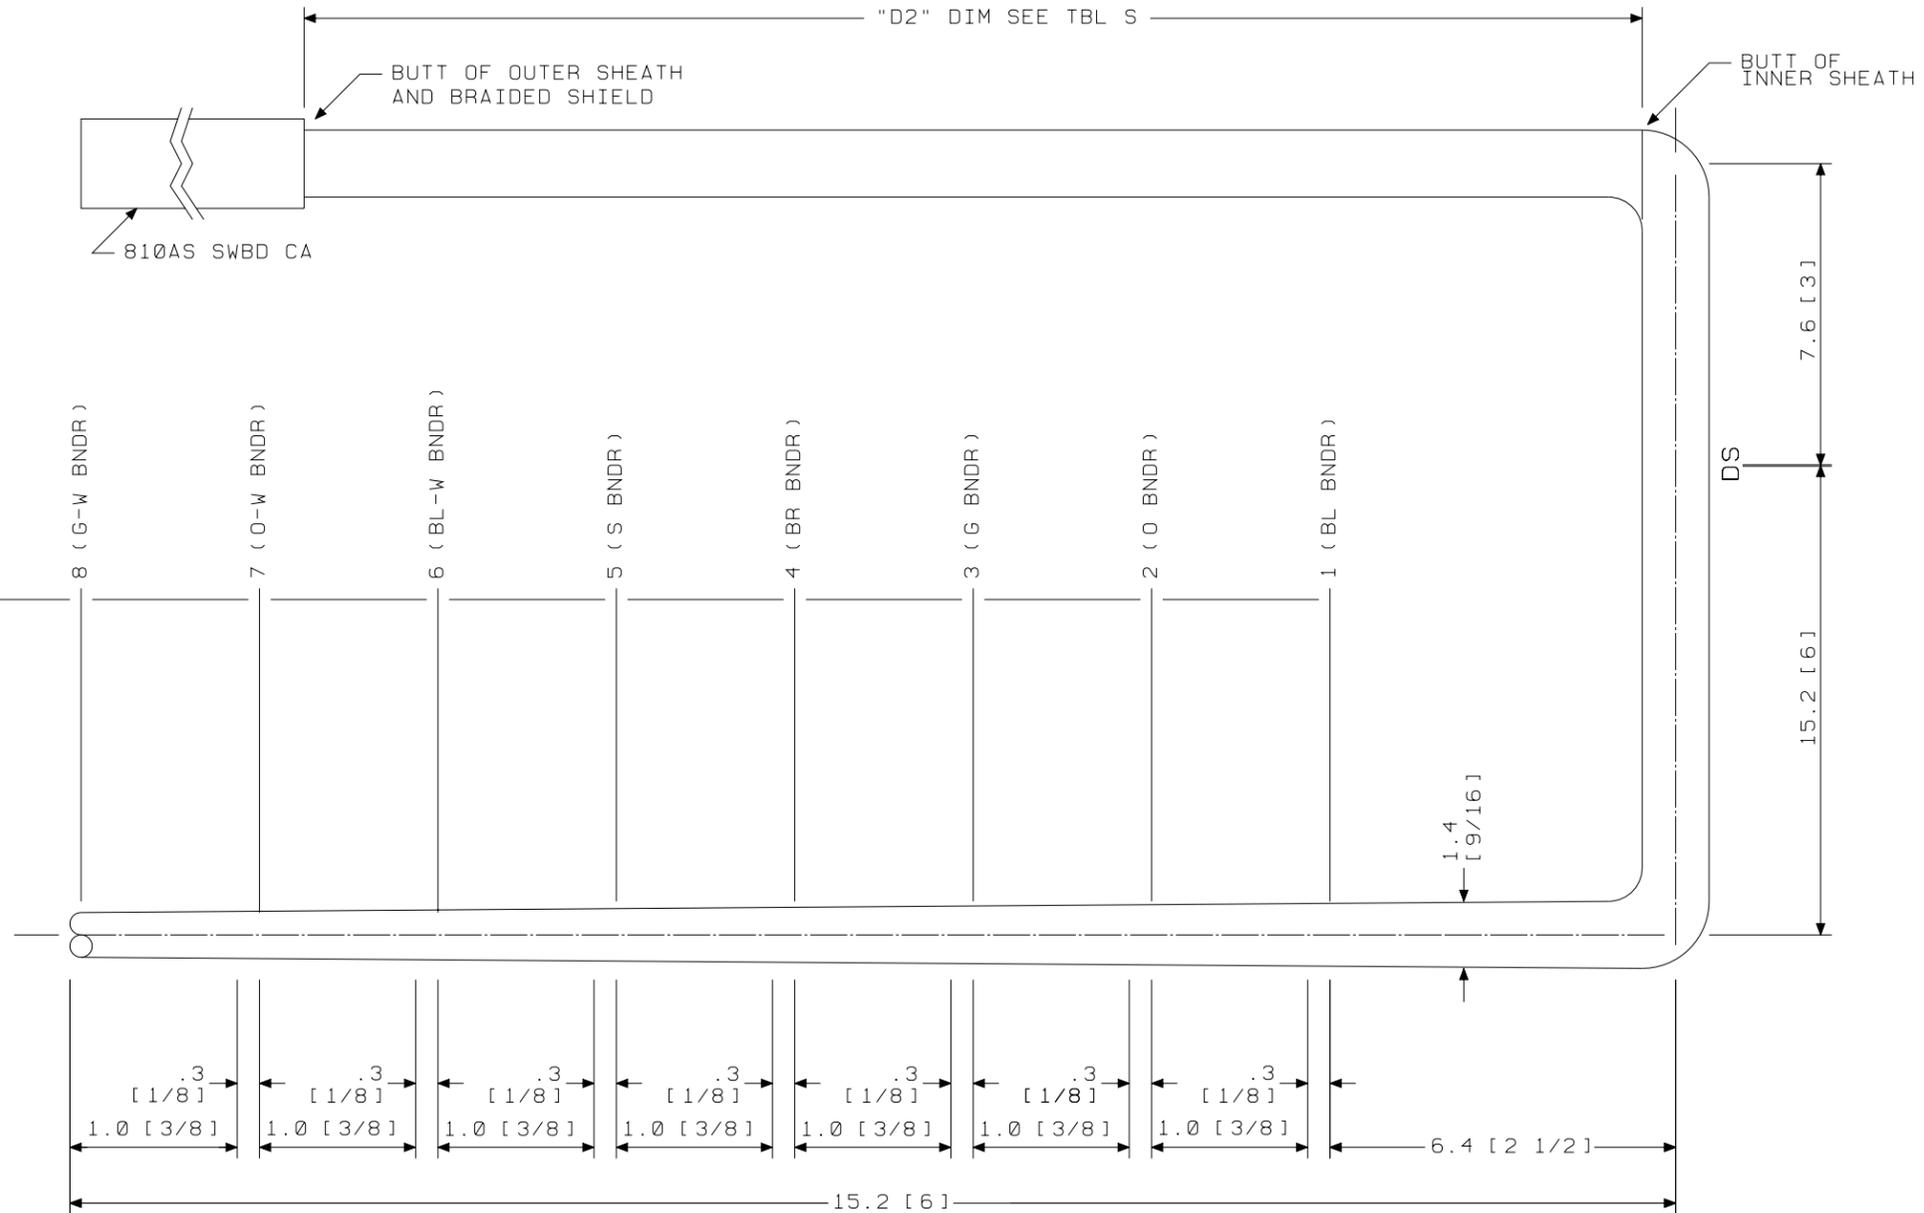

GROUP 503A OR 553A
 CABLE FOR INTERGRATED SERVICES LINE UNIT (4-WIRE) PBX APPL ONLY
 LG 02.03
 END "A"


SEE PROPRIETARY NOTICE ON SHEET ONE		
CONNECTORIZED SWITCHBOARD CABLE ASSEMBLIES	DWG SIZE	ISSUE
	c2	49
LUCENT TECHNOLOGIES INC.	ED5D621-35	SHEET C23

26.7 [10 1/2] TO ARM Q (INCLUDES 25.4 [10] FOR MANUFACTURING PURPOSES)

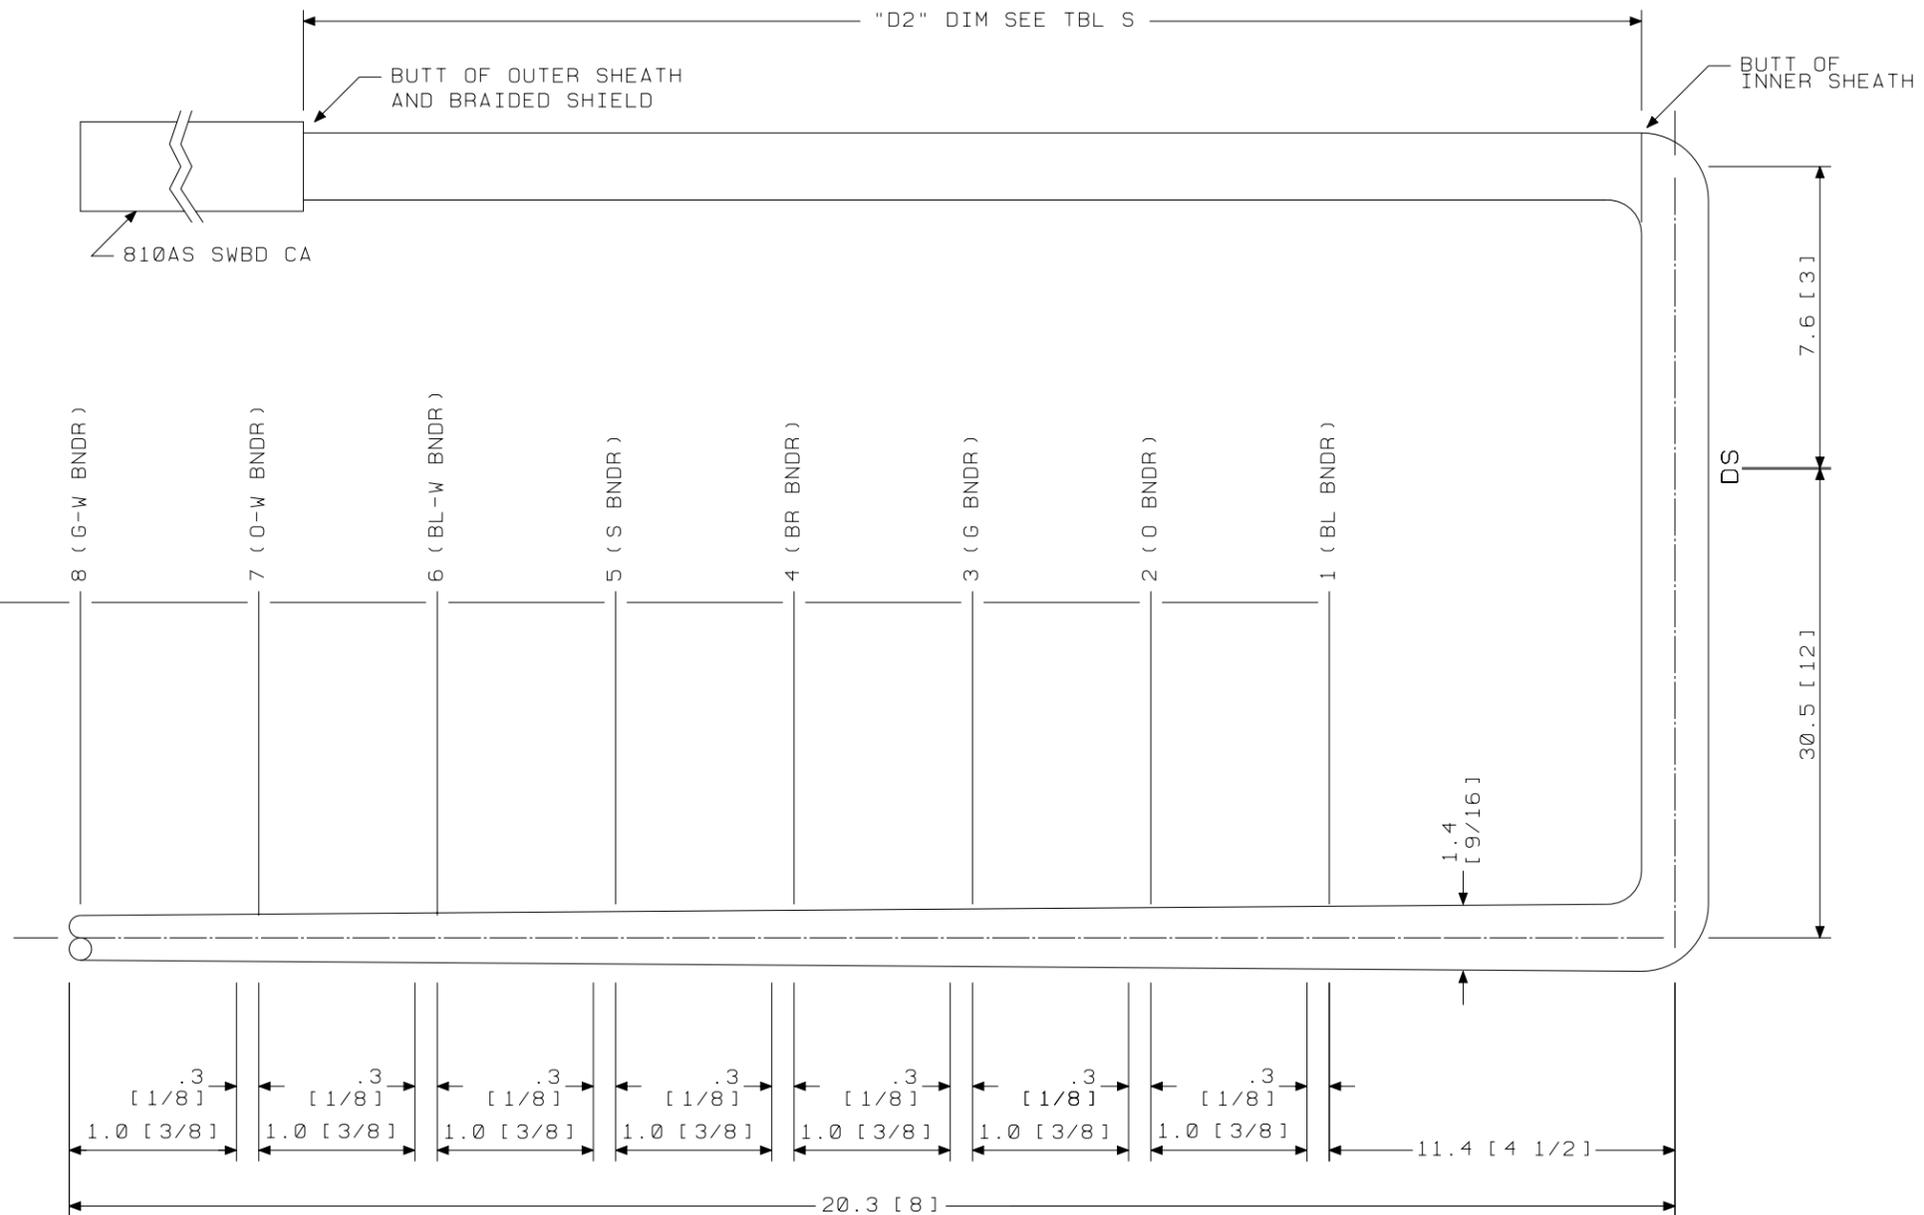


GROUP 507A OR 557A
 CABLE FOR INTERGRATED SERVICES LINE UNIT (4-WIRE) PBX APPL ONLY
 LG 06.07
 END "A"

SEE PROPRIETARY NOTICE ON SHEET ONE		
CONNECTORIZED SWITCHBOARD CABLE ASSEMBLIES	DWG SIZE	ISSUE
	c2	49
LUCENT TECHNOLOGIES INC.	ED5D621-35	SHEET C24

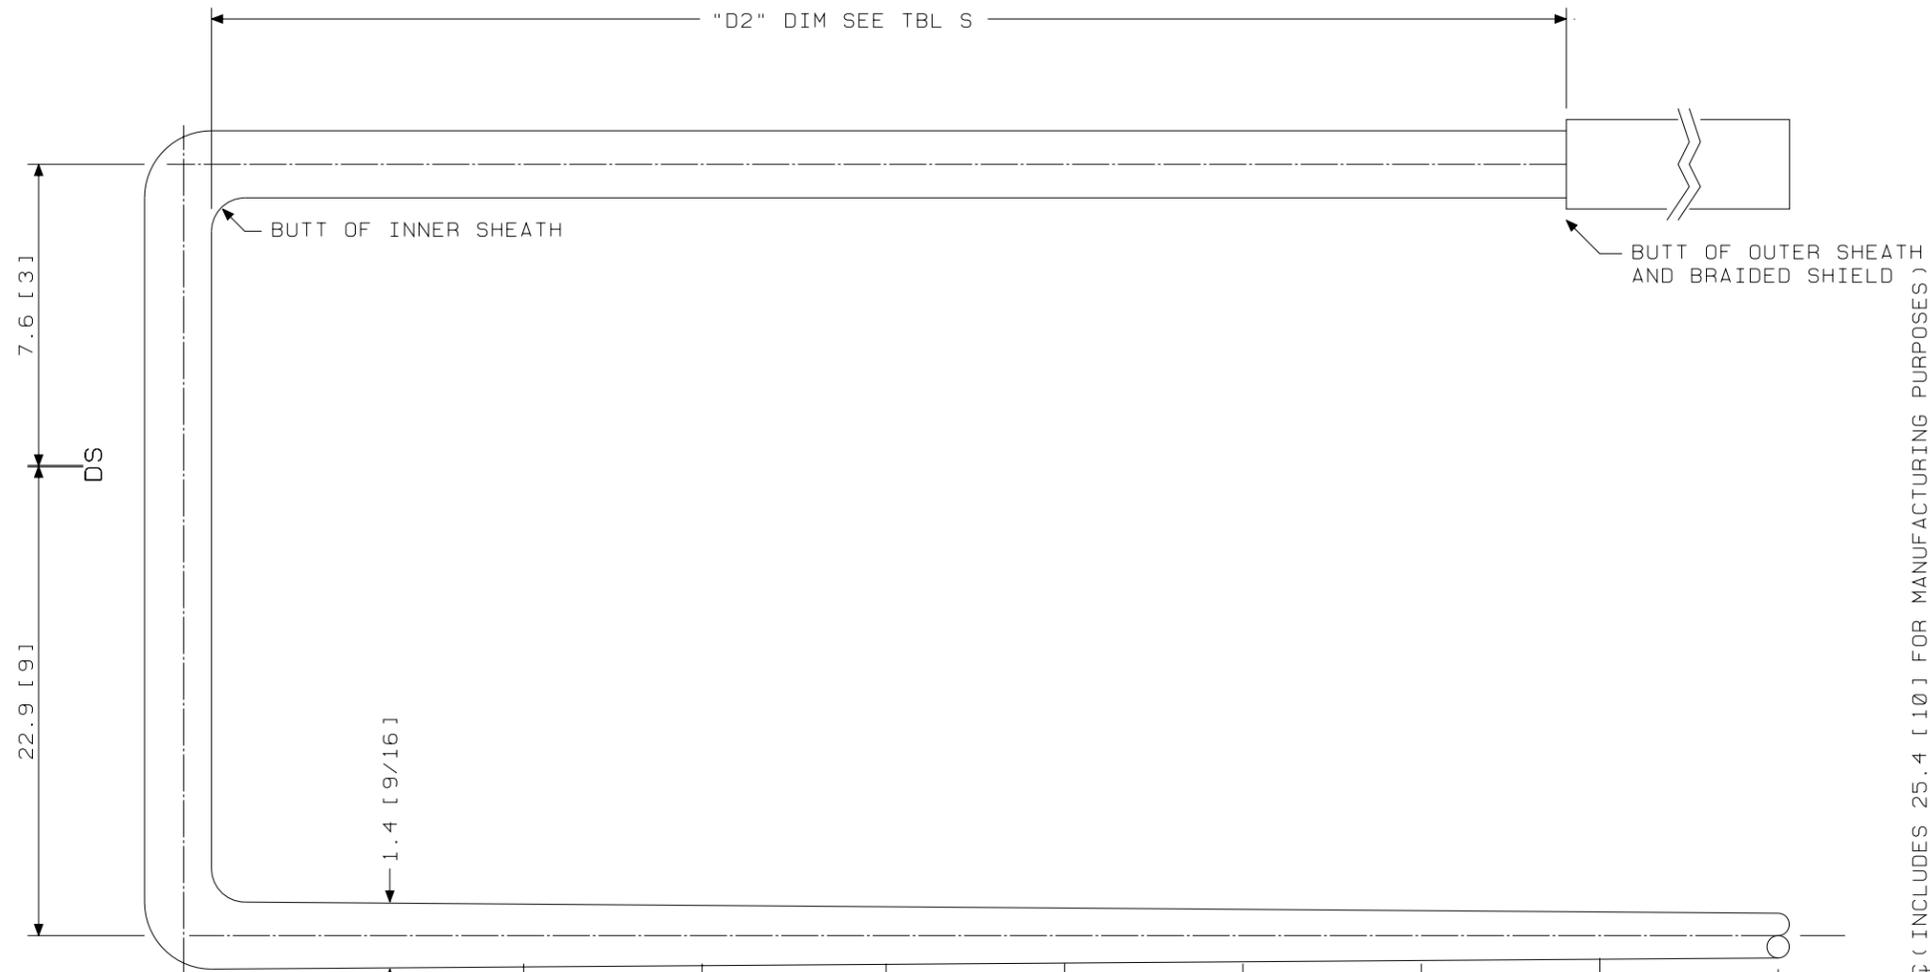


SK 26.7 [10 1/2] TO ARM Q (INCLUDES 25.4 [10] FOR MANUFACTURING PURPOSES)

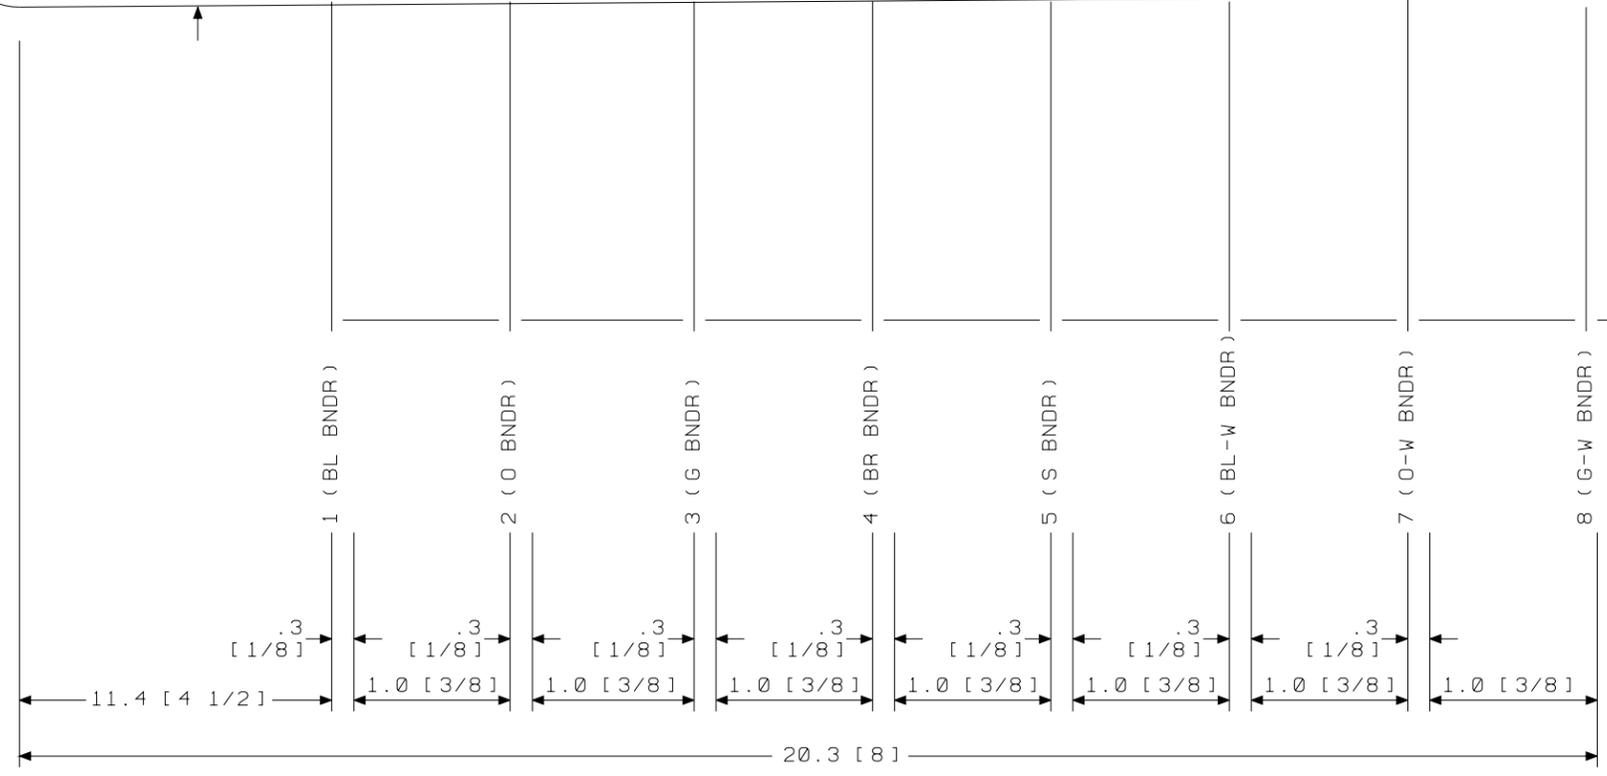


GROUP 502A OR 552A
 CABLE FOR INTEGRATED SERVICES LINE UNIT (4-WIRE) PBX APPL ONLY
 LG 08.09
 END "A"

SEE PROPRIETARY NOTICE ON SHEET ONE		
CONNECTORIZED SWITCHBOARD CABLE ASSEMBLIES	DWG SIZE	ISSUE
	c2	49
LUCENT TECHNOLOGIES INC.	ED5D621-35	SHEET C25

ED5D621-35

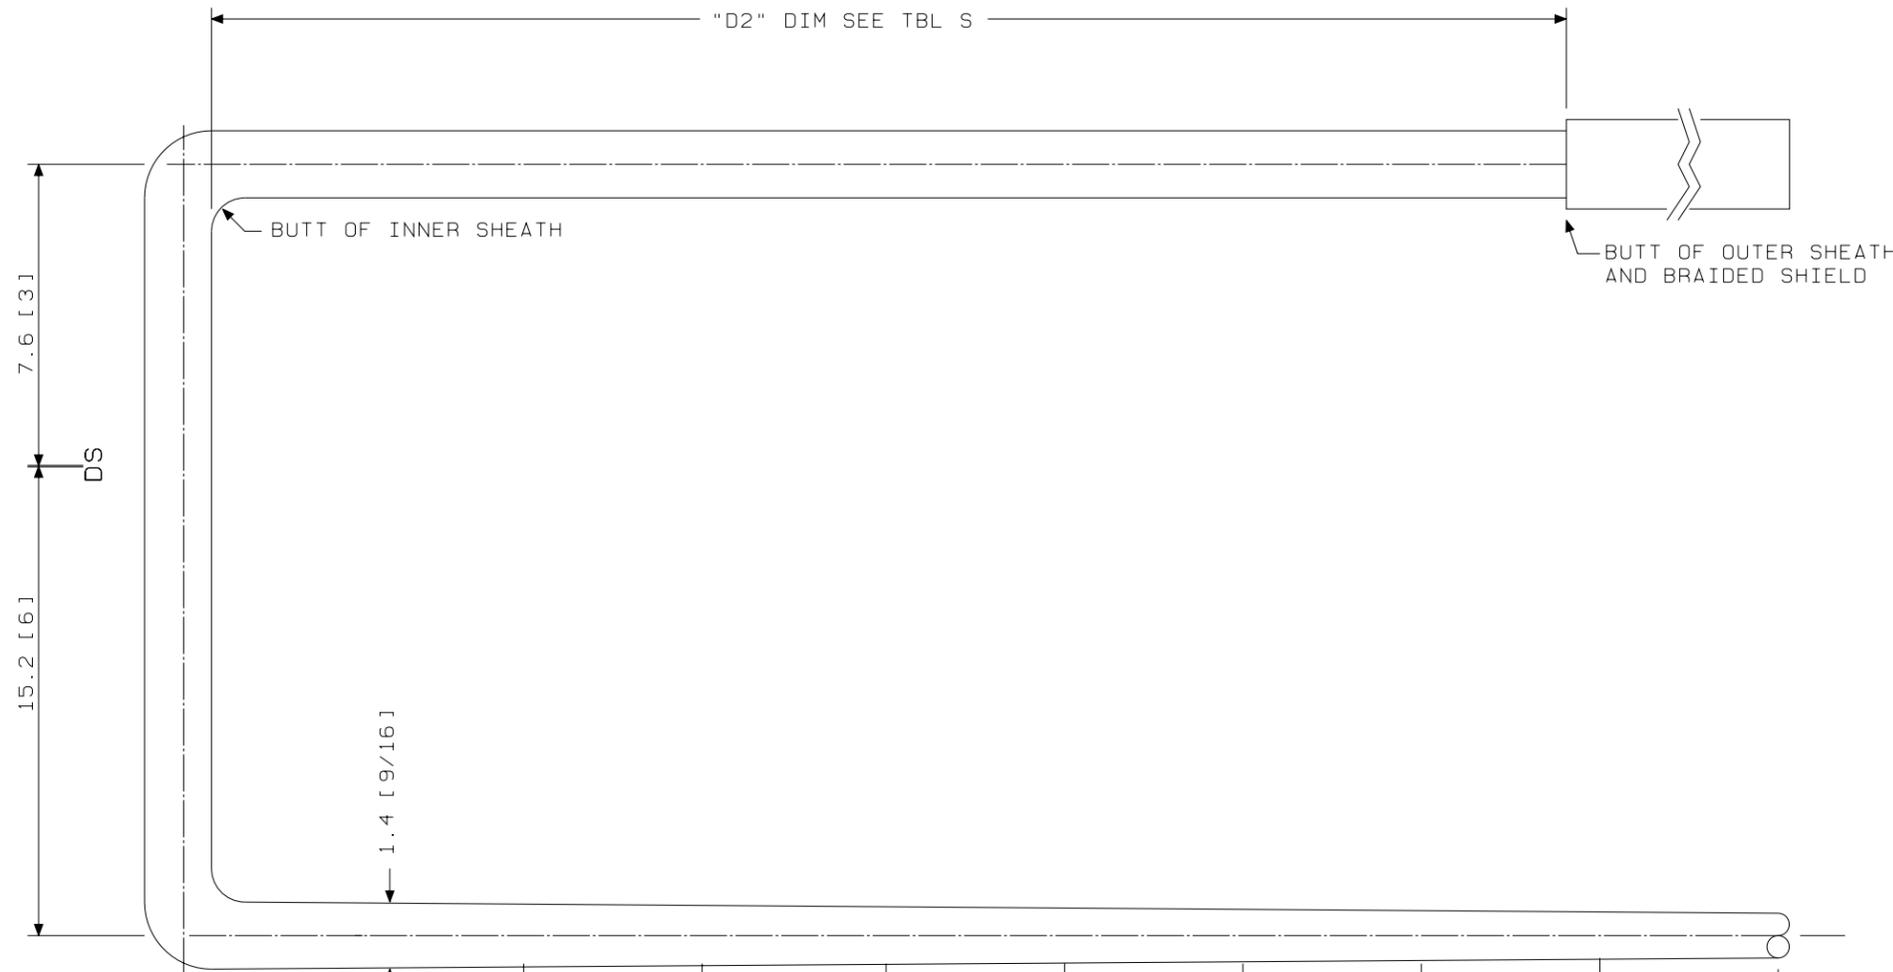


SK 26.7 [10 1/2] TO ARM Q (INCLUDES 25.4 [10.0] FOR MANUFACTURING PURPOSES)

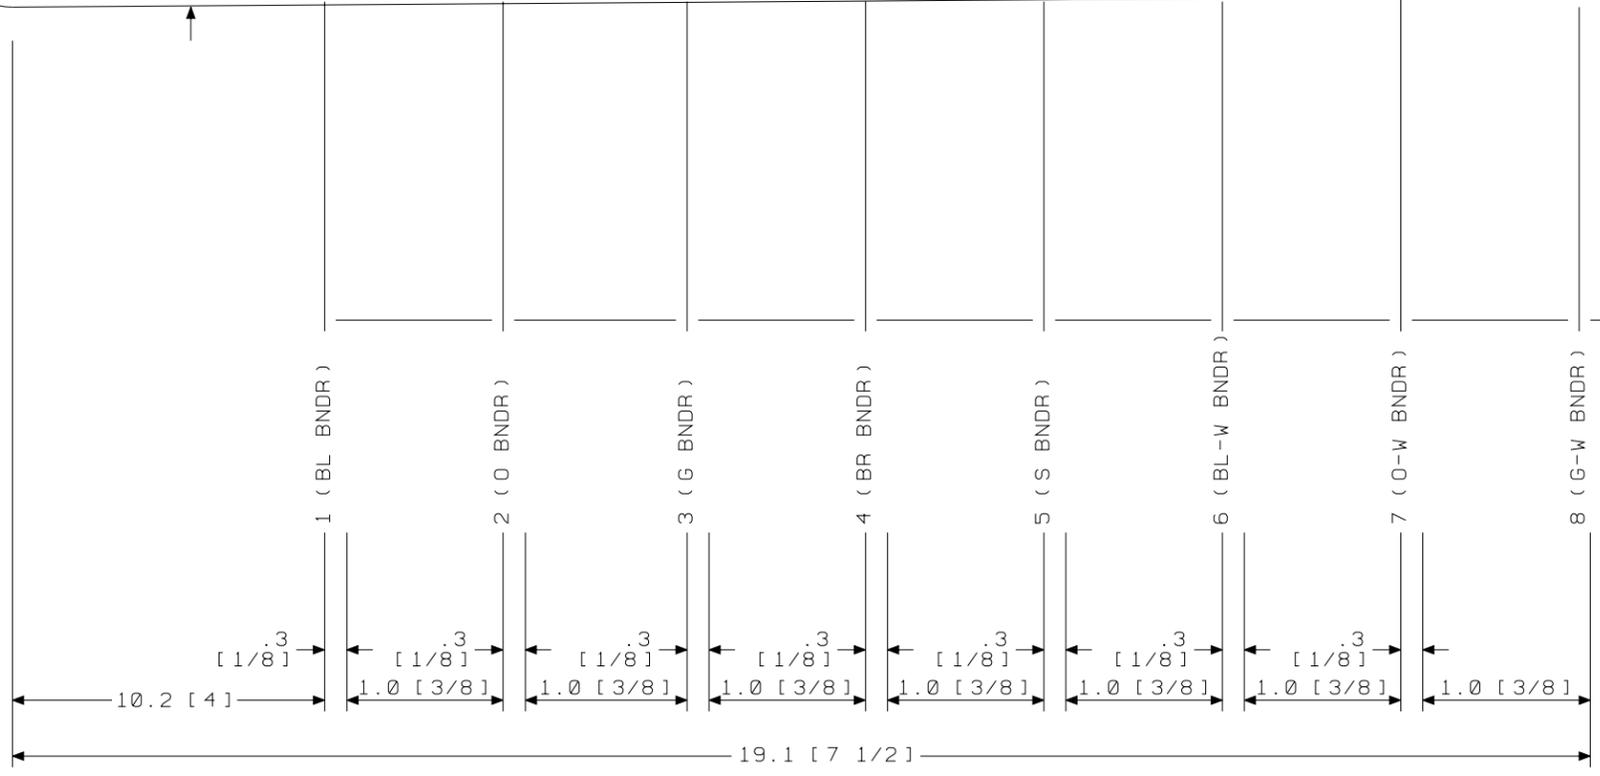


GROUP 504A OR 554A
 CABLE FOR INTEGRATED SERVICES LINE UNIT (4-WIRE) PBX APPL ONLY
 LG 08.09
 END "A"

SEE PROPRIETARY NOTICE ON SHEET ONE		
CONNECTORIZED SWITCHBOARD CABLE ASSEMBLIES	DWG SIZE	ISSUE
	c2	49
LUCENT TECHNOLOGIES INC.	ED5D621-35	SHEET C26

ED5D621-35

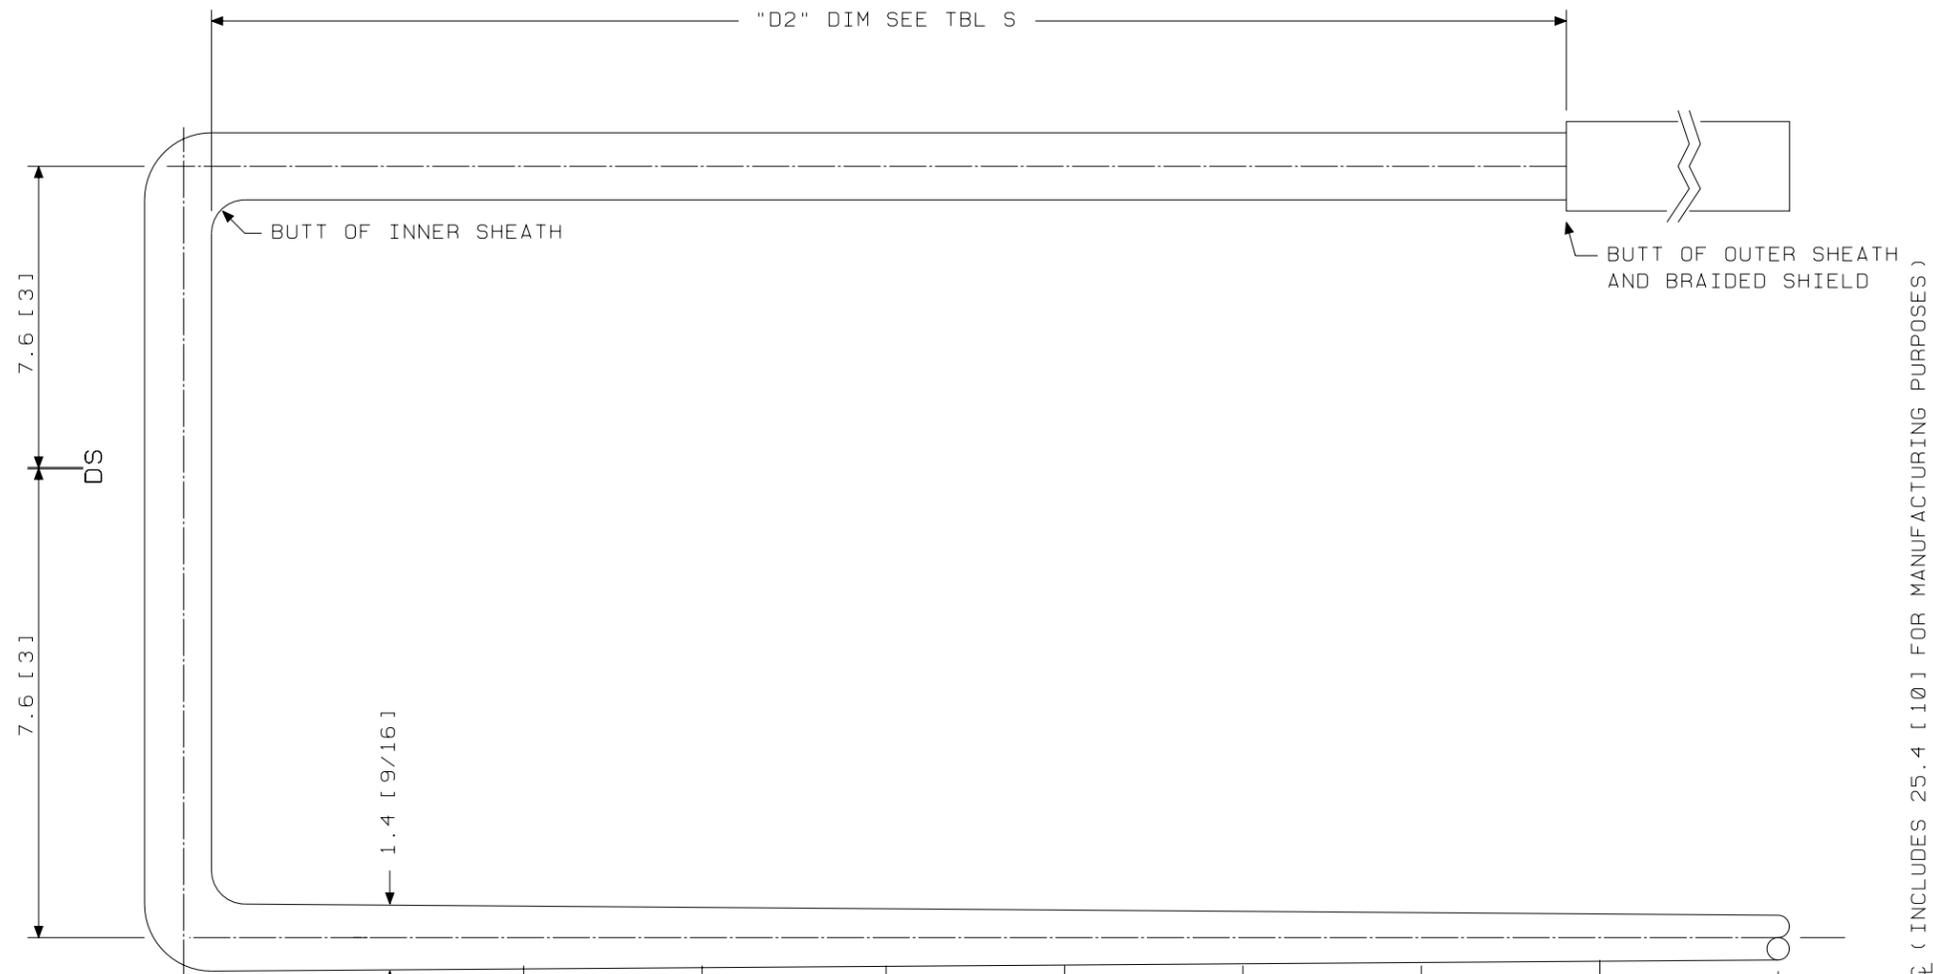


SK 26.7 [10 1/2] TO ARM ϕ (INCLUDES 25.4 [10] FOR MANUFACTURING PURPOSES)

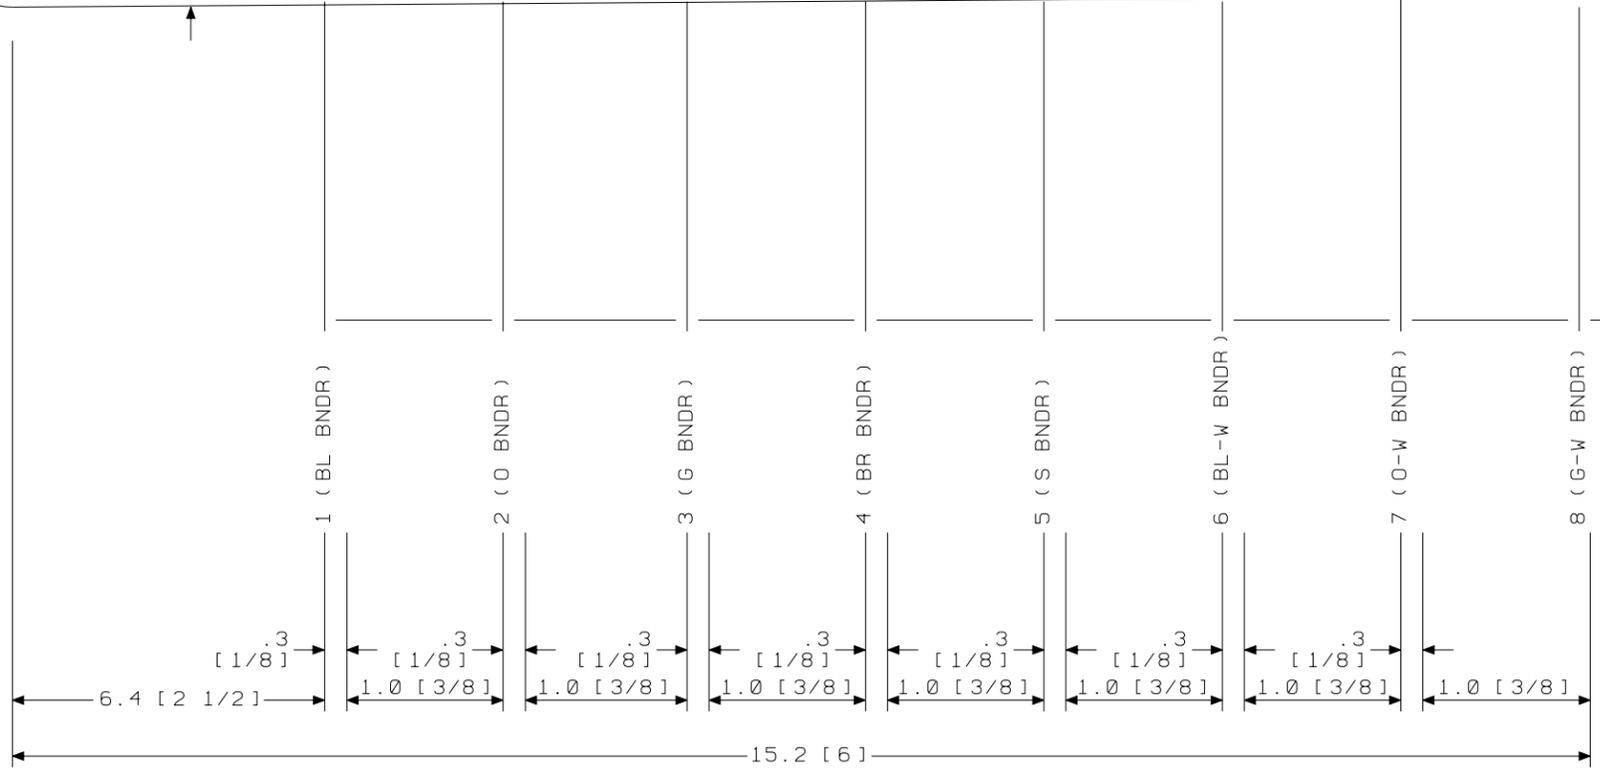


GROUP 506A OR 556A
 CABLE FOR INTEGRATED SERVICES LINE UNIT (4-WIRE) PBX APPL ONLY
 LG 12.13
 END "A"

SEE PROPRIETARY NOTICE ON SHEET ONE		
CONNECTORIZED SWITCHBOARD CABLE ASSEMBLIES	DWG SIZE	ISSUE
	c2	49
LUCENT TECHNOLOGIES INC.	ED5D621-35	SHEET c27

ED5D621-35

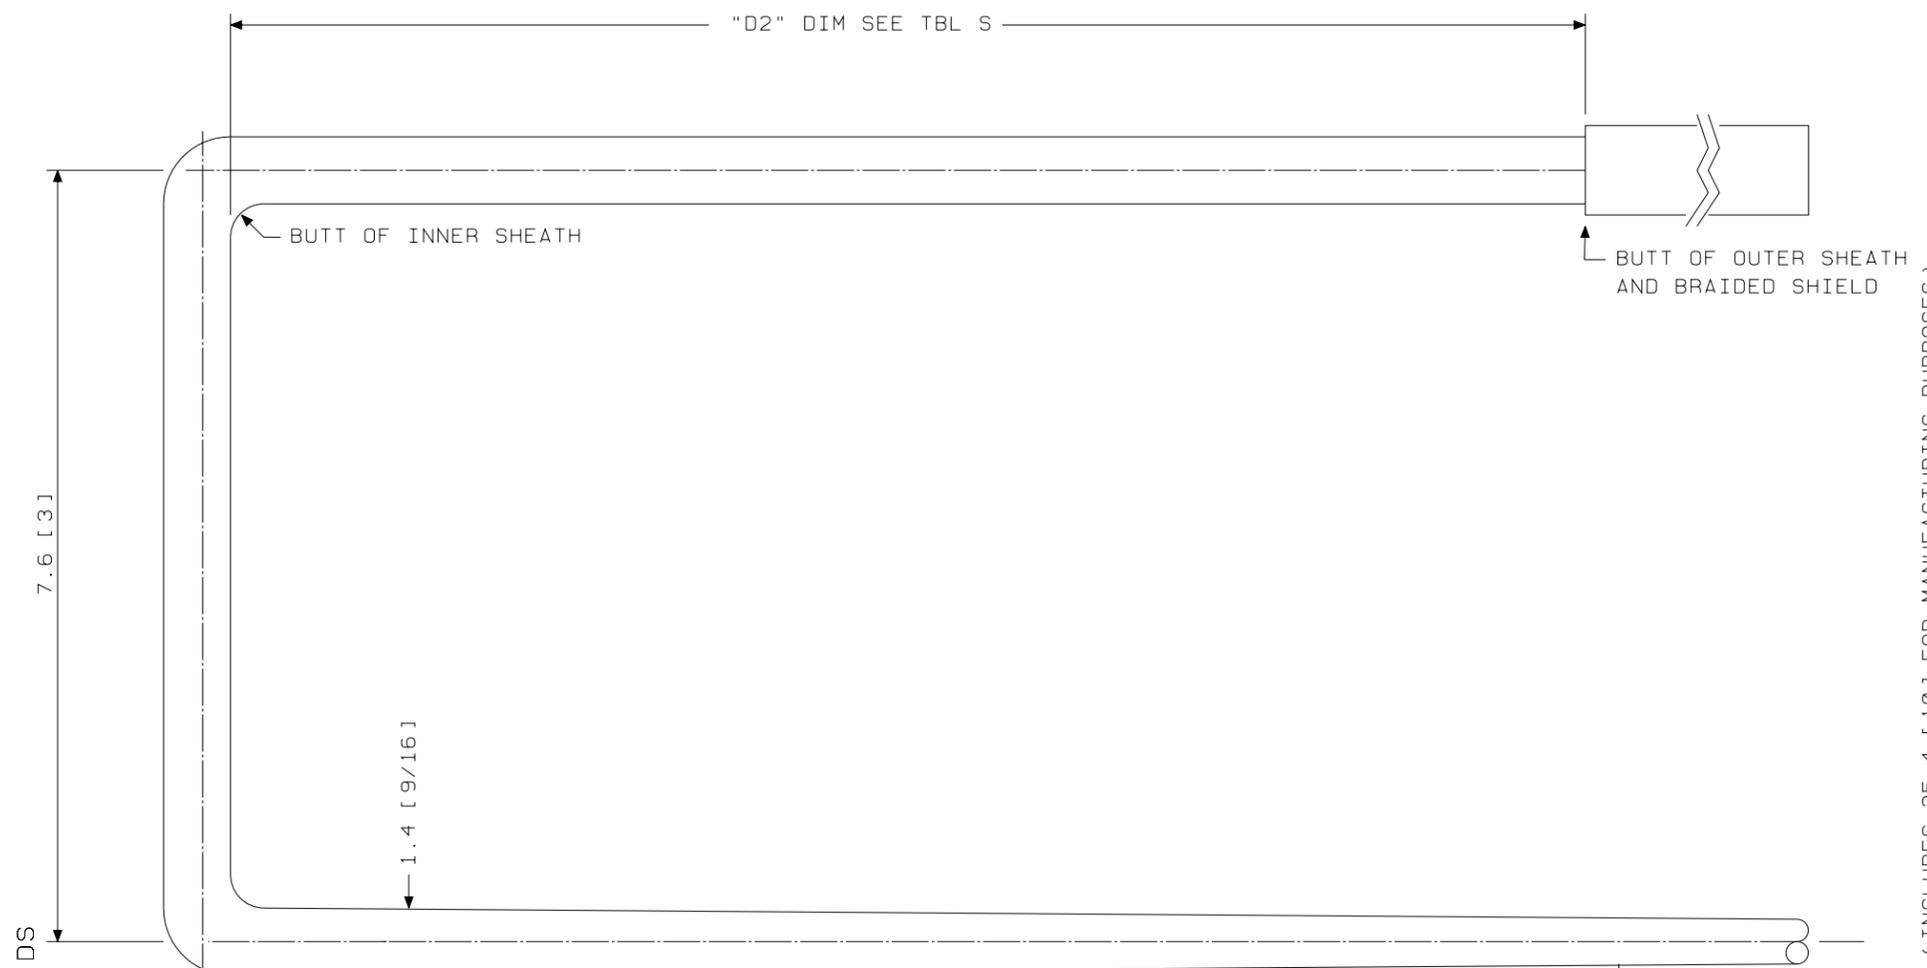

SK 26.7 [10 1/2] TO ARM C (INCLUDES 25.4 [10] FOR MANUFACTURING PURPOSES)

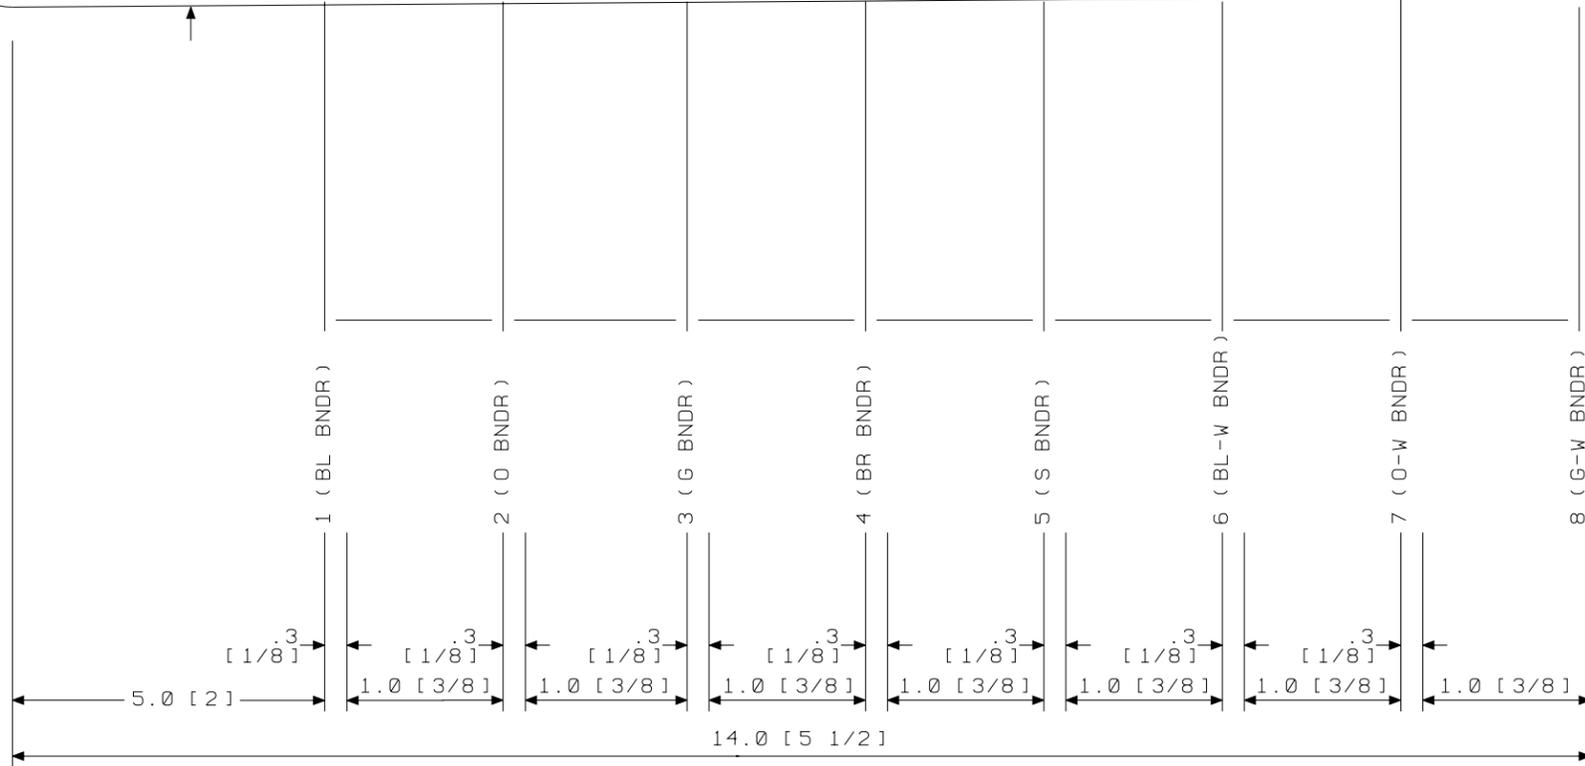


GROUP 508A OR 558A
 CABLE FOR INTEGRATED SERVICES LINE UNIT (4-WIRE) PBX APPL ONLY
 LG 14.15
 END "A"

SEE PROPRIETARY NOTICE ON SHEET ONE		
CONNECTORIZED SWITCHBOARD CABLE ASSEMBLIES		DWG SIZE C2
LUCENT TECHNOLOGIES INC.		ISSUE 49 SHEET C28
ED5D621-35		

ED5D621-35

SK 26.7 [10 1/2] TO ARM ϕ (INCLUDES 25.4 [10] FOR MANUFACTURING PURPOSES)

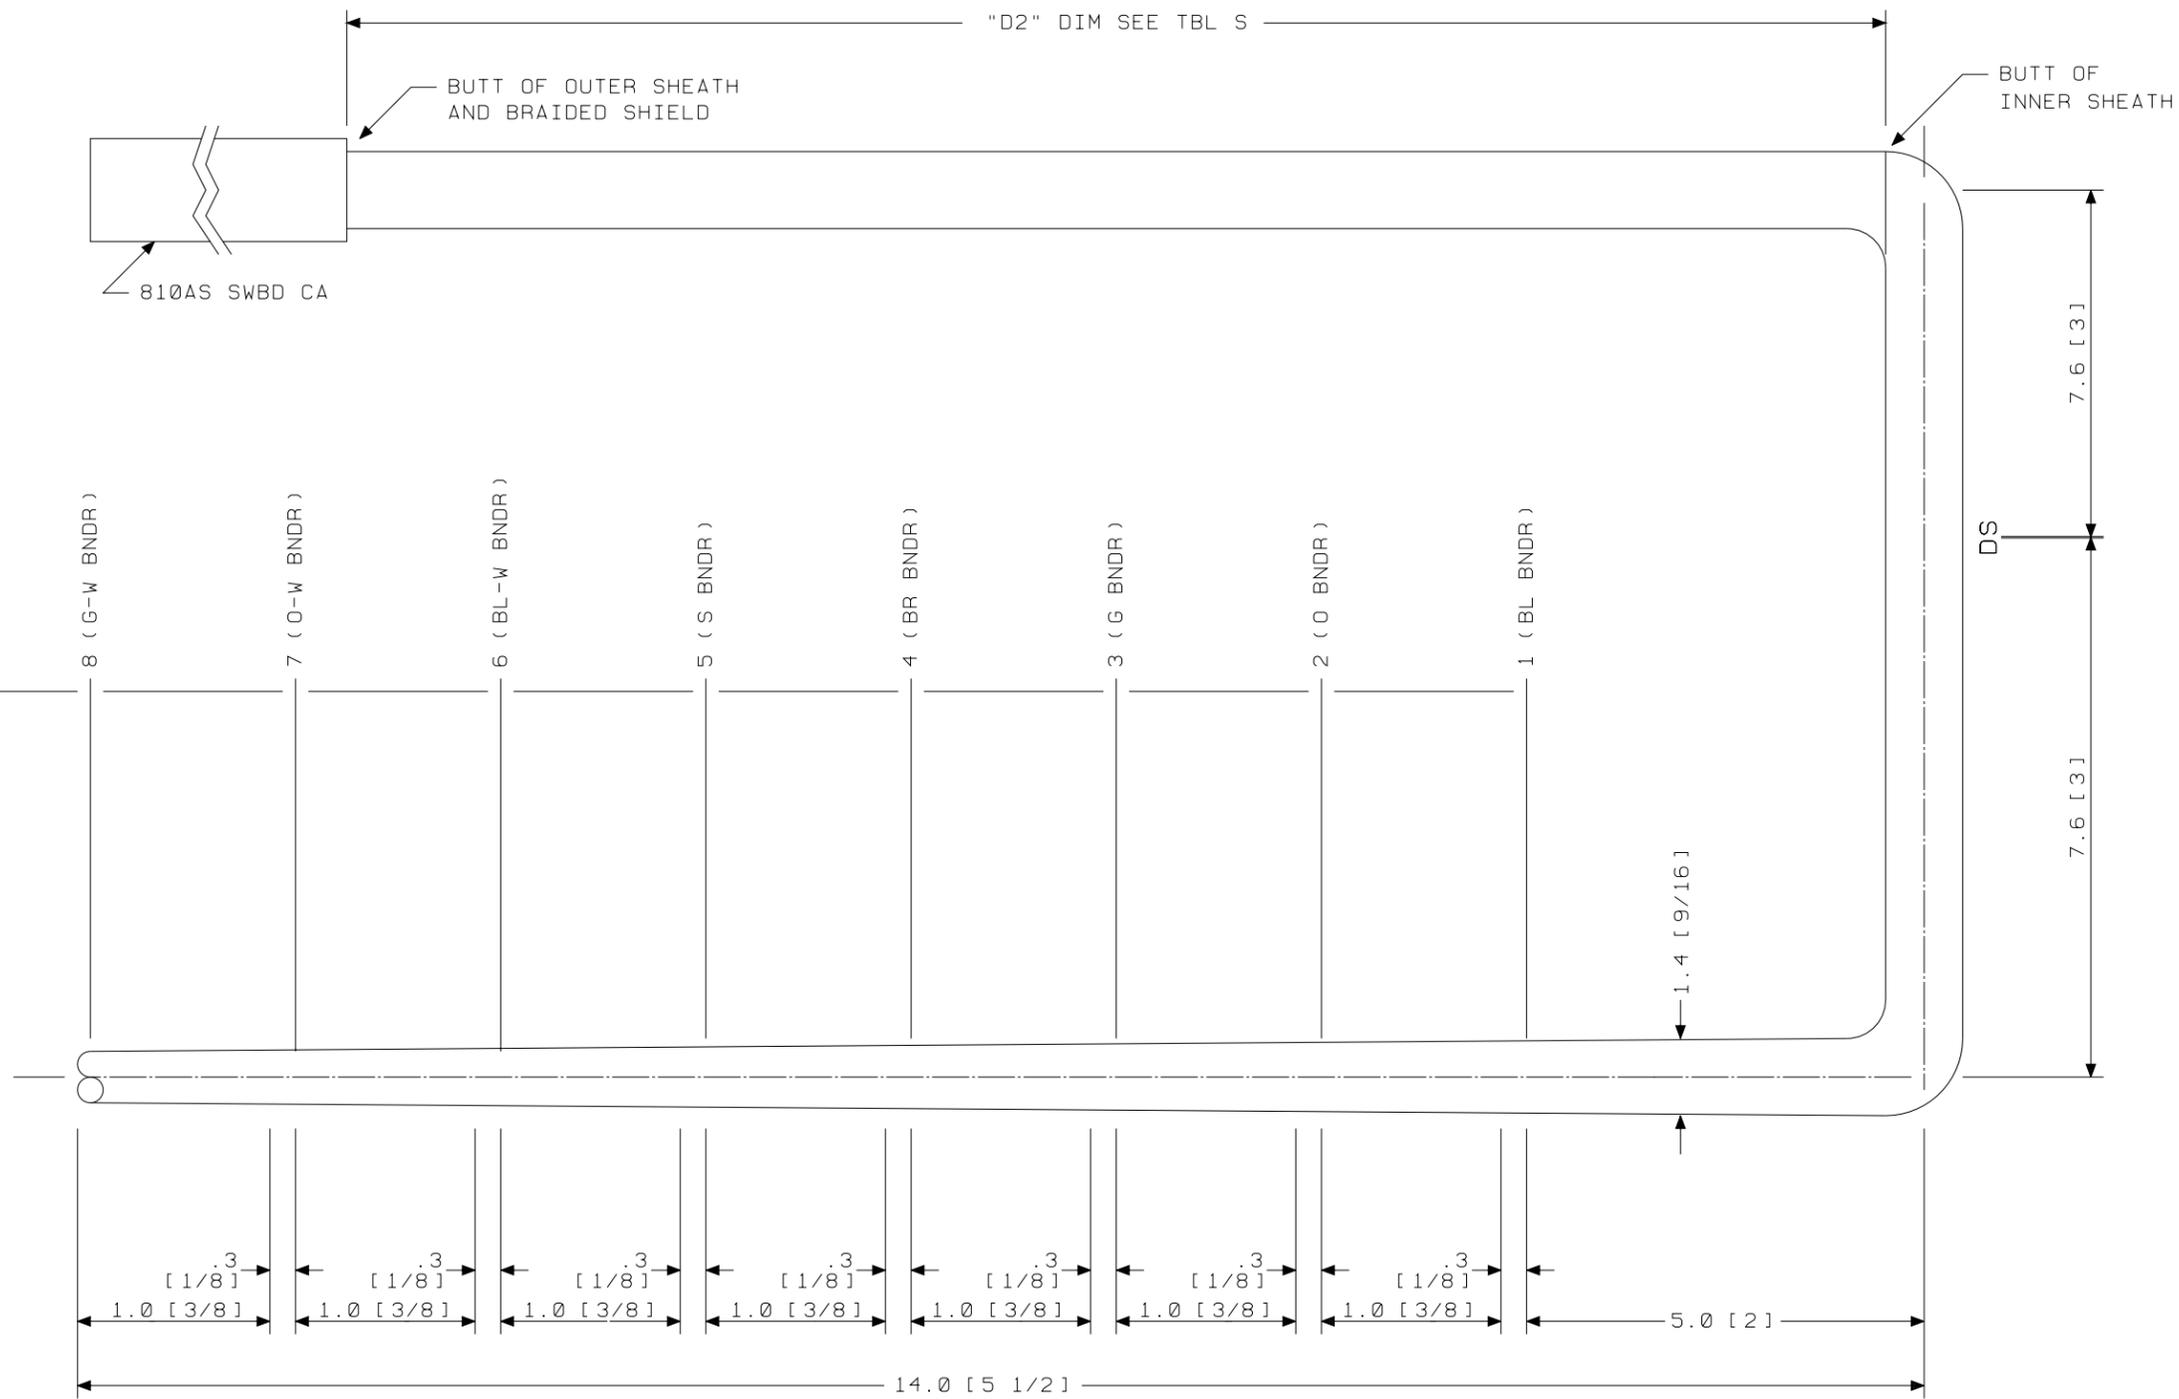

GROUP 511A

CABLE FOR INTERGRATED SERVICES LINE UNIT (4-WIRE) PBX APPL ONLY
 LG 00.01
 END "A"

SEE PROPRIETARY NOTICE ON SHEET ONE

CONNECTORIZED SWITCHBOARD
 CABLE ASSEMBLIES


DWG SIZE	ISSUE
c2	49

LUCENT
 TECHNOLOGIES INC.

ED5D621-35

SHEET
 C29

SK 26.7 [10 1/2] TO ARM ϕ (INCLUDES 25.4 [10] FOR MANUFACTURING PURPOSES)

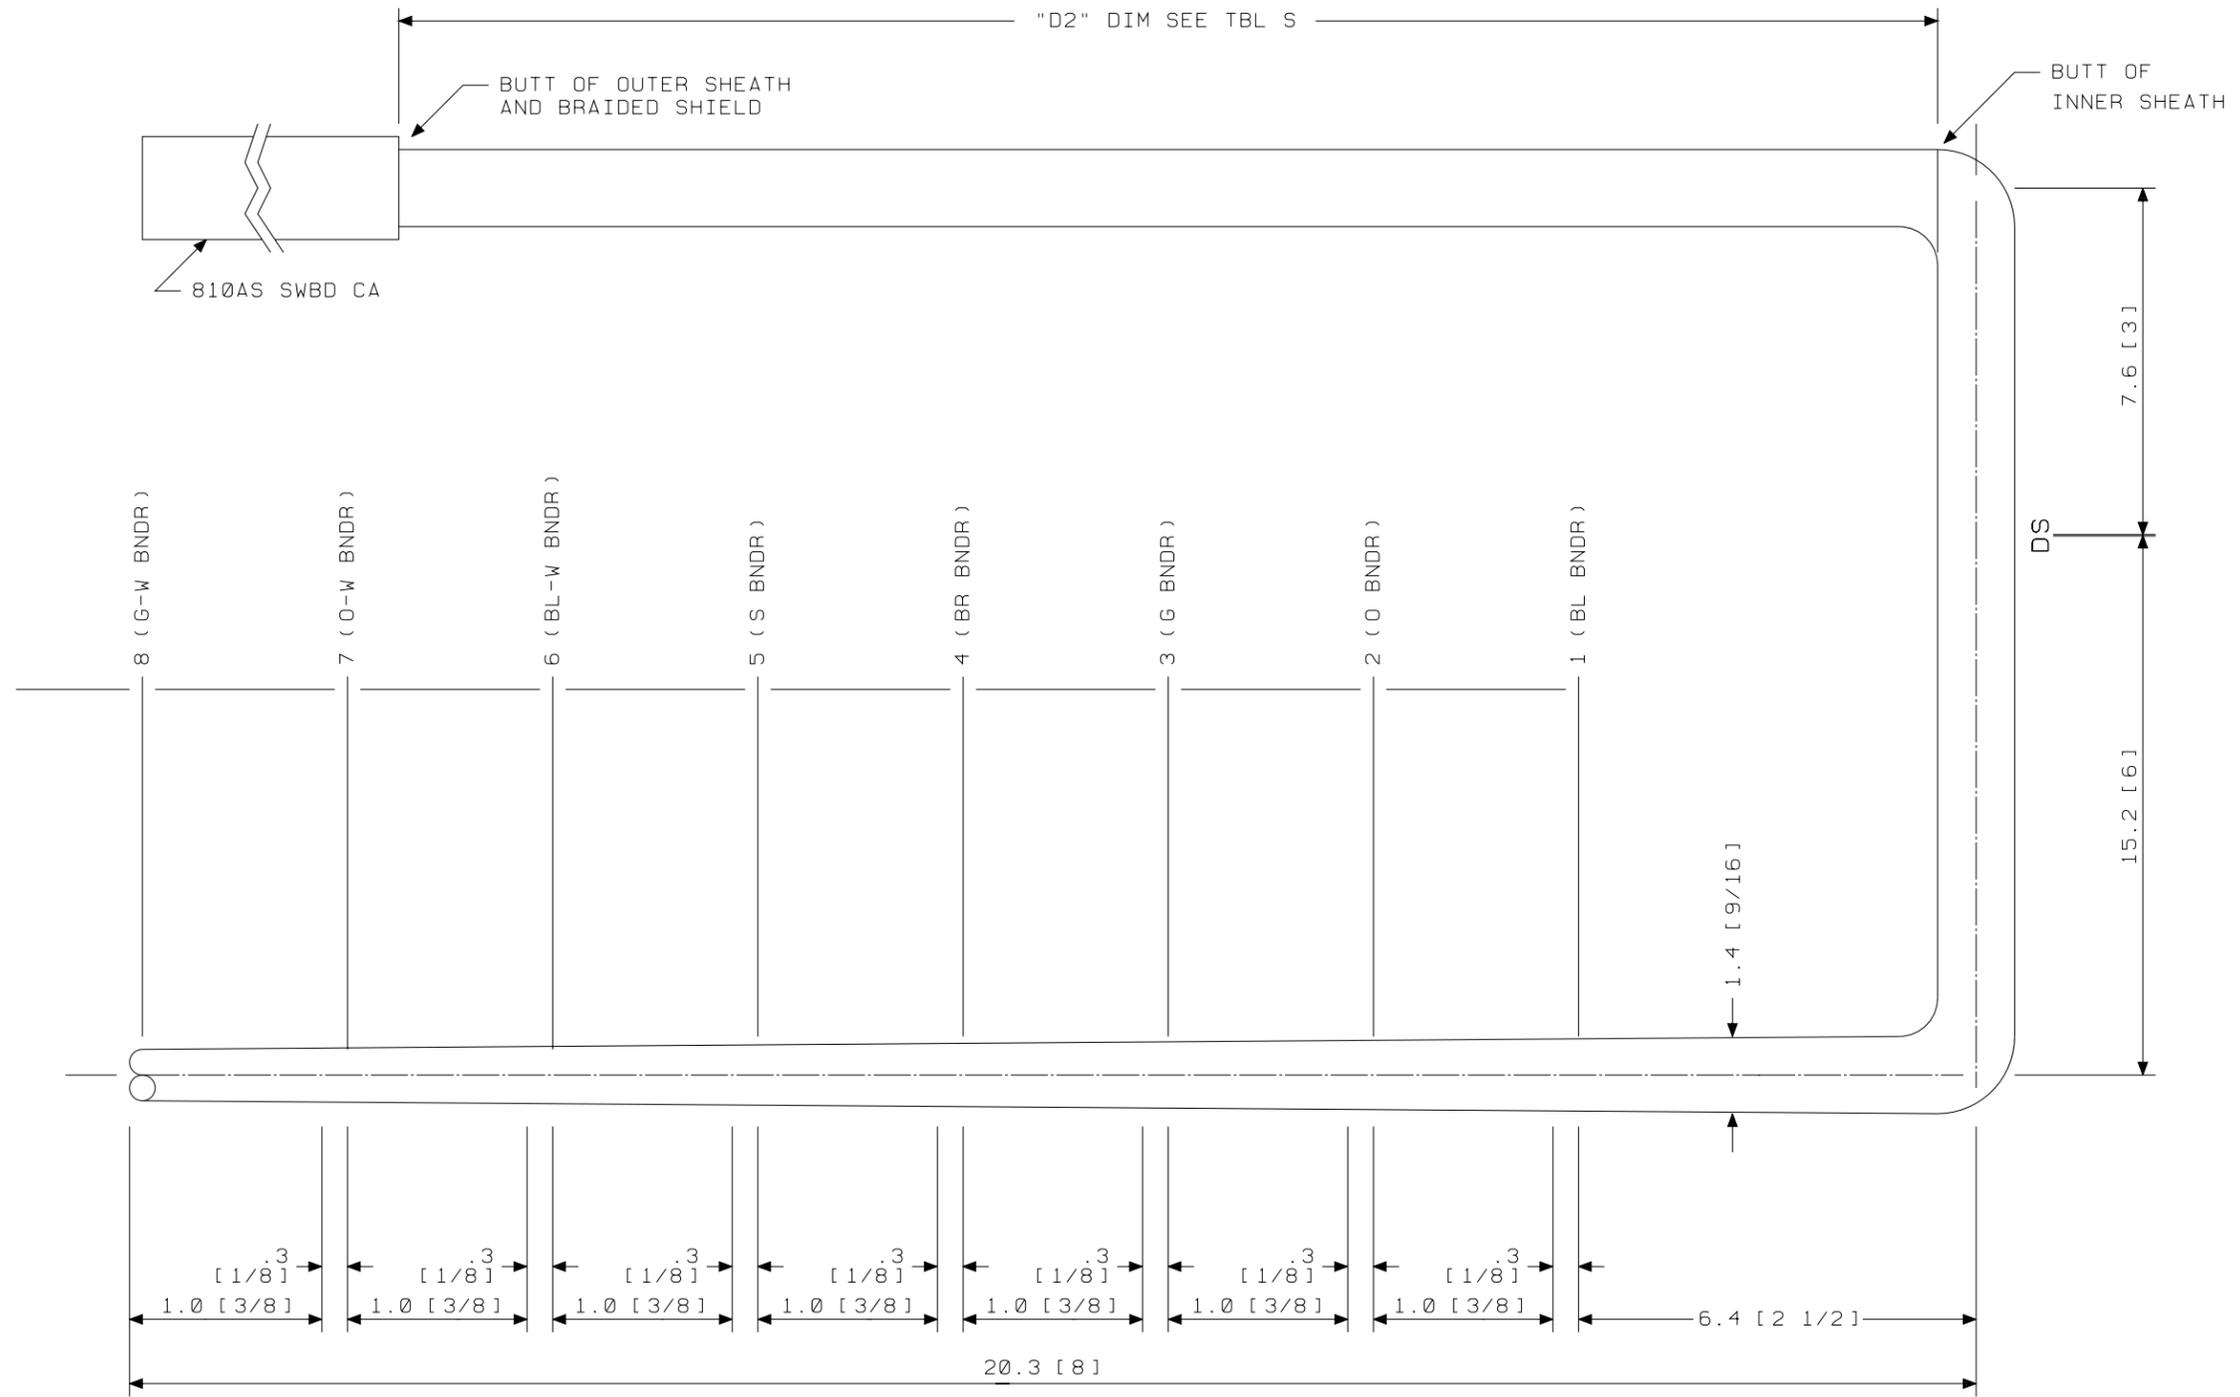


GROUP 513A
 CABLE FOR INTERGRATED SERVICES LINE UNIT (4-WIRE) PBX APPL ONLY
 LG 02.03
 END " A "

SEE PROPRIETARY NOTICE ON SHEET ONE		
CONNECTORIZED SWITCHBOARD CABLE ASSEMBLIES	DWG SIZE	ISSUE
	c2	49
LUCENT TECHNOLOGIES INC.	ED5D621-35	SHEET C30

ED5D621-35


SK 26.7 [10 1/2] TO ARM ϕ (INCLUDES 25.4 [10] FOR MANUFACTURING PURPOSES)

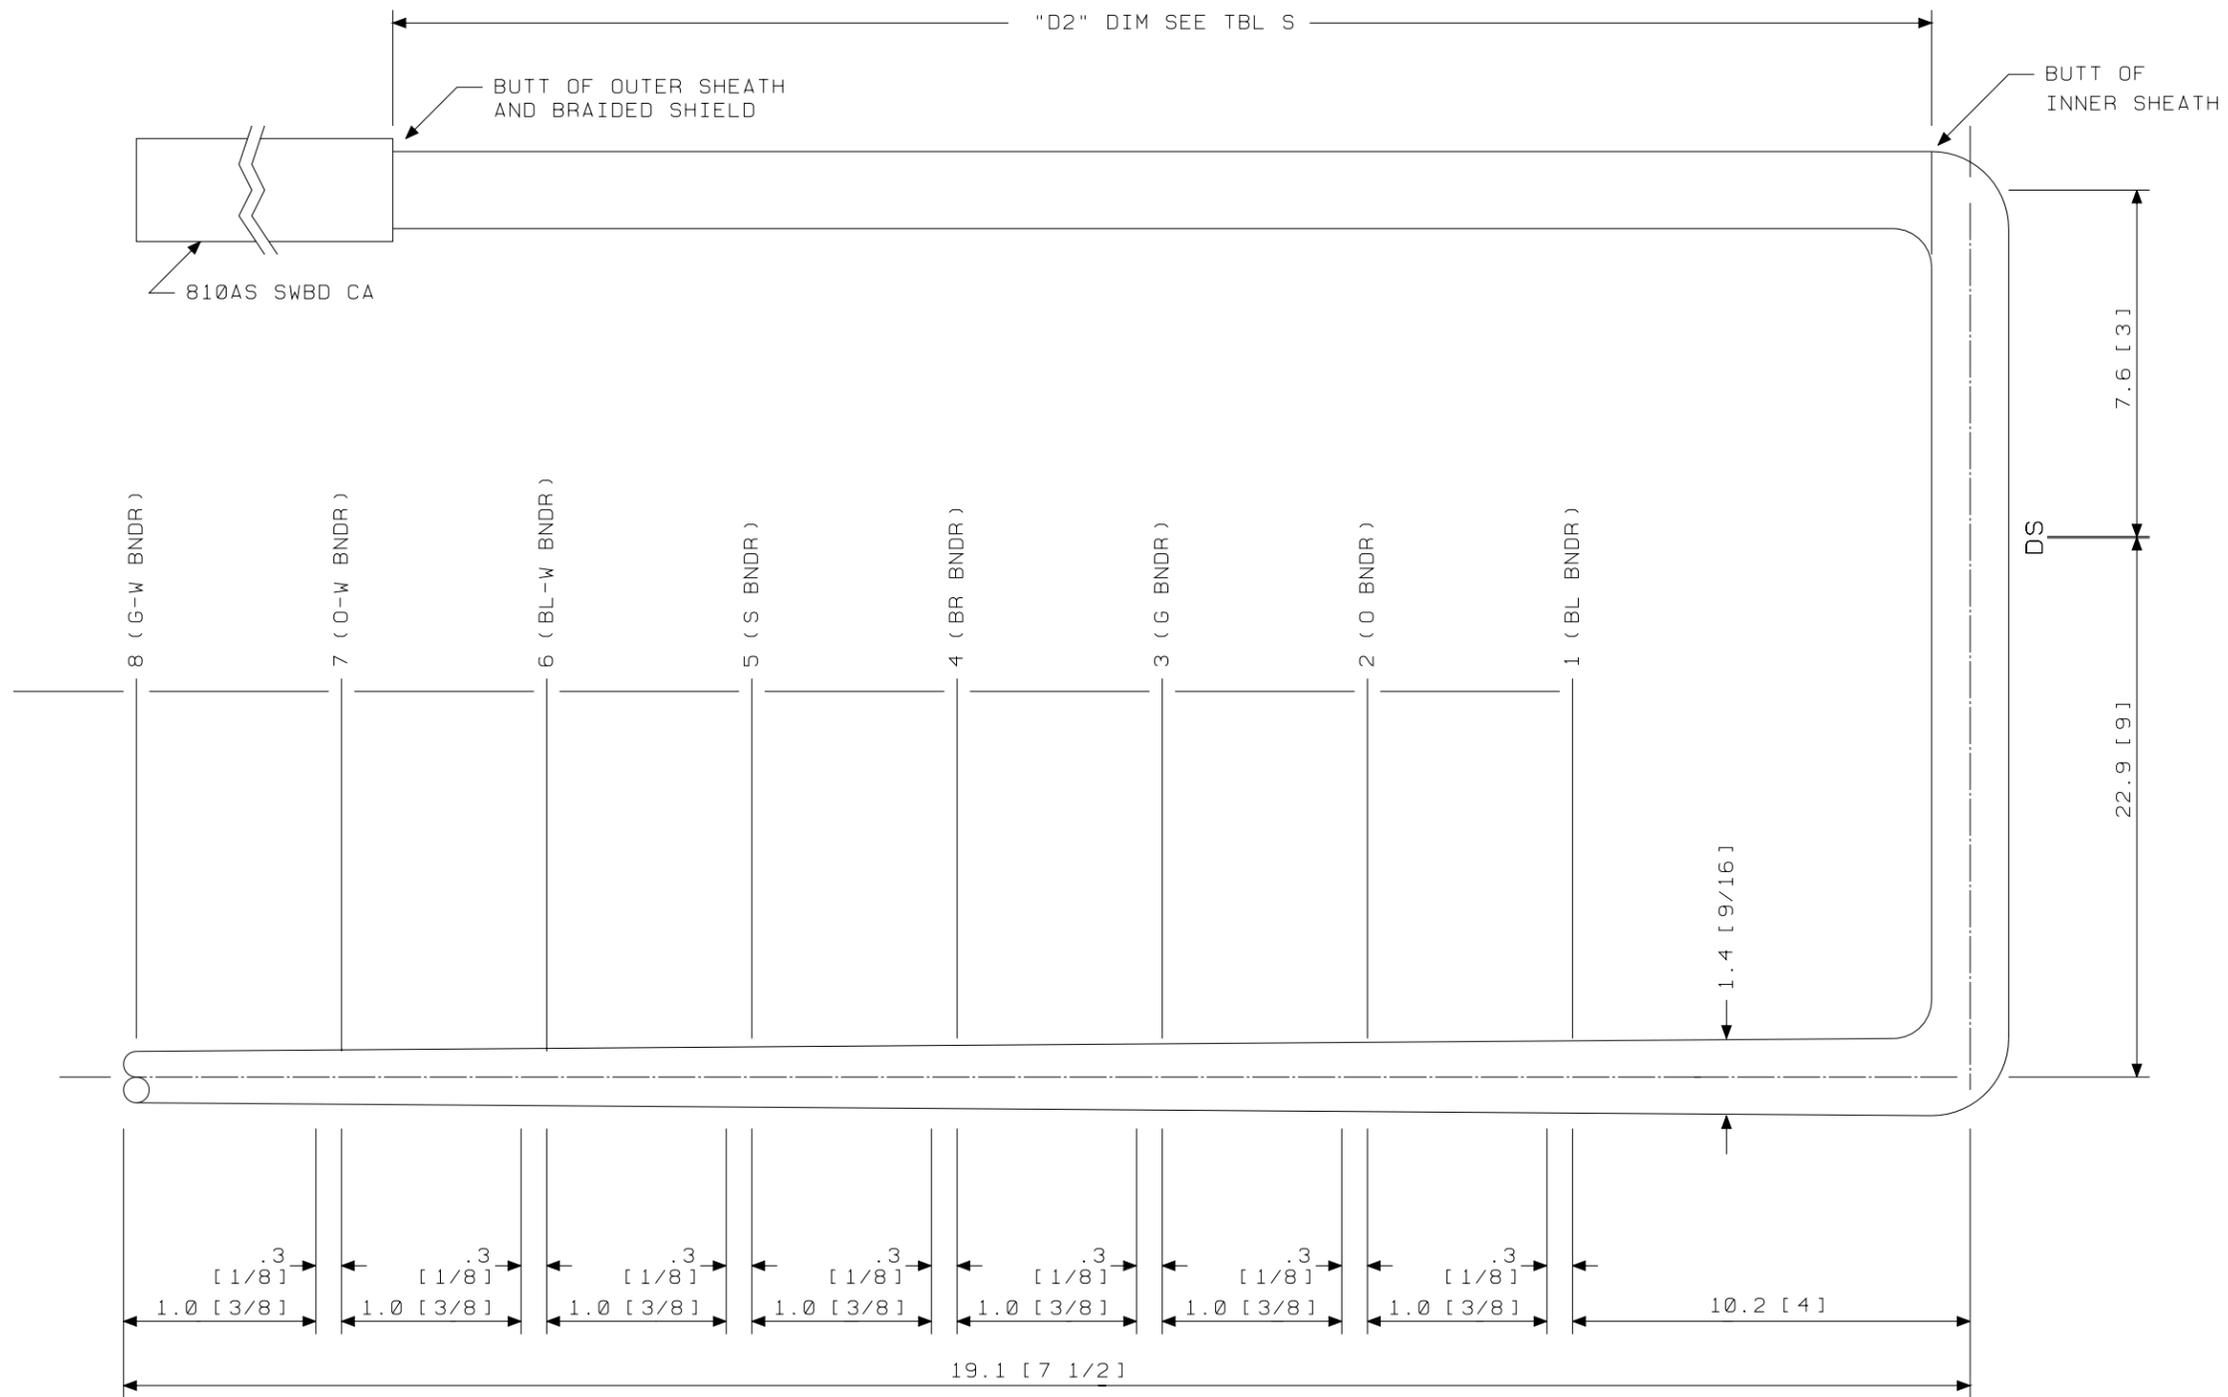

GROUP 515A
 CABLE FOR INTERGRATED SERVICES LINE UNIT (4-WIRE) PBX APPL ONLY
 LG 04.05
 END "A"

SEE PROPRIETARY NOTICE ON SHEET ONE		
CONNECTORIZED SWITCHBOARD CABLE ASSEMBLIES	DWG SIZE	ISSUE
	c2	49
LUCENT TECHNOLOGIES INC.	ED5D621-35	SHEET C31

SK 26.7 [10 1/2] ARM ϕ (INCLUDES 25.4 [10] FOR MANUFACTURING PURPOSES)

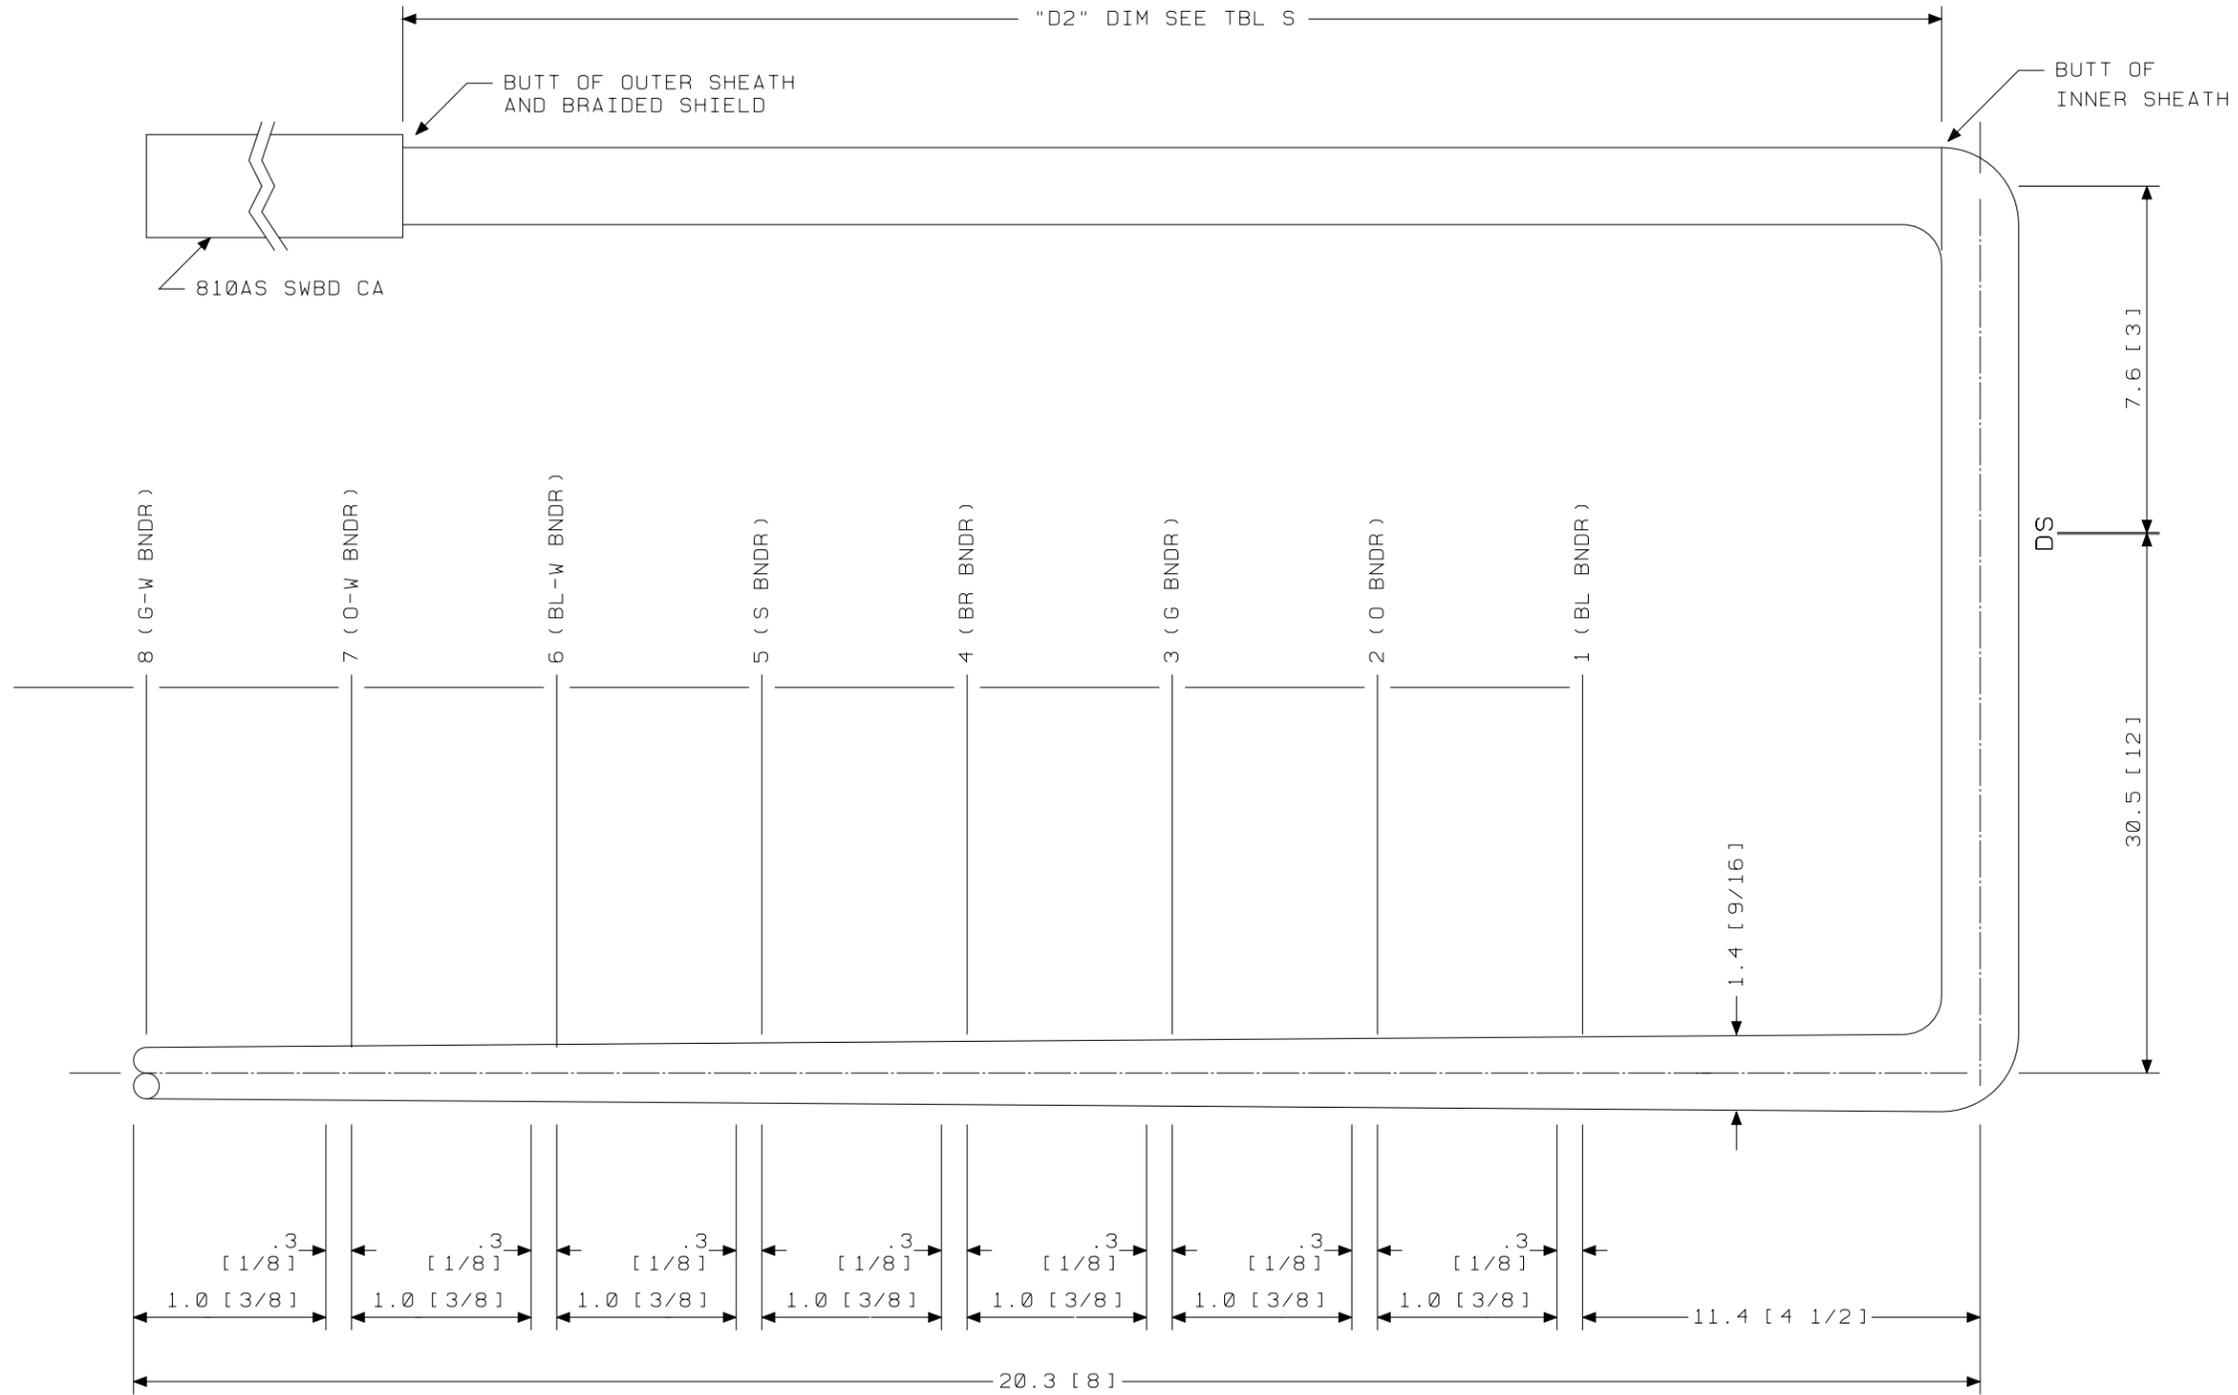


GROUP 517A
 CABLE FOR INTERGRATED SERVICES LINE UNIT (4-WIRE) PBX APPL ONLY
 LG 06.07
 END "A"

SEE PROPRIETARY NOTICE ON SHEET ONE		
CONNECTORIZED SWITCHBOARD CABLE ASSEMBLIES	DWG SIZE	ISSUE
	c2	49
LUCENT TECHNOLOGIES INC.	ED5D621-35	SHEET C32

ED5D621-35





SK 26.7 [10 1/2] TO ARM ϕ (INCLUDES 25.4 [10] INCHES FOR MANUFACTURING PURPOSES)

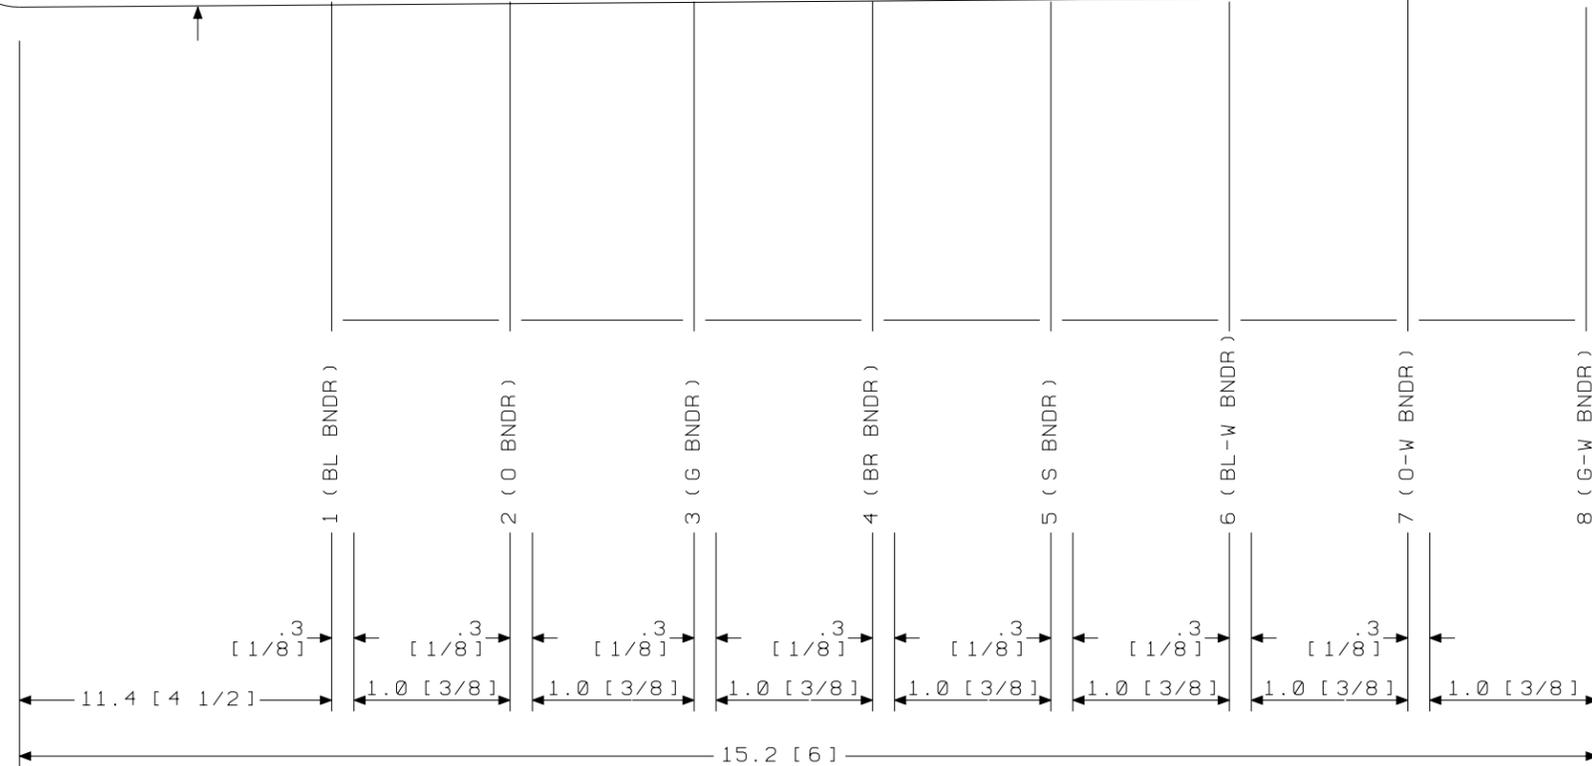

GROUP 512A
 CABLE FOR INTEGRATED SERVICES LINE UNIT (4-WIRE) PBX APPL ONLY
 LG 08.09
 END "A"

SEE PROPRIETARY NOTICE ON SHEET ONE		
CONNECTORIZED SWITCHBOARD CABLE ASSEMBLIES	DWG SIZE	ISSUE
	c2	49
LUCENT TECHNOLOGIES INC.	ED5D621-35	SHEET C33

ED5D621-35

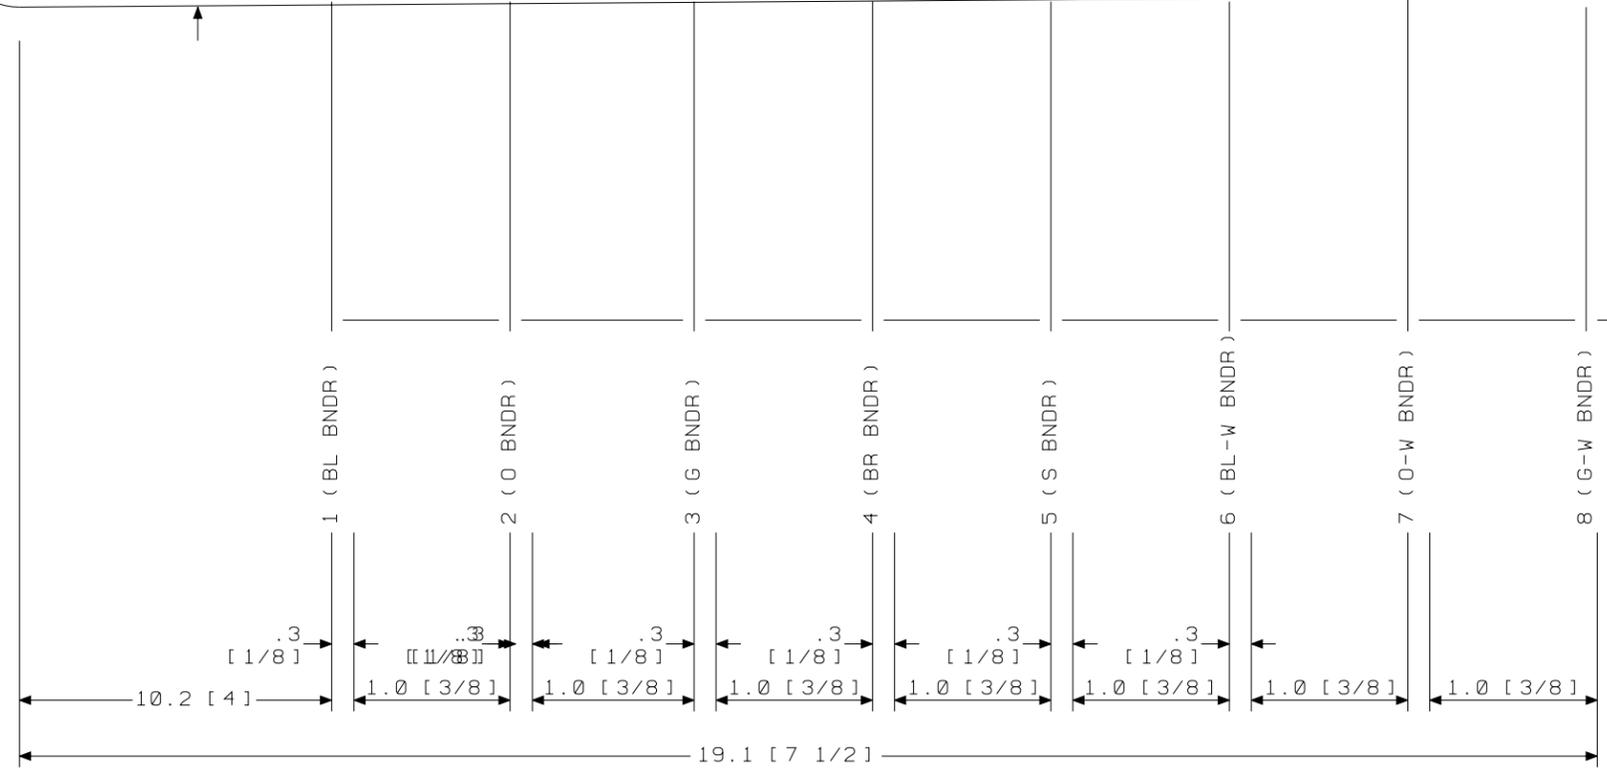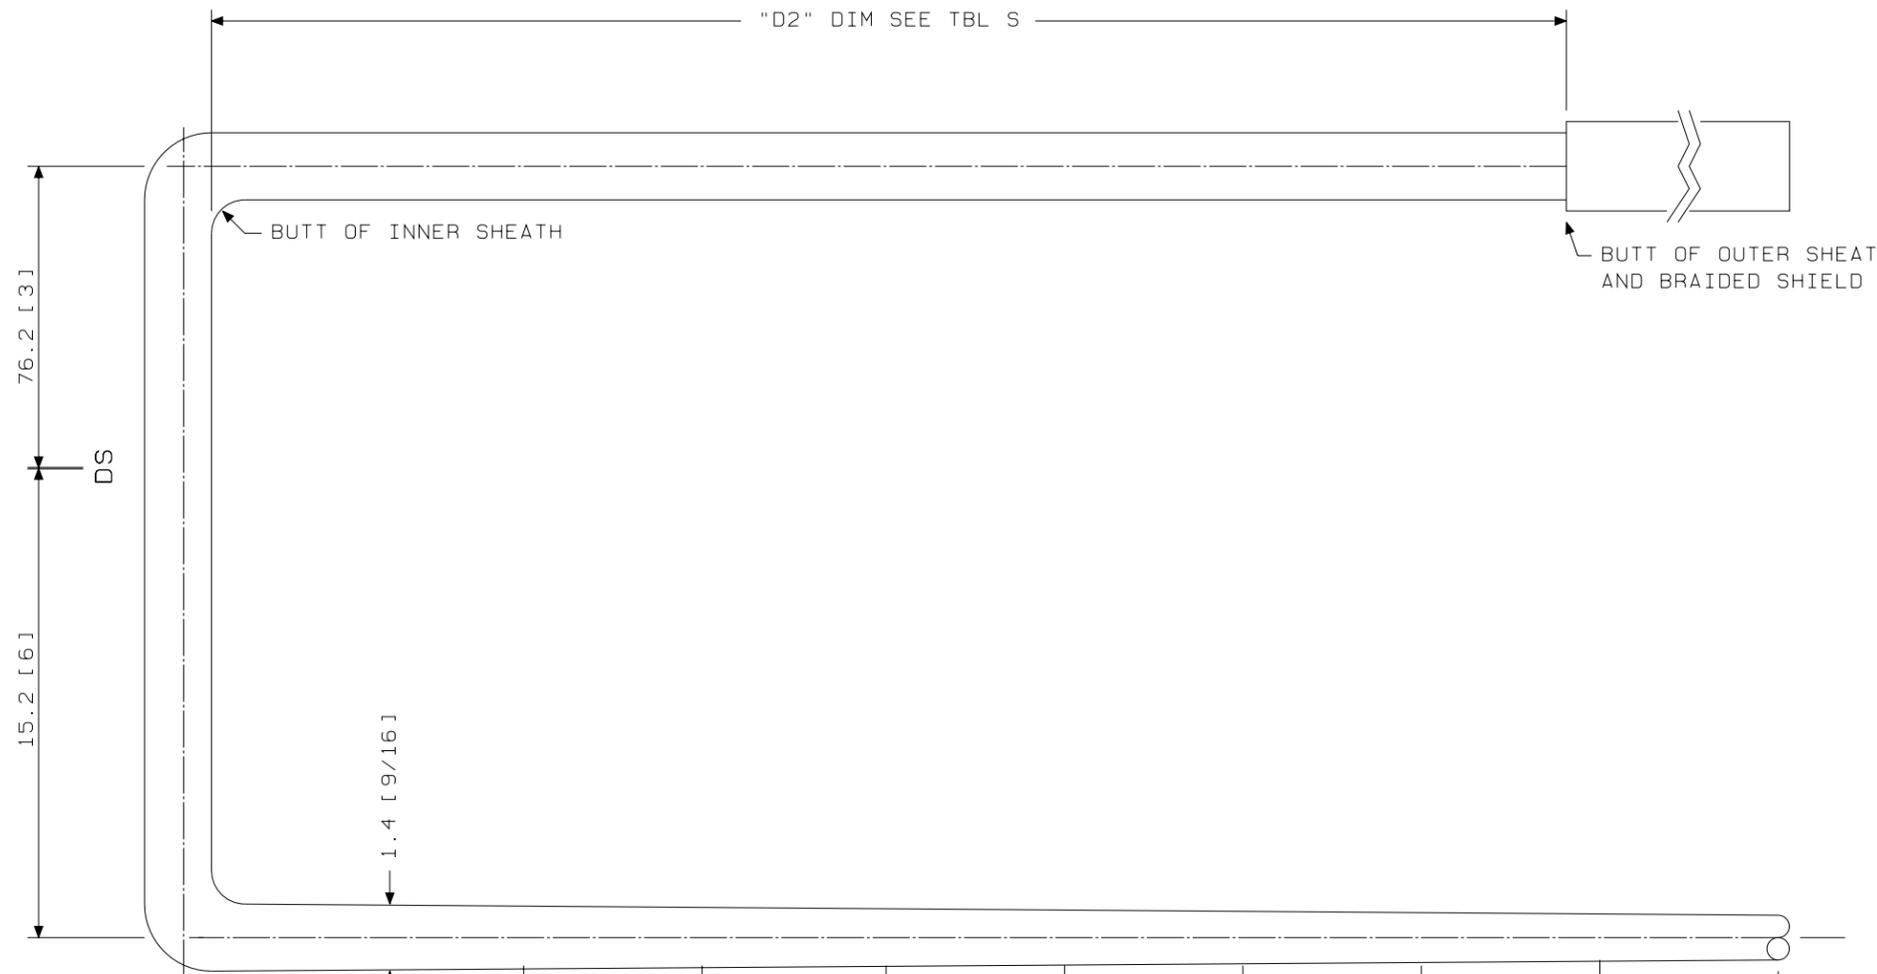


SK 26.7 [10 1/2] TO ARM ϕ (INCLUDES 25.4 [10] FOR MANUFACTURING PURPOSES)

GROUP 514A
 CABLE FOR INTEGRATED SERVICES LINE UNIT (4-WIRE) PBX APPL ONLY
 LG 10.11
 END "A"

SEE PROPRIETARY NOTICE ON SHEET ONE		
CONNECTORIZED SWITCHBOARD CABLE ASSEMBLIES	DWG SIZE	ISSUE
	C2	49
LUCENT TECHNOLOGIES INC.	ED5D621-35	SHEET C34

ED5D621-35

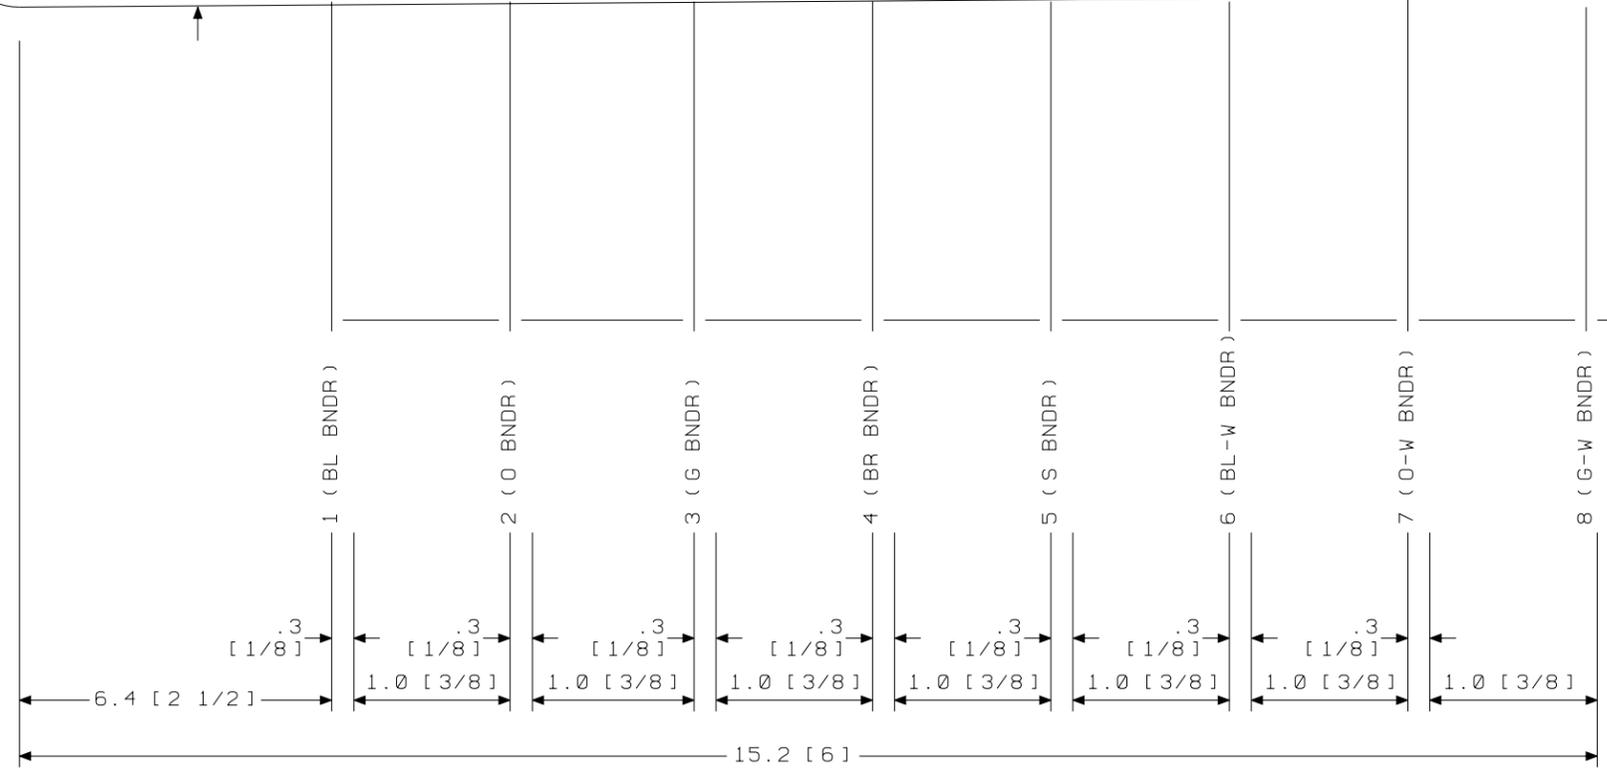


SK 26.7 [10 1/2] TO ARM ϕ (INCLUDES 25.4 [10] FOR MANUFACTURING PURPOSES)

GROUP 516A


CABLE FOR INTEGRATED SERVICES LINE UNIT (4-WIRE) PBX APPL ONLY
 LG 12,13
 END "A"

SEE PROPRIETARY NOTICE ON SHEET ONE		
CONNECTORIZED SWITCHBOARD CABLE ASSEMBLIES		
	DWG SIZE C2	ISSUE 49
LUCENT TECHNOLOGIES INC.	ED5D621-35	SHEET C35

ED5D621-35

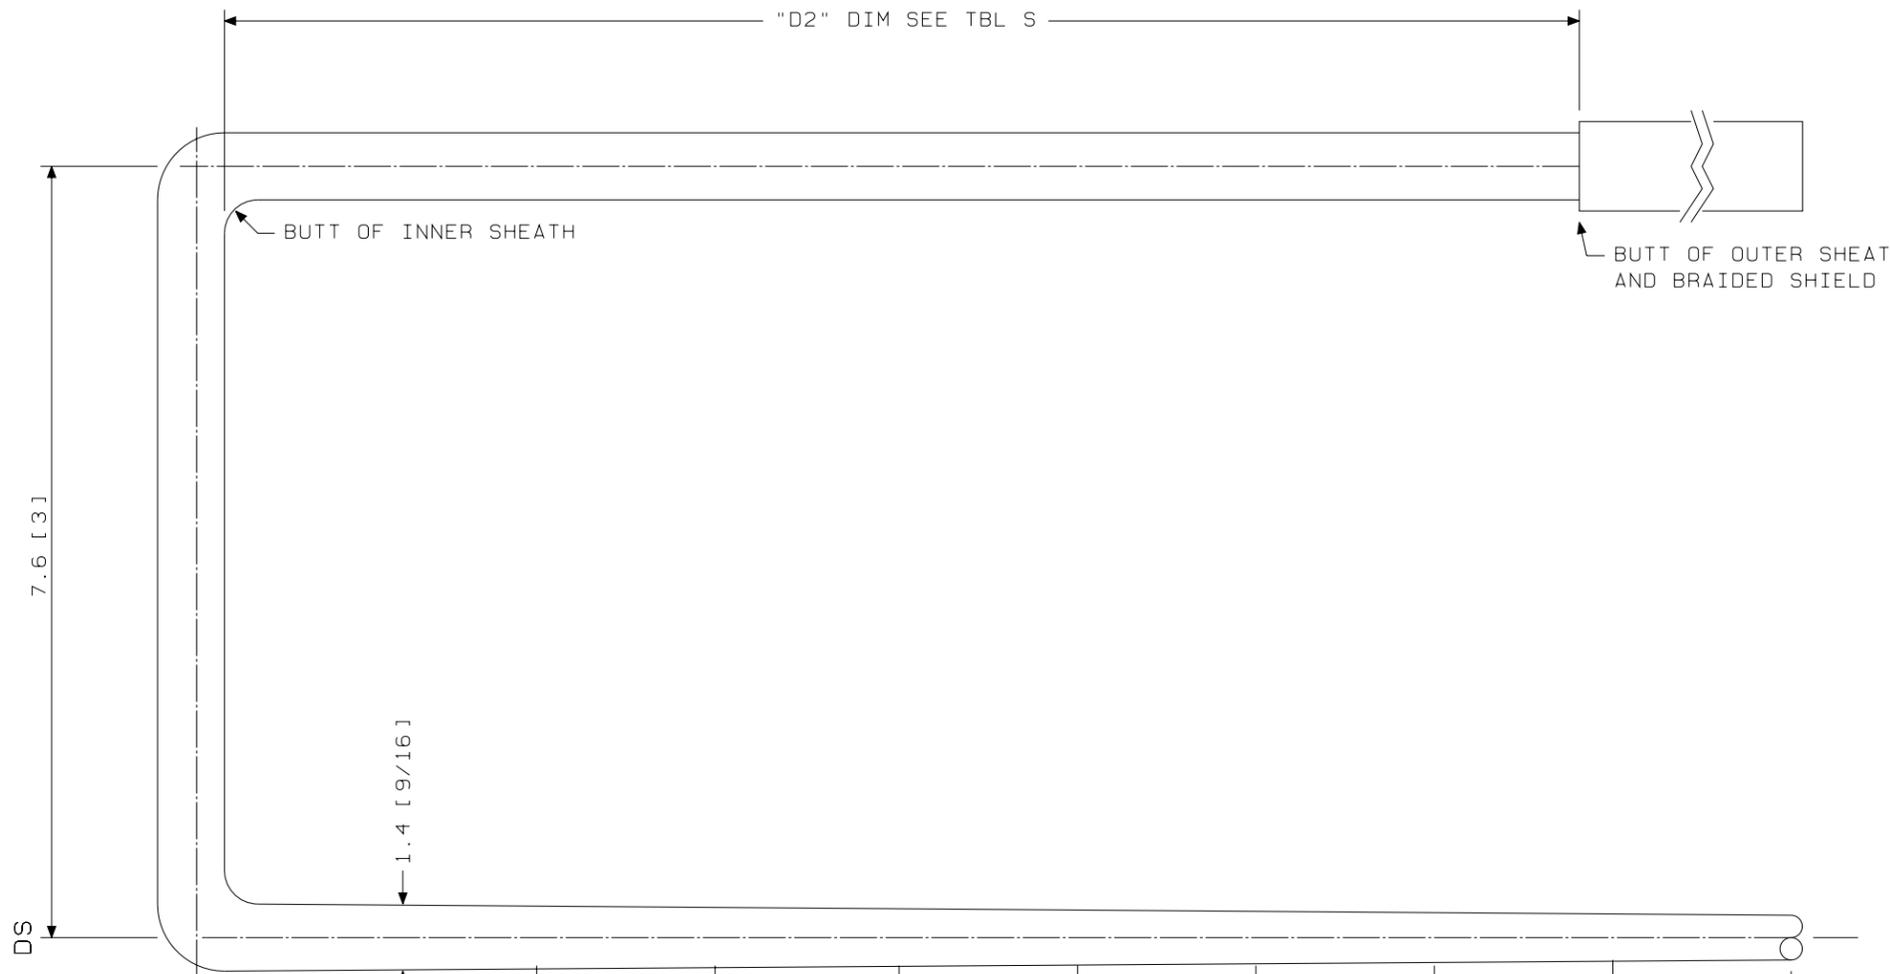

SK 26.7 [10 1/2] TO ARM C (INCLUDES 25.4 [10] INCHES FOR MANUFACTURING PURPOSES)

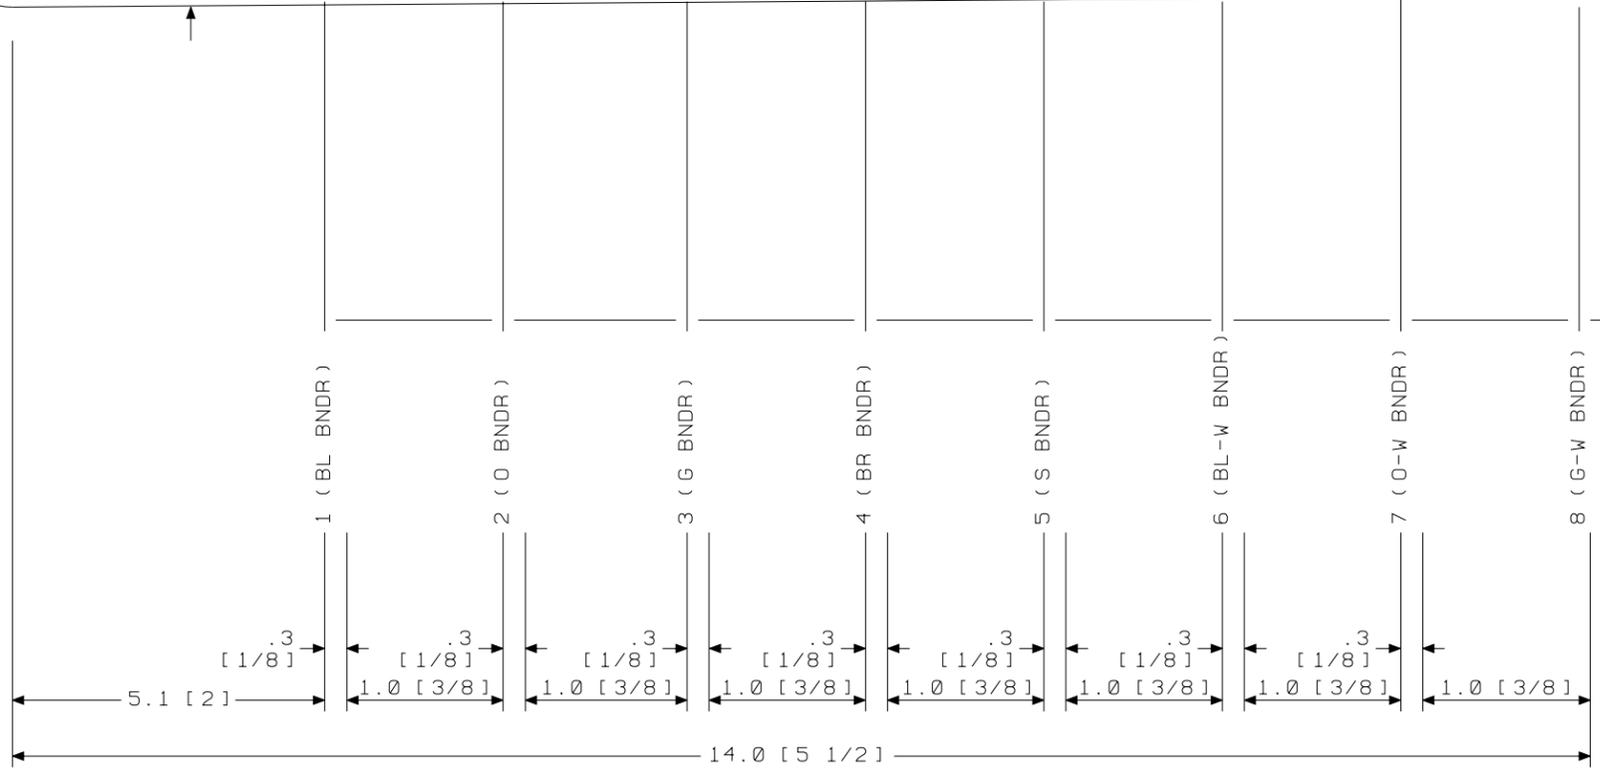


GROUP 518A
 CABLE FOR INTEGRATED SERVICES LINE UNIT (4-WIRE) PBX APPL ONLY
 LG 14.15
 END "A"

SEE PROPRIETARY NOTICE ON SHEET ONE		
CONNECTORIZED SWITCHBOARD CABLE ASSEMBLIES	DWG SIZE	ISSUE
	c2	49
LUCENT TECHNOLOGIES INC.	ED5D621-35	SHEET C36

ED5D621-35

SK 26.7 [10 1/2] TO ARM ϕ (INCLUDES 25.4 [10] FOR MANUFACTURING PURPOSES)

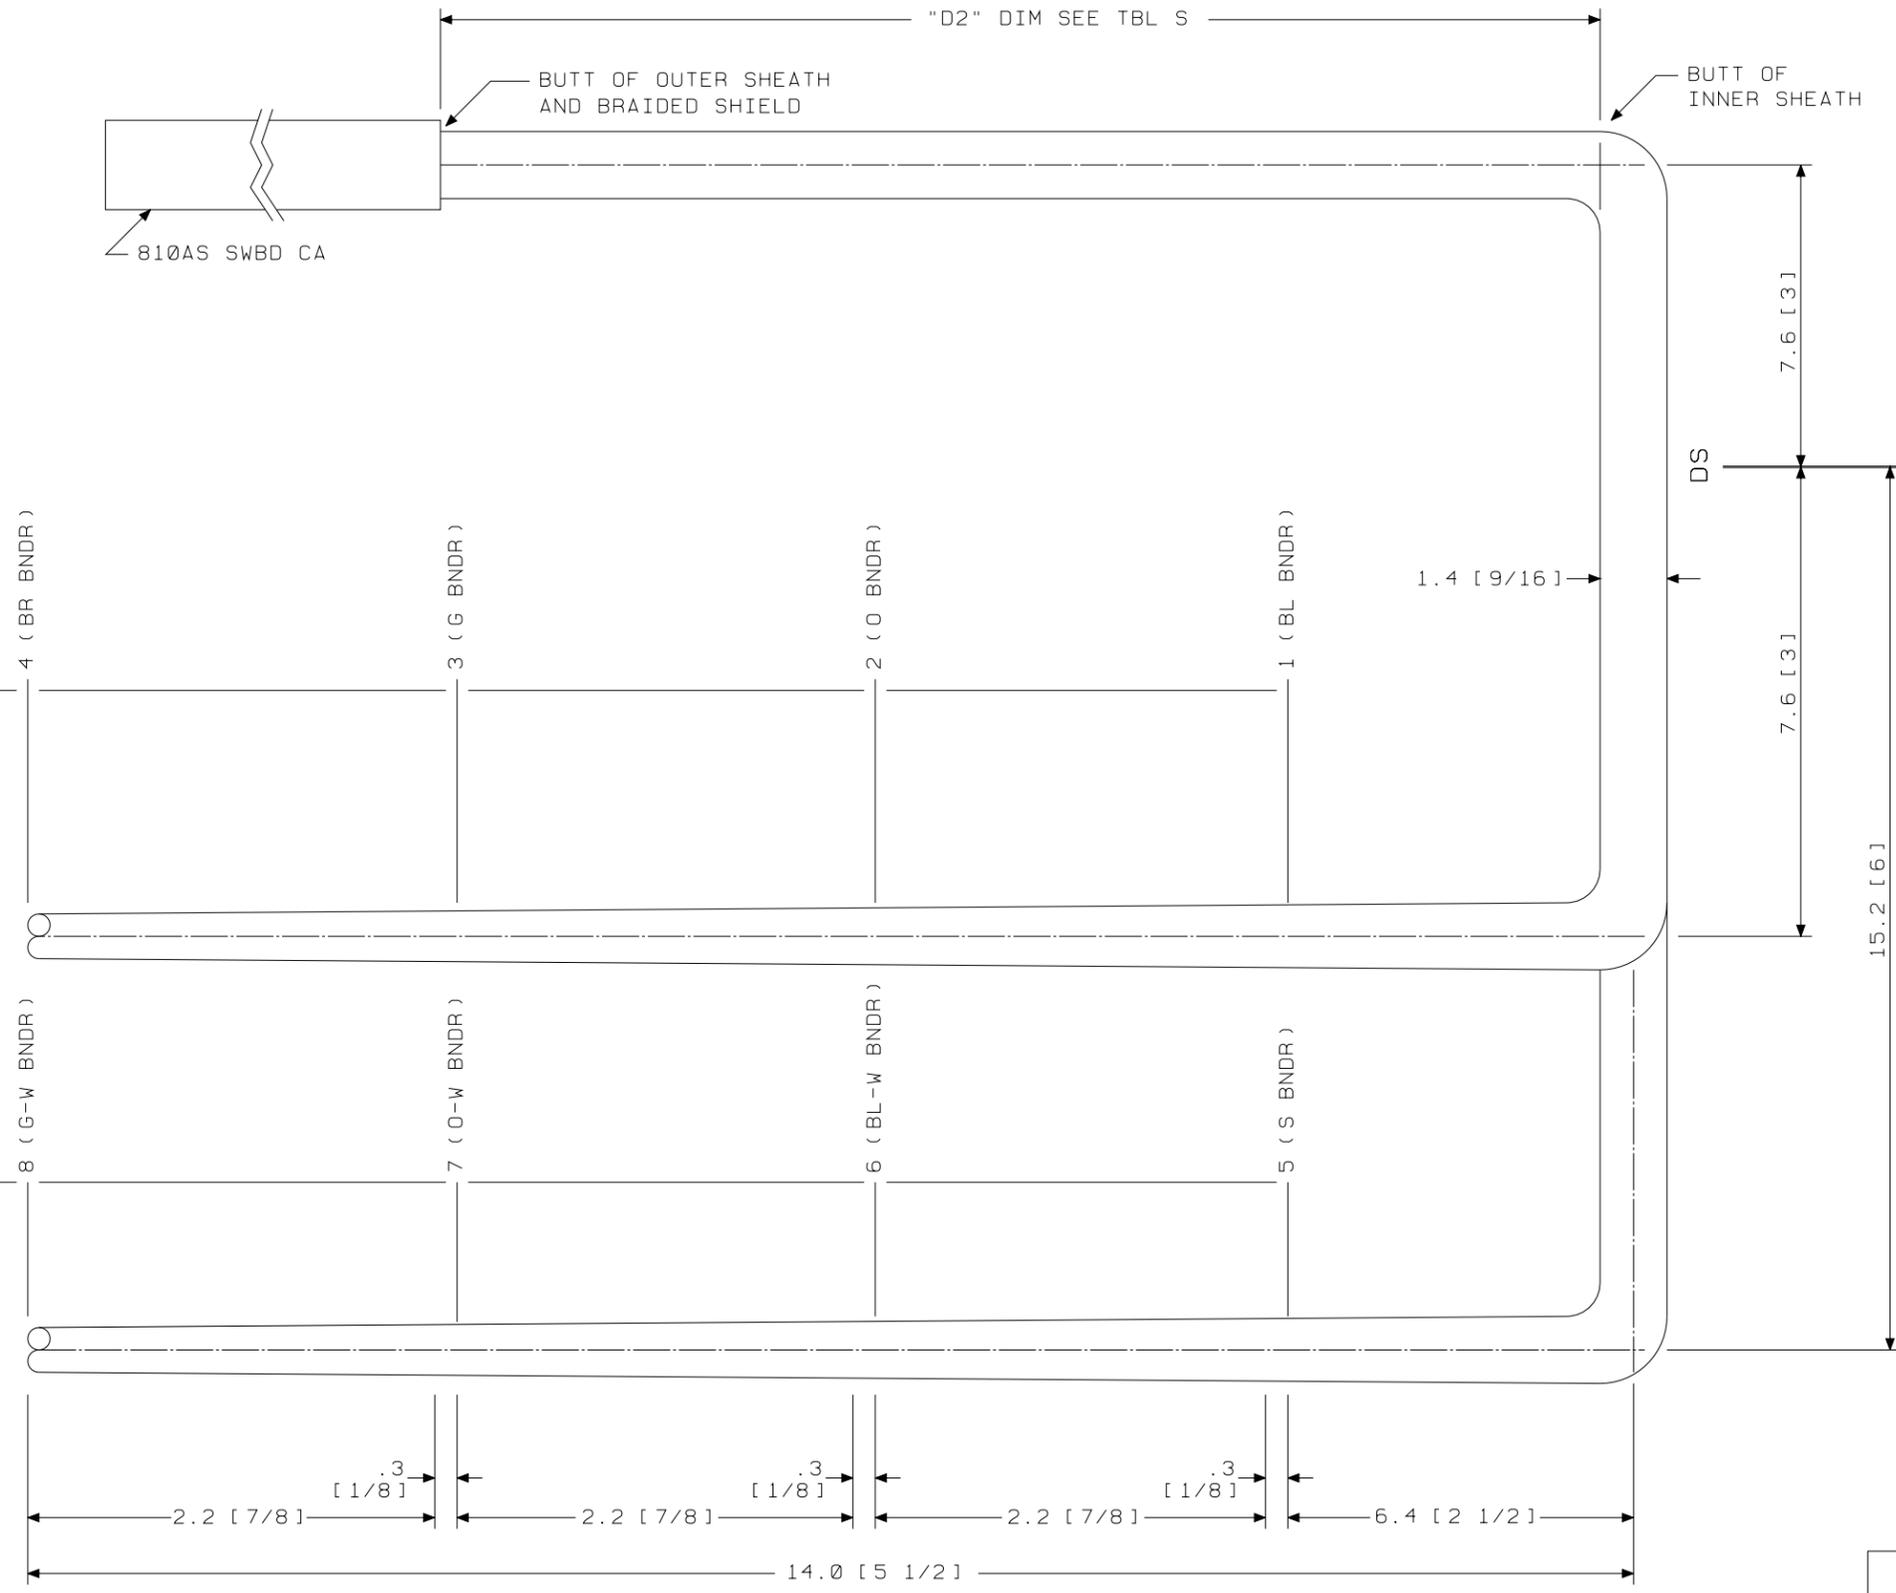


GROUP 521A OR 561A
 CABLE FOR INTEGRATED SERVICES LINE UNIT (2-WIRE) PBX APPL ONLY
 LG 00-03
 END "A"

SEE PROPRIETARY NOTICE ON SHEET ONE		
CONNECTORIZED SWITCHBOARD CABLE ASSEMBLIES		DWG SIZE c2
LUCENT TECHNOLOGIES INC.		ISSUE 49 SHEET c37
ED5D621-35		

ED5D621-35


SK 26.7 [10 1/2] TO ARM ϕ (INCLUDES 25.4 [10] FOR MANUFACTURING PURPOSES)

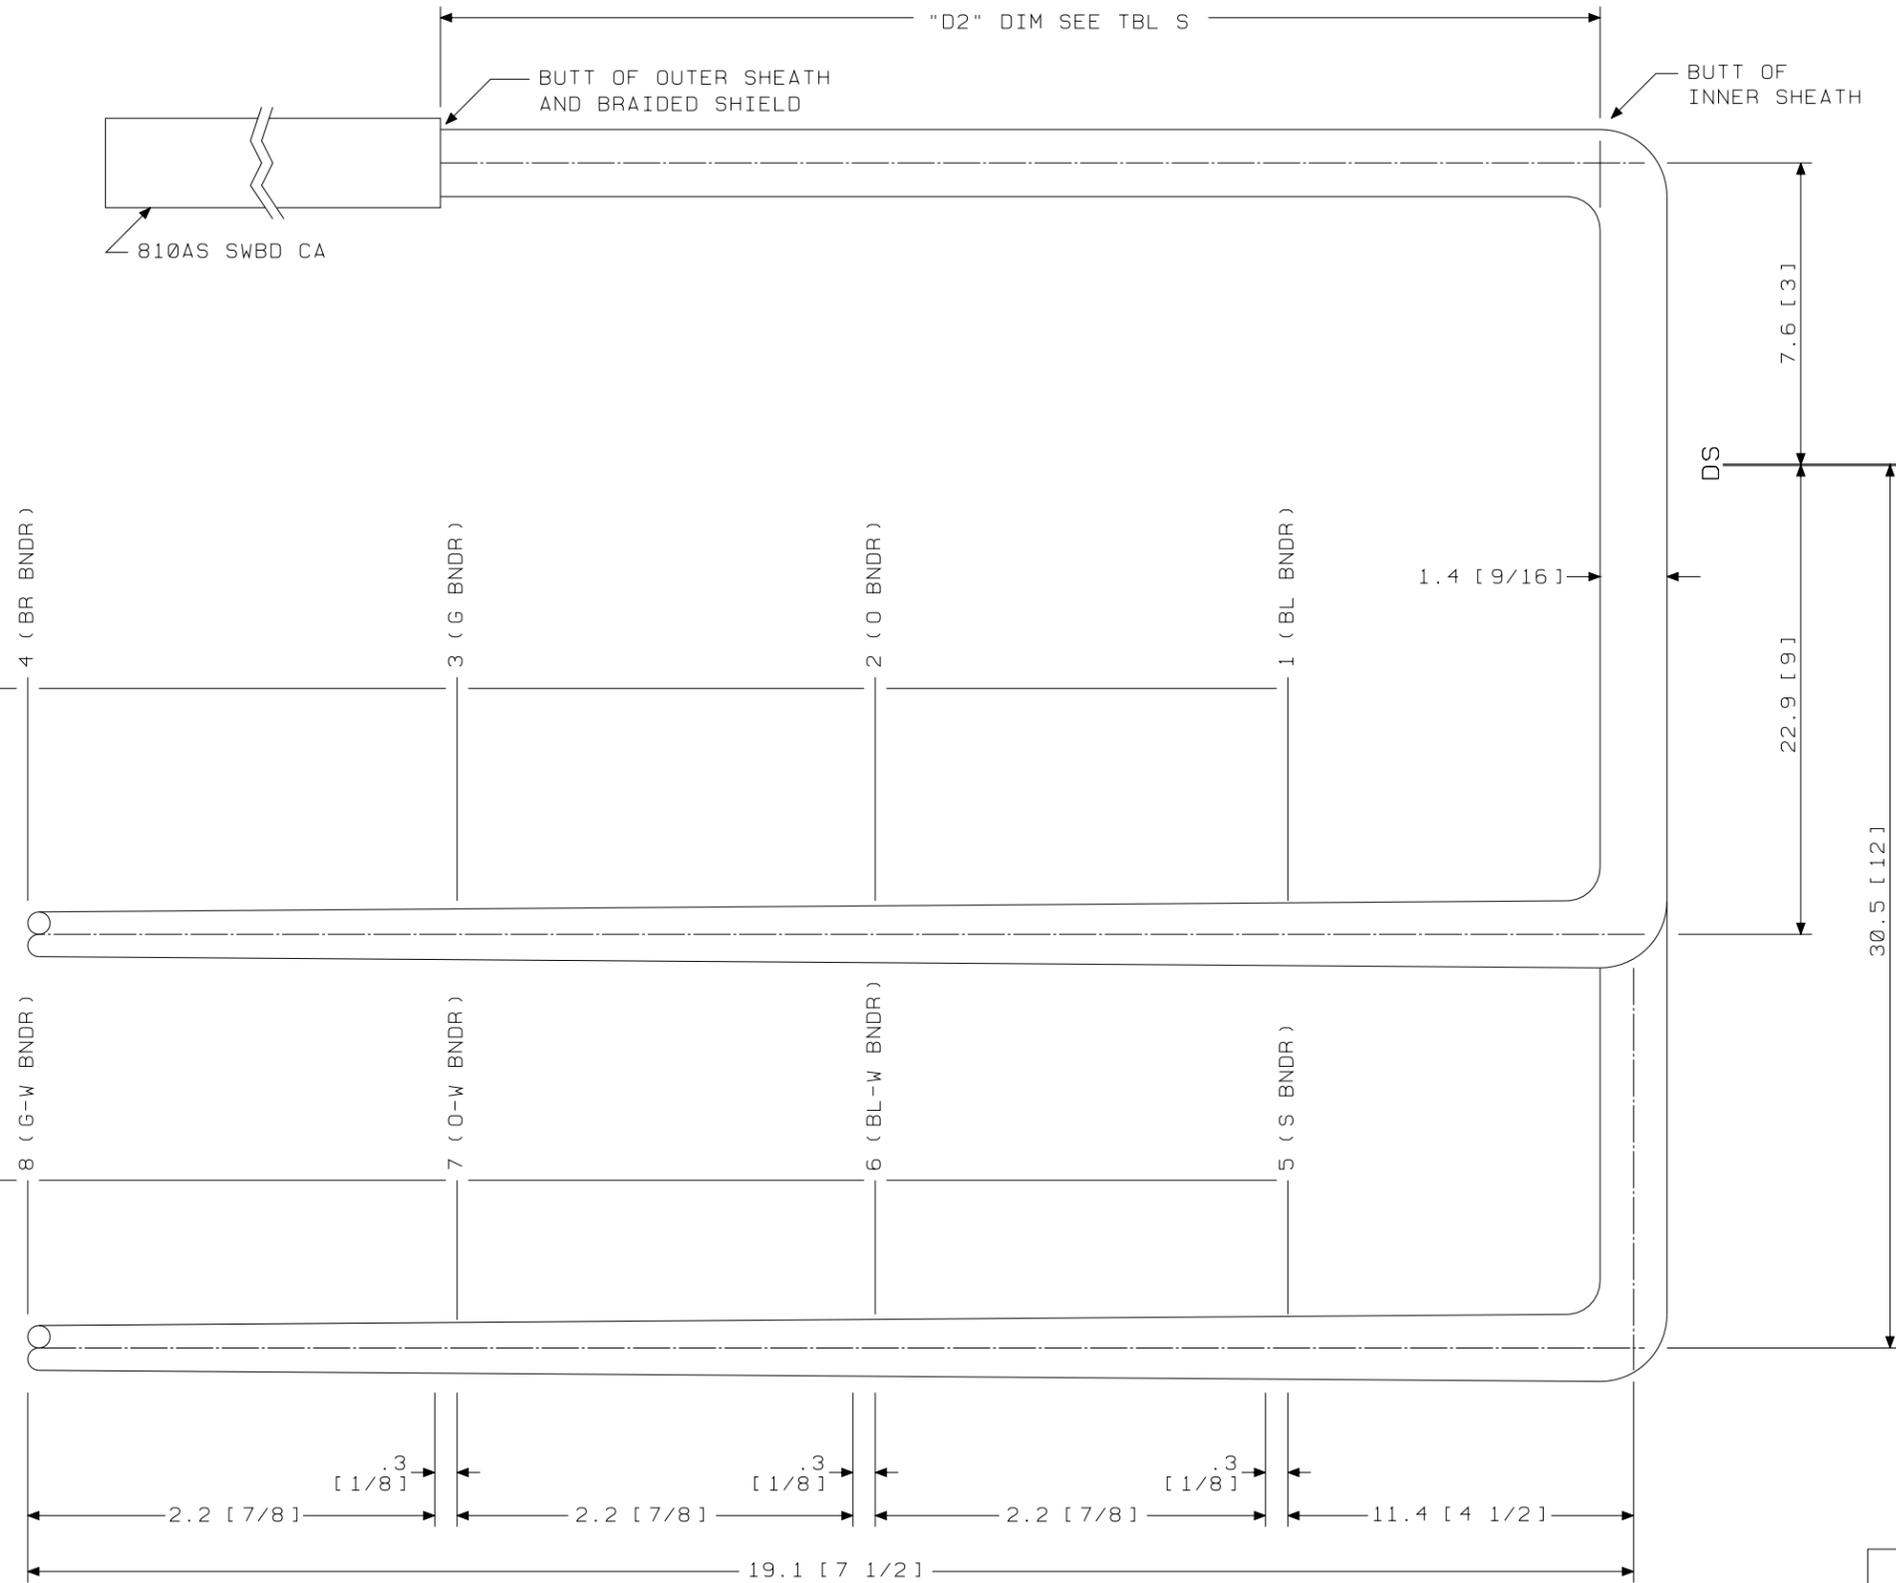

GROUP 523A OR 563A
 CABLE FOR INTEGRATED SERVICES LINE UNIT (2-WIRE) PBX APPL ONLY
 LG 04-07
 END "A"

SEE PROPRIETARY NOTICE ON SHEET ONE		
CONNECTORIZED SWITCHBOARD CABLE ASSEMBLIES	DWG SIZE	ISSUE
	c2	49
LUCENT TECHNOLOGIES INC.	ED5D621-35	SHEET C38


ED5D621-35

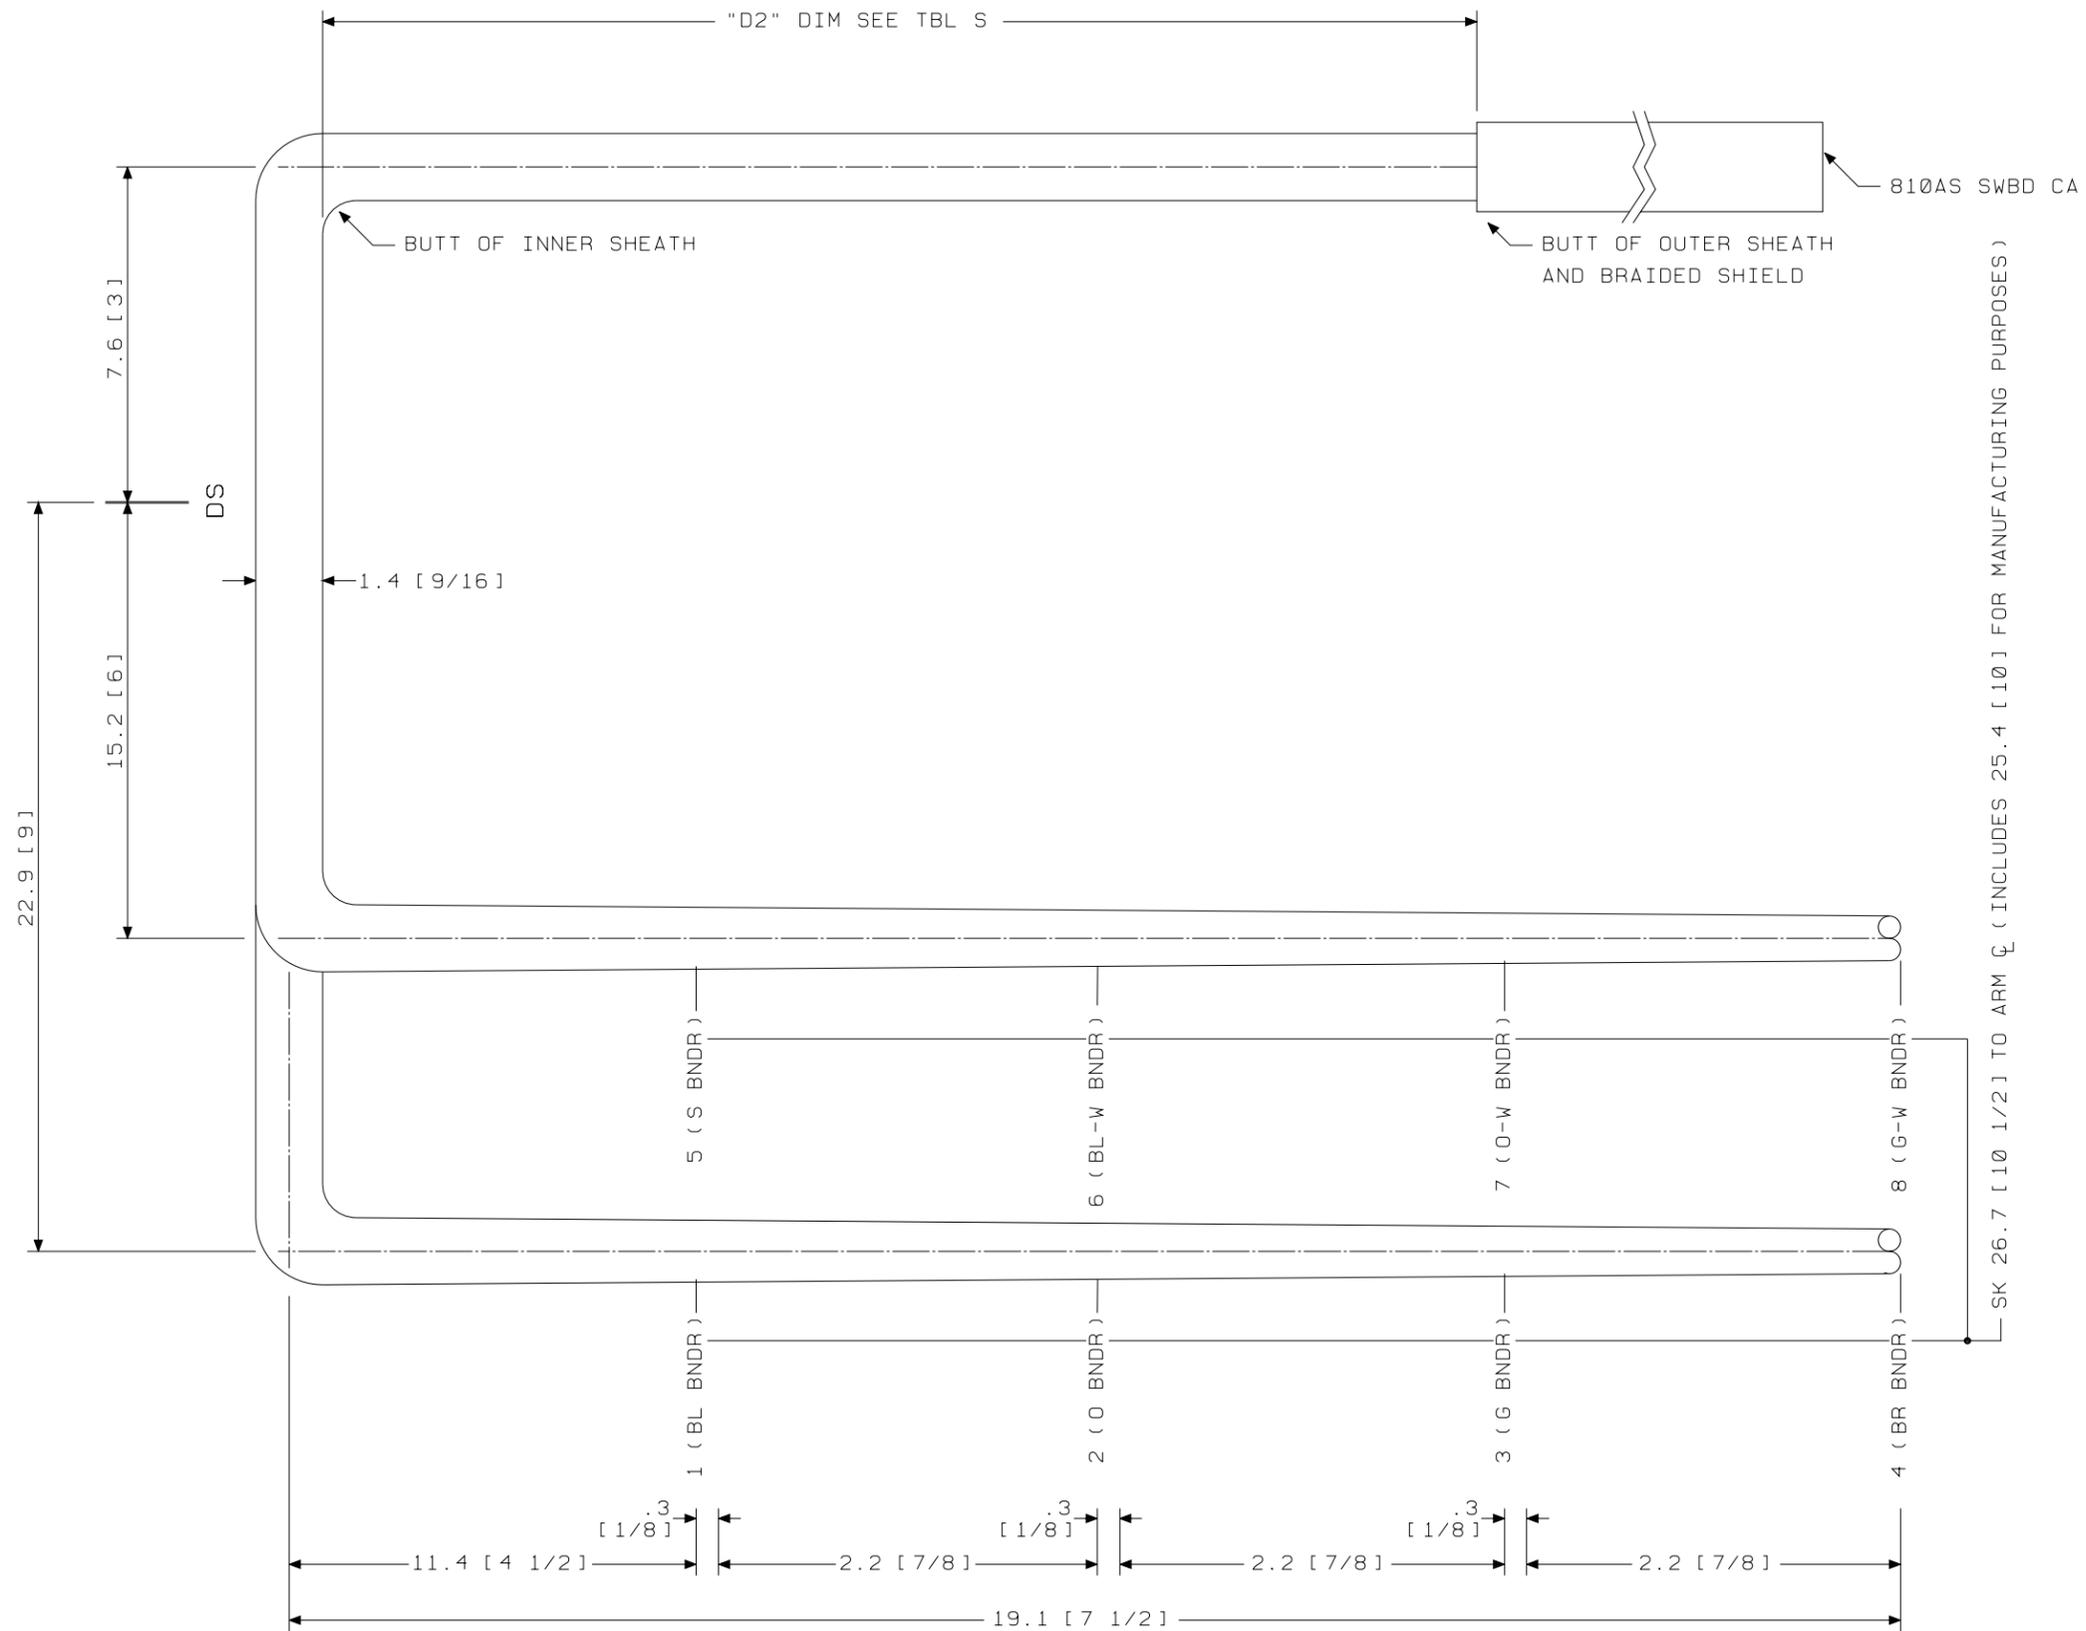

GROUP 522A OR 562A
 CABLE FOR INTEGRATED SERVICES LINE UNIT (2-WIRE) PBX APPL ONLY
 LG 08-11
 END "A"

SEE PROPRIETARY NOTICE ON SHEET ONE		
CONNECTORIZED SWITCHBOARD CABLE ASSEMBLIES		
	DWG SIZE c2	ISSUE 49
LUCENT TECHNOLOGIES INC.	ED5D621-35	SHEET c39

ED5D621-35

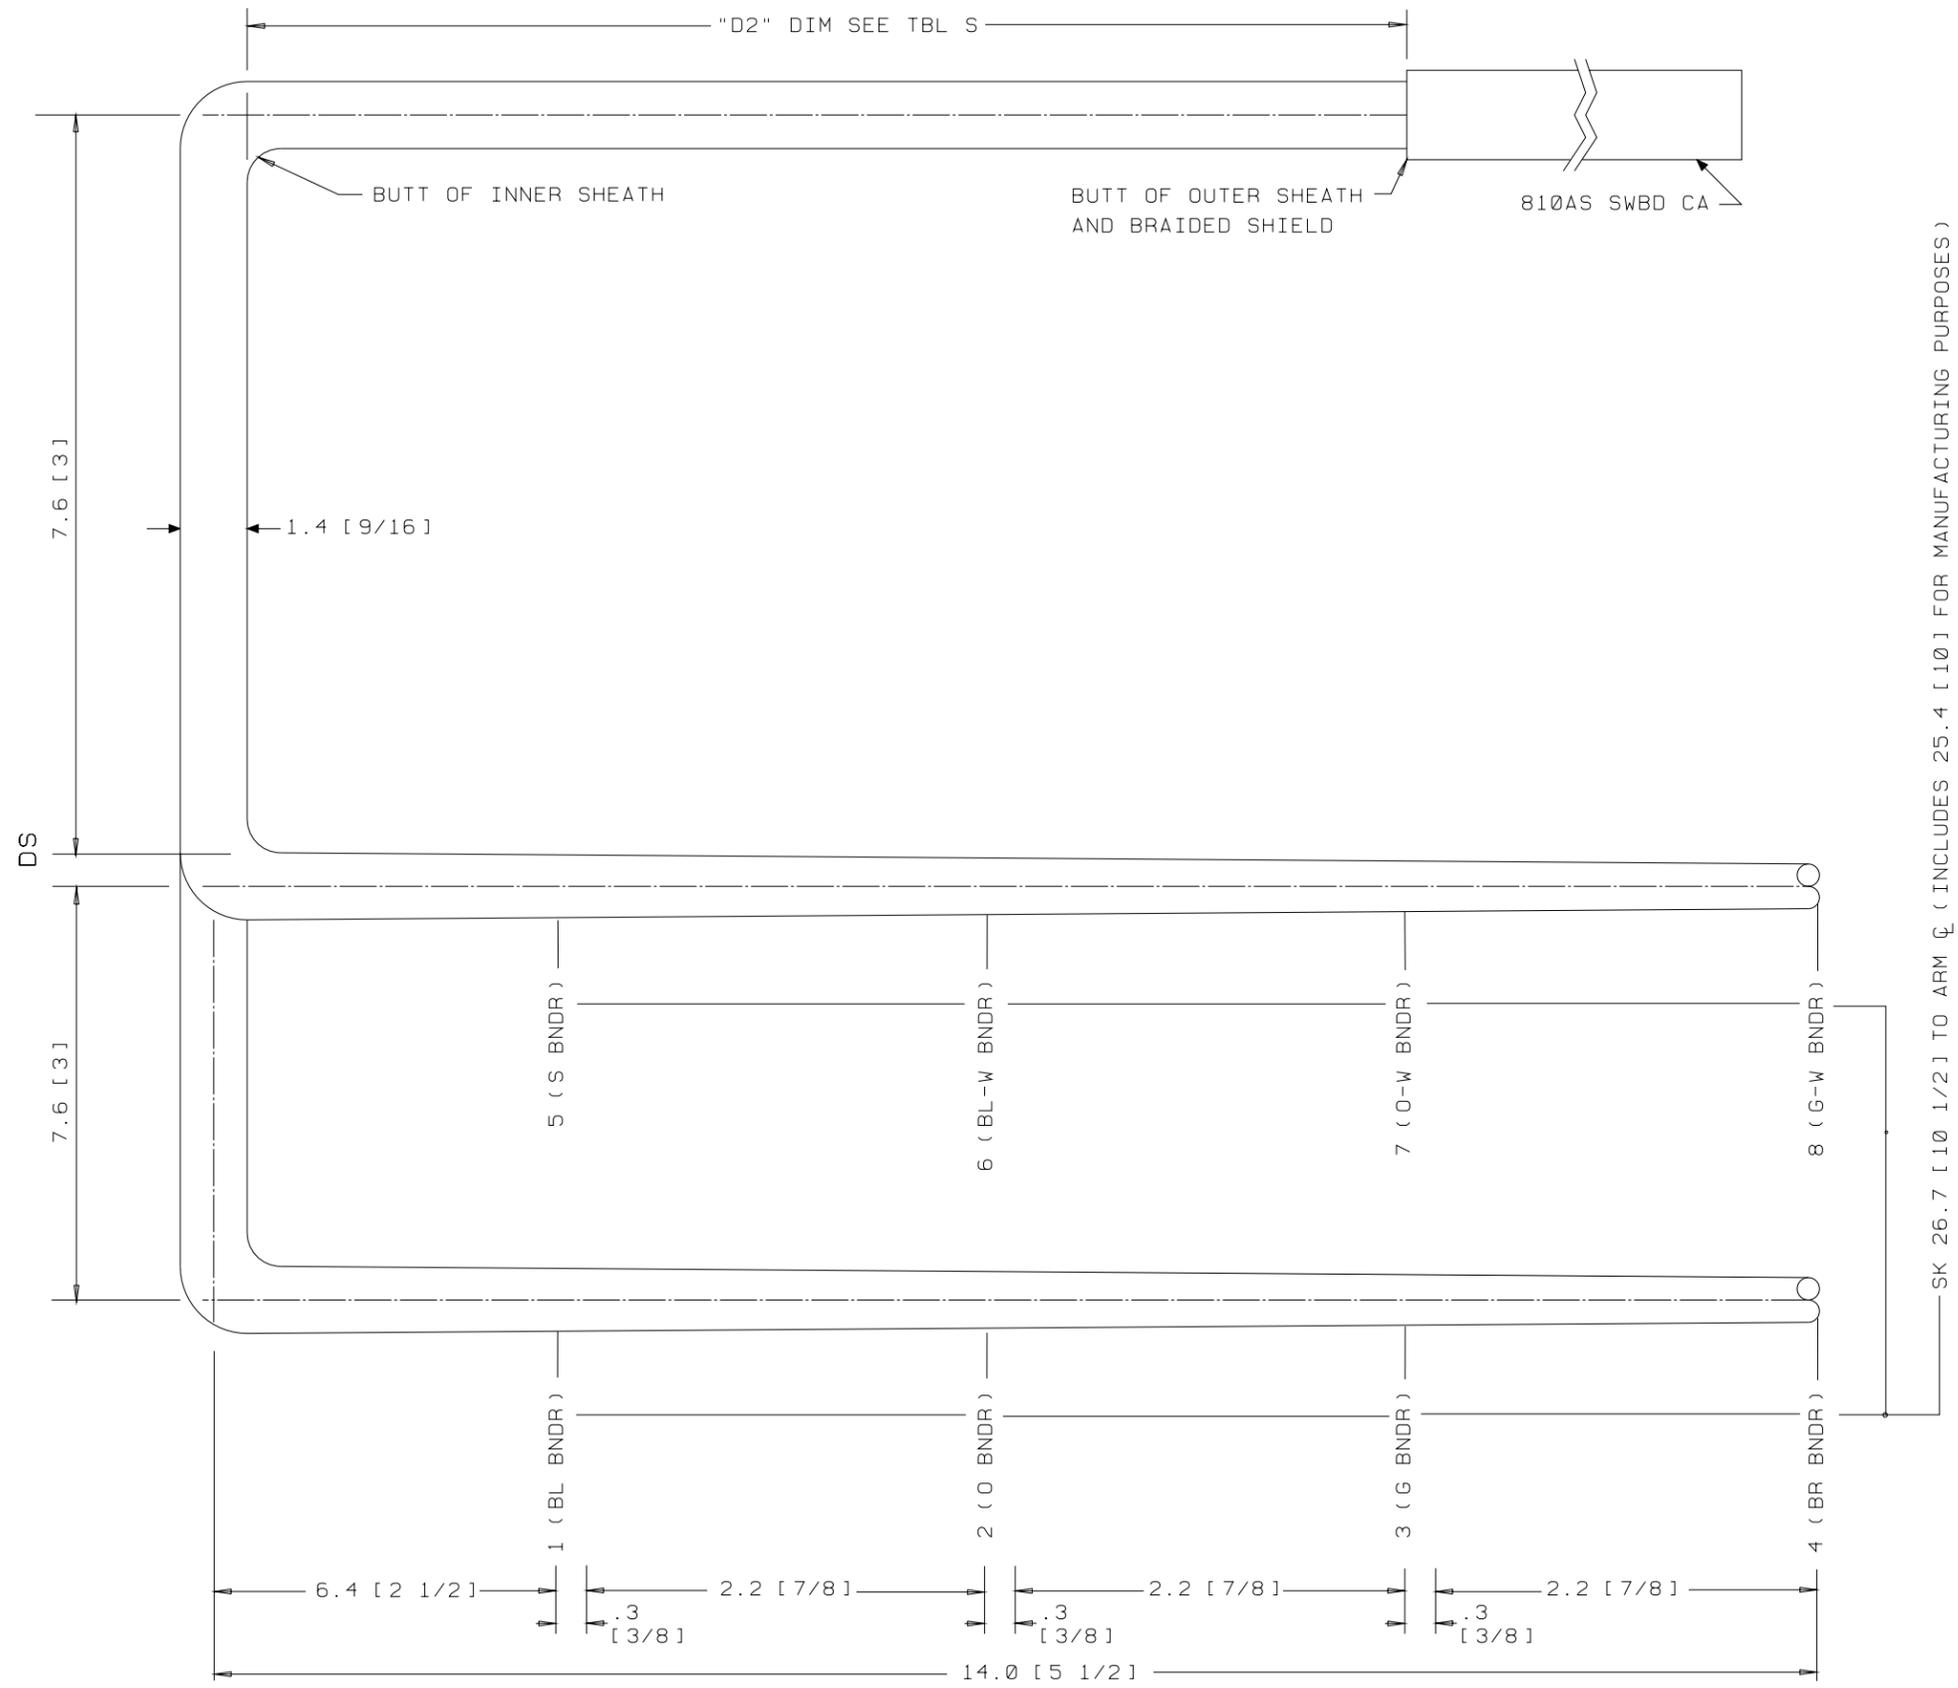


GROUP 524 OR 564A
 CABLE FOR INTEGRATED SERVICES LINE UNIT (2-WIRE) PBX APPL ONLY
 LG 12-15
 END "A"

SEE PROPRIETARY NOTICE ON SHEET ONE		
CONNECTORIZED SWITCHBOARD CABLE ASSEMBLIES	DWG SIZE	ISSUE
	C2	49
LUCENT TECHNOLOGIES INC.	ED5D621-35	SHEET C40

ED5D621-35


SK 26.7 [10 1/2] TO ARM ϕ (INCLUDES 25.4 [10] FOR MANUFACTURING PURPOSES)

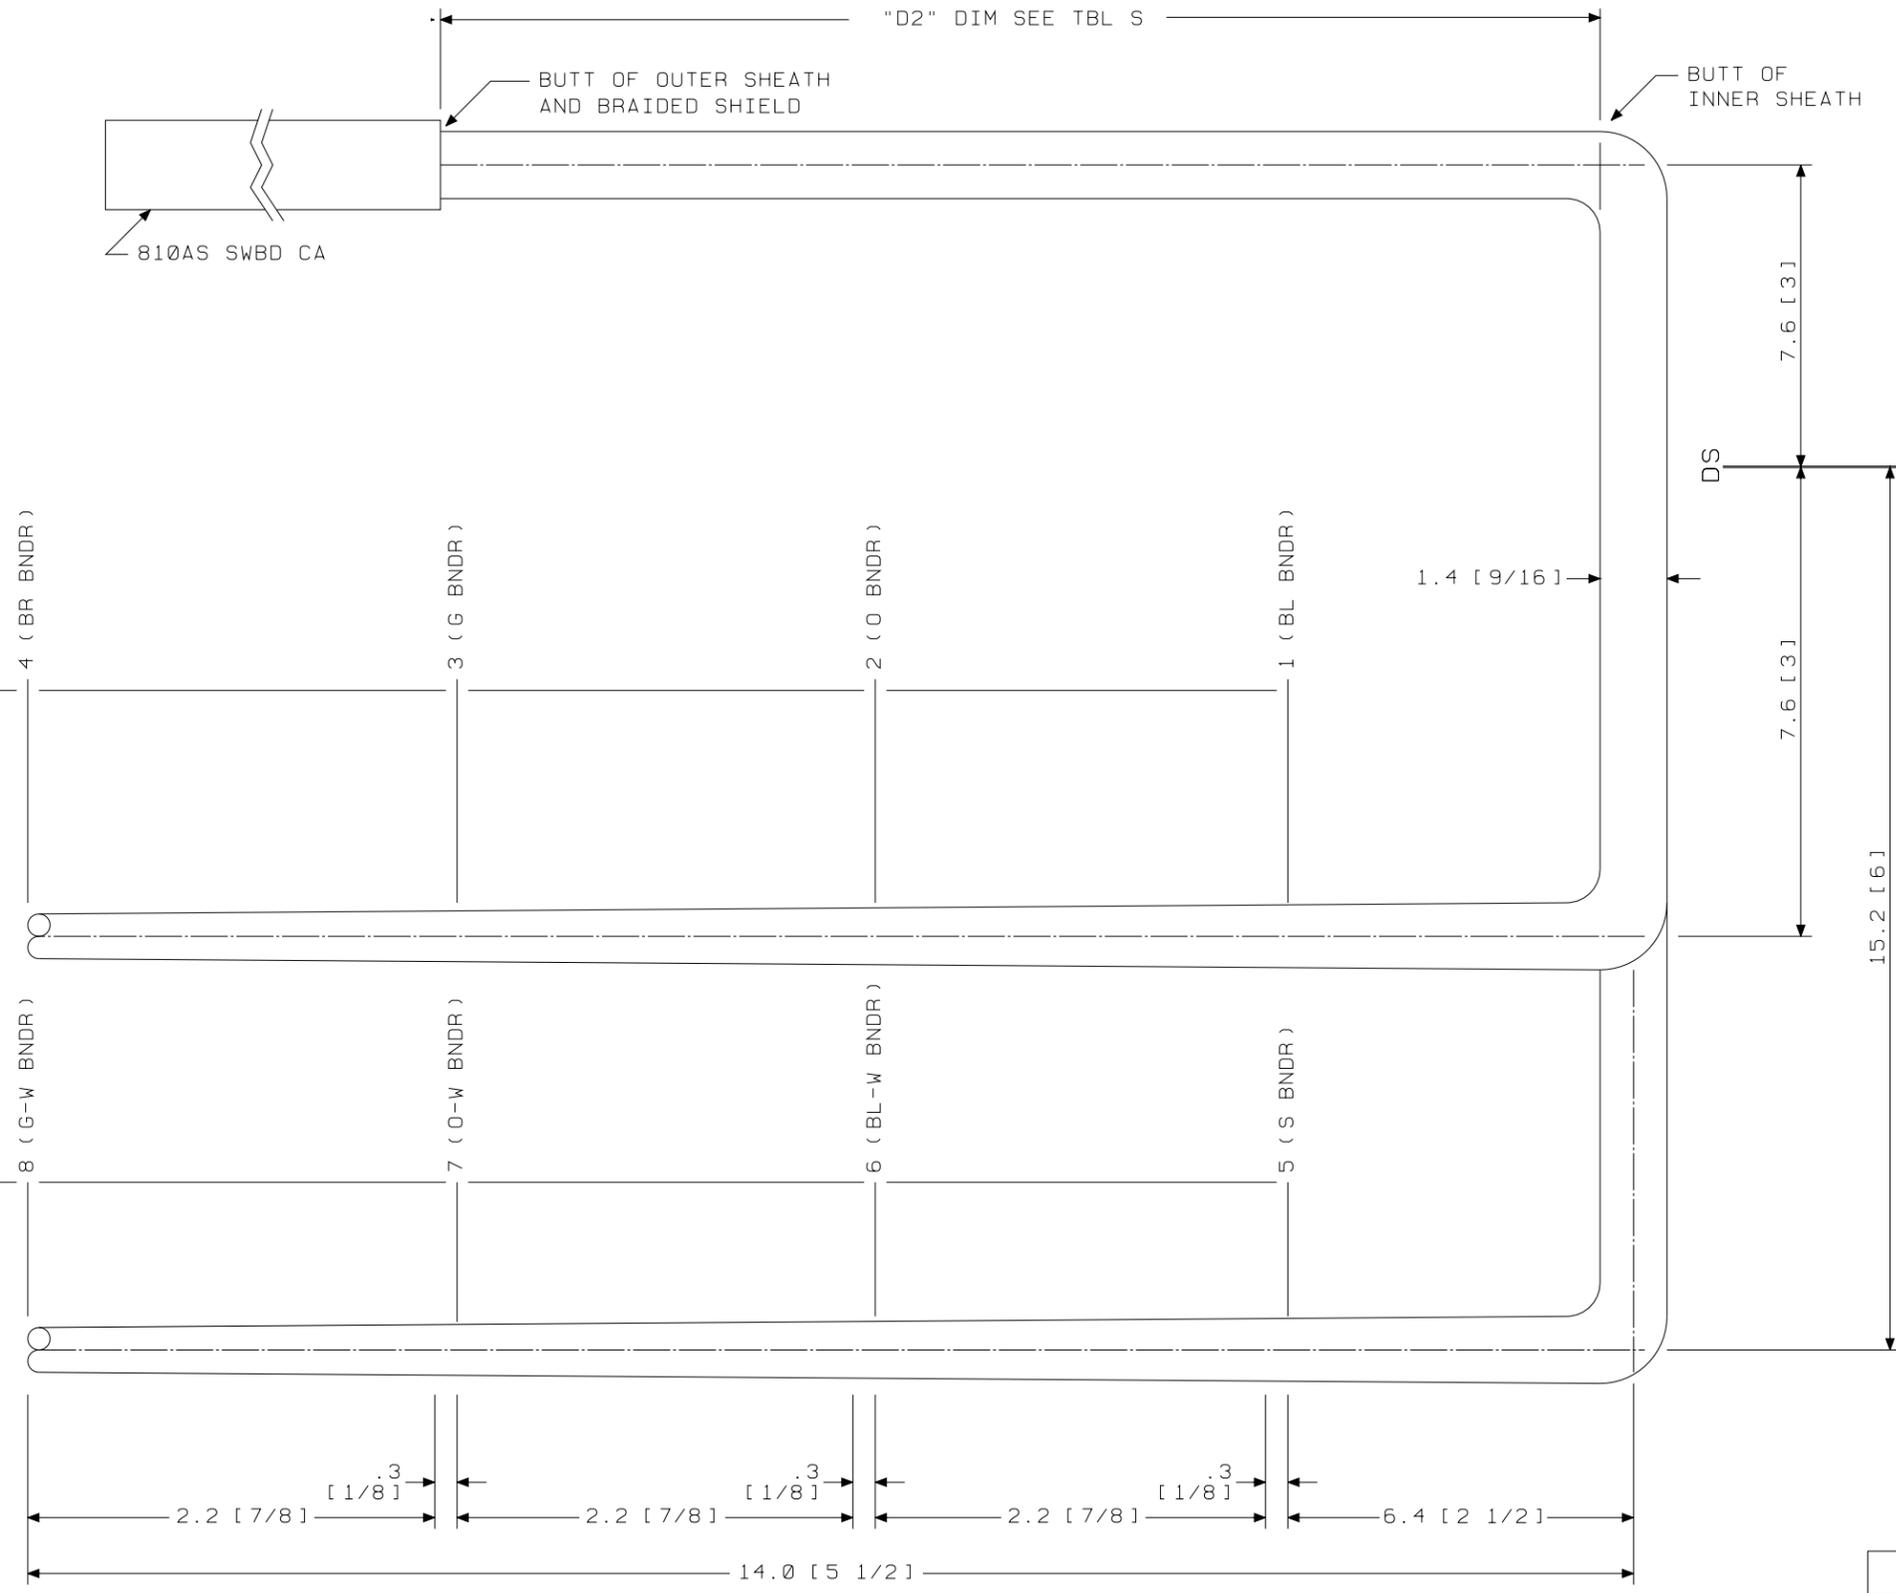

GROUP 531A
 CABLE FOR INTEGRATED SERVICES LINE UNIT (2-WIRE) PBX APPL ONLY
 LG 00-03
 END "A"

SEE PROPRIETARY NOTICE ON SHEET ONE		
CONNECTORIZED SWITCHBOARD CABLE ASSEMBLIES		
	DWG SIZE c2	ISSUE 49
LUCENT TECHNOLOGIES INC.	ED5D621-35	SHEET c41


ED5D621-35

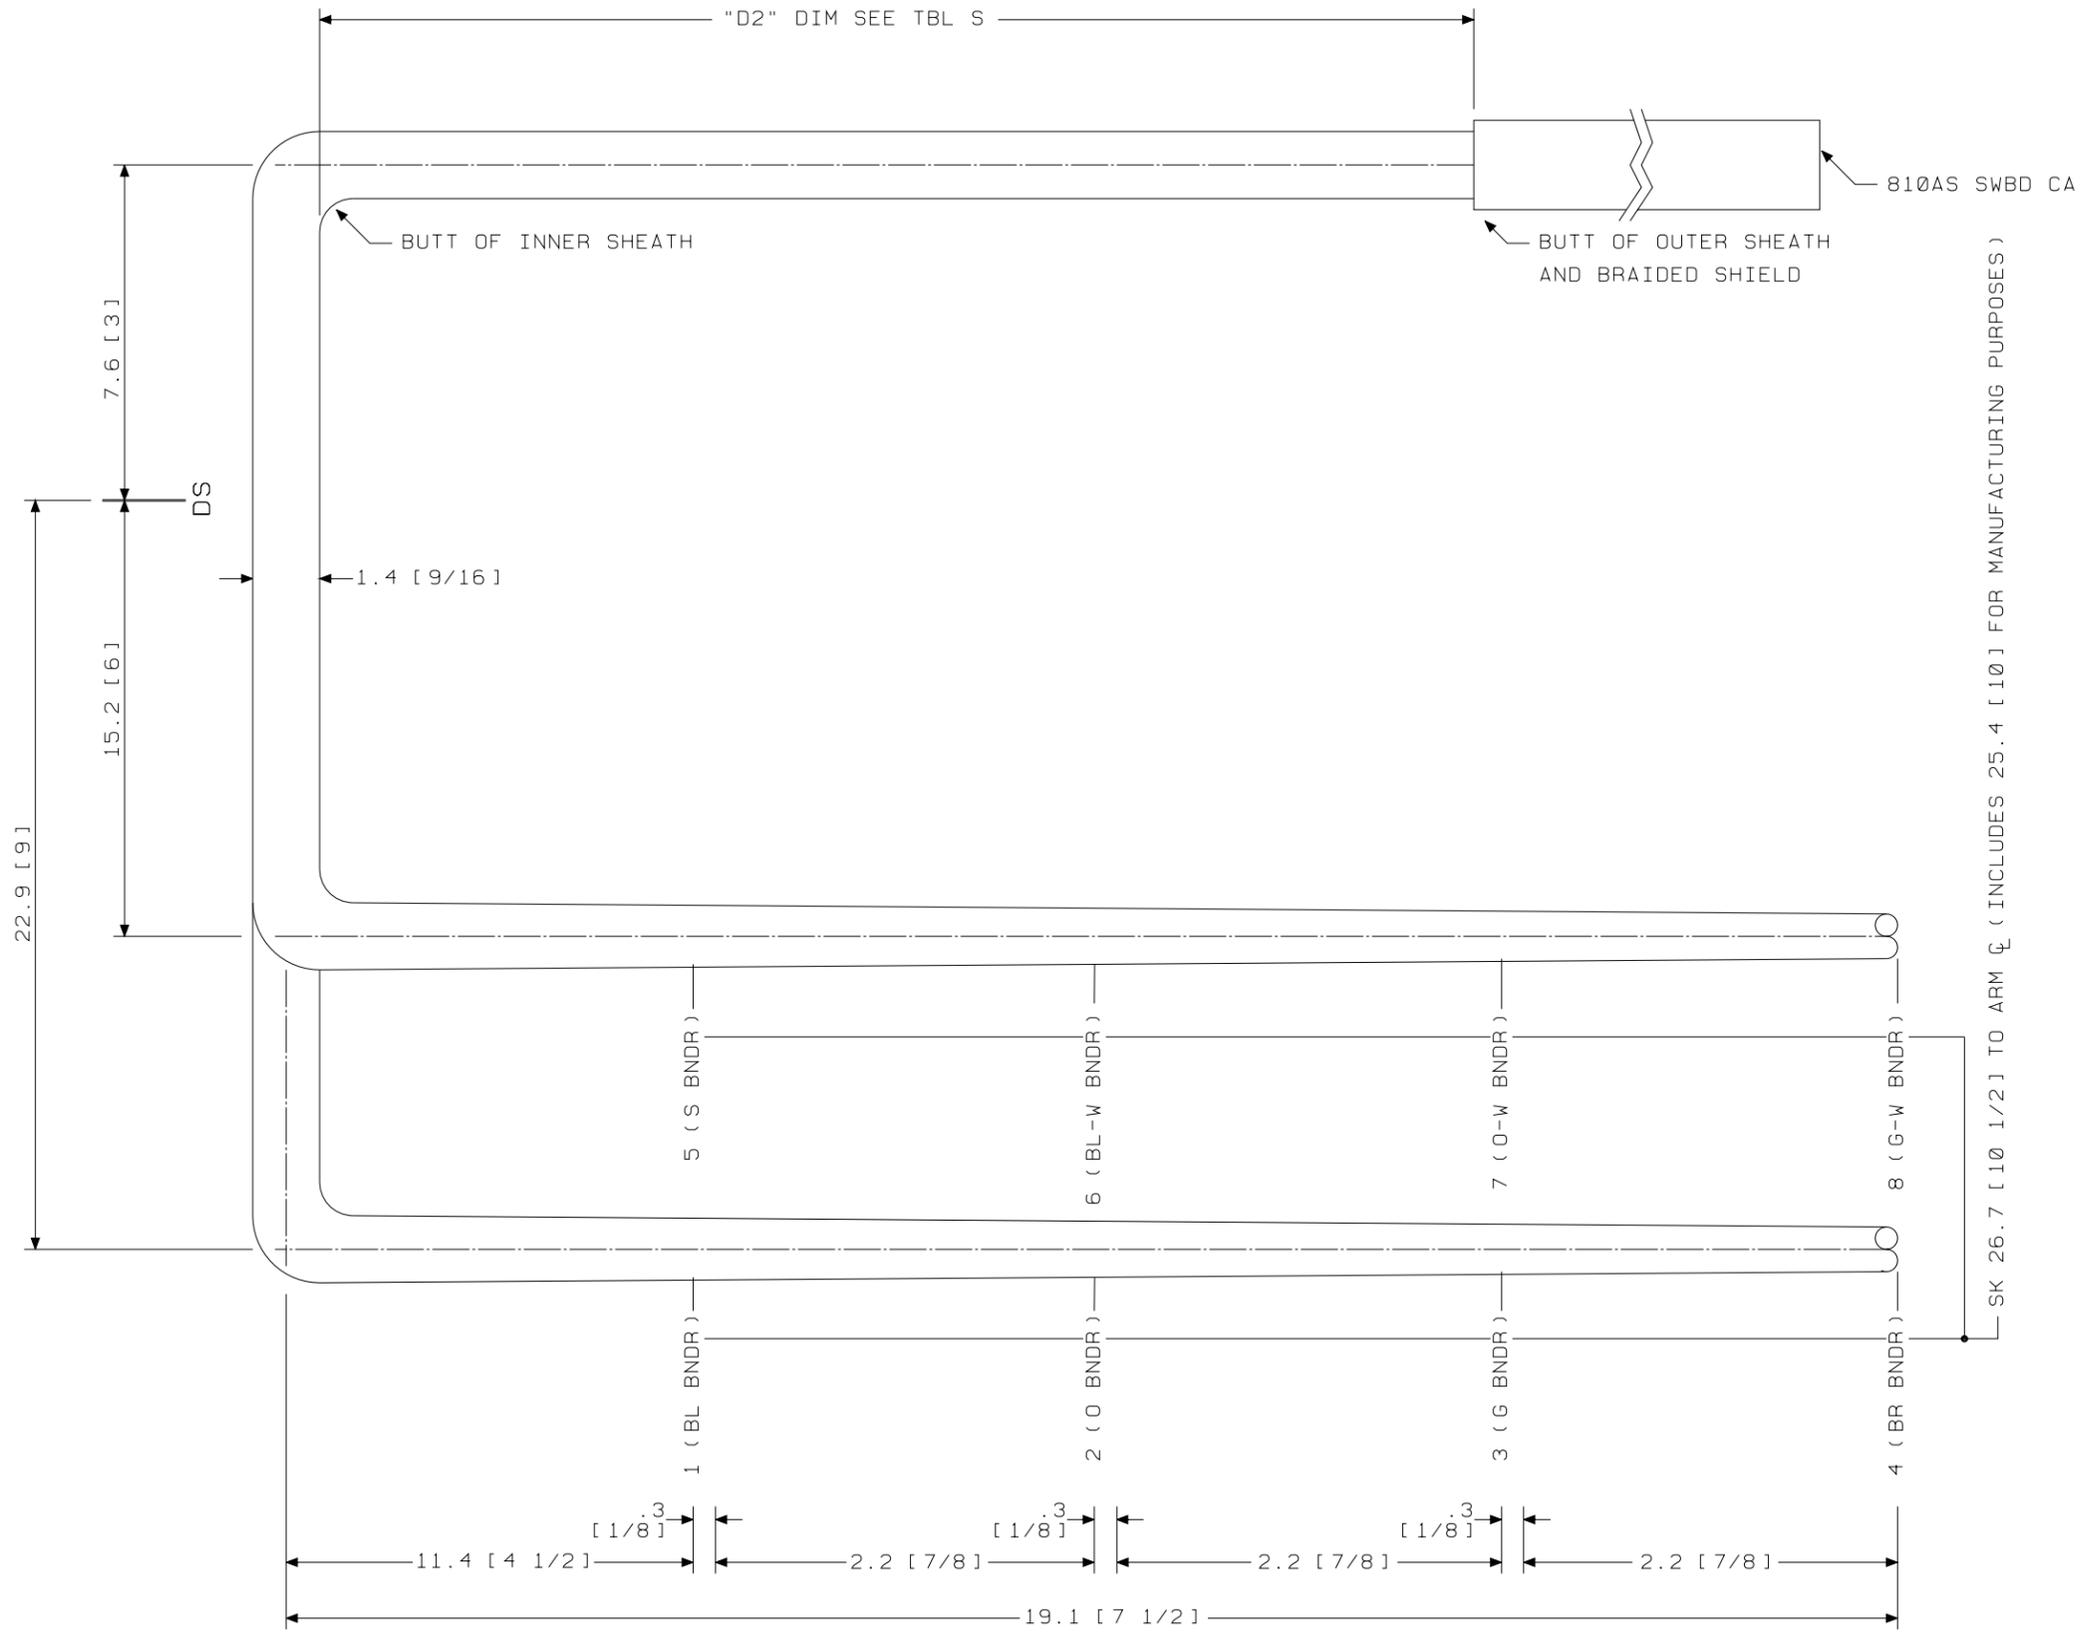

GROUP 532A
 CABLE FOR INTEGRATED SERVICES LINE UNIT (2-WIRE) PBX APPL ONLY
 LG 08-11
 END "A"

SEE PROPRIETARY NOTICE ON SHEET ONE		
CONNECTORIZED SWITCHBOARD CABLE ASSEMBLIES		
	DWG SIZE C2	ISSUE 49
LUCENT TECHNOLOGIES INC.	ED5D621-35	SHEET C43

ED5D621-35

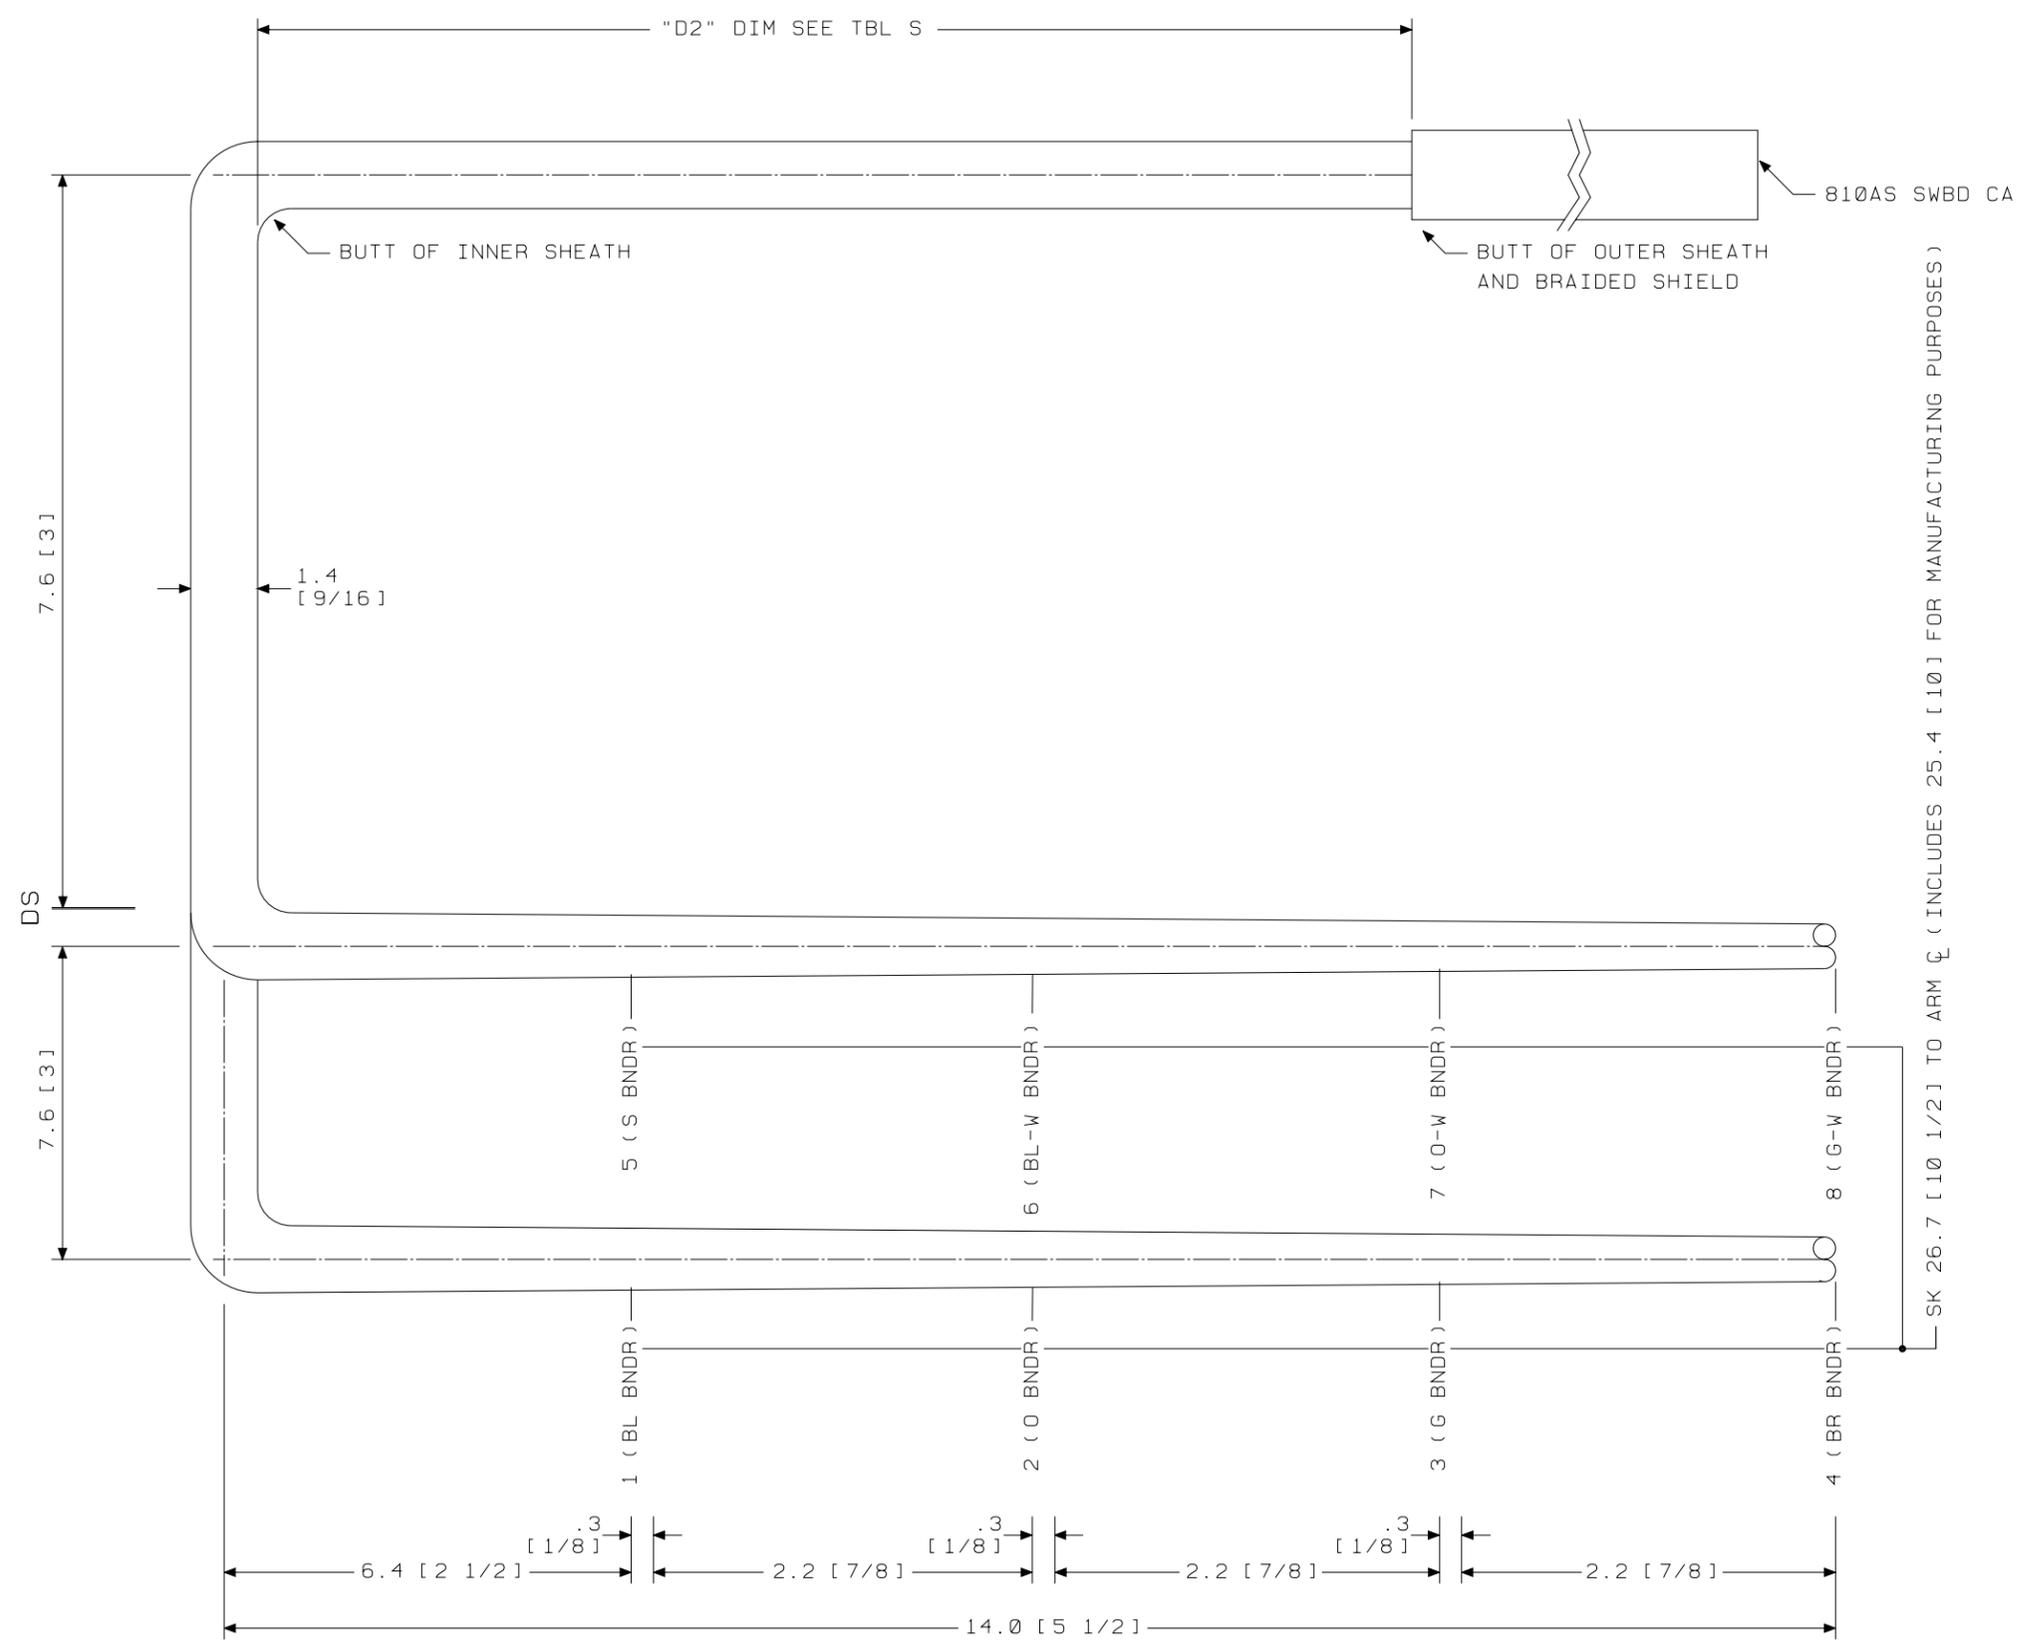


GROUP 534A
 CABLE FOR INTEGRATED SERVICES LINE UNIT (2-WIRE) PBX APPL ONLY
 LG 12-15
 END "A"

SEE PROPRIETARY NOTICE ON SHEET ONE		
CONNECTORIZED SWITCHBOARD CABLE ASSEMBLIES		DWG SIZE C2
LUCENT TECHNOLOGIES INC.		ISSUE 49 SHEET C44
ED5D621-35		

ED5D621-35

SK 26.7 [10 1/2] TO ARM ϕ (INCLUDES 25.4 [10] FOR MANUFACTURING PURPOSES)

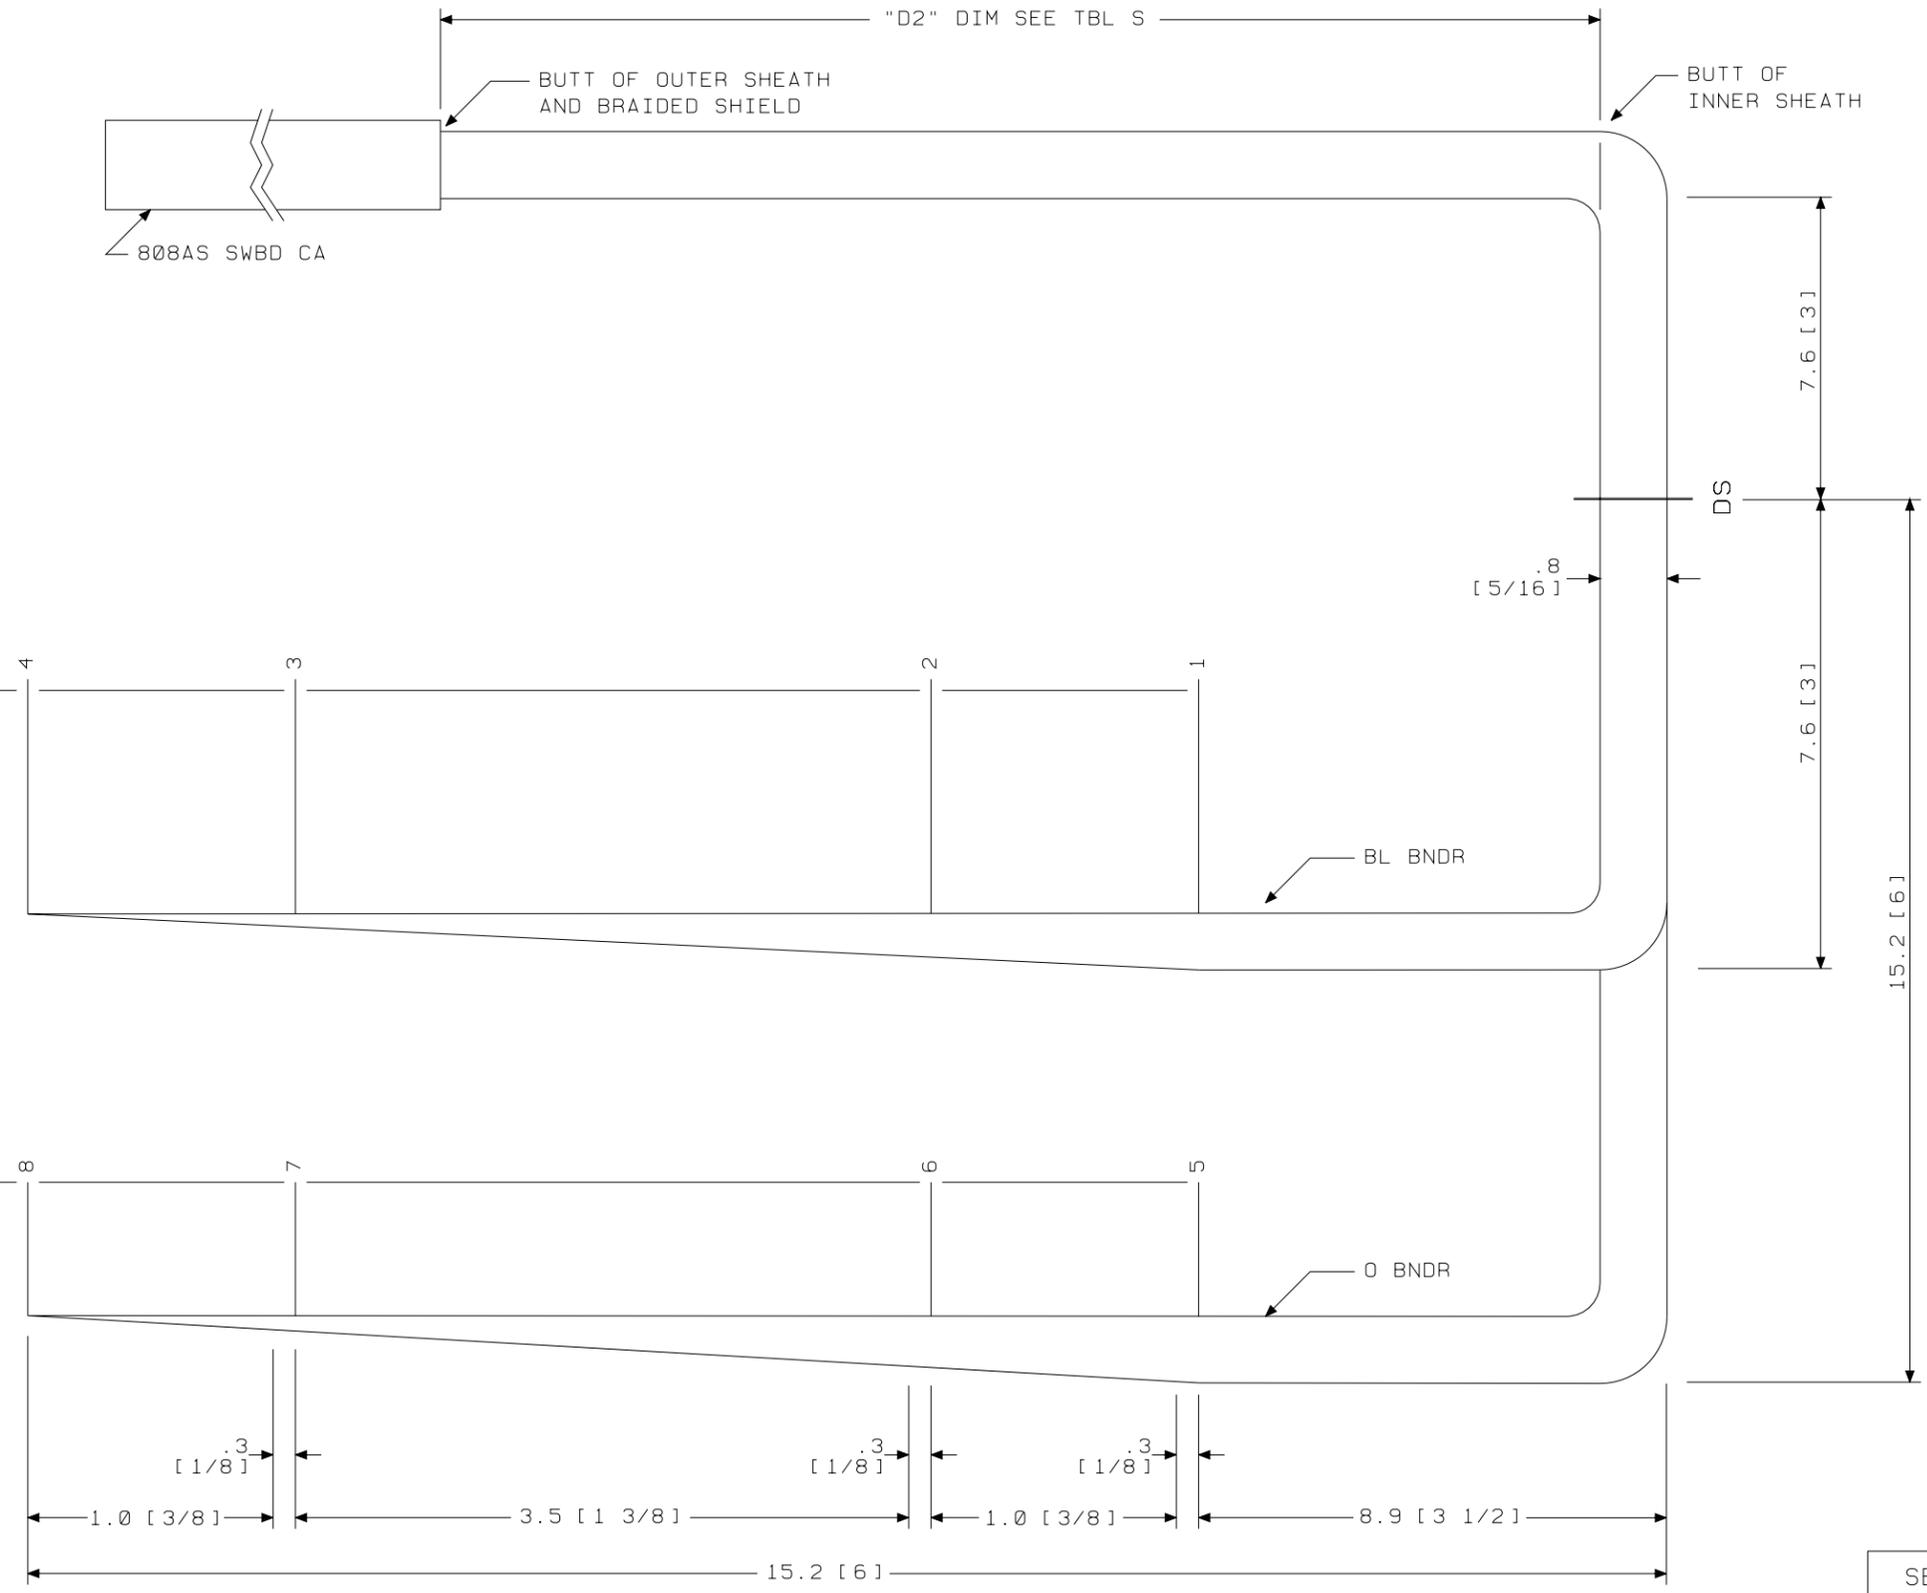


GROUP 541A
 CABLE FOR INTEGRATED SERVICES LINE UNIT (4-WIRE OSPS) PBX APPL ONLY
 LG 00-03
 END "A"

SEE PROPRIETARY NOTICE ON SHEET ONE		
CONNECTORIZED SWITCHBOARD CABLE ASSEMBLIES	DWG SIZE	ISSUE
	c2	49
LUCENT TECHNOLOGIES INC.	ED5D621-35	SHEET C45

ED5D621-35


SK 26.7 [10 1/2] TO ARM ϕ (INCLUDES 25.4 [10] FOR MANUFACTURING PURPOSES)

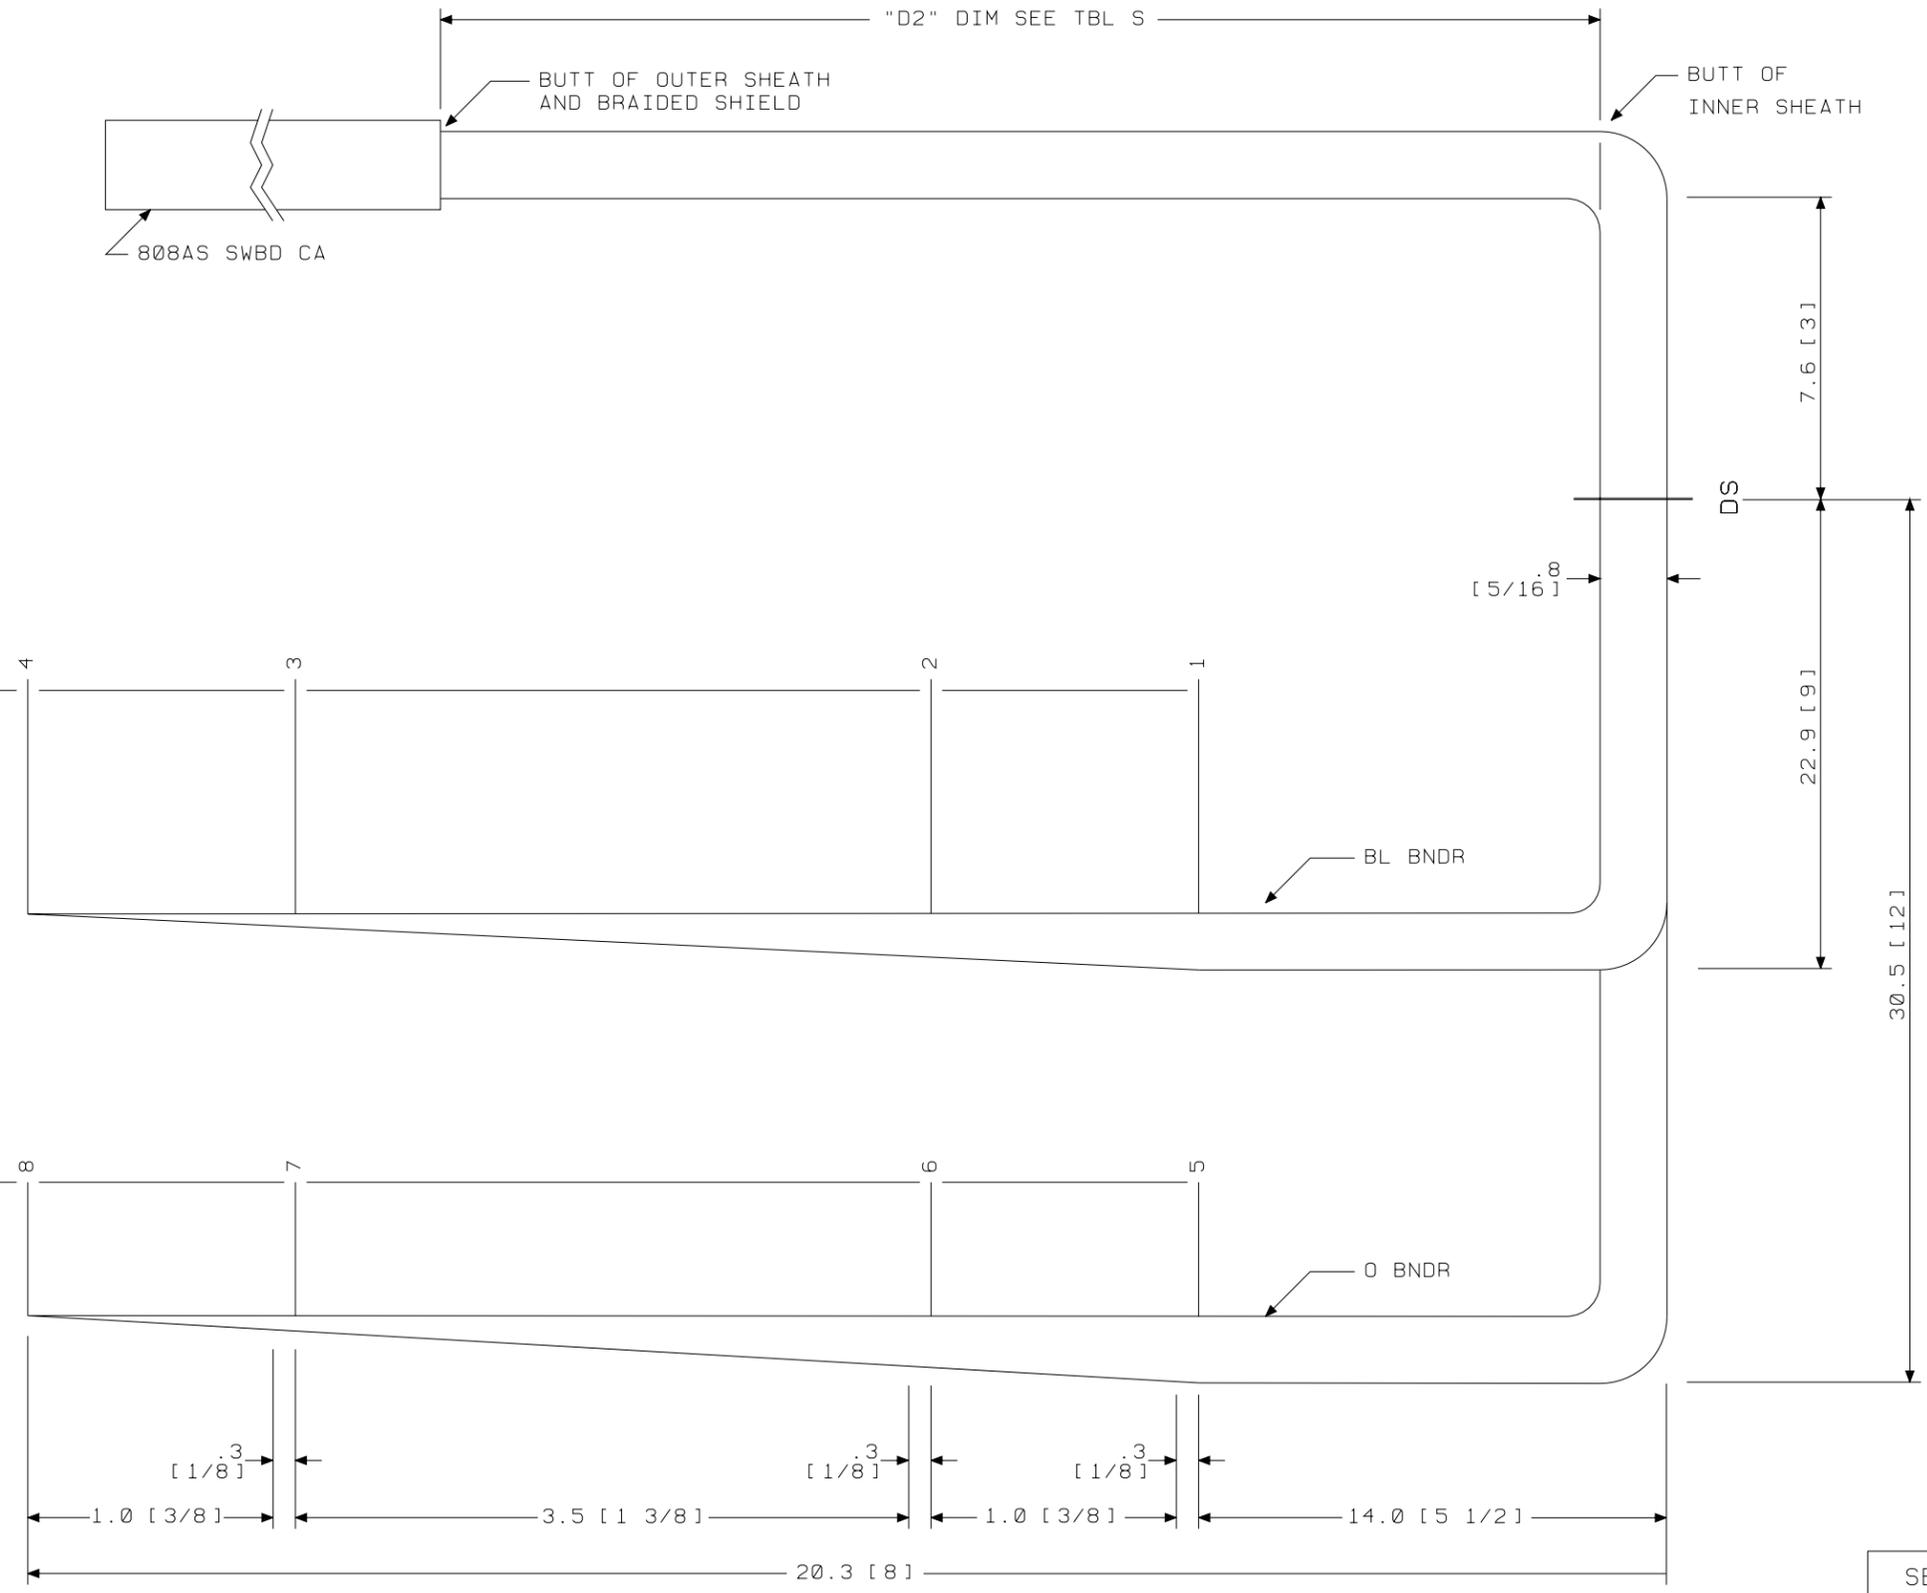

GROUP 543A
 CABLE FOR INTEGRATED SERVICES LINE UNIT (4-WIRE OSPS) PBX APPL ONLY
 LG 04-07
 END "A"

SEE PROPRIETARY NOTICE ON SHEET ONE		
CONNECTORIZED SWITCHBOARD CABLE ASSEMBLIES	DWG SIZE	ISSUE
	c2	49
LUCENT TECHNOLOGIES INC.	ED5D621-35	SHEET C46


ED5D621-35

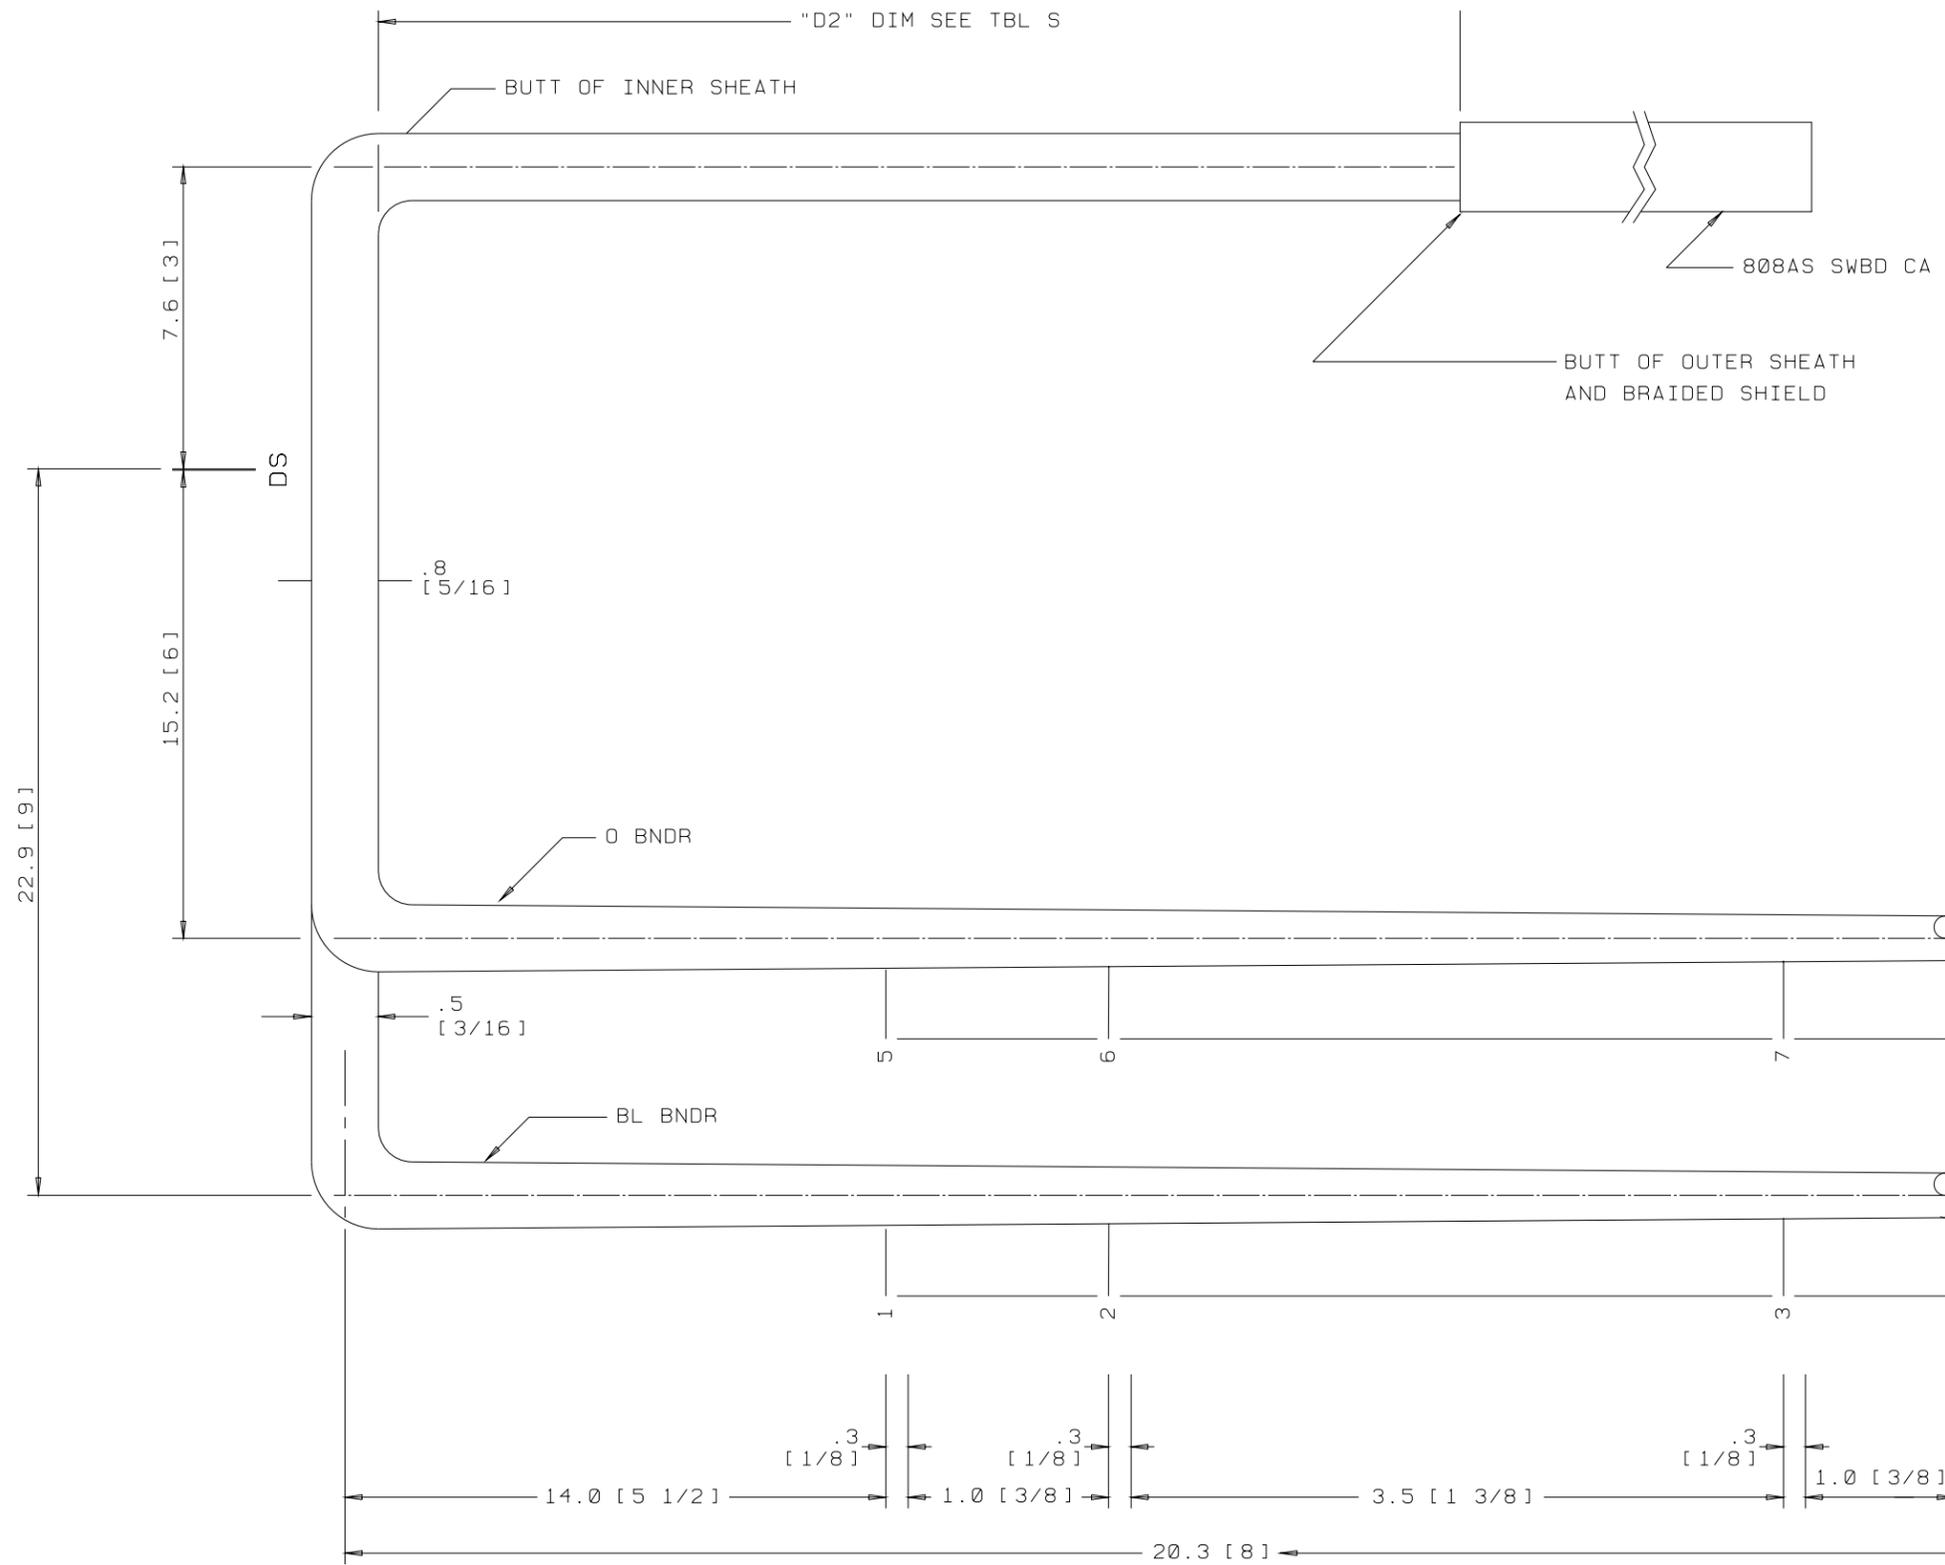

GROUP 542A
 CABLE FOR INTEGRATED SERVICES LINE UNIT (4-WIRE OSPS) PBX APPL ONLY
 LG 08-11
 END "A"

SEE PROPRIETARY NOTICE ON SHEET ONE		
CONNECTORIZED SWITCHBOARD CABLE ASSEMBLIES	DWG SIZE	ISSUE
	c2	49
LUCENT TECHNOLOGIES INC.	ED5D621-35	SHEET C47

ED5D621-35

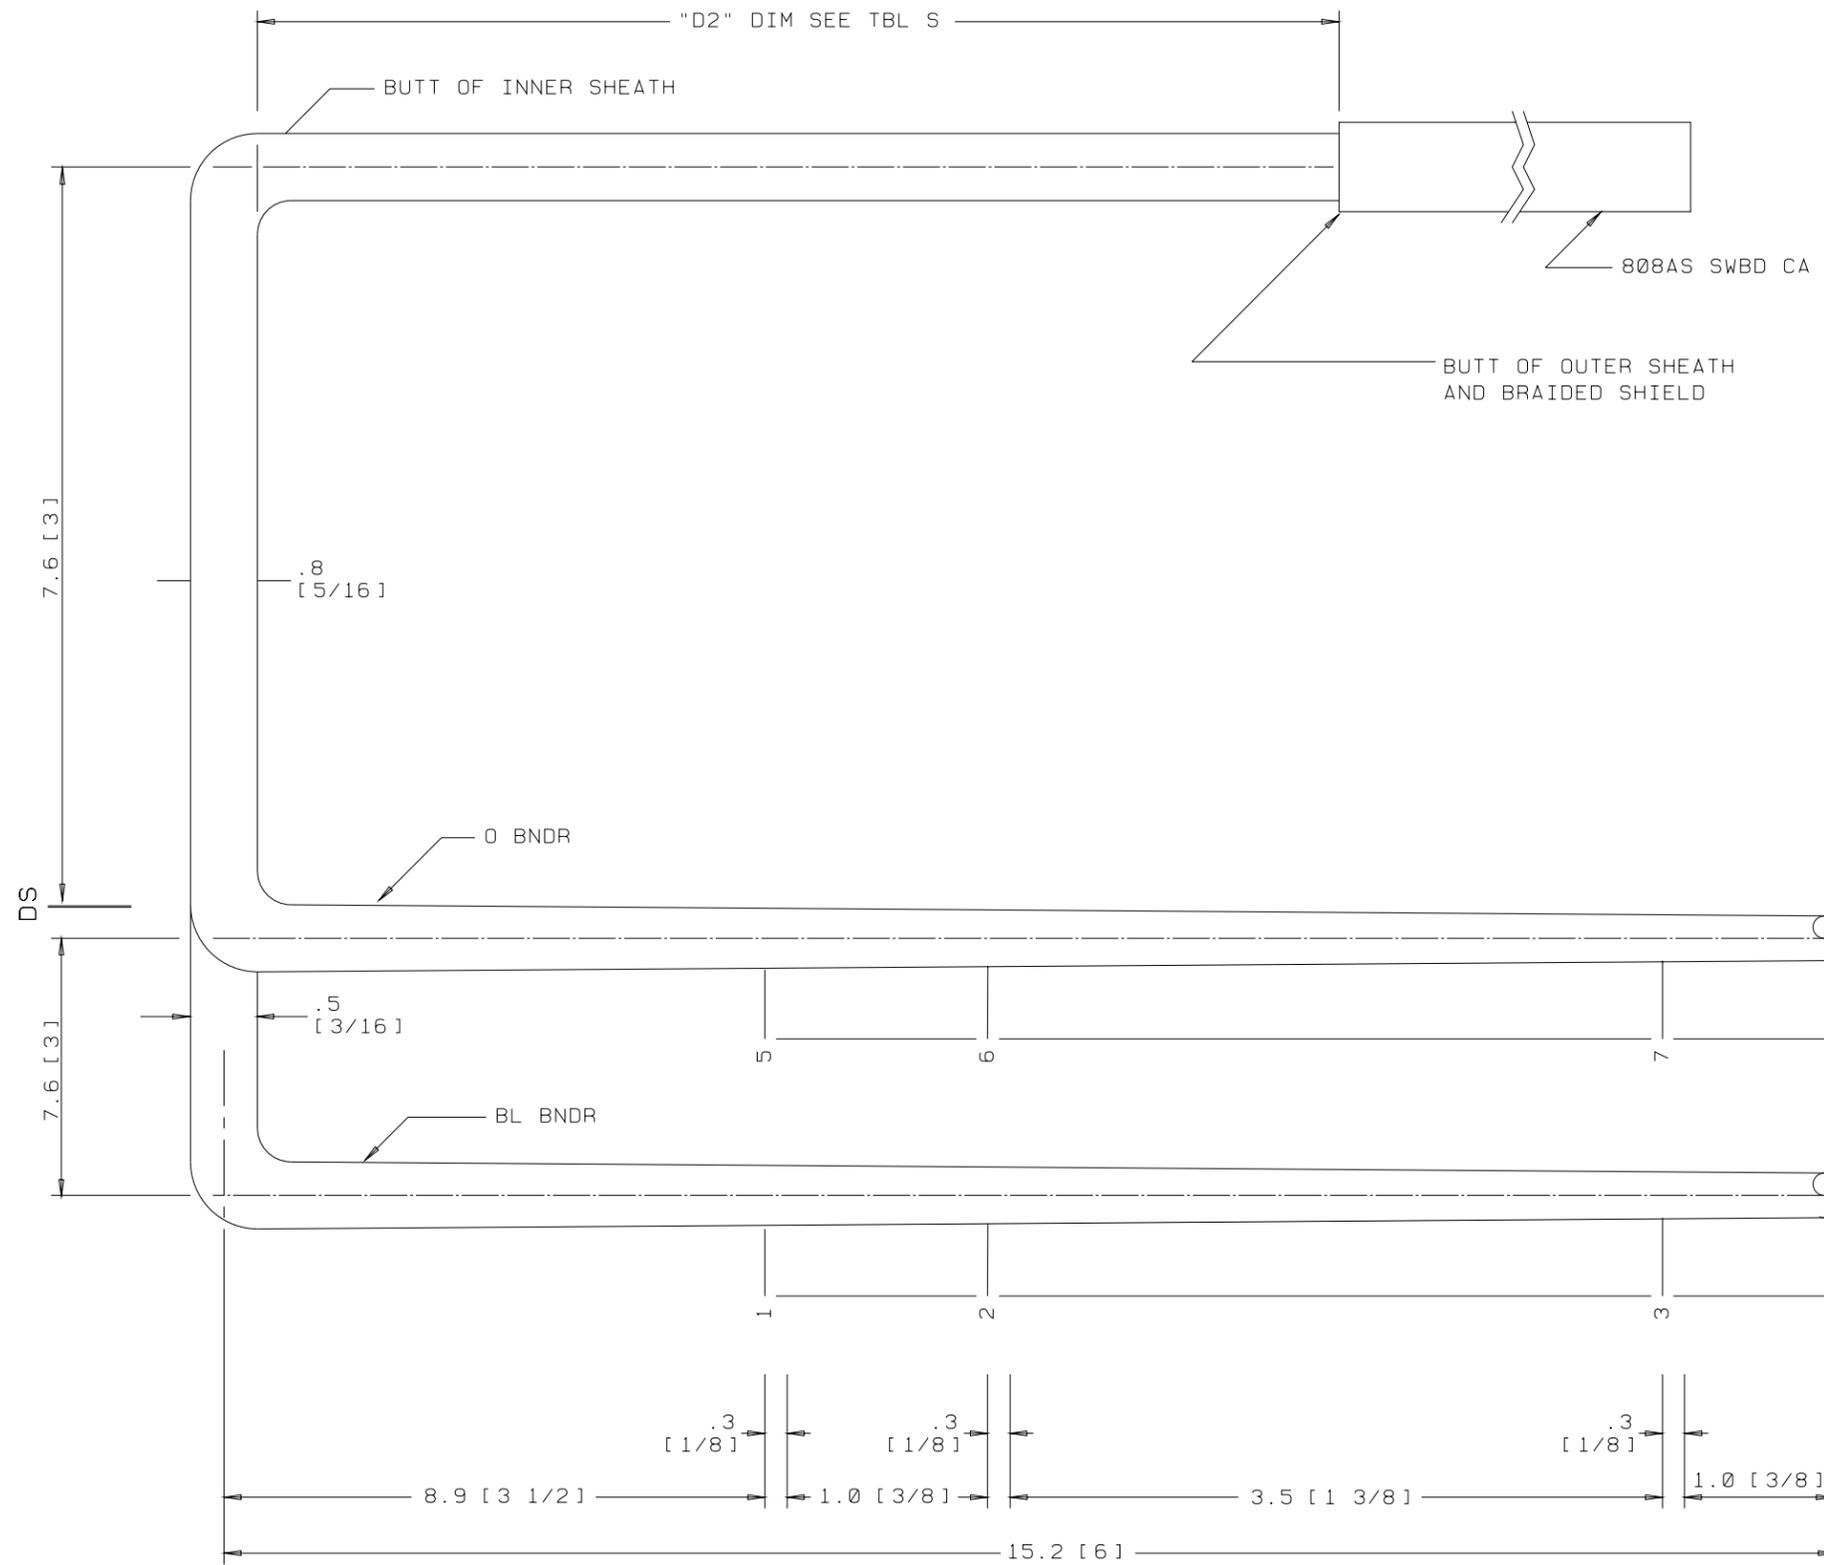


SEE PROPRIETARY NOTICE ON SHEET ONE

CONNECTORIZED SWITCHBOARD CABLE ASSEMBLIES		DWG SIZE c2	ISSUE 49
LUCENT TECHNOLOGIES INC.	ED5D621-35	SHEET c48	

GROUP 544A
 CABLE FOR INTEGRATED SERVICES LINE UNIT (4-WIRE OSPS) PBX APPL ONLY
 LG 12-15
 END "A"

ED5D621-35

SK 26.7 [10 1/2] TO ARM C (INCLUDES 25.4 [10] FOR MANUFACTURING PURPOSES)

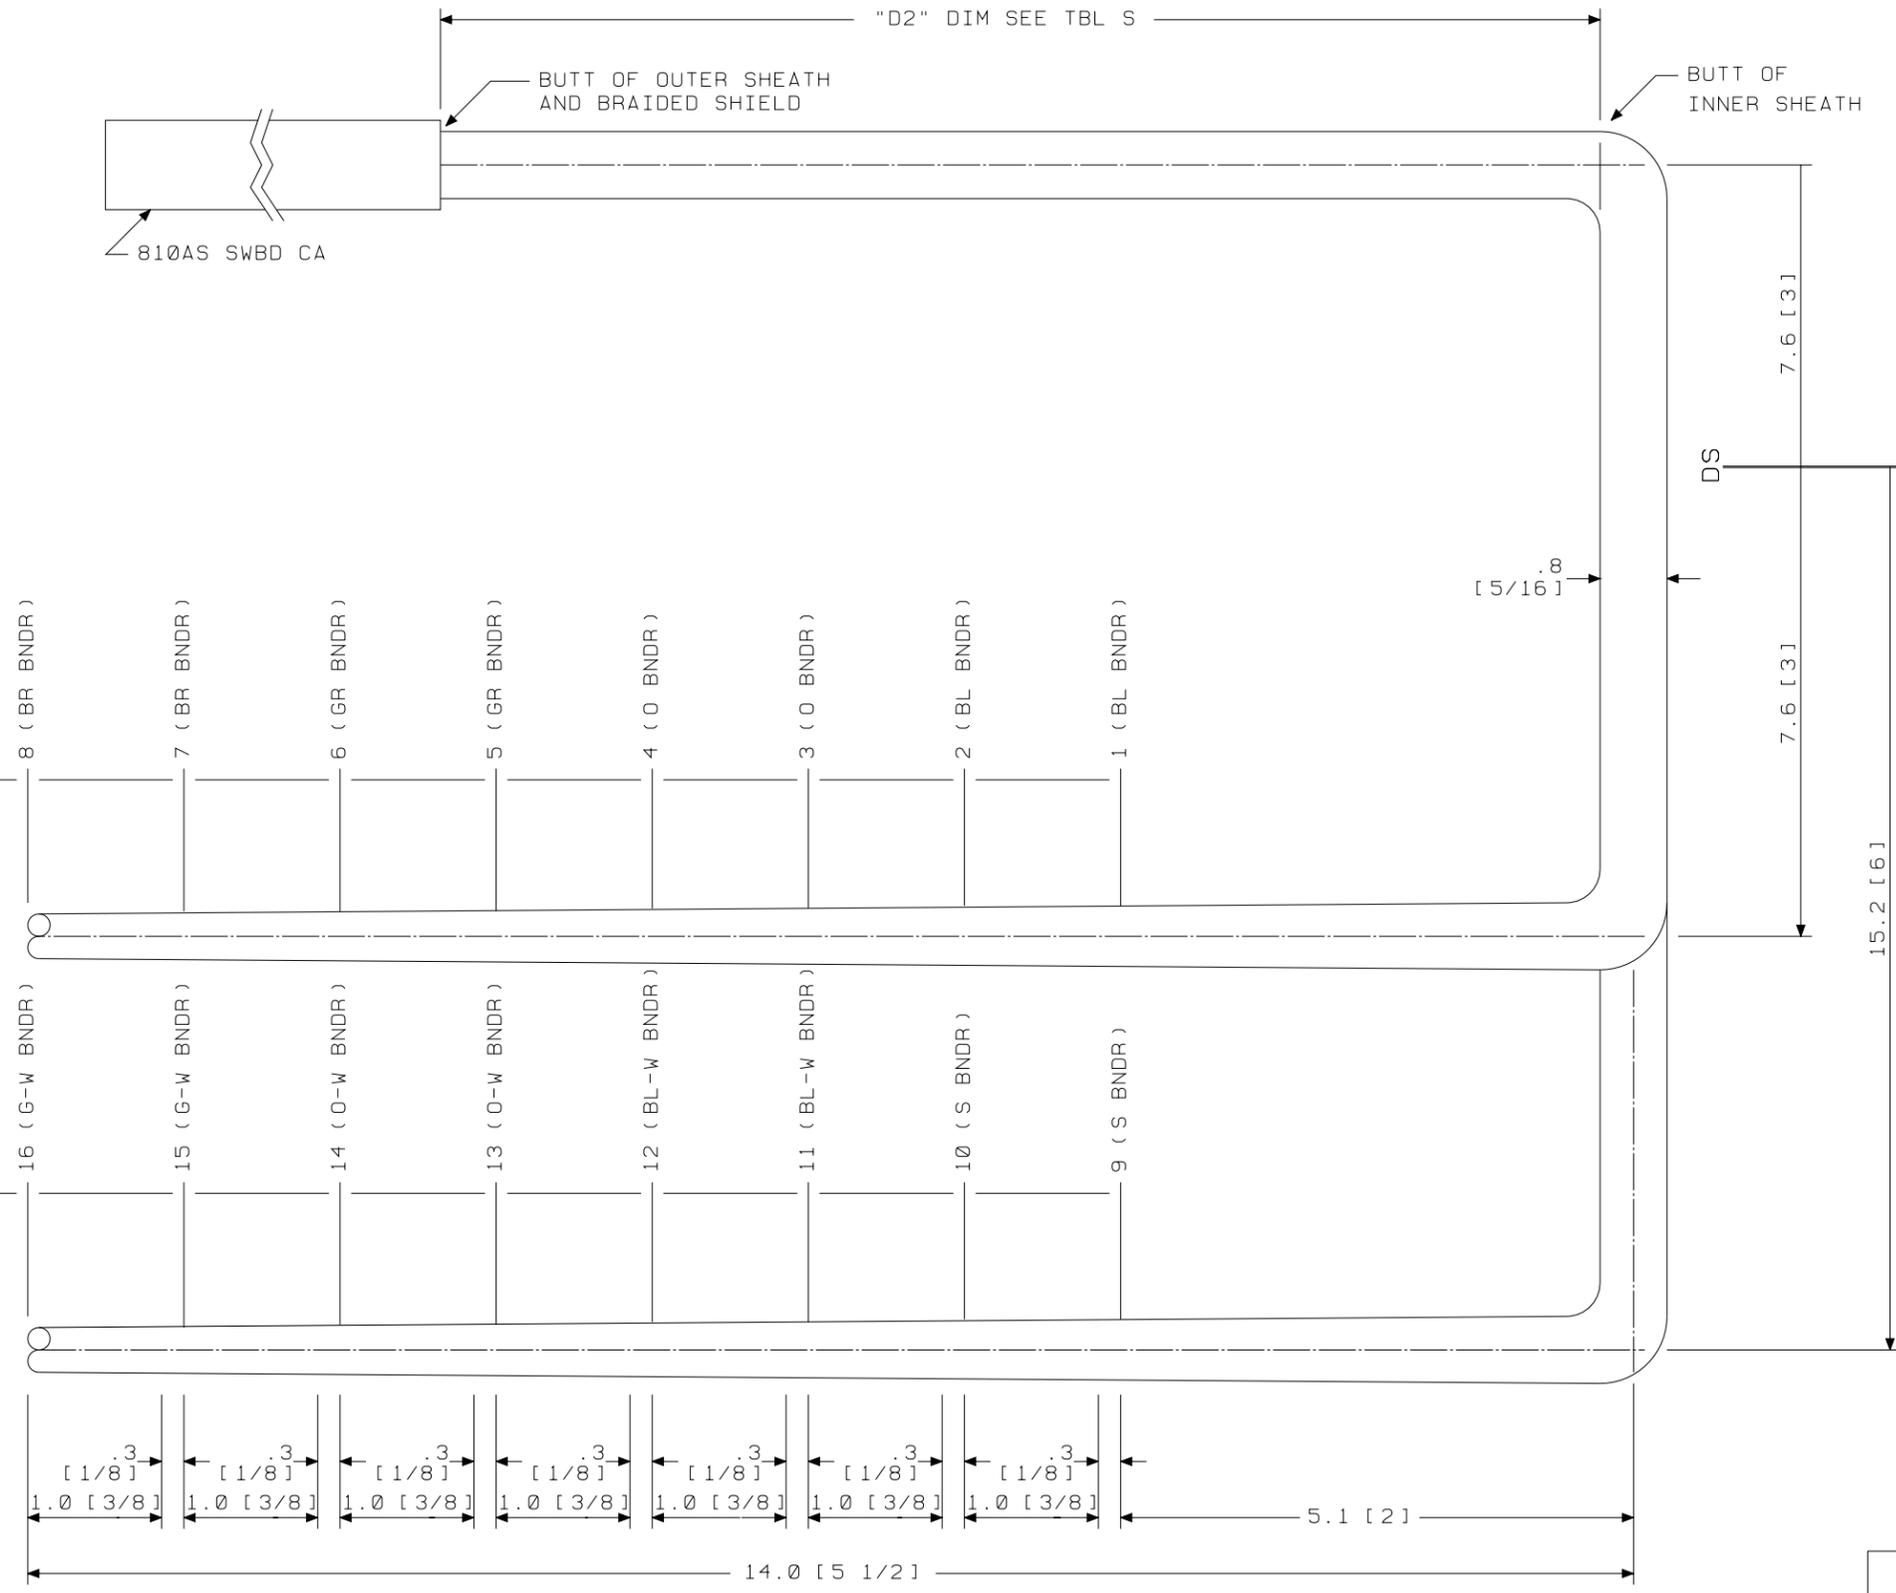


GROUP 545A
 CABLE FOR INTEGRATED SERVICES LINE UNIT (4-WIRE OSPS) PBX APPL ONLY
 LG 00-03
 END "A"

SEE PROPRIETARY NOTICE ON SHEET ONE		
CONNECTORIZED SWITCHBOARD CABLE ASSEMBLIES	DWG SIZE	ISSUE
	c2	49
LUCENT TECHNOLOGIES INC.	ED5D621-35	SHEET C49

ED5D621-35


SK 26.7 [10 1/2] TO ARM ϕ (INCLUDES 25.4 [10] FOR MANUFACTURING PURPOSES)

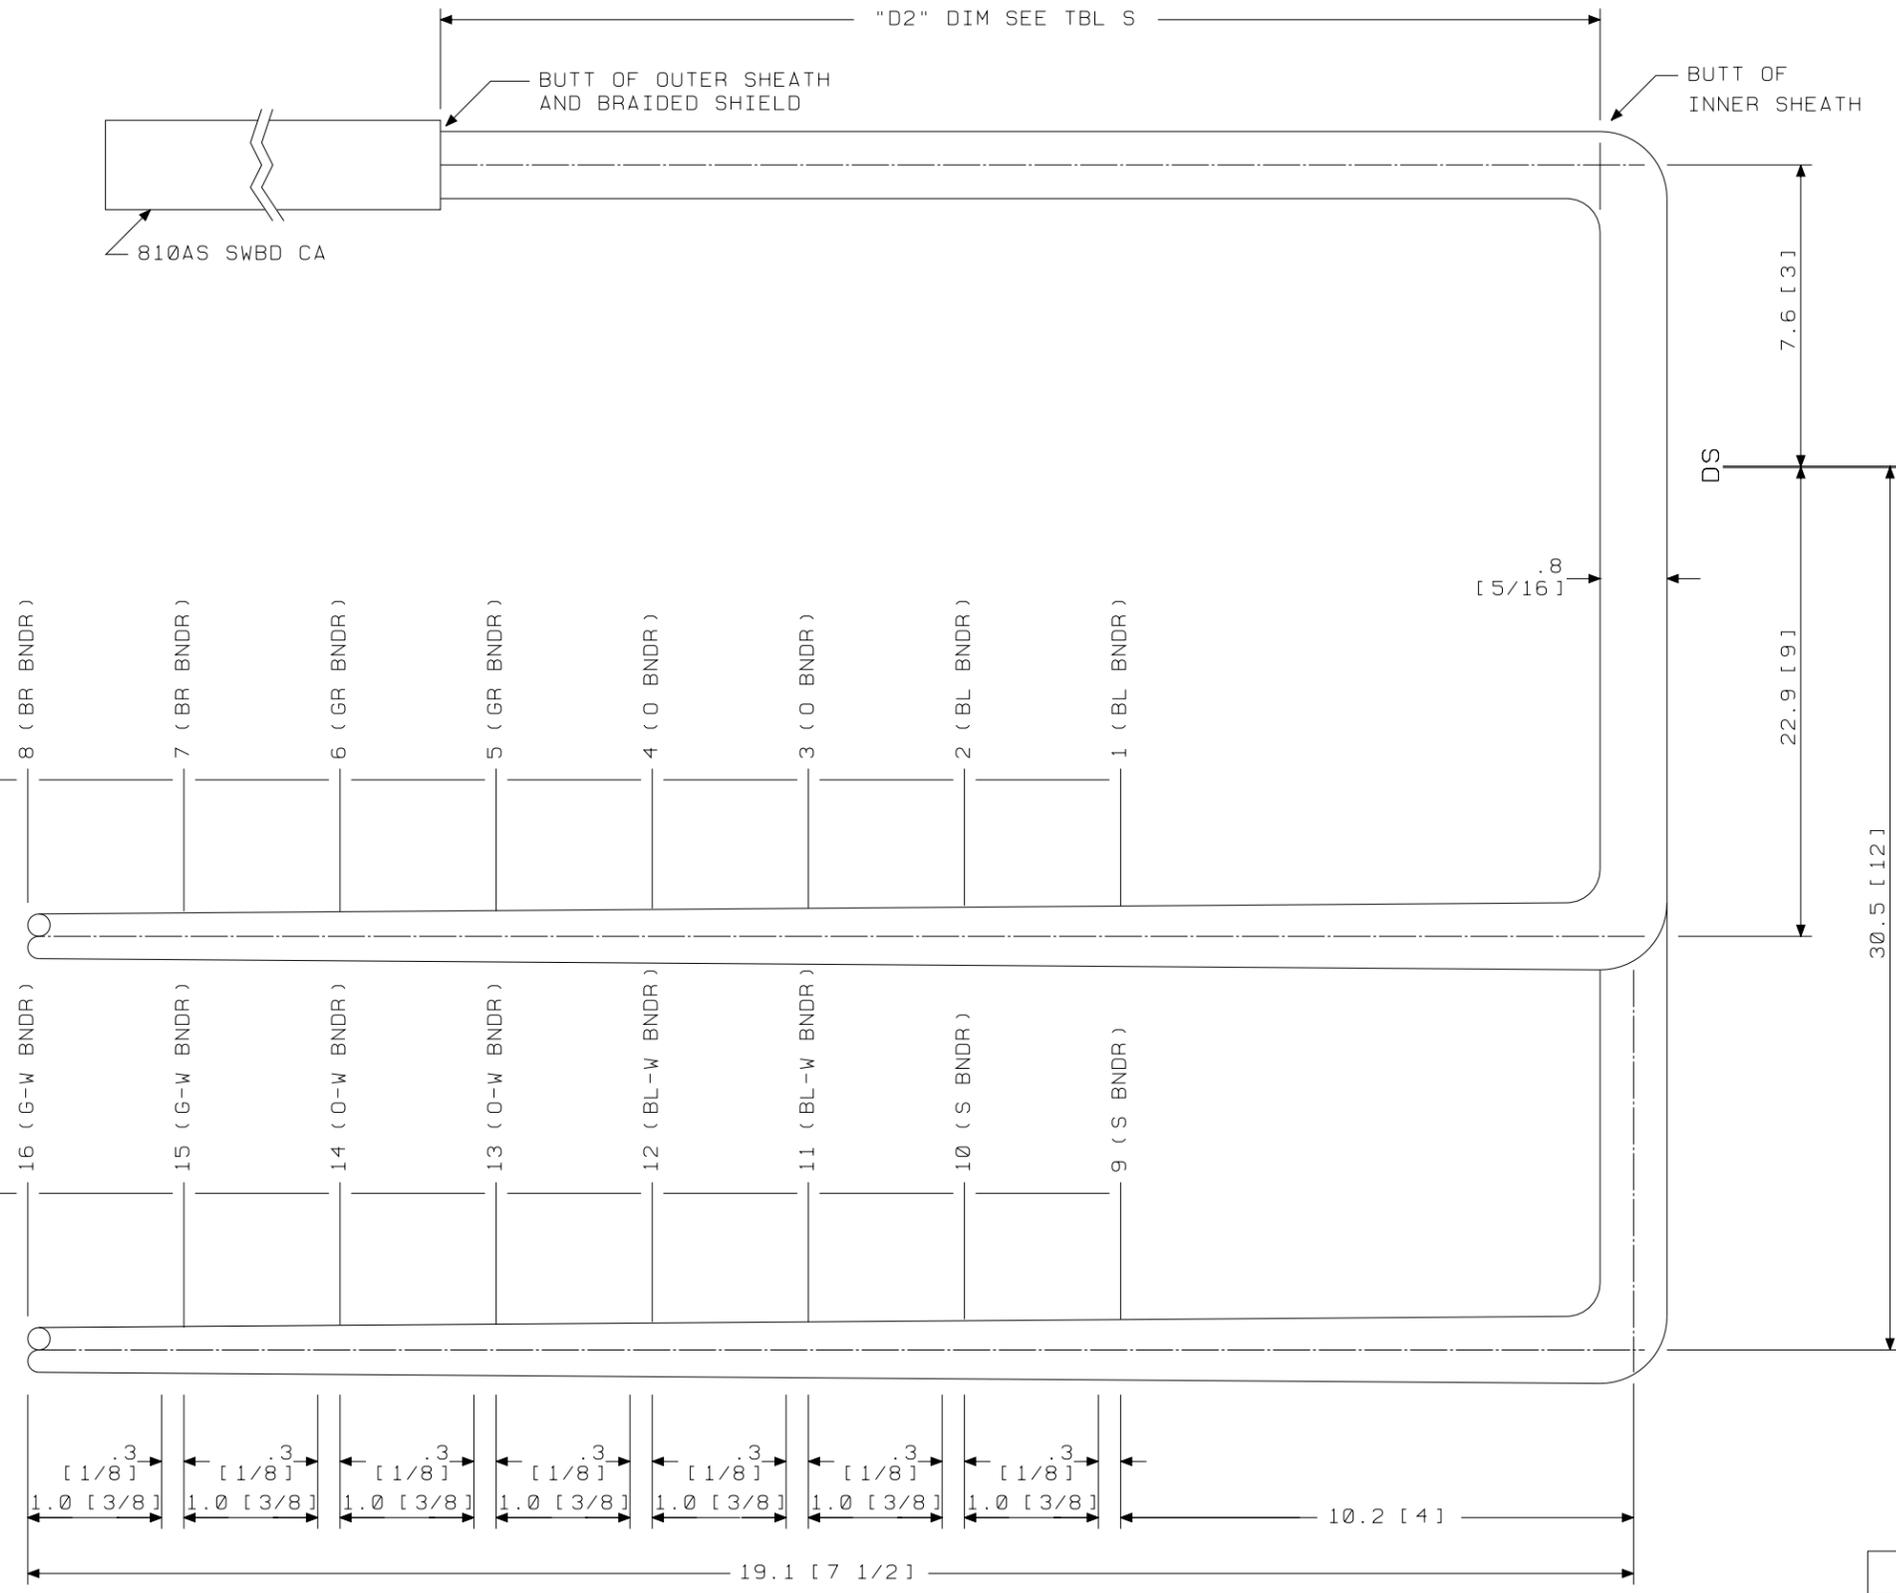

GROUP 547A
 CABLE FOR INTEGRATED SERVICES LINE UNIT (4-WIRE OSPS) PBX APPL ONLY
 LG 04-07
 END "A"

SEE PROPRIETARY NOTICE ON SHEET ONE		
CONNECTORIZED SWITCHBOARD CABLE ASSEMBLIES		
DWG SIZE c2	ISSUE 49	
LUCENT TECHNOLOGIES INC.	ED5D621-35	SHEET c50


ED5D621-35

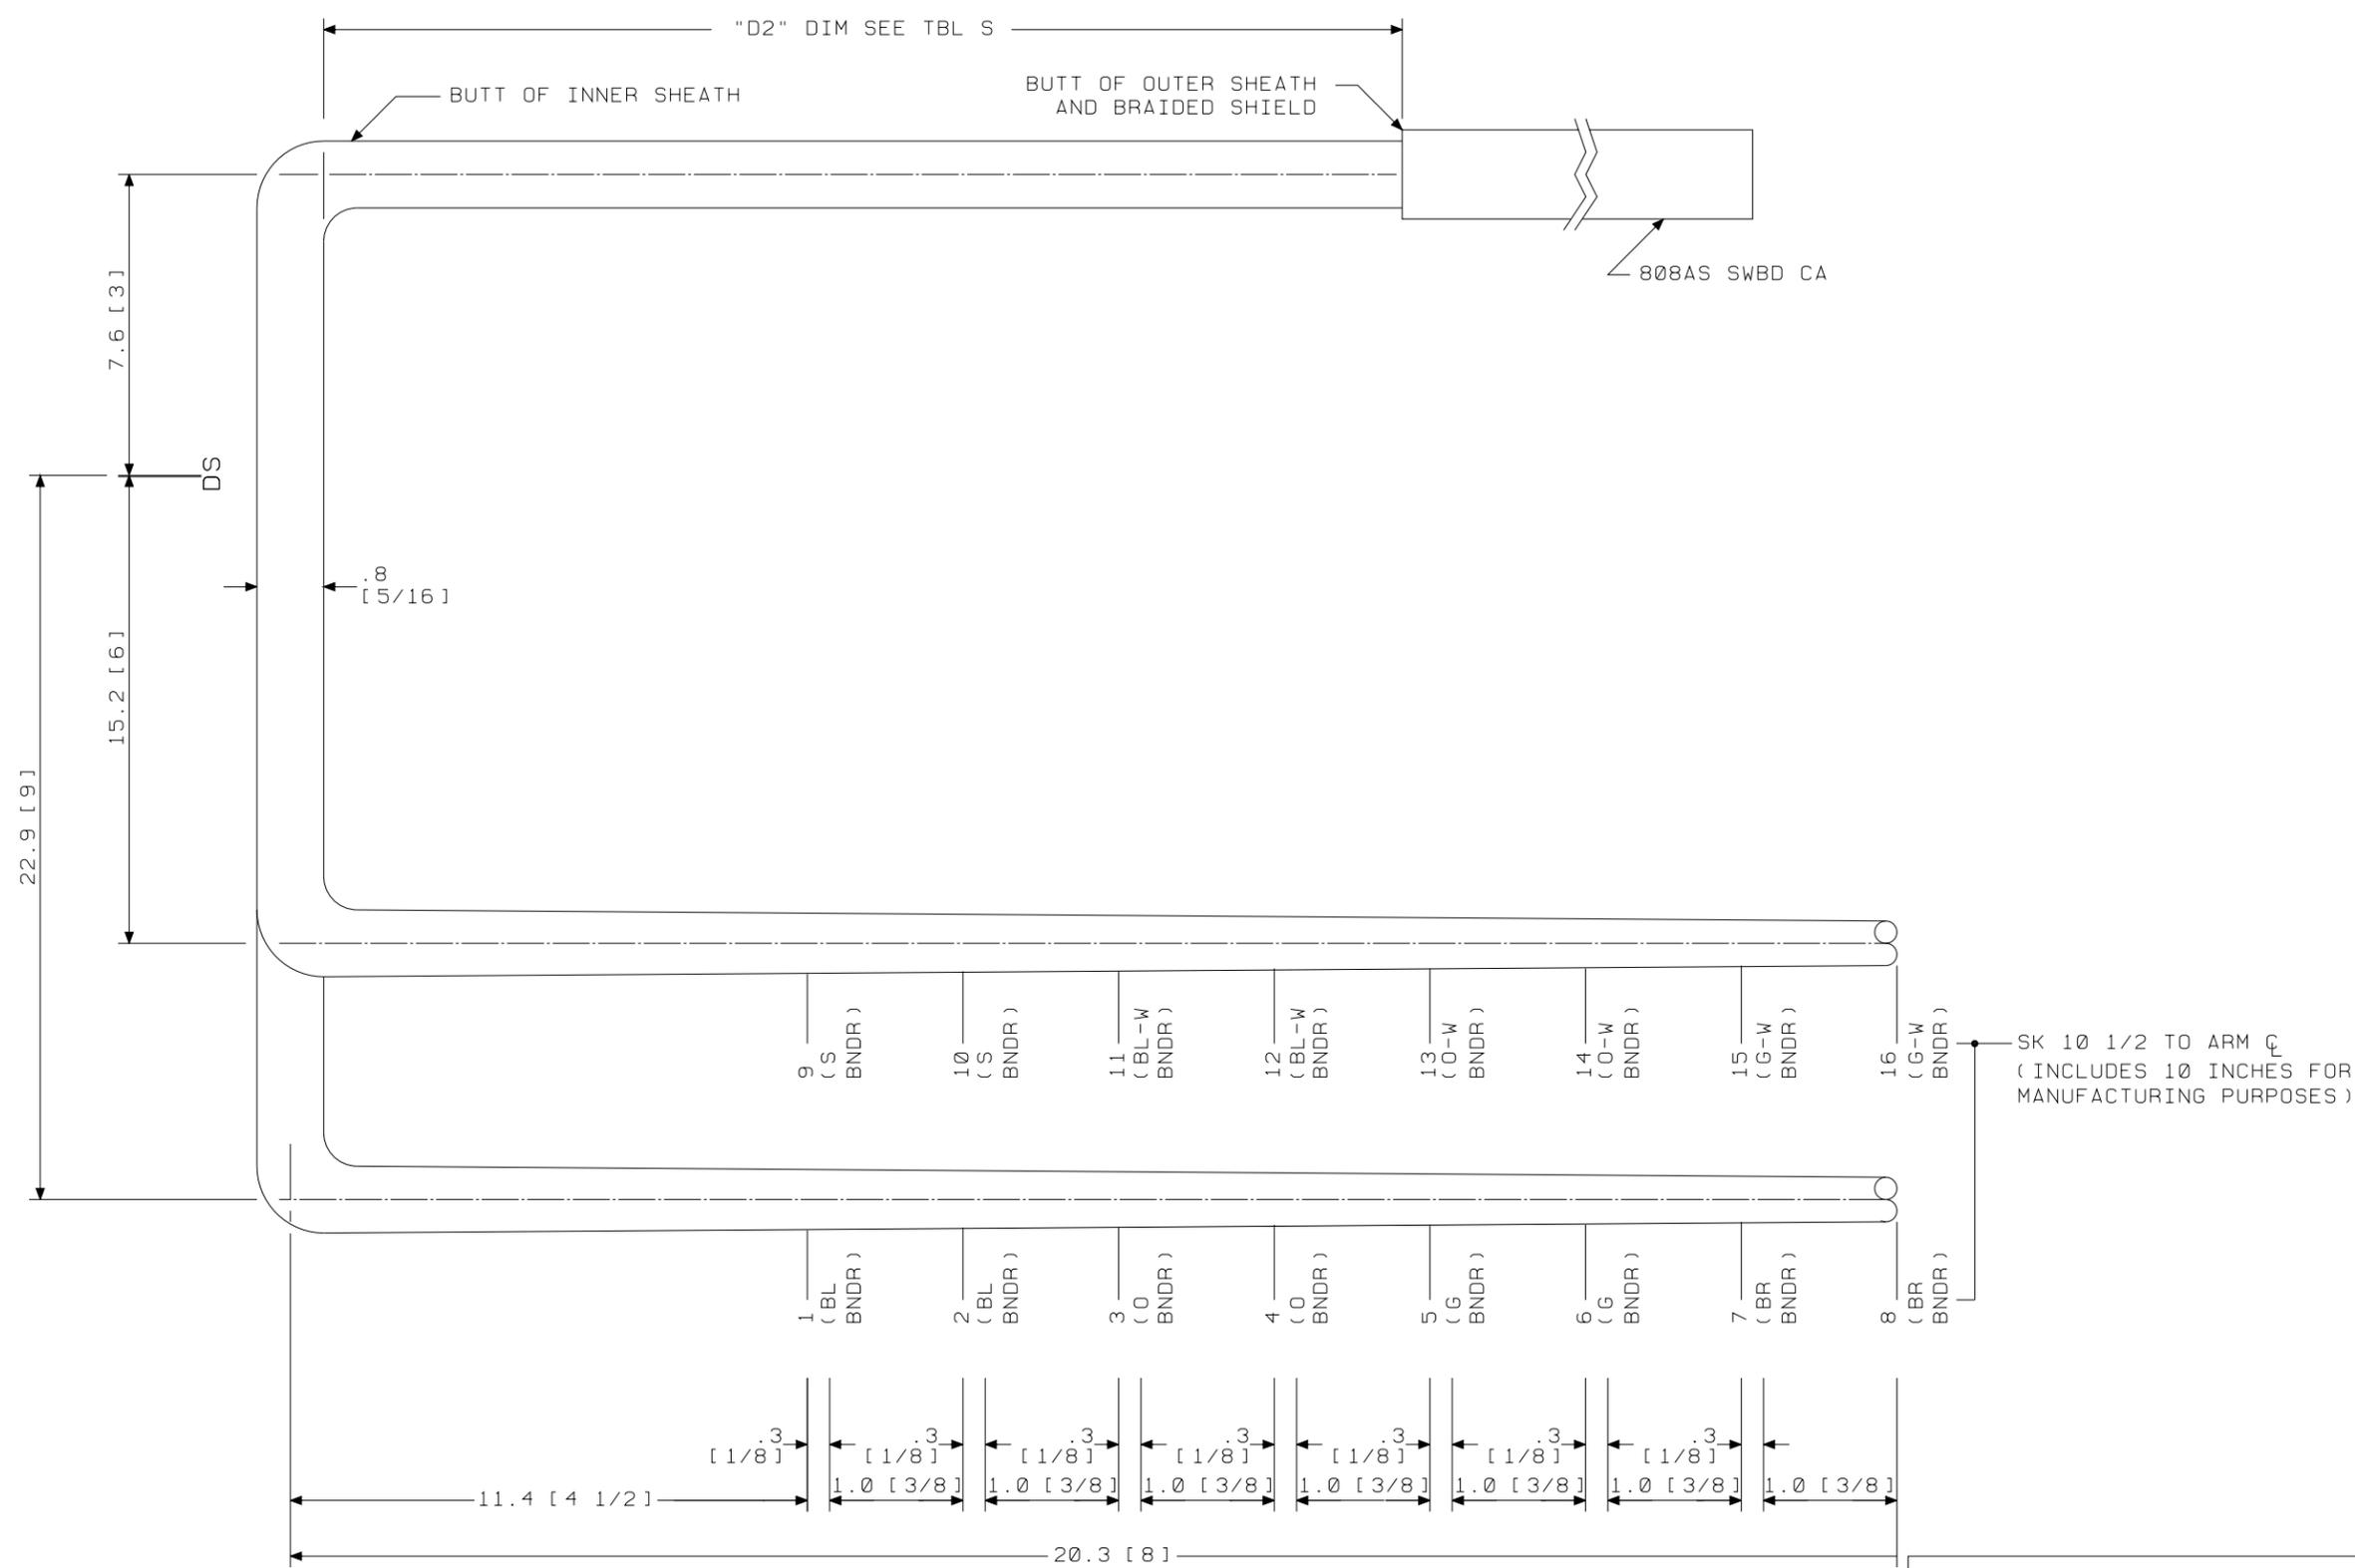

GROUP 546A
 CABLE FOR INTEGRATED SERVICES LINE UNIT (4-WIRE OSPS) PBX APPL ONLY
 LG 08-11
 END "A"



SEE PROPRIETARY NOTICE ON SHEET ONE		
CONNECTORIZED SWITCHBOARD CABLE ASSEMBLIES		DWG SIZE c2
LUCENT TECHNOLOGIES INC.		ISSUE 49
ED5D621-35		SHEET c51

ED5D621-35

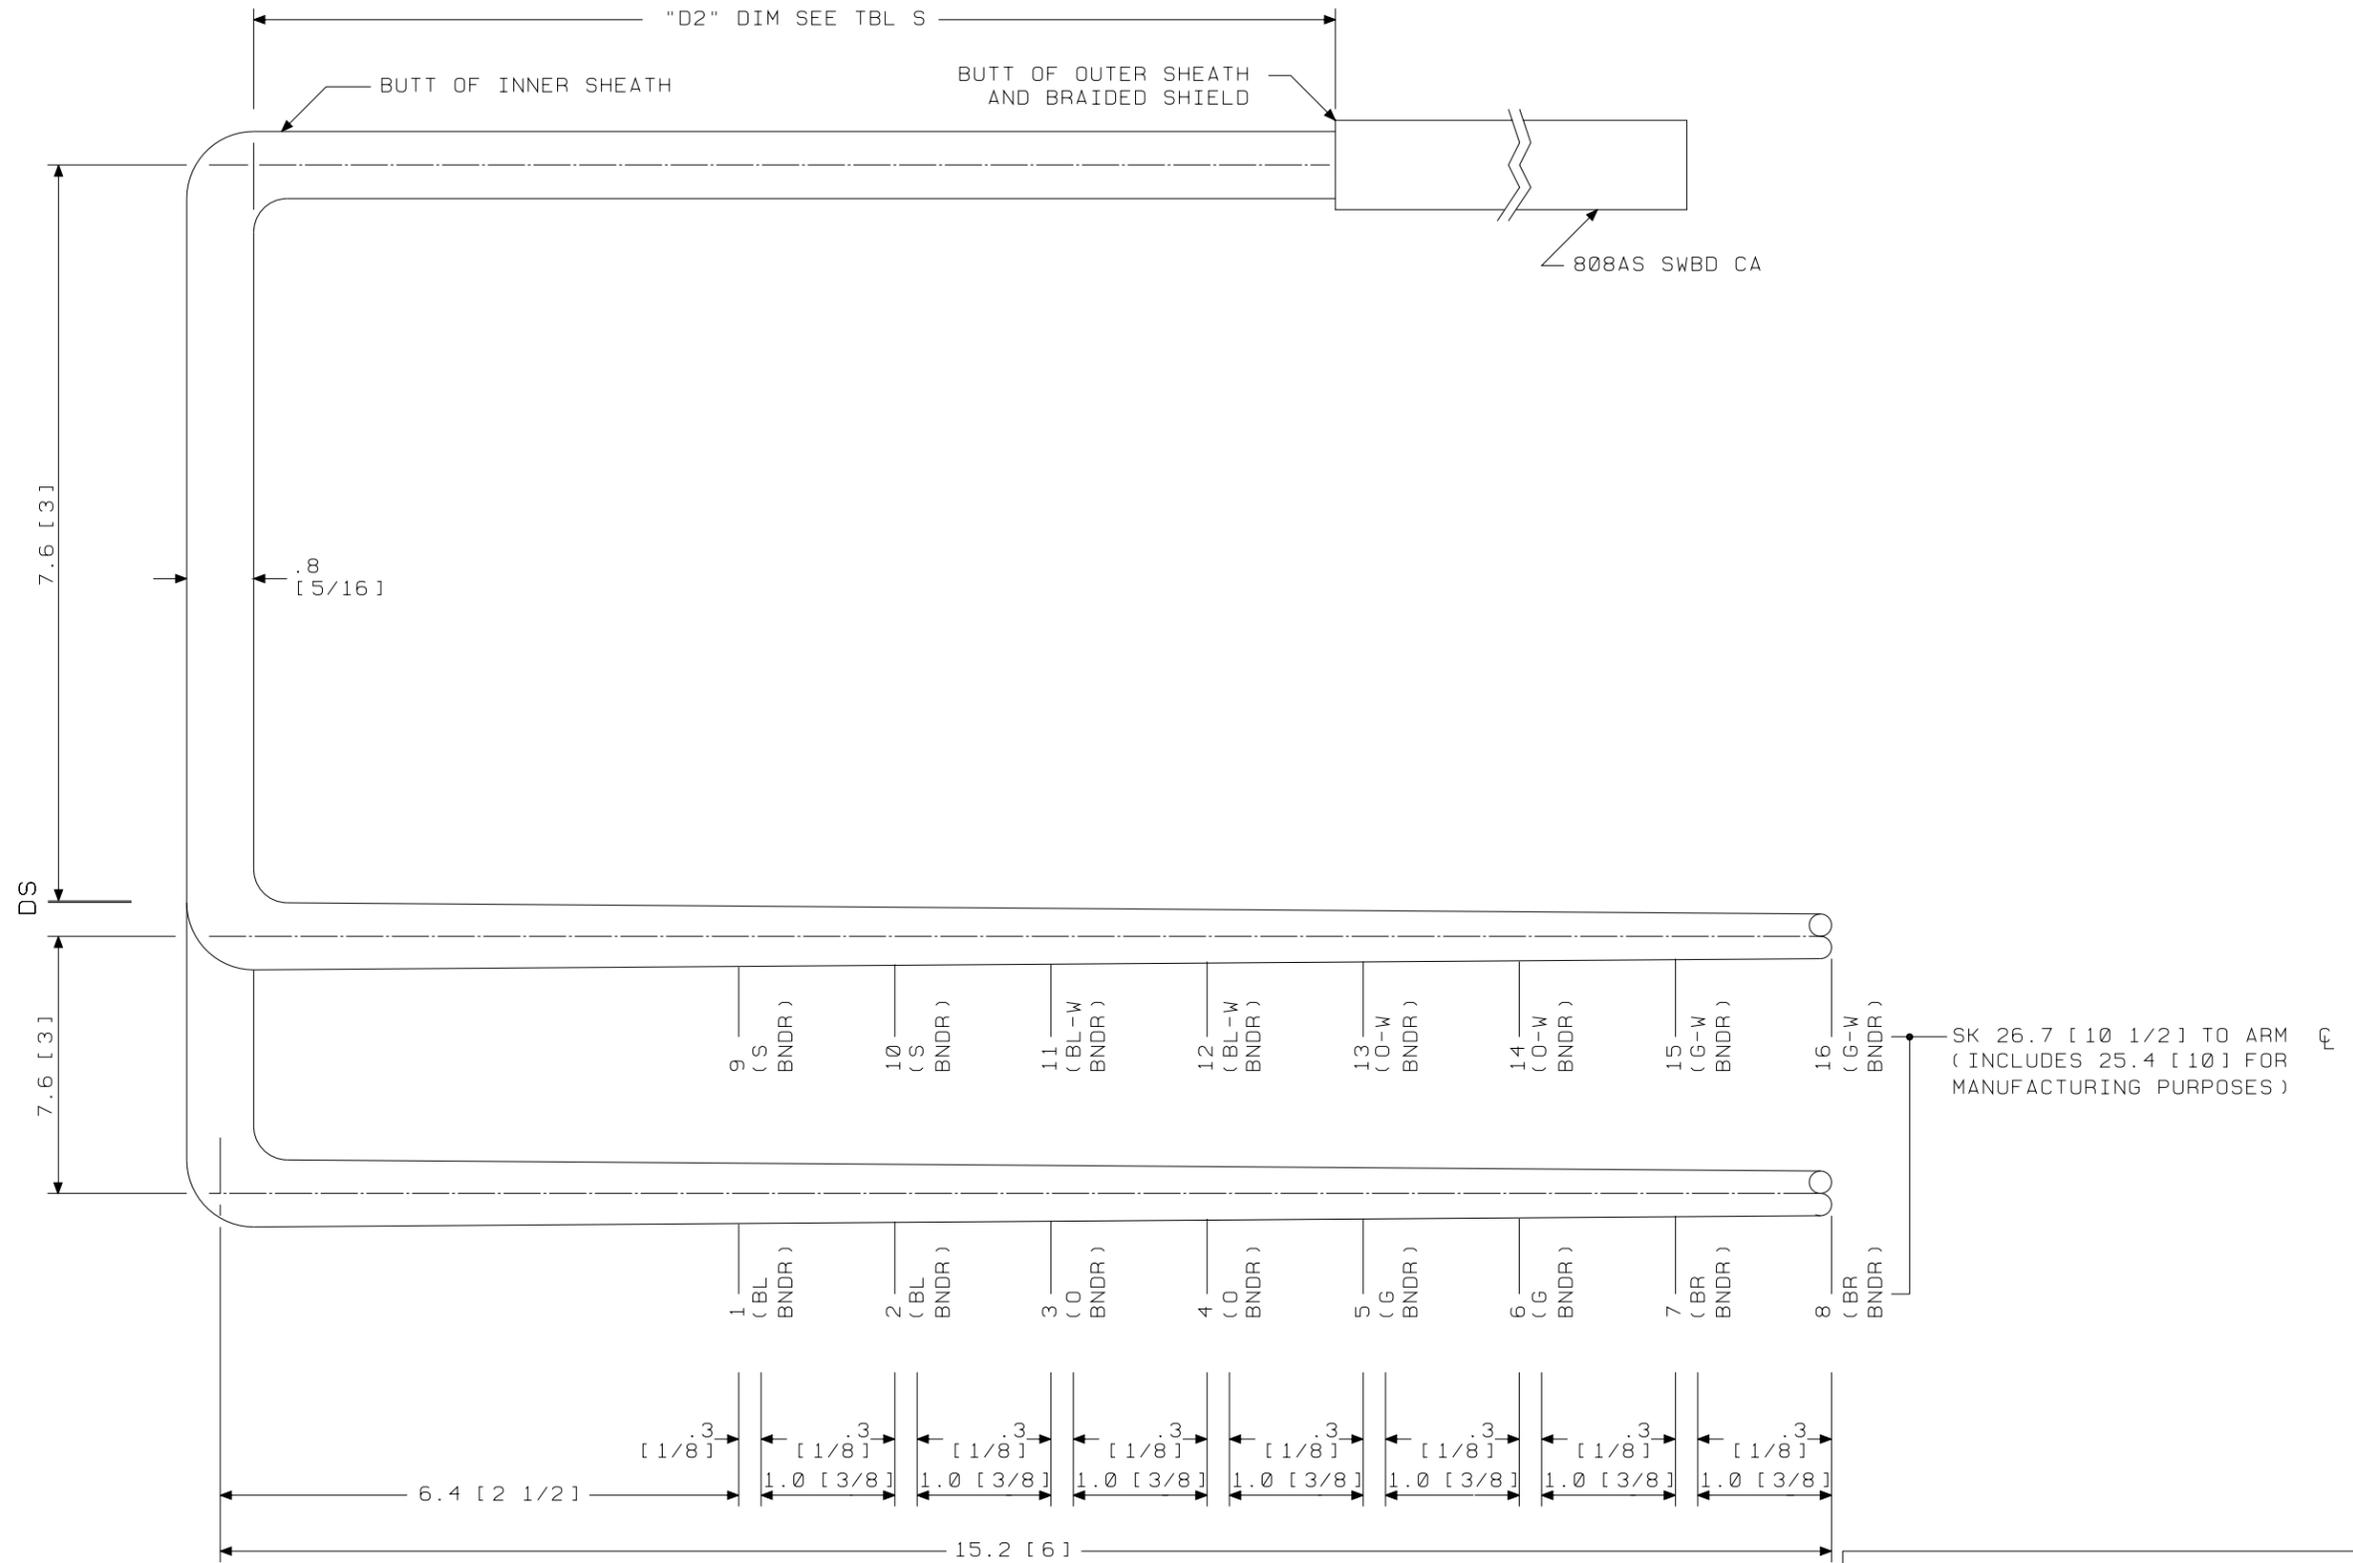

GROUP 548A
 CABLE FOR INTEGRATED SERVICES LINE UNIT (4-WIRE OSPS) PBX APPL ONLY
 LG 12-15
 END "A"

SEE PROPRIETARY NOTICE ON SHEET ONE		
CONNECTORIZED SWITCHBOARD CABLE ASSEMBLIES	DWG SIZE	ISSUE
	c2	49
LUCENT TECHNOLOGIES INC.	ED5D621-35	SHEET c52

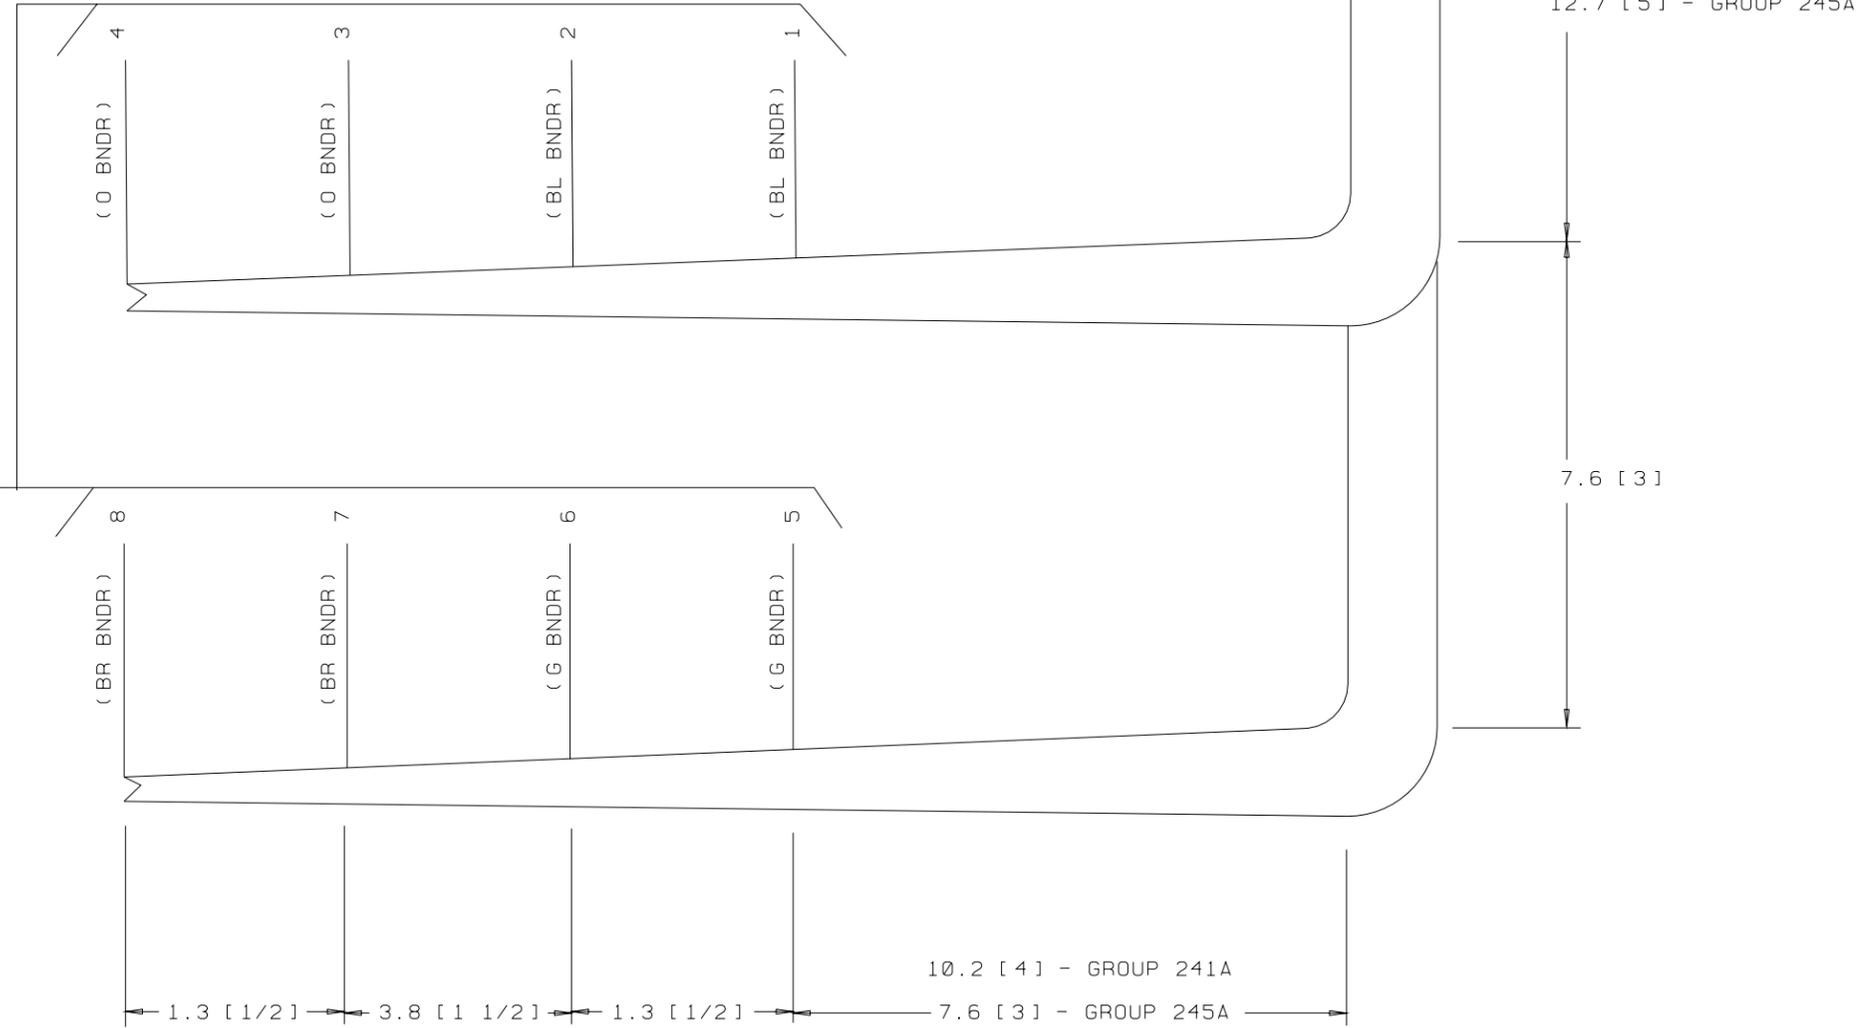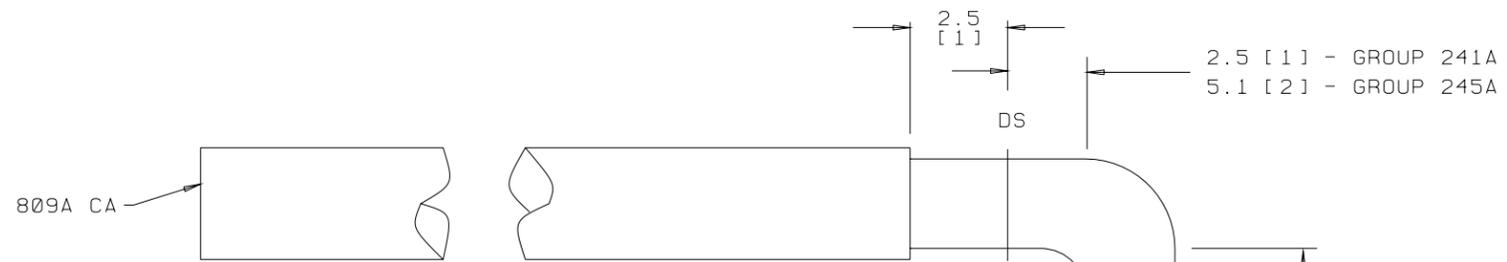

SK 26.7 [10 1/2] FOR GROUP 241A
 SK 27.9 [11] FOR GROUP 245A
 (INCLUDES 25.4 [10] FOR MANUF PURPOSES)

GROUP 241A, 245A
 CABLE FOR INTEGRATED SERVICES LINE UNIT (4-WIRE OSPS)
 LG 00-03
 END "A"

SEE PROPRIETARY NOTICE ON SHEET ONE		
CONNECTORIZED SWITCHBOARD CABLE ASSEMBLIES	DWG SIZE	ISSUE
	c2	49
LUCENT TECHNOLOGIES INC.	ED5D621-35	SHEET C54

ED5D621-35

809A CA

2.5
[1]

3.8 [1 1/2] - GROUP 243A
6.4 [2 1/2] - GROUP 247A

DS


1.0
[3/8]

26.7 [10 1/2] - GROUP 243A
27.9 [11] - GROUP 247A

7.6 [3]

10.2 [4] - GROUP 241A

1.3 [1/2] 3.8 [1 1/2] 1.3 [1/2] 7.6 [3] - GROUP 245A

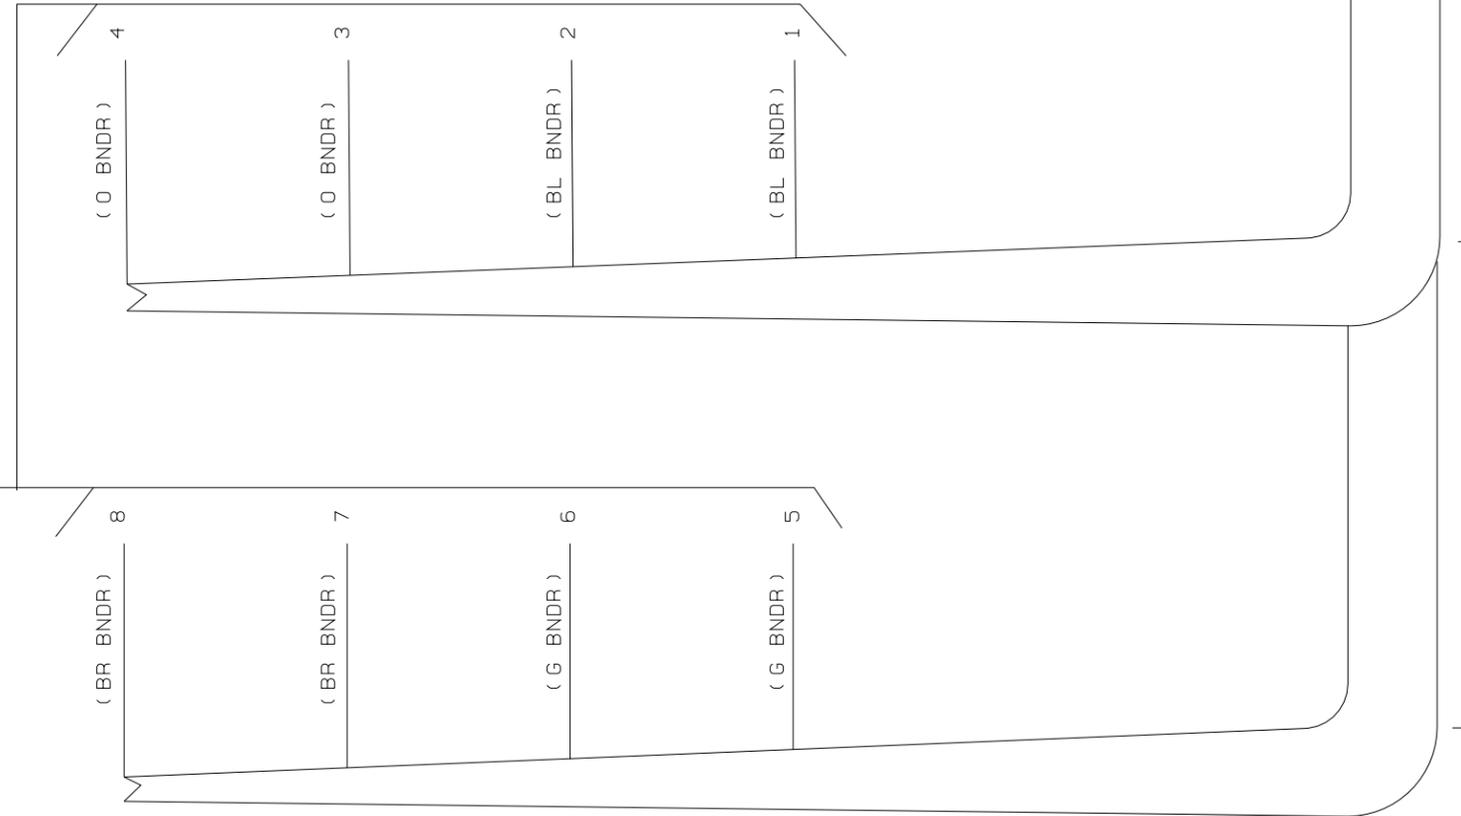

SK 26.7 [10 1/2] FOR GROUP 243A
SK 27.9 [11] FOR GROUP 247A
(INCLUDES 25.4 [10] FOR MANUF PURPOSES)

GROUP 243A, 247A
CABLE FOR INTEGRATED SERVICES LINE UNIT (4-WIRE OSPS)
LG 04-07
END "A"

SEE PROPRIETARY NOTICE ON SHEET ONE		
CONNECTORIZED SWITCHBOARD CABLE ASSEMBLIES	DWG SIZE	ISSUE
	c2	49
LUCENT TECHNOLOGIES INC.	ED5D621-35	SHEET C55

ED5D621-35

GROUP 242A - 2.5 [1]
 GROUP 246A - 5.1 [2]


2.5 [1]
 DS

809A CA


GROUP 242A - 25.7 [8 1/2]
 GROUP 246A - 20.3 [8]

1.0 [3/8]

7.6 [3]

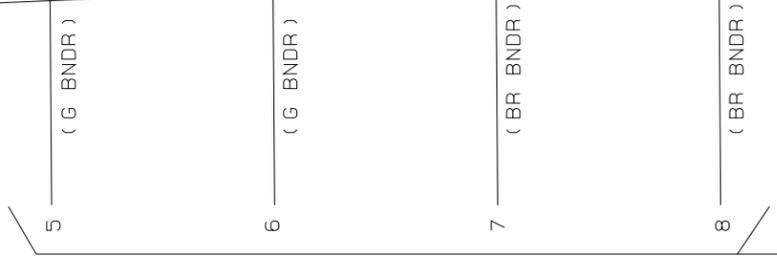

SK 26.7 [10 1/2] FOR GROUP 242A
 SK 27.9 [11] FOR GROUP 246A
 (INCLUDES 25.4 [10] FOR MANUFACTURING PURPOSES)

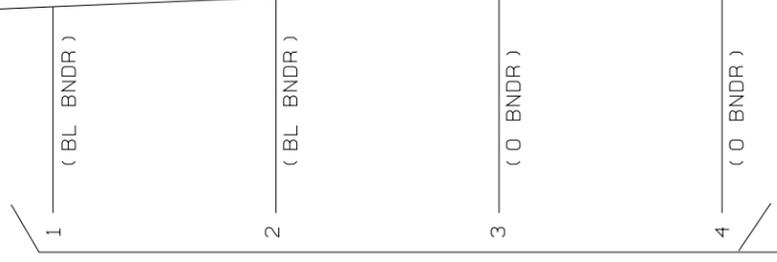

10.2 [4] - GROUP 242A
 7.6 [3] - GROUP 246A
 1.3 [1/2]
 3.8 [1 1/2]
 1.3 [1/2]

GROUP 242A, 246A
 CABLE FOR INTEGRATED SERVICES LINE UNIT (4-WIRE OSPS)
 LG 08-11
 END "A"

SEE PROPRIETARY NOTICE ON SHEET ONE		
CONNECTORIZED SWITCHBOARD CABLE ASSEMBLIES	DWG SIZE	ISSUE
	c2	49
LUCENT TECHNOLOGIES INC.	ED5D621-35	SHEET C56

ED5D621-35

GROUP 244A - 3.8 [1 1/2]
 GROUP 248A - 6.4 [2 1/2]


2.5 [1]
 DS

1.0 [3/8]

809A CA

GROUP 244A - 6.4 [2 1/2]
 GROUP 248A - 5.1 [2]

7.6 [3]

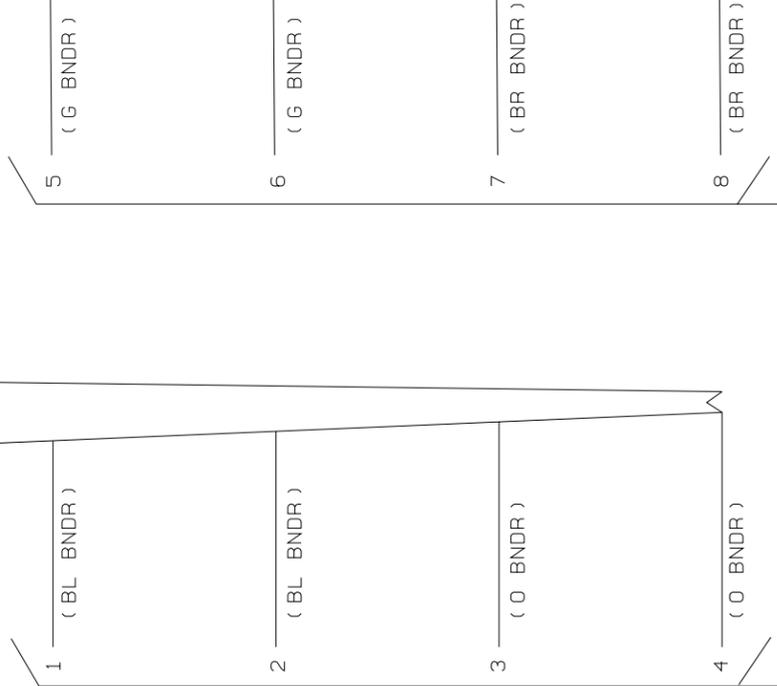

SK 26.7 [10 1/2] FOR GROUP 244A
 SK 27.9 [11] FOR GROUP 248A
 (INCLUDES 25.4 [10] FOR MANUFACTURING PURPOSES)

10.2 [4] - GROUP 244A
 7.6 [3] - GROUP 248A

1.3 [1/2] 3.8 [1 1/2] 1.3 [1/2]


GROUP 244A, 248A
 CABLE FOR INTEGRATED SERVICES LINE UNIT (4-WIRE OSPS)
 LG 12-15
 END "A"

SEE PROPRIETARY NOTICE ON SHEET ONE		
CONNECTORIZED SWITCHBOARD CABLE ASSEMBLIES	DWG SIZE	ISSUE
	c2	49
LUCENT TECHNOLOGIES INC.	ED5D621-35	SHEET c57

ED5D621-35

809A CA

SK 26.7 [10 1/2] TO ARM CL
(INCLUDES 25.4 [10] FOR MANUFACTURING PURPOSES)

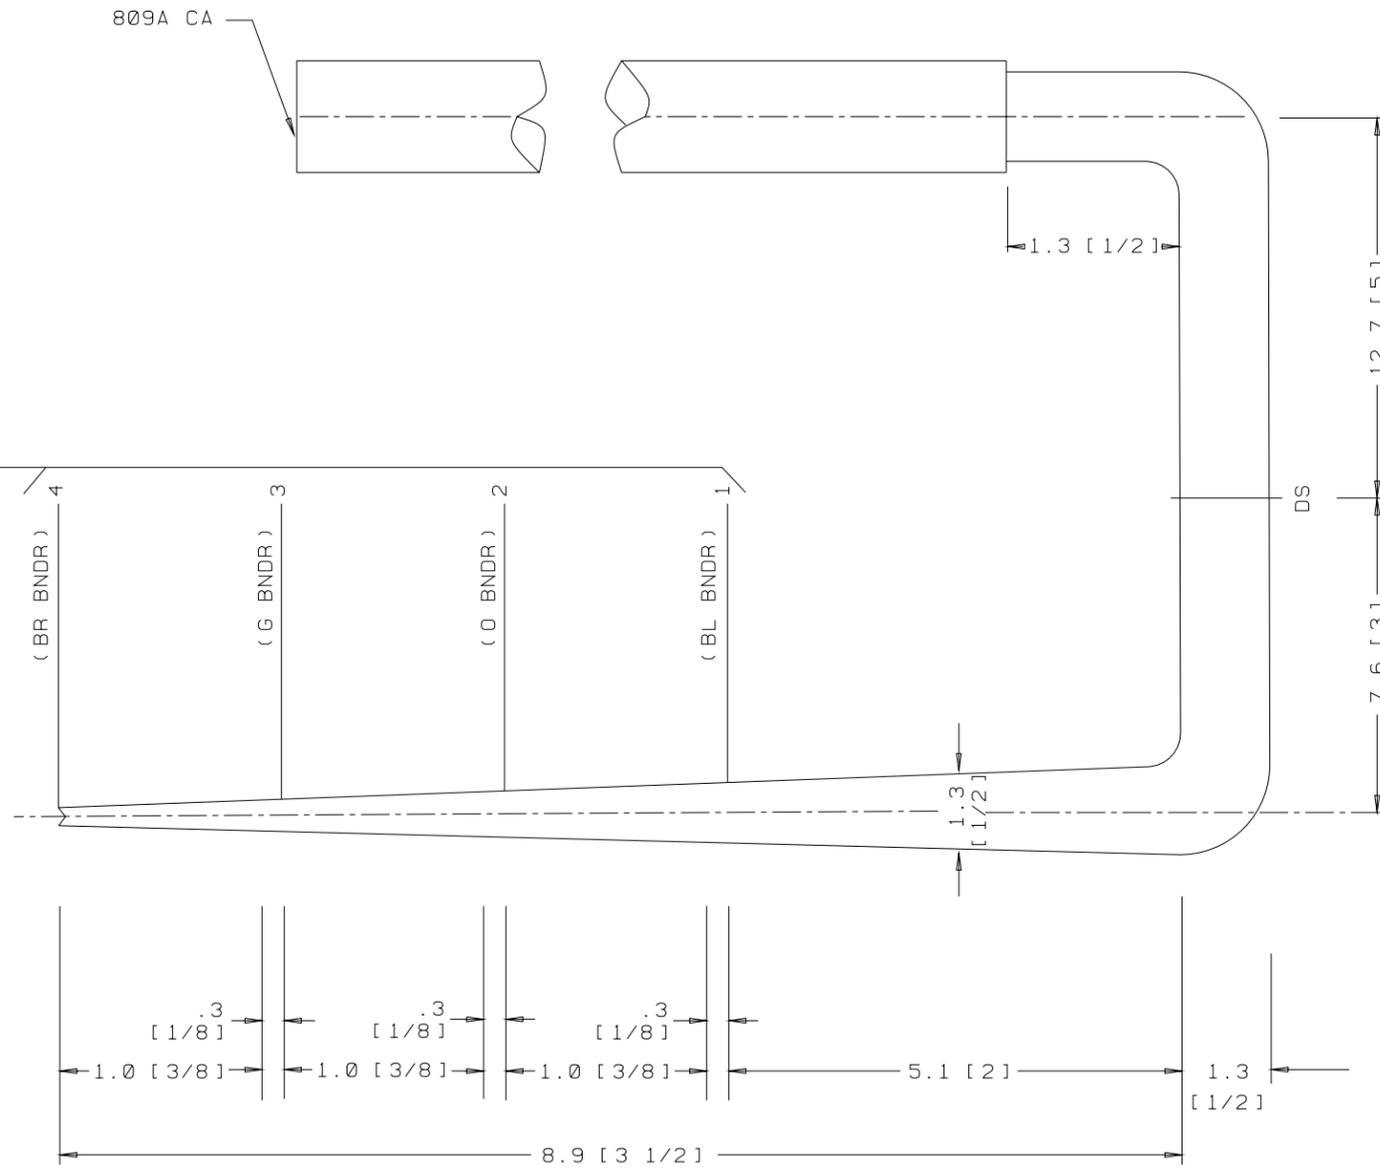

GROUP 251A

CABLE FOR INTEGRATED SERVICES LINE UNIT (4-WIRE)

LG 00
END "A"

SEE PROPRIETARY NOTICE ON SHEET ONE

CONNECTORIZED SWITCHBOARD
CABLE ASSEMBLIES

DWG SIZE
c2

ISSUE
49

LUCENT
TECHNOLOGIES INC.


ED5D621-35

SHEET
c58

ED5D621-35

809A CA

SK 26.7 [10 1/2] TO ARM C
 (INCLUDES 25.4 [10] FOR MANUFACTURING PURPOSES)

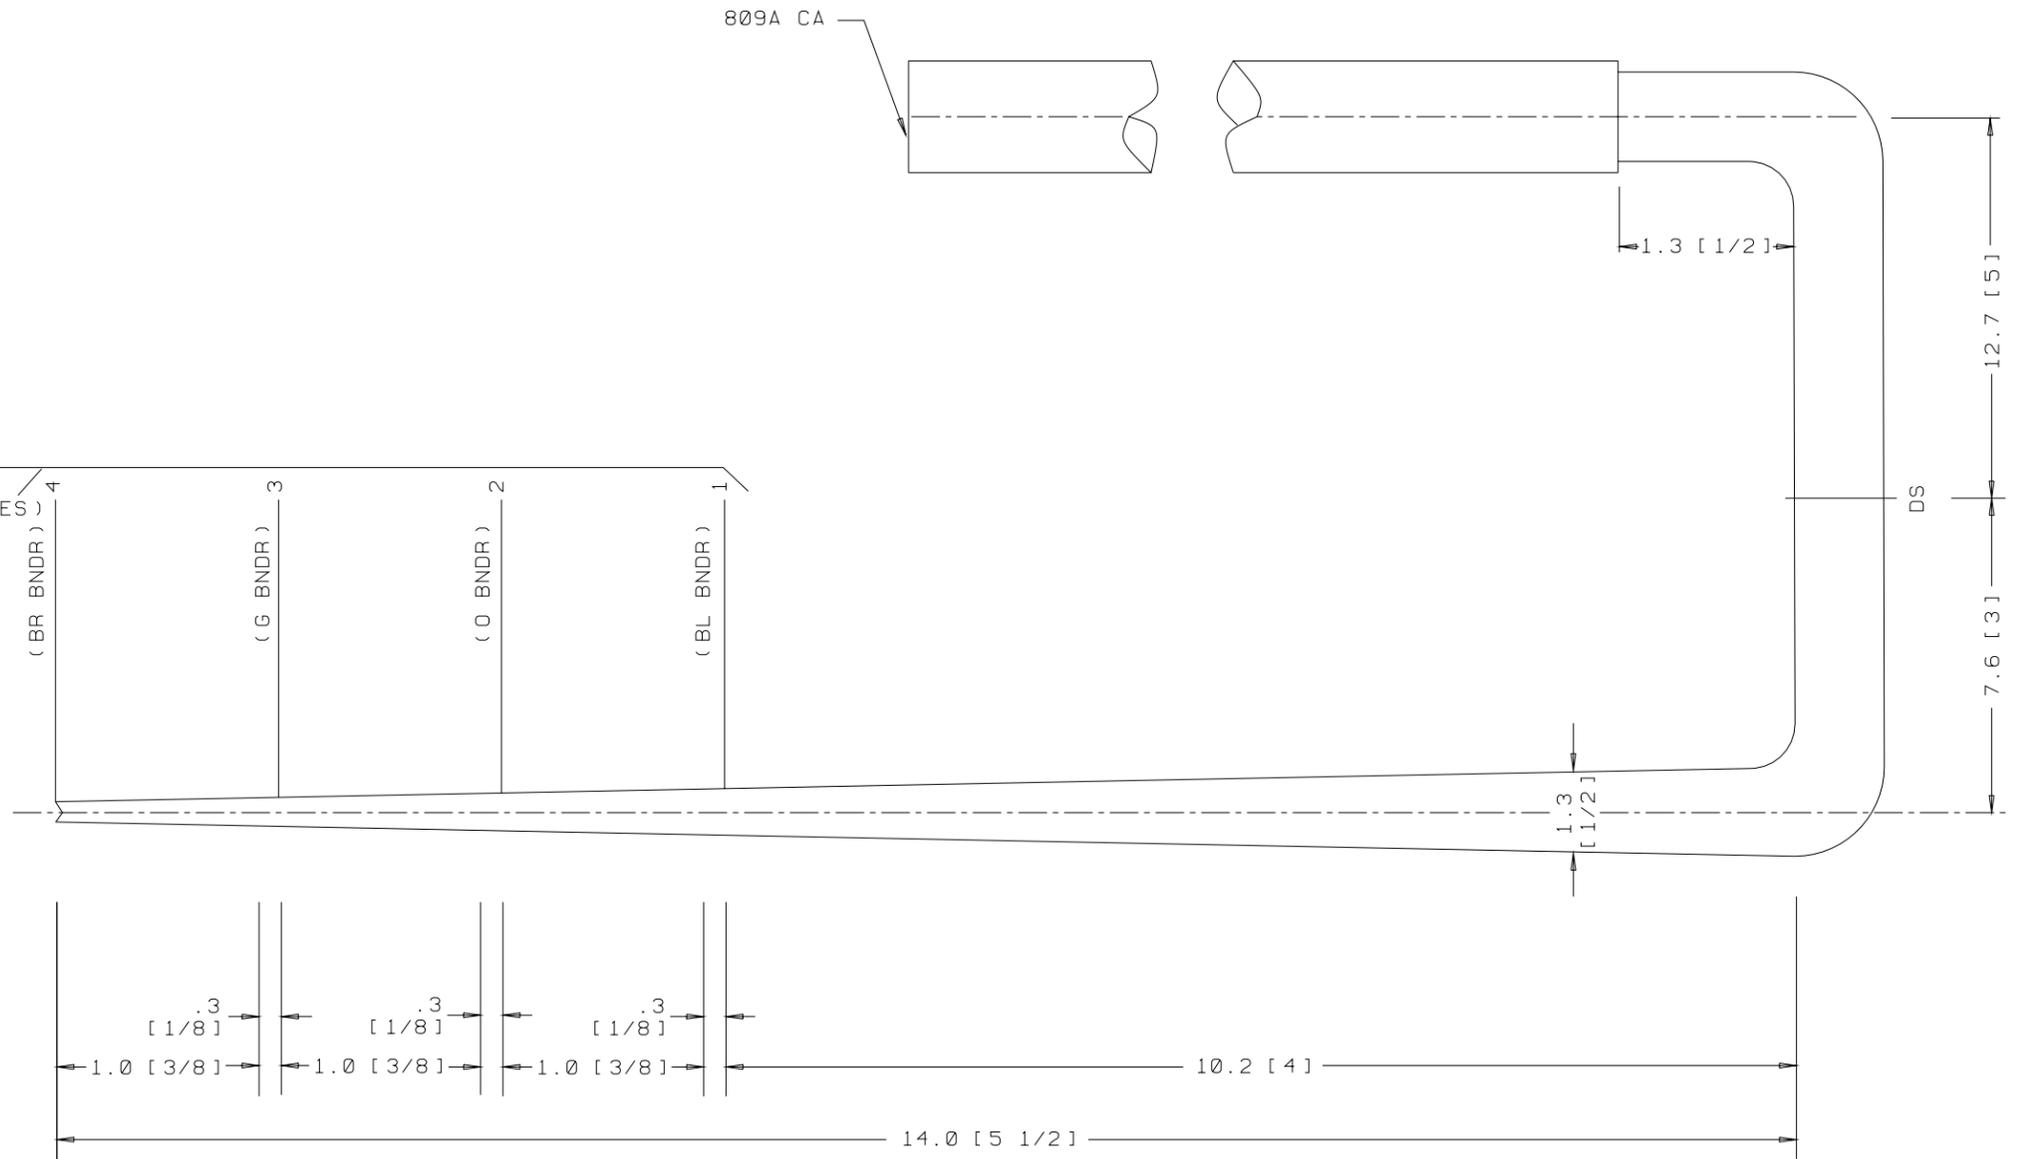

GROUP 252A

CABLE FOR INTEGRATED SERVICES LINE UNIT (4-WIRE)


LG 01
 END "A"

SEE PROPRIETARY NOTICE ON SHEET ONE		
CONNECTORIZED SWITCHBOARD CABLE ASSEMBLIES	DWG SIZE	ISSUE
	c2	49
LUCENT TECHNOLOGIES INC.	ED5D621-35	SHEET c59

ED5D621-35

809A CA

SK 26.7 [10 1/2] TO ARM C
 (INCLUDES 25.4 [10] FOR MANUFACTURING PURPOSES)

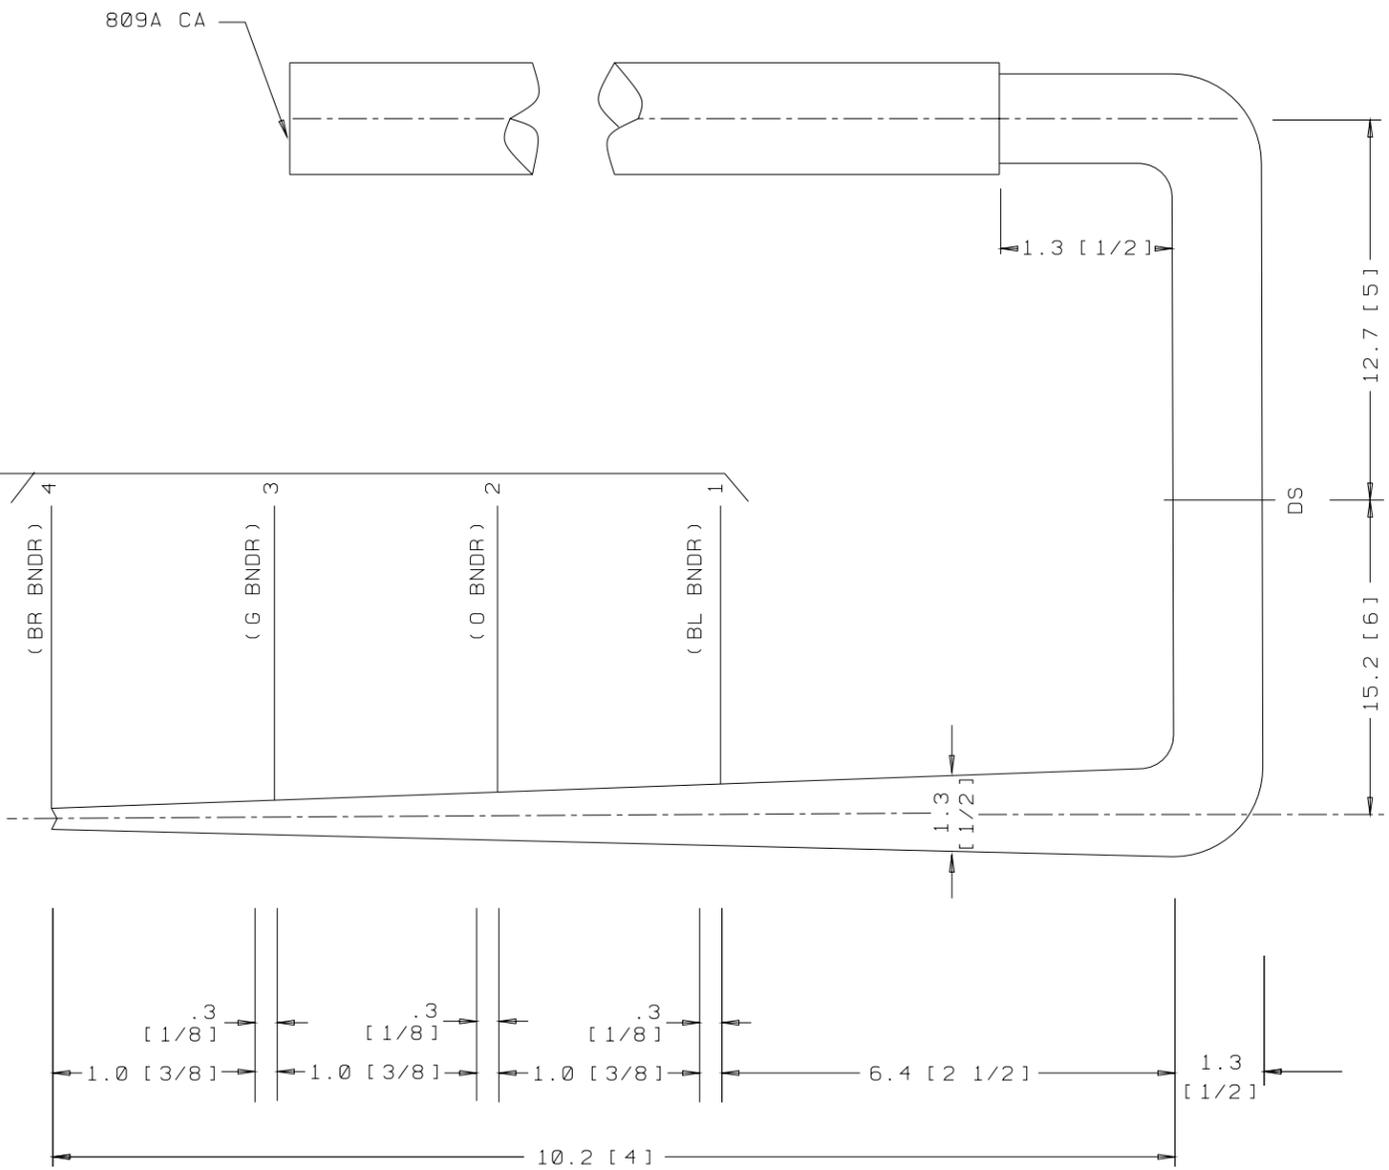

GROUP 253A


CABLE FOR INTEGRATED SERVICES LINE UNIT (4-WIRE)

LG 02
 END "A"

SEE PROPRIETARY NOTICE ON SHEET ONE		
CONNECTORIZED SWITCHBOARD CABLE ASSEMBLIES	DWG SIZE	ISSUE
	c2	49
LUCENT TECHNOLOGIES INC.	ED5D621-35	SHEET C60

809A CA

SK 26.7 [10 1/2] TO ARM C
(INCLUDES 25.4 [10] FOR MANUFACTURING PURPOSES)

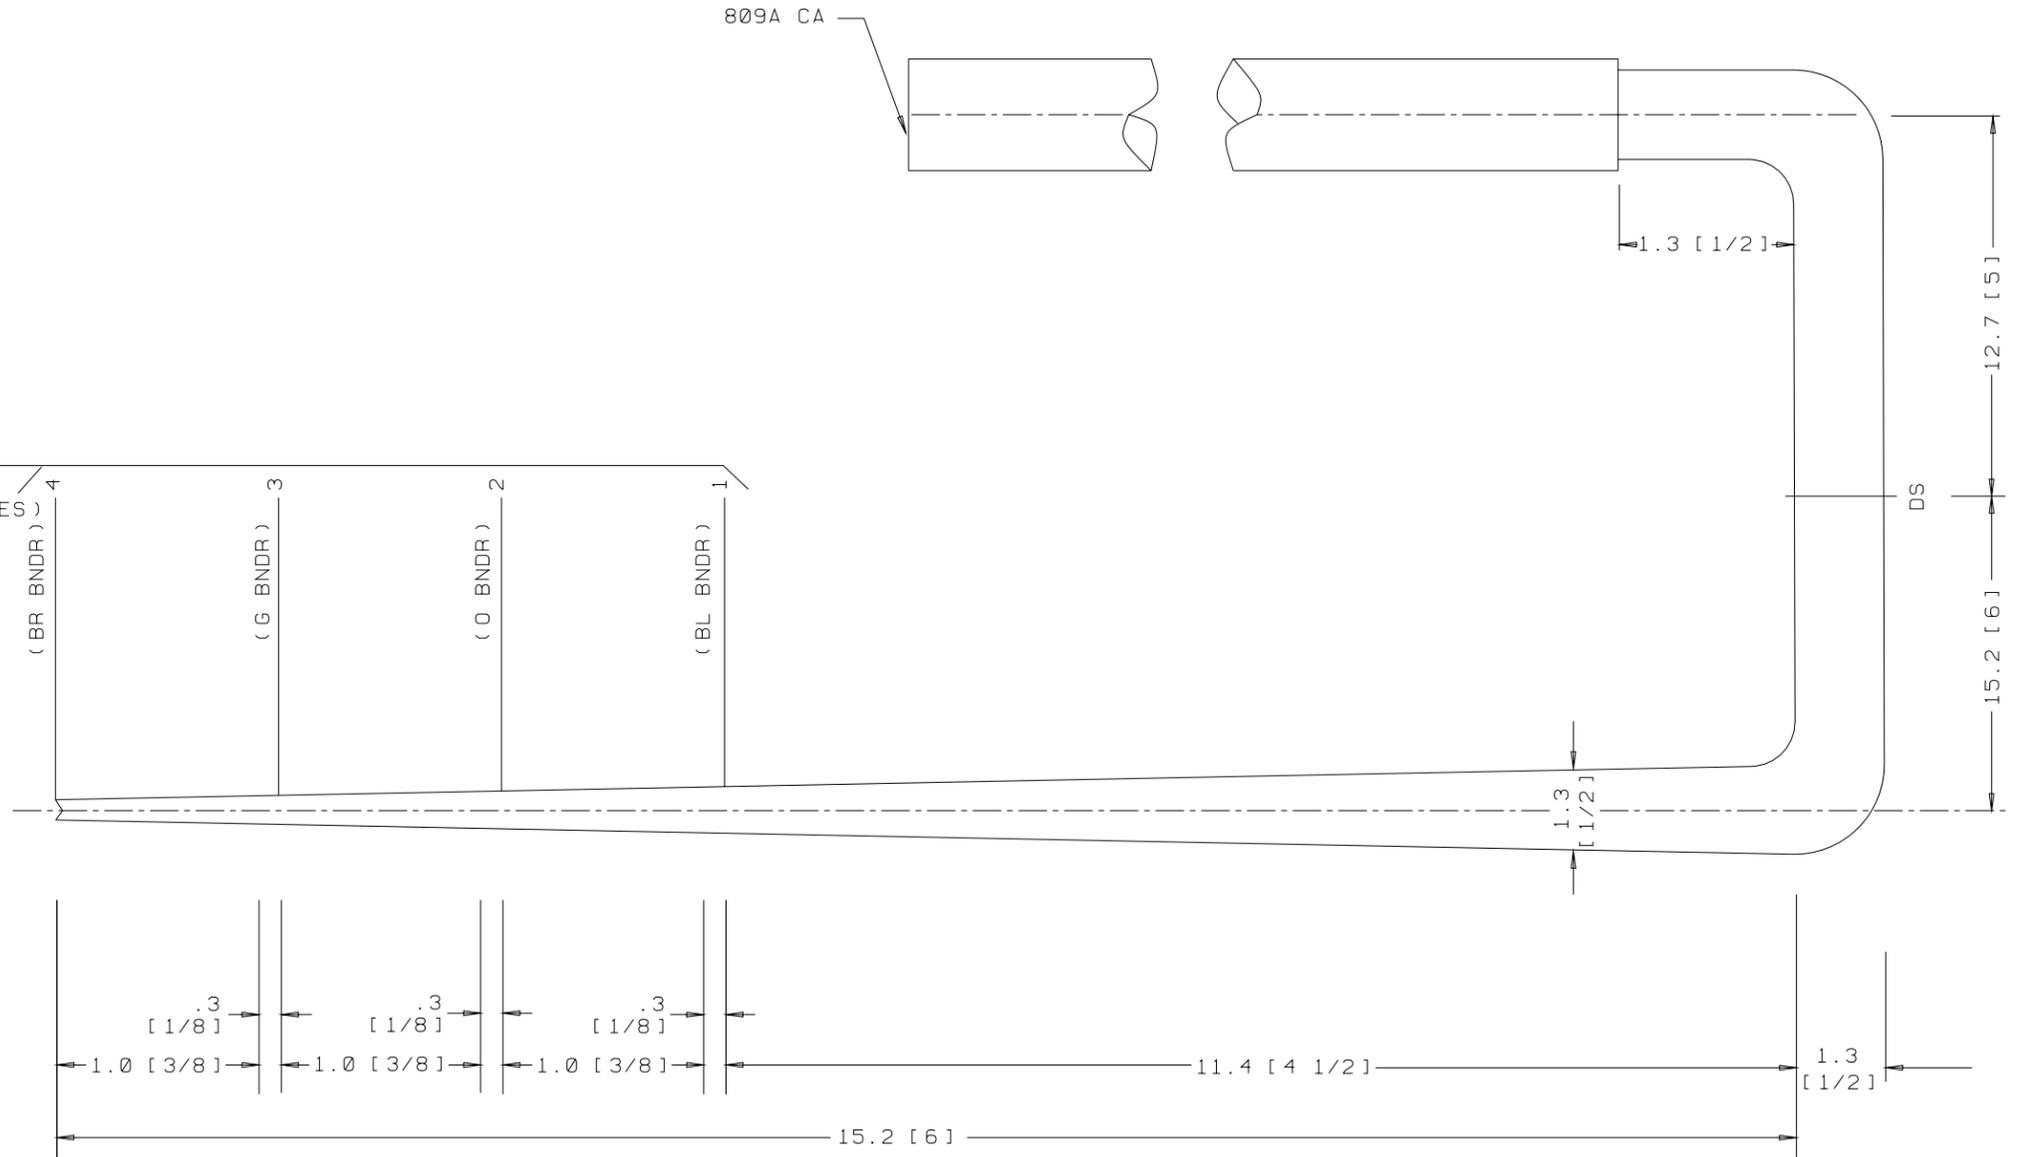


GROUP 254A
 CABLE FOR INTEGRATED SERVICES LINE UNIT (4-WIRE)
 LG Ø3
 END "A"



SEE PROPRIETARY NOTICE ON SHEET ONE		
CONNECTORIZED SWITCHBOARD CABLE ASSEMBLIES		
DWG SIZE c2	ISSUE 49	
LUCENT TECHNOLOGIES INC.	ED5D621-35	SHEET c61

ED5D621-35

809A CA

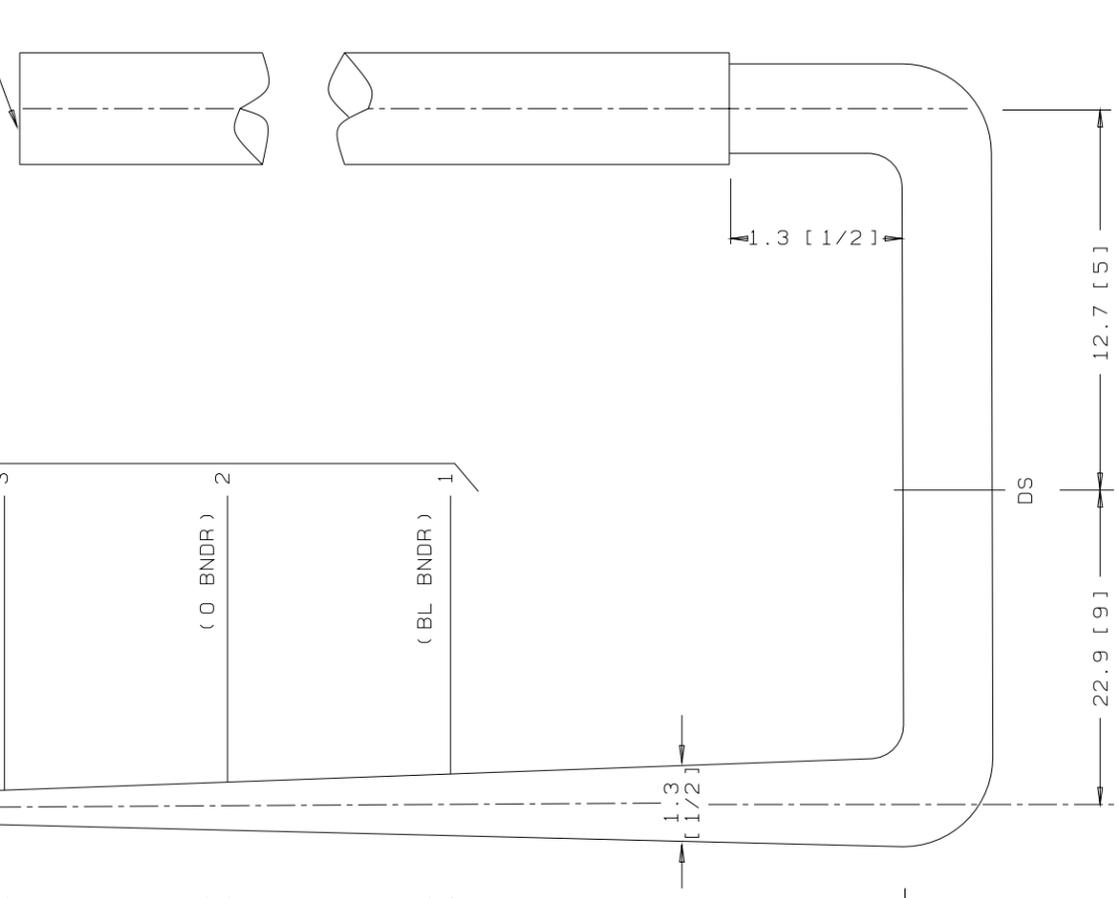

SK 26.7 [10 1/2] TO ARM C
 (INCLUDES 25.4 [10] FOR MANUFACTURING PURPOSES)

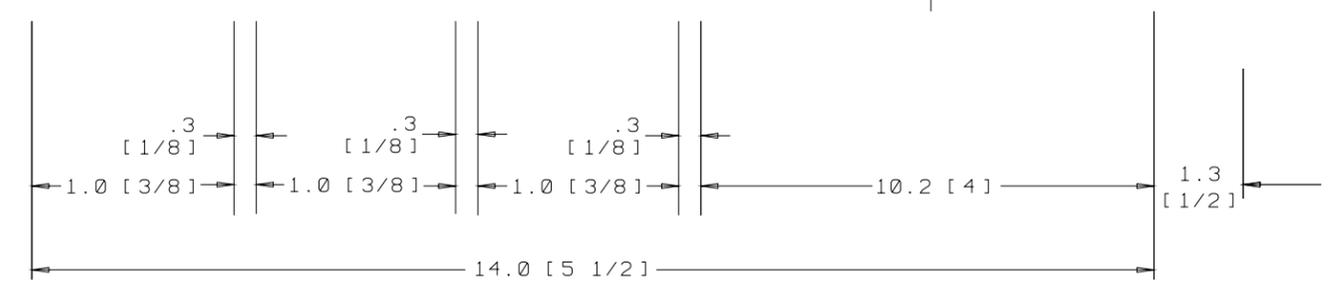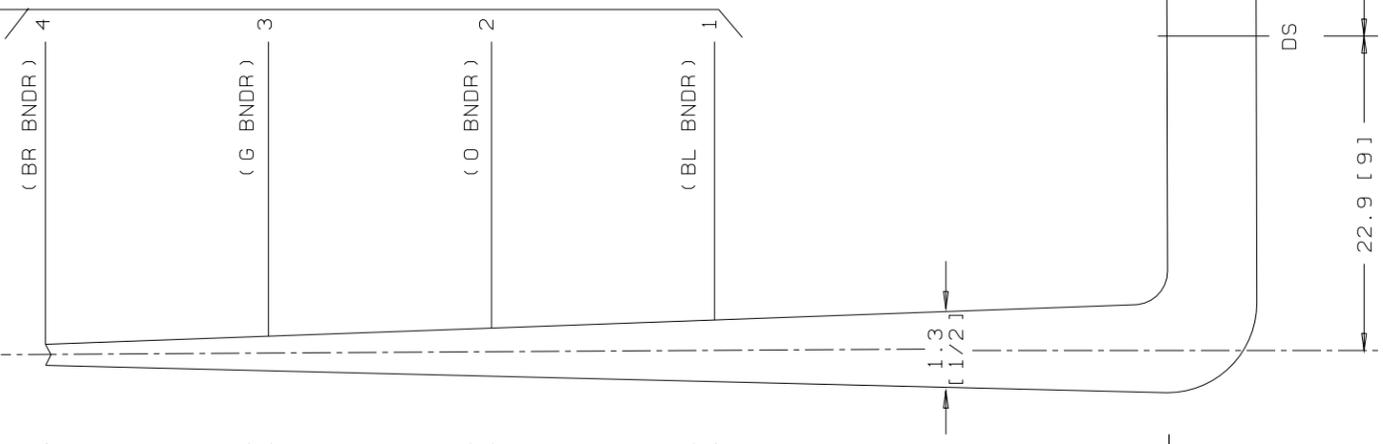


GROUP 255A
 CABLE FOR INTEGRATED SERVICES LINE UNIT (4-WIRE)
 LG Ø4
 END "A"

SEE PROPRIETARY NOTICE ON SHEET ONE		
CONNECTORIZED SWITCHBOARD CABLE ASSEMBLIES	DWG SIZE	ISSUE
	c2	49
LUCENT TECHNOLOGIES INC.	ED5D621-35	SHEET c62

ED5D621-35

809A CA

SK 26.7 [10 1/2] TO ARM C
 (INCLUDES 25.4 [10] FOR MANUFACTURING PURPOSES)

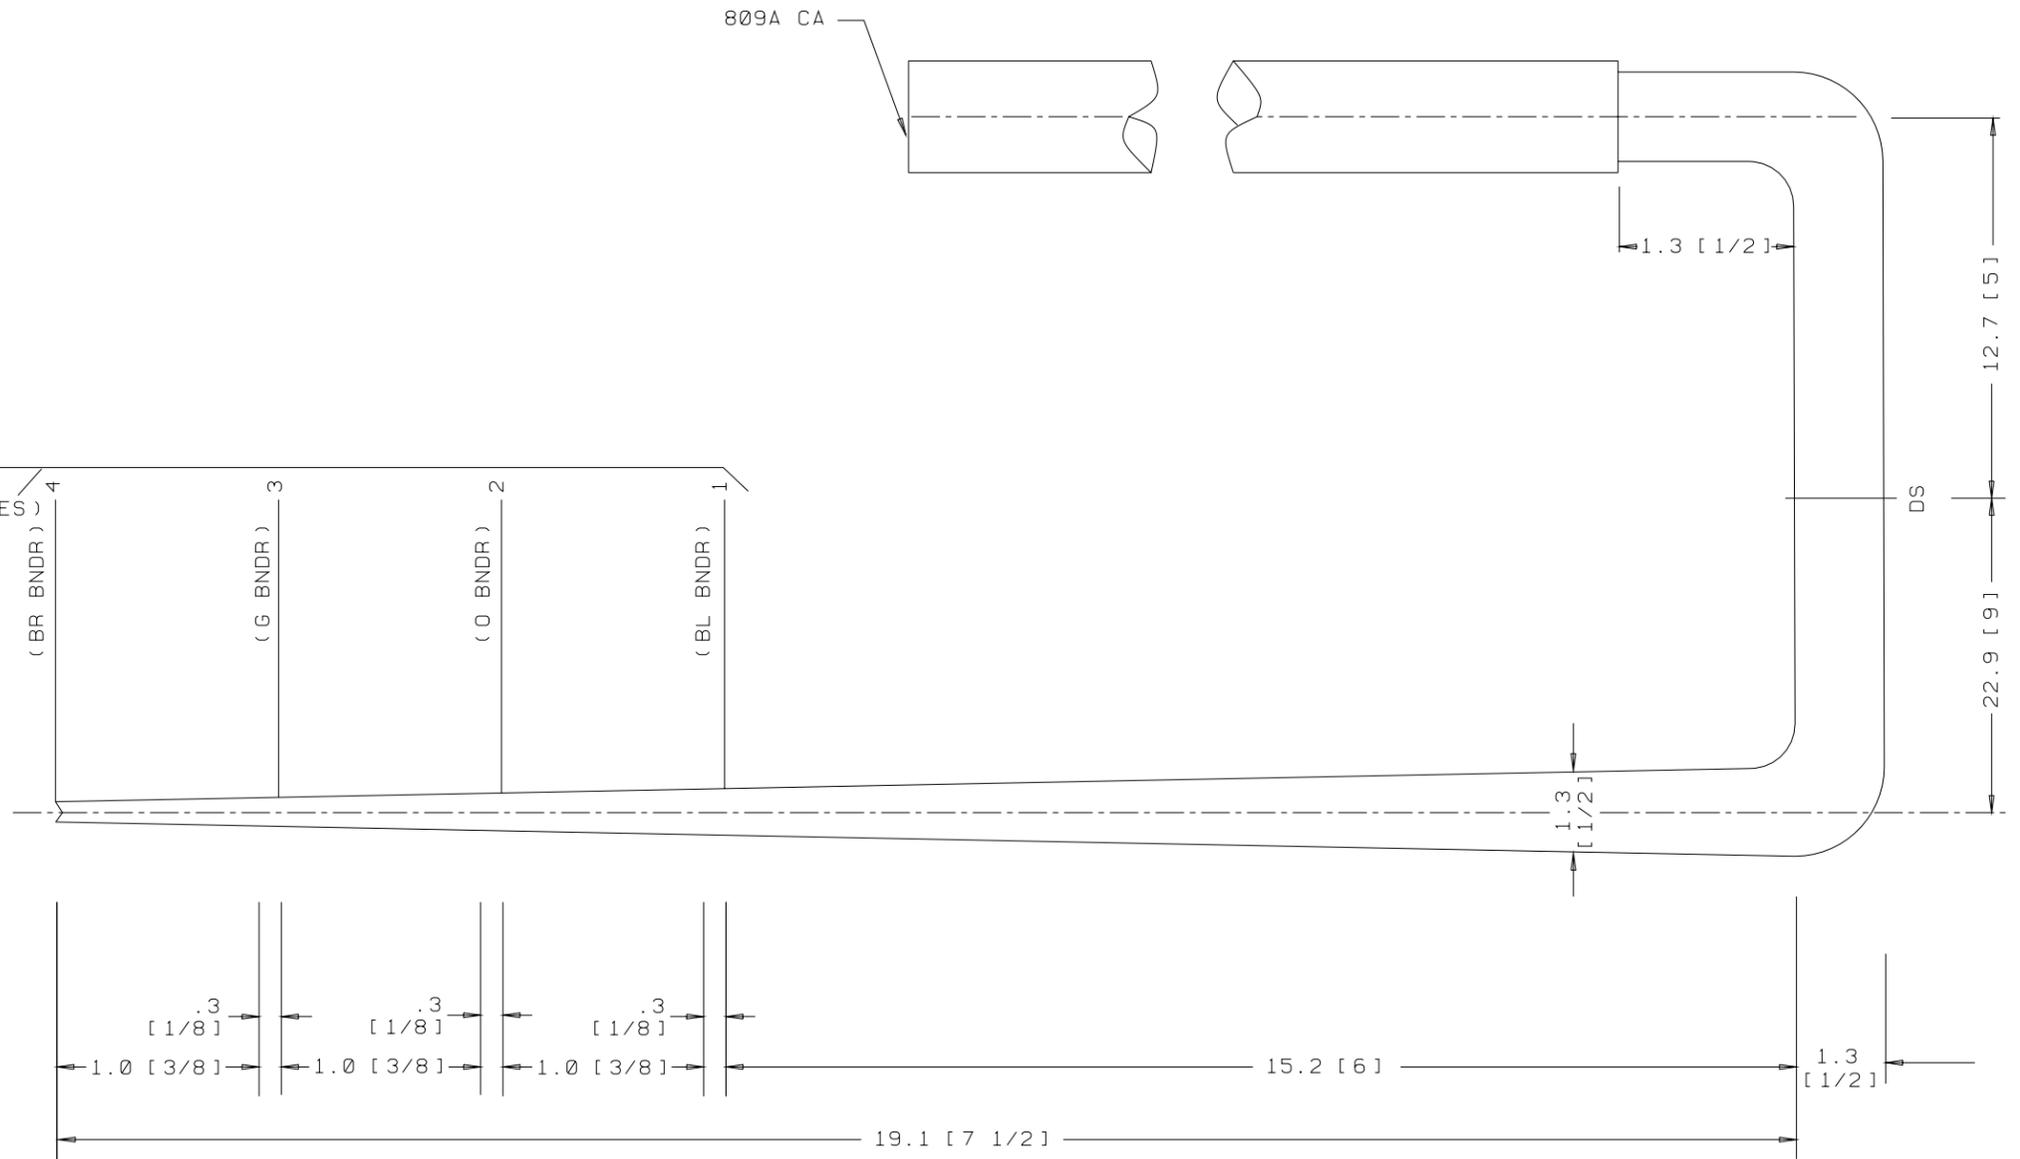


GROUP 256A
 CABLE FOR INTEGRATED SERVICES LINE UNIT (4-WIRE)
 LG 05
 END "A"

SEE PROPRIETARY NOTICE ON SHEET ONE		
CONNECTORIZED SWITCHBOARD CABLE ASSEMBLIES		
	DWG SIZE c2	ISSUE 49
LUCENT TECHNOLOGIES INC.	ED5D621-35	SHEET c63

ED5D621-35

809A CA

SK 26.7 [10 1/2] TO ARM C
 (INCLUDES 25.4 [10] FOR MANUFACTURING PURPOSES)

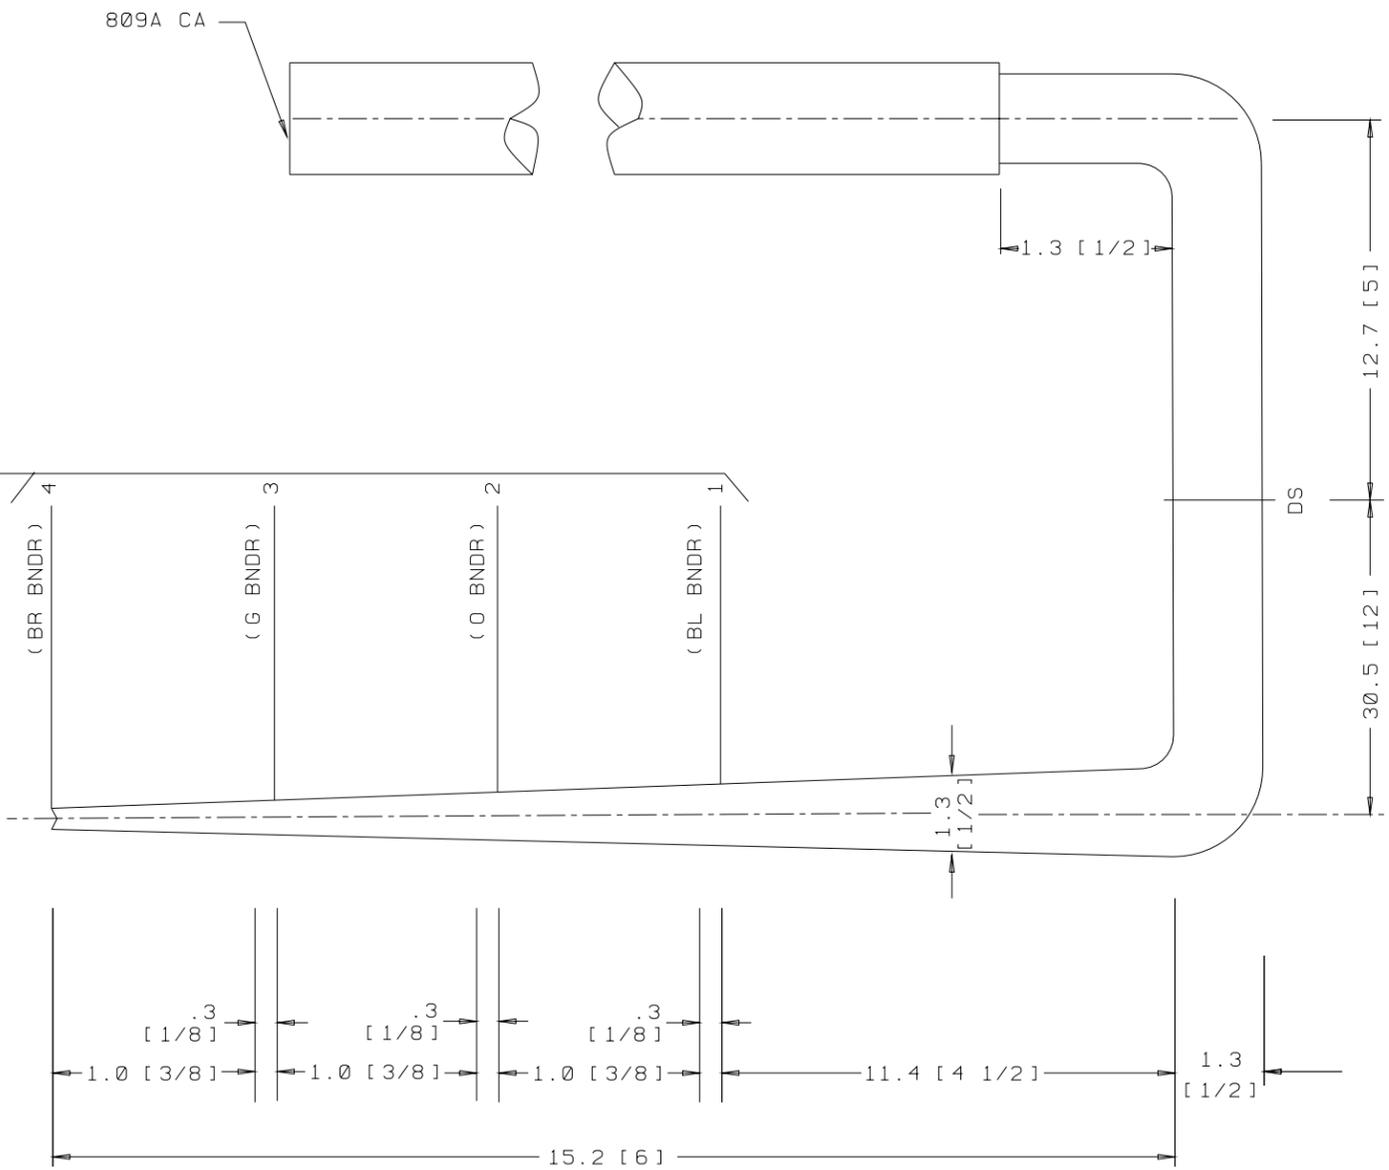

GROUP 257A
 CABLE FOR INTEGRATED SERVICES LINE UNIT (4-WIRE)
 LG 06
 END "A"

SEE PROPRIETARY NOTICE ON SHEET ONE		
CONNECTORIZED SWITCHBOARD CABLE ASSEMBLIES	DWG SIZE	ISSUE
	c2	49
LUCENT TECHNOLOGIES INC.	ED5D621-35	SHEET C64

ED5D621-35

809A CA



1.3
[1/2]

12.7 [5]

DS

30.5 [12]

1.3
[1/2]

1.3
[1/2]

SK 26.7 [10 1/2] TO ARM C

(INCLUDES 25.4 [10] FOR MANUFACTURING PURPOSES)



.3
[1/8]

.3
[1/8]

.3
[1/8]

1.0 [3/8]

1.0 [3/8]

1.0 [3/8]

16.5 [6 1/2]

20.3 [8]

GROUP 258A

CABLE FOR INTEGRATED SERVICES LINE UNIT (4-WIRE)

LG 07
END "A"

SEE PROPRIETARY NOTICE ON SHEET ONE

CONNECTORIZED SWITCHBOARD
CABLE ASSEMBLIES

DWG SIZE
C2


ISSUE
49

LUCENT
TECHNOLOGIES INC.


ED5D621-35

SHEET
C65

ED5D621-35

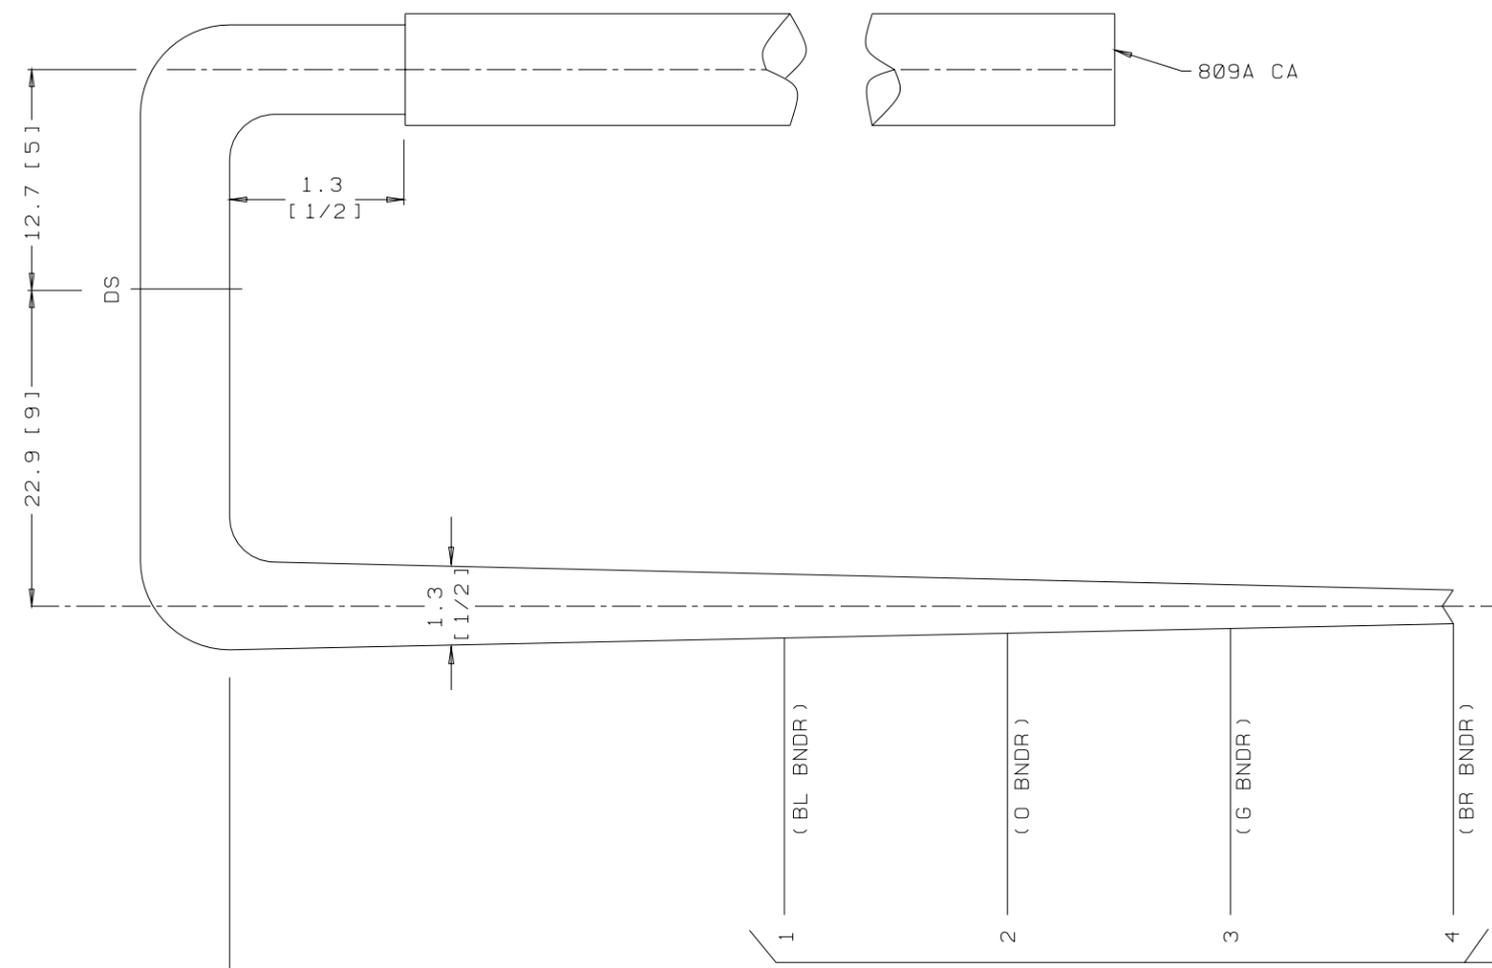


SK 26.7 [10 1/2] TO ARM C
 (INCLUDES 25.4 [10] FOR MANUFACTURING PURPOSES)

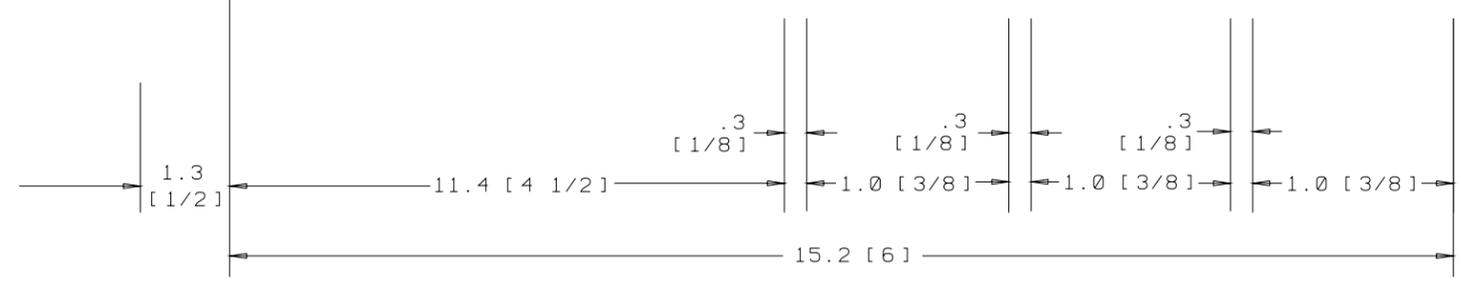


GROUP 259A
 CABLE FOR INTEGRATED SERVICES LINE UNIT (4-WIRE)
 LG Ø8
 END "A"

SEE PROPRIETARY NOTICE ON SHEET ONE		
CONNECTORIZED SWITCHBOARD CABLE ASSEMBLIES	DWG SIZE	ISSUE
	c2	49
LUCENT TECHNOLOGIES INC.	ED5D621-35	SHEET C66

ED5D621-35

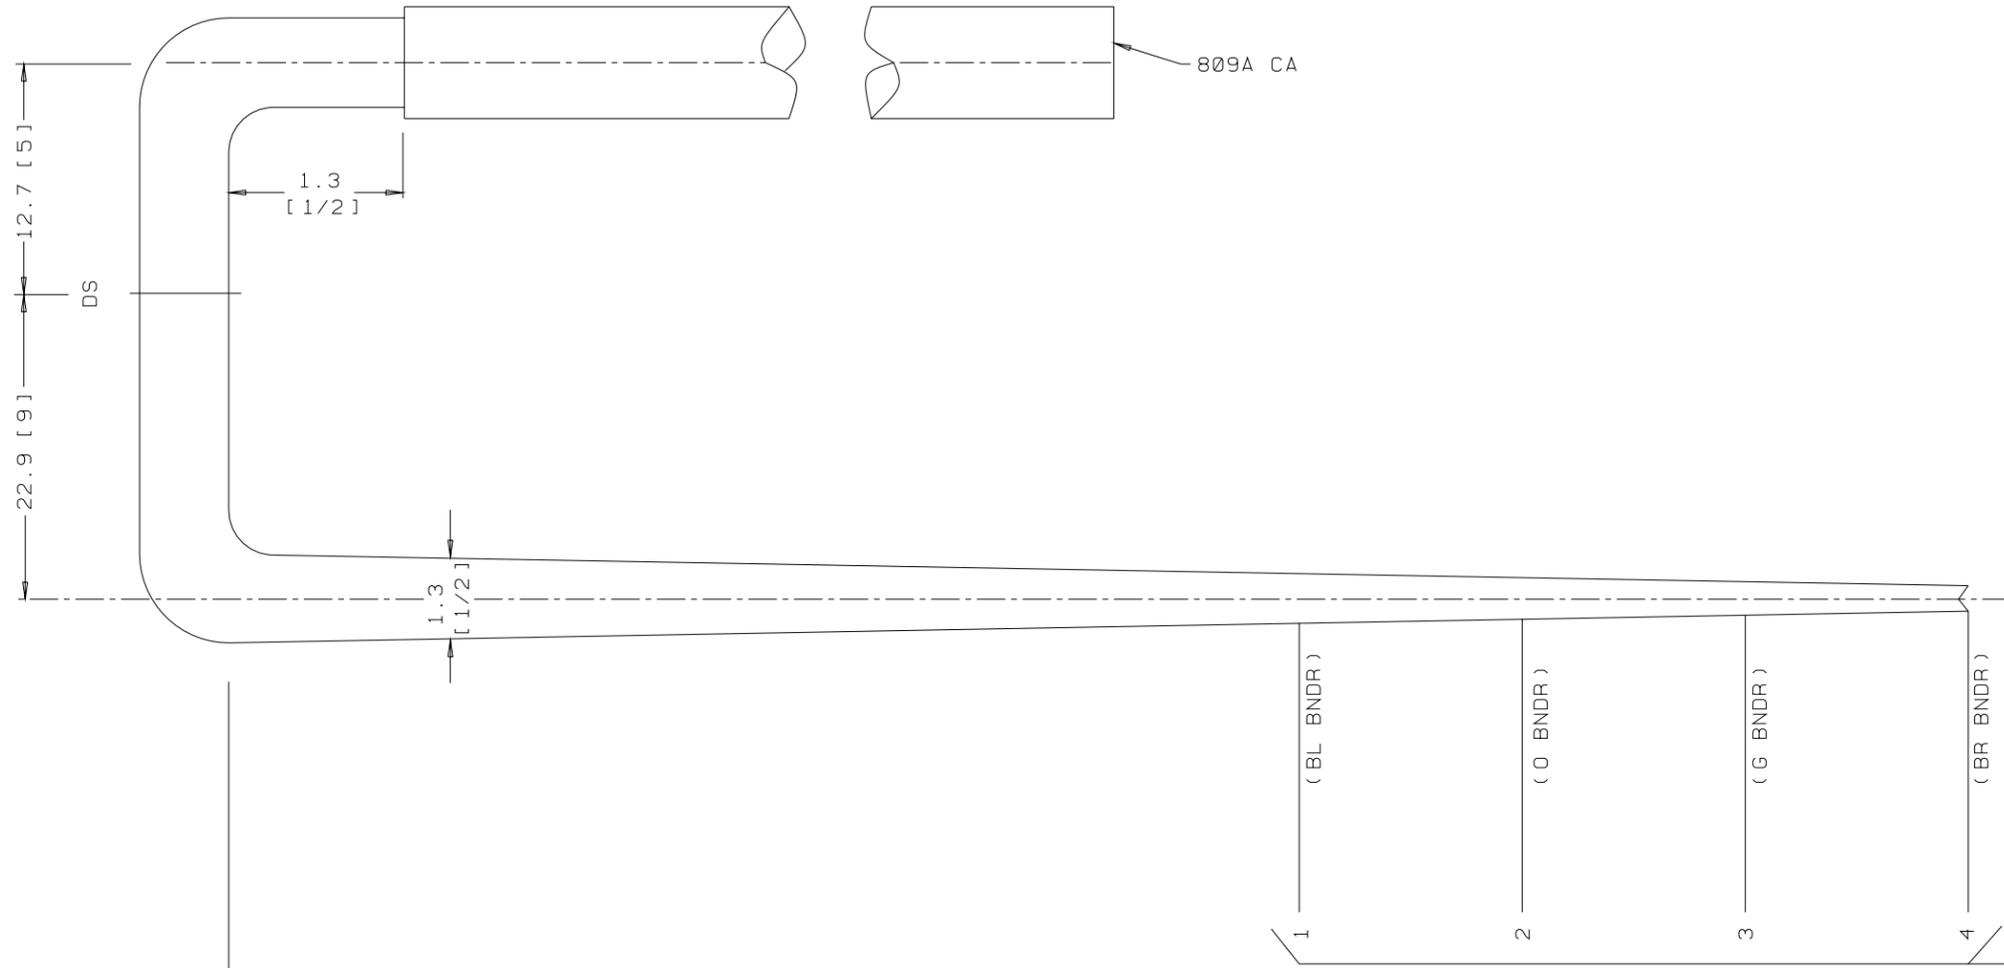


SK 26.7 [10 1/2] TO ARM Ⓞ
 (INCLUDES 25.4 [10] FOR MANUFACTURING PURPOSES)

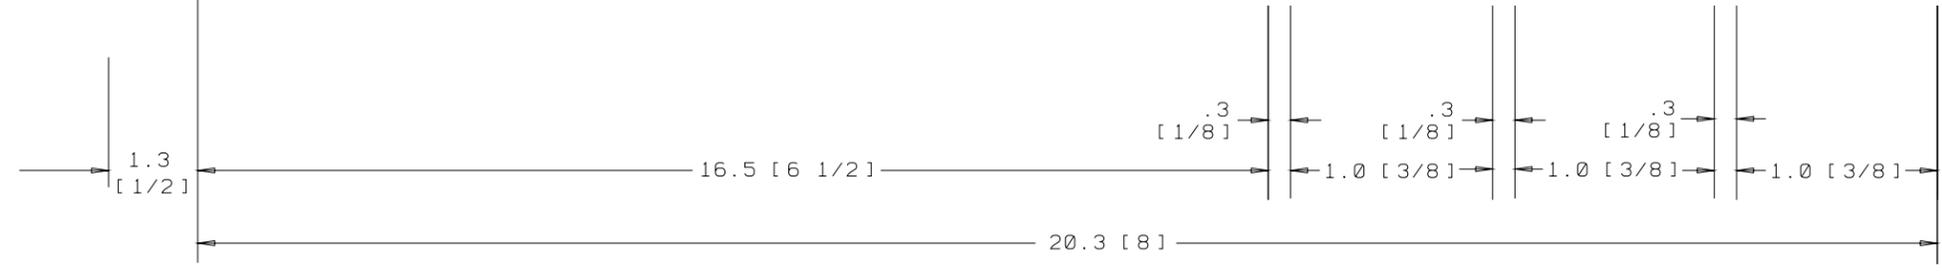

GROUP 260A
 CABLE FOR INTEGRATED SERVICES LINE UNIT (4-WIRE)
 LG 09
 END "A"

SEE PROPRIETARY NOTICE ON SHEET ONE		
CONNECTORIZED SWITCHBOARD CABLE ASSEMBLIES		
DWG SIZE c2	ISSUE 49	
LUCENT TECHNOLOGIES INC.	ED5D621-35	SHEET c67

ED5D621-35

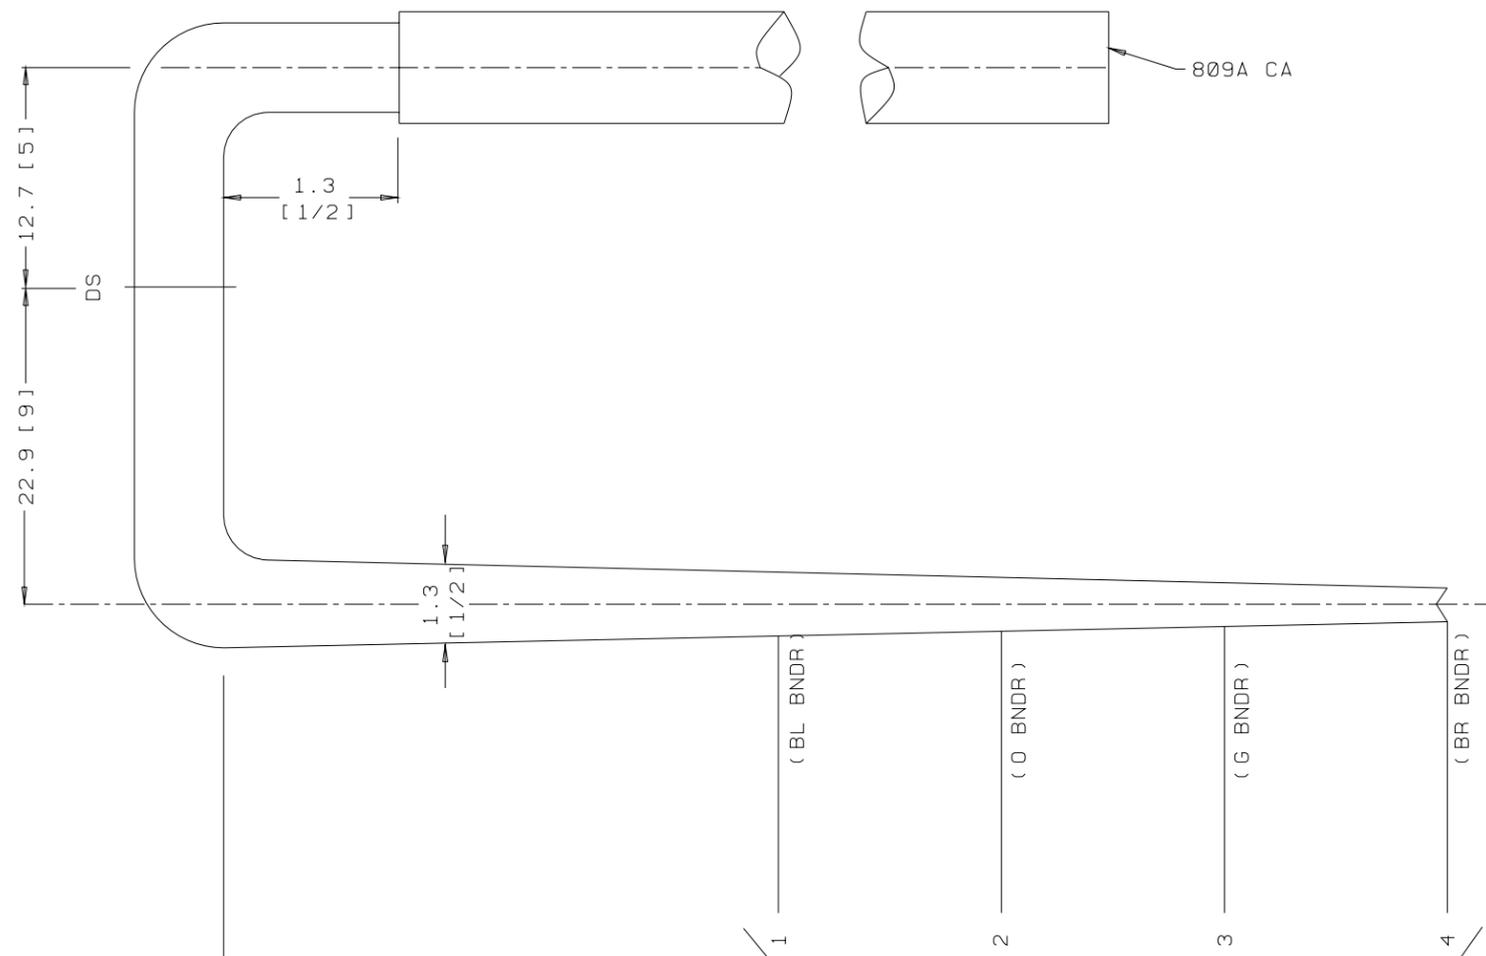


809A CA

DS


12.7 [5]
22.9 [9]

1.3 [1/2]

1.3 [1/2]

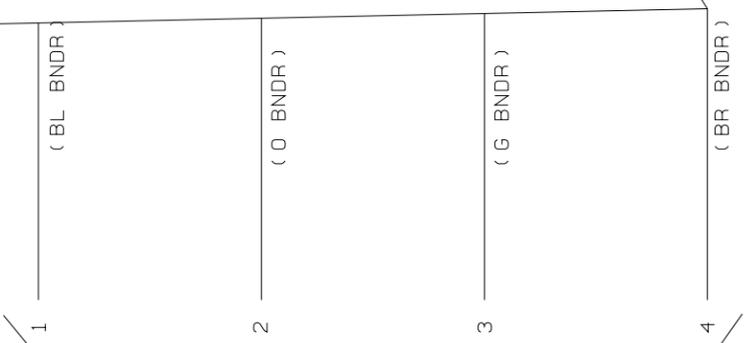


SK 26.7 [10 1/2] TO ARM CL
(INCLUDES 25.4 [10] FOR MANUFACTURING PURPOSES)

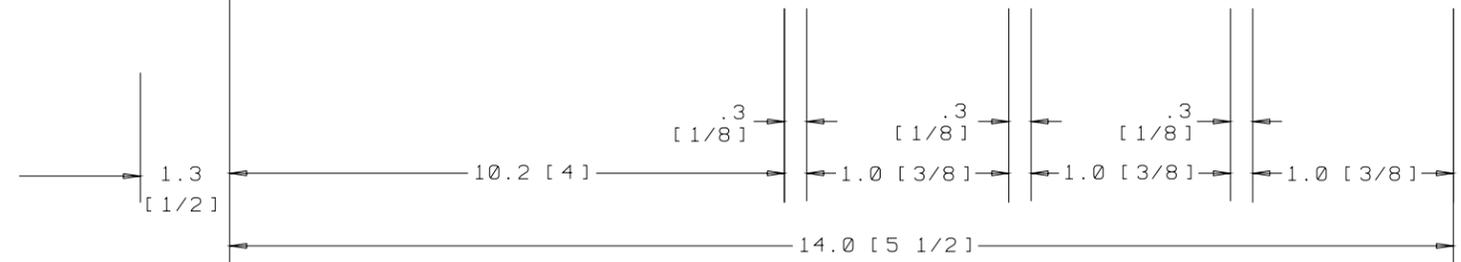

GROUP 261A
CABLE FOR INTEGRATED SERVICES LINE UNIT (4-WIRE)
LG 10
END "A"

SEE PROPRIETARY NOTICE ON SHEET ONE		
CONNECTORIZED SWITCHBOARD CABLE ASSEMBLIES	DWG SIZE	ISSUE
	c2	49
LUCENT TECHNOLOGIES INC.	ED5D621-35	SHEET C68

ED5D621-35

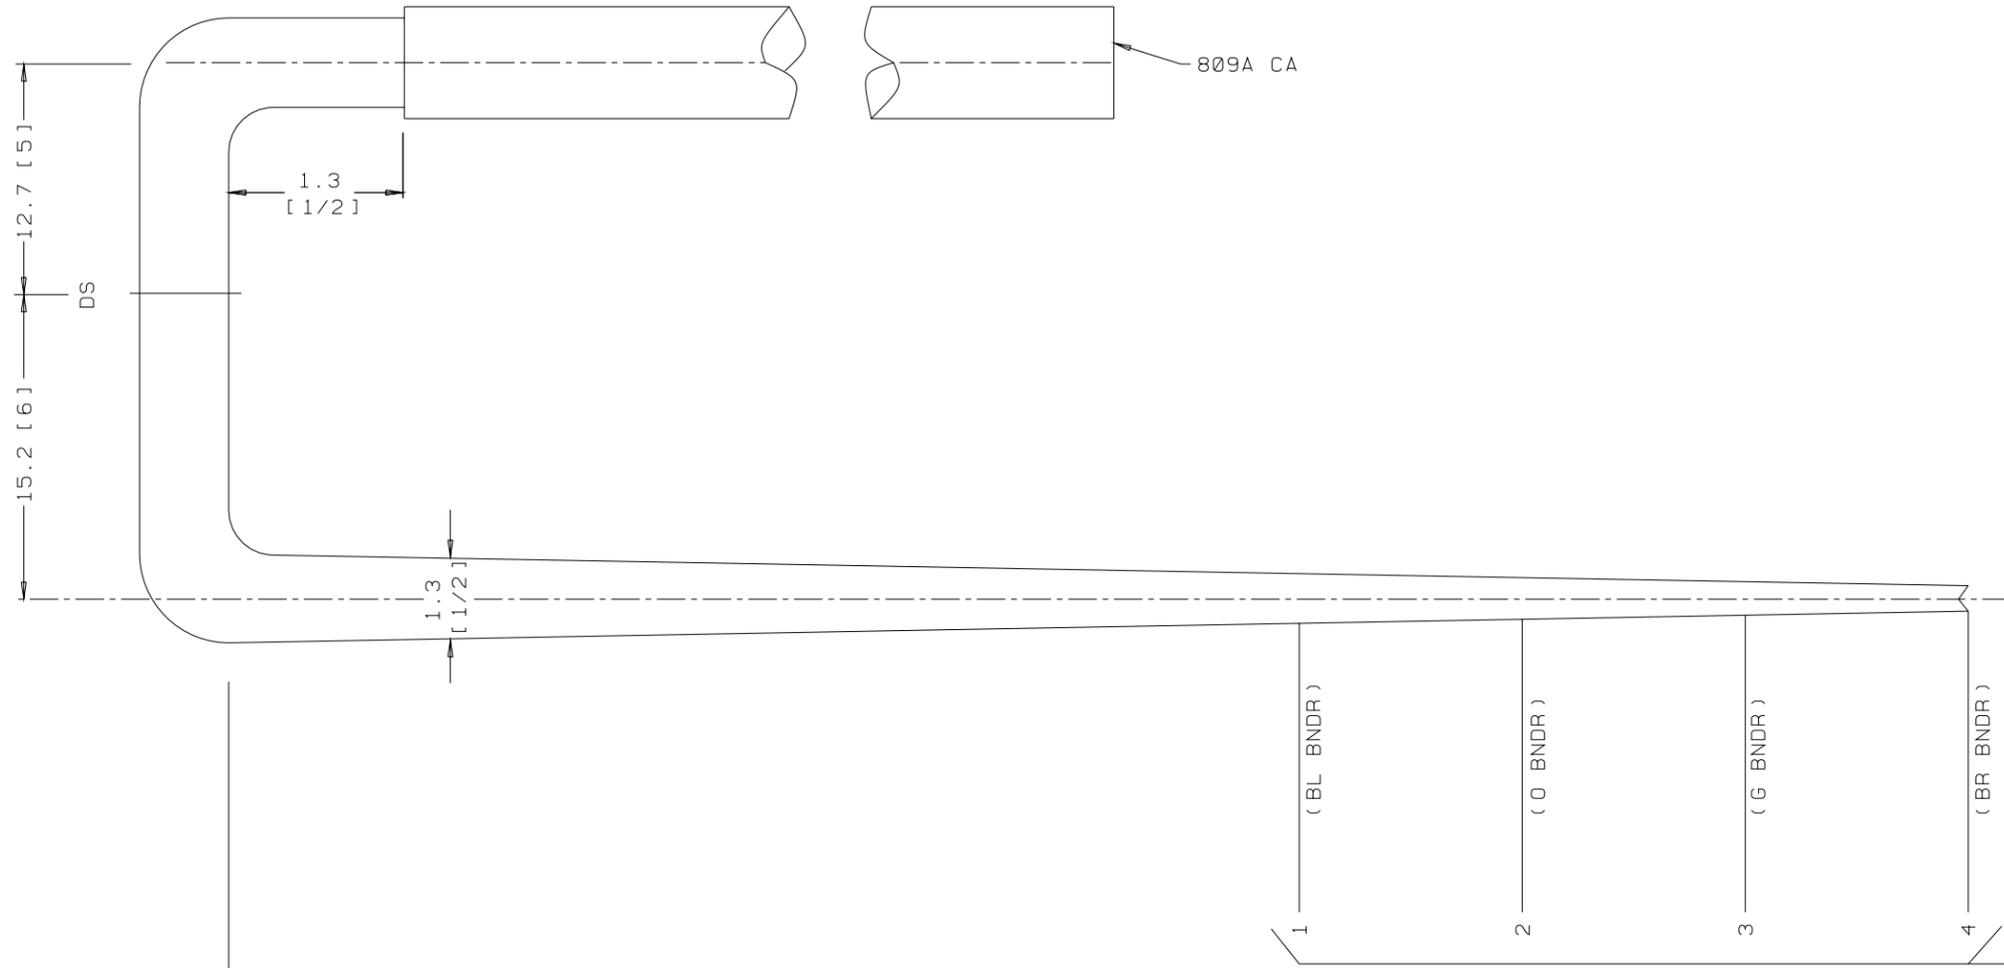


SK 26.7 [10 1/2] TO ARM C
 (INCLUDES 25.4 [10] FOR MANUFACTURING PURPOSES)



GROUP 262A
 CABLE FOR INTEGRATED SERVICES LINE UNIT (4-WIRE)
 LG 11
 END "A"

ED5D621-35

SEE PROPRIETARY NOTICE ON SHEET ONE		
CONNECTORIZED SWITCHBOARD CABLE ASSEMBLIES		
DWG SIZE c2	ISSUE 49	
LUCENT TECHNOLOGIES INC.	ED5D621-35	SHEET c69

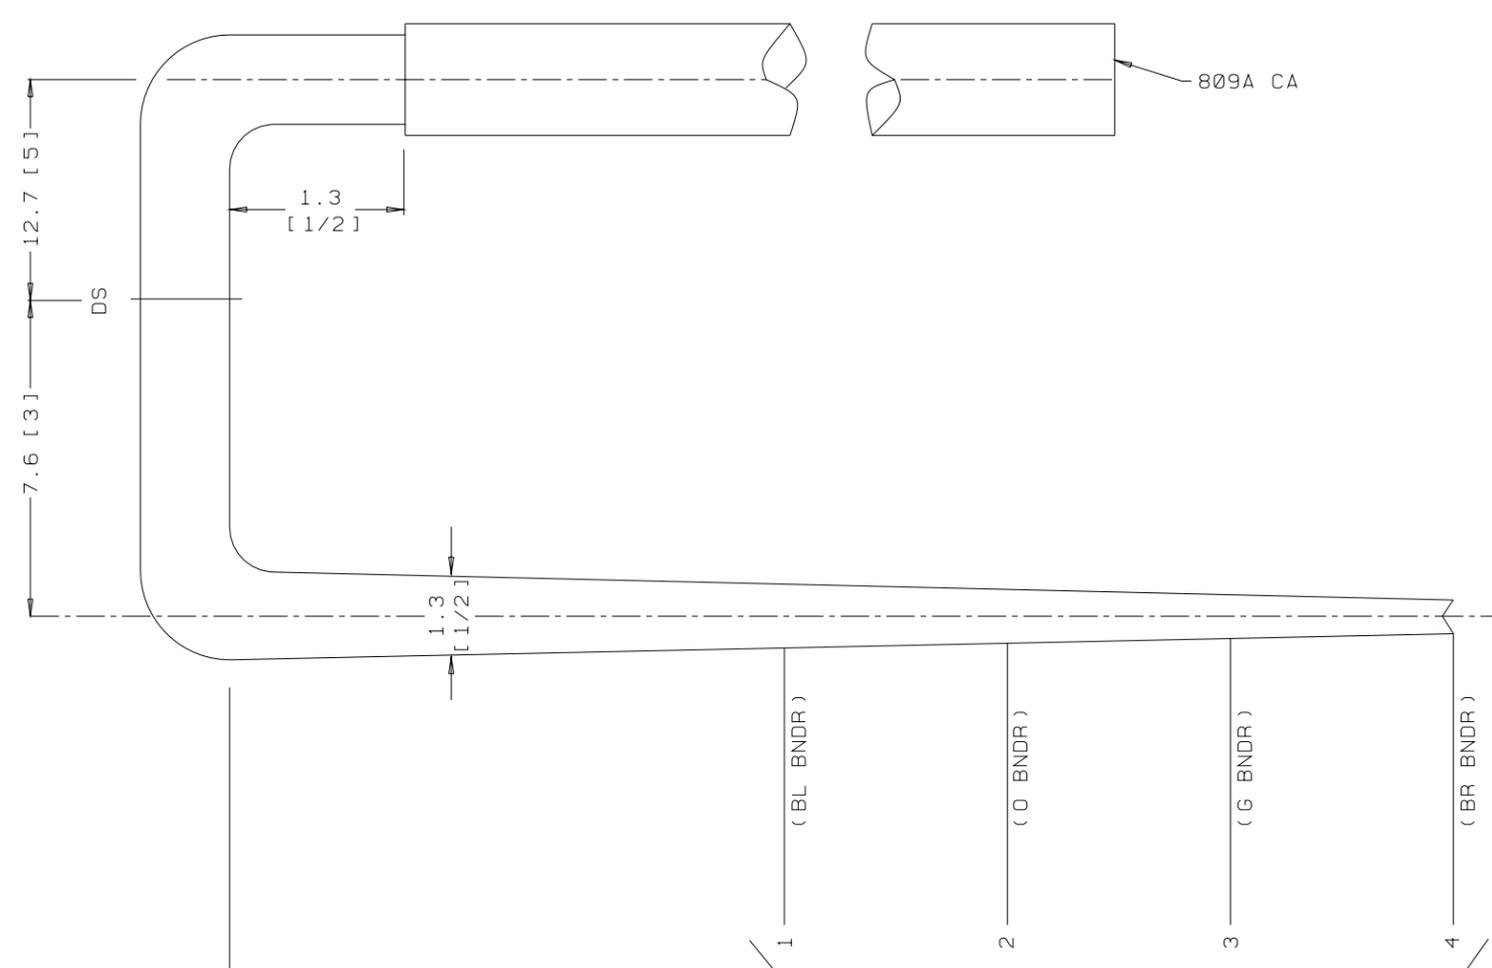


809A CA

DS

1 (BL BNDR)
2 (O BNDR)
3 (G BNDR)
4 (BR BNDR)


SK 26.7 [10 1/2] TO ARM Q
(INCLUDES 25.4 [10] FOR MANUFACTURING PURPOSES)

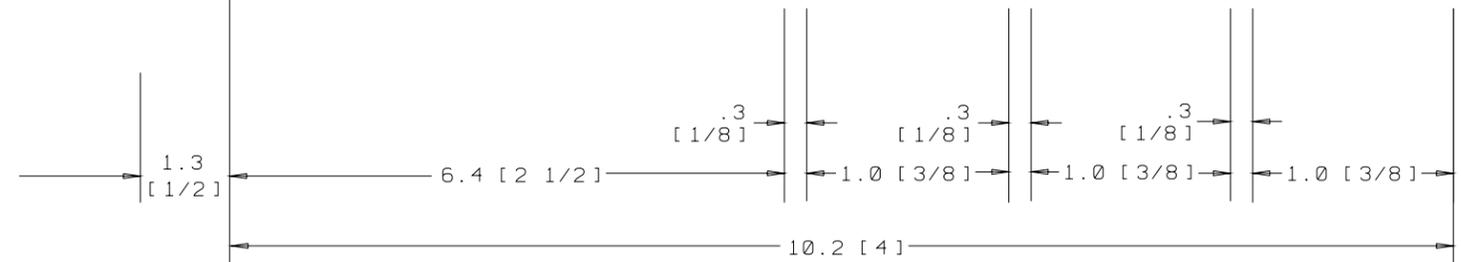


GROUP 263A
CABLE FOR INTEGRATED SERVICES LINE UNIT (4-WIRE)
LG 12
END "A"

SEE PROPRIETARY NOTICE ON SHEET ONE		
CONNECTORIZED SWITCHBOARD CABLE ASSEMBLIES	DWG SIZE	ISSUE
	c2	49
LUCENT TECHNOLOGIES INC.	ED5D621-35	SHEET c70

ED5D621-35

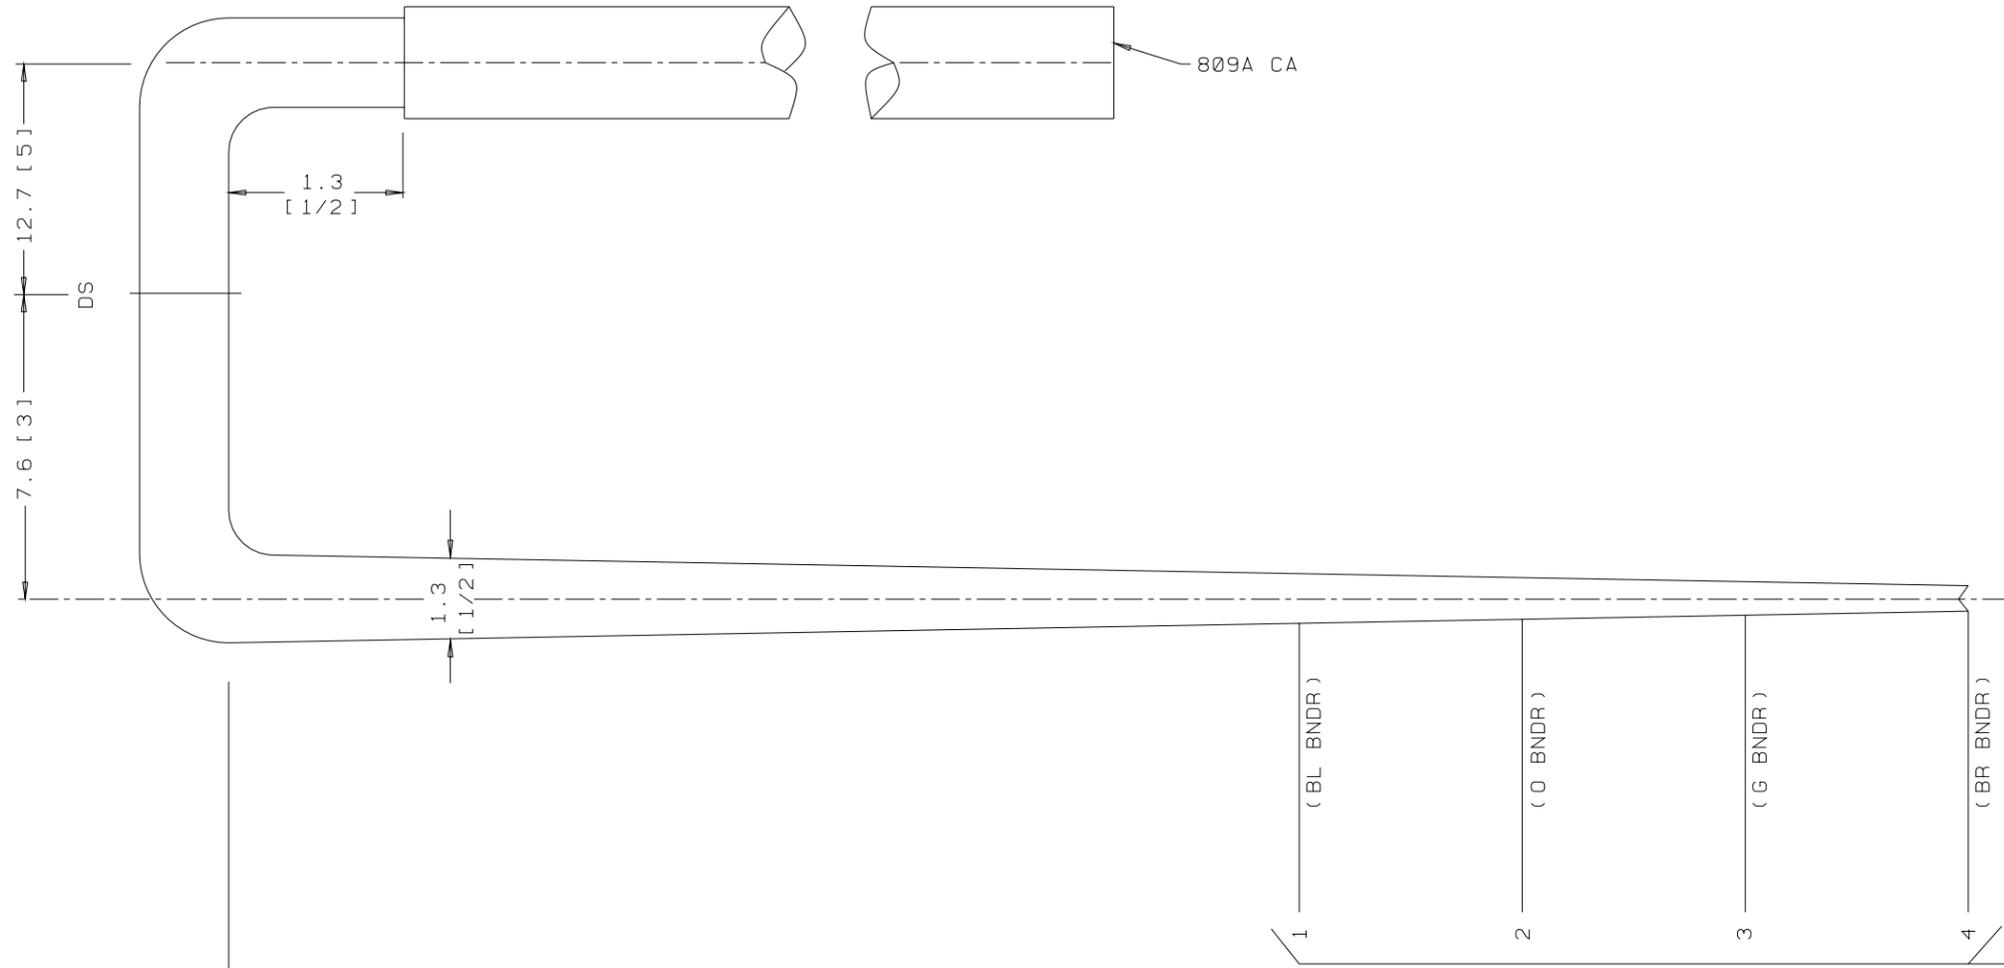


SK 26.7 [10 1/2] TO ARM C
 (INCLUDES 25.4 [10] FOR MANUFACTURING PURPOSES)

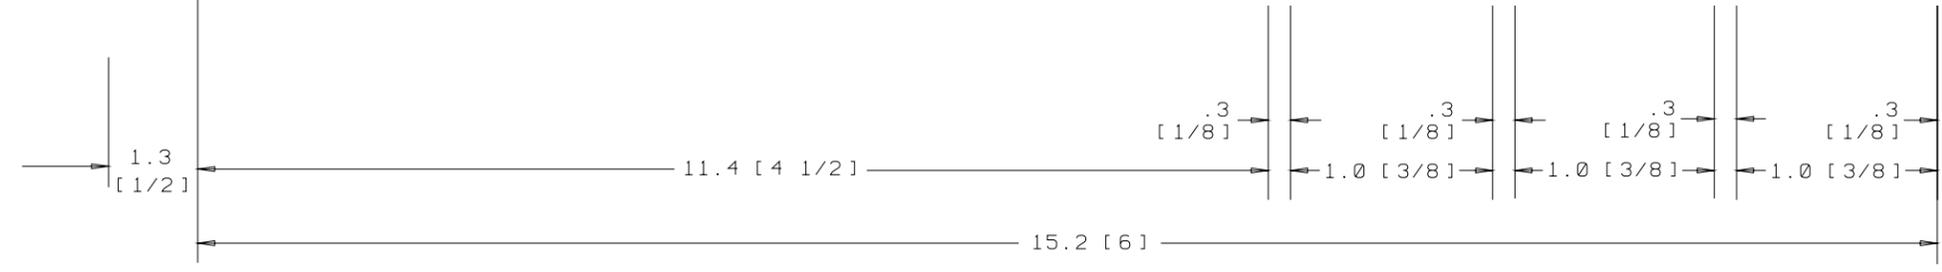


GROUP 264A
 CABLE FOR INTEGRATED SERVICES LINE UNIT (4-WIRE)
 LG 13
 END "A"

SEE PROPRIETARY NOTICE ON SHEET ONE		
CONNECTORIZED SWITCHBOARD CABLE ASSEMBLIES		
DWG SIZE c2	ISSUE 49	
LUCENT TECHNOLOGIES INC.	ED5D621-35	SHEET c71

ED5D621-35

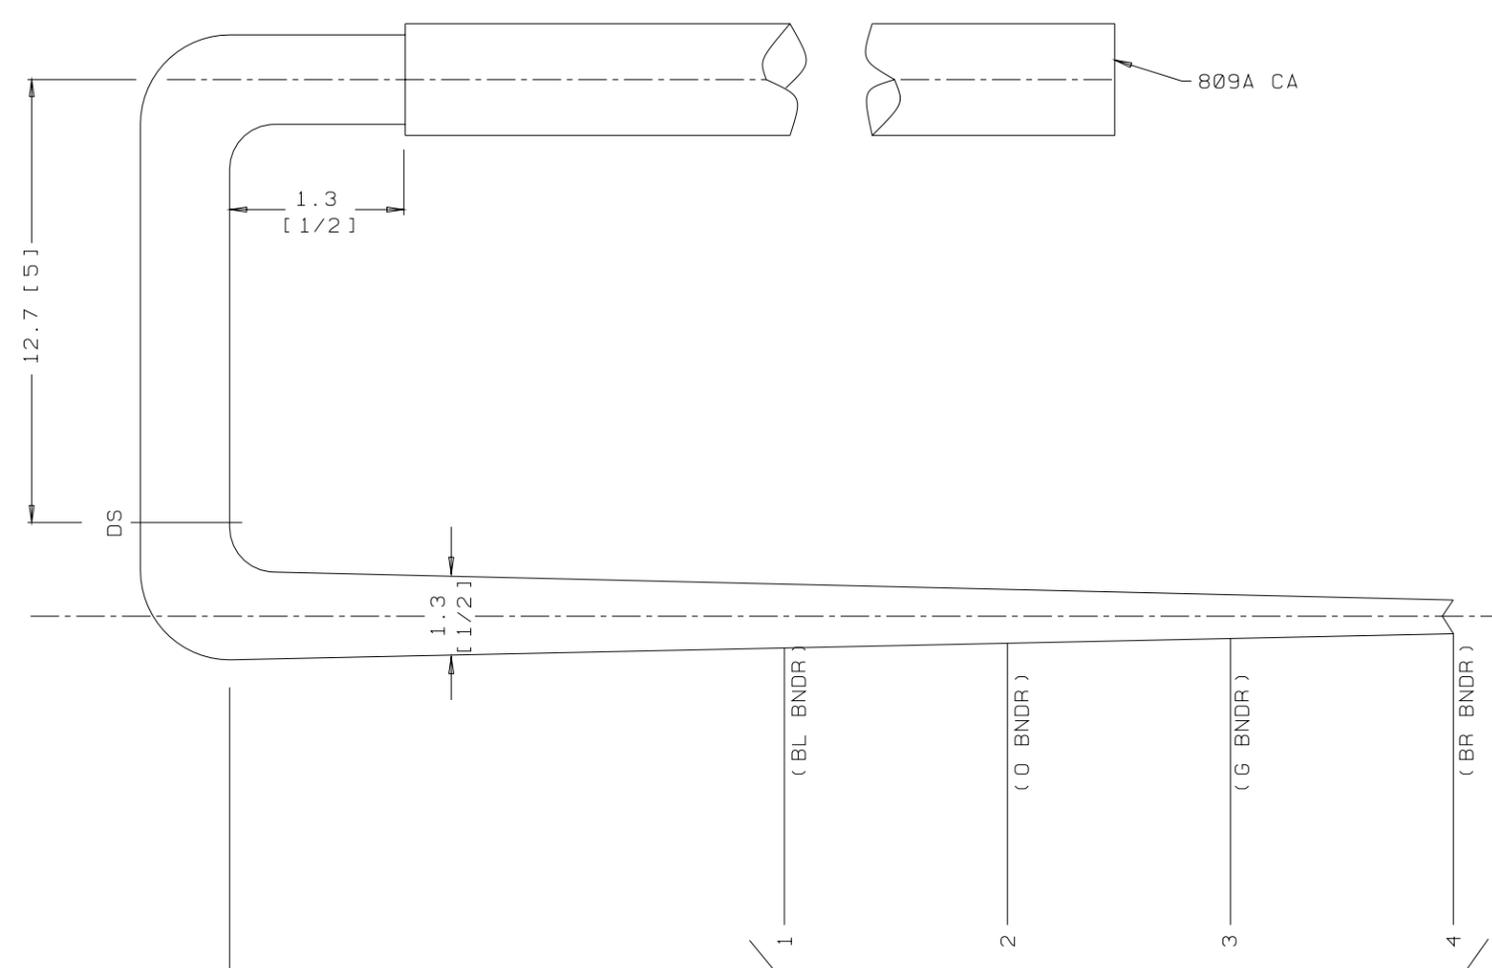


SK 26.7 [10 1/2] TO ARM ϕ
 (INCLUDES 25.4 [10] FOR MANUFACTURING PURPOSES)

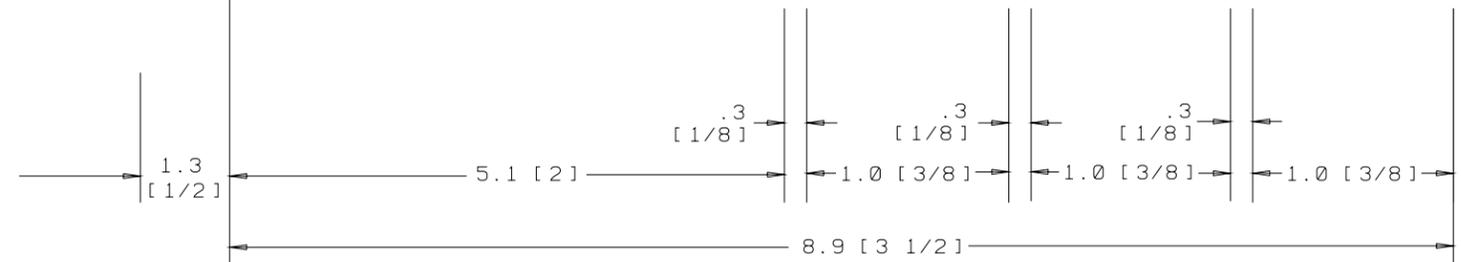

GROUP 265A
 CABLE FOR INTEGRATED SERVICES LINE UNIT (4-WIRE)
 LG 14
 END "A"

SEE PROPRIETARY NOTICE ON SHEET ONE		
CONNECTORIZED SWITCHBOARD CABLE ASSEMBLIES	DWG SIZE	ISSUE
	c2	49
LUCENT TECHNOLOGIES INC.	ED5D621-35	SHEET c72

ED5D621-35

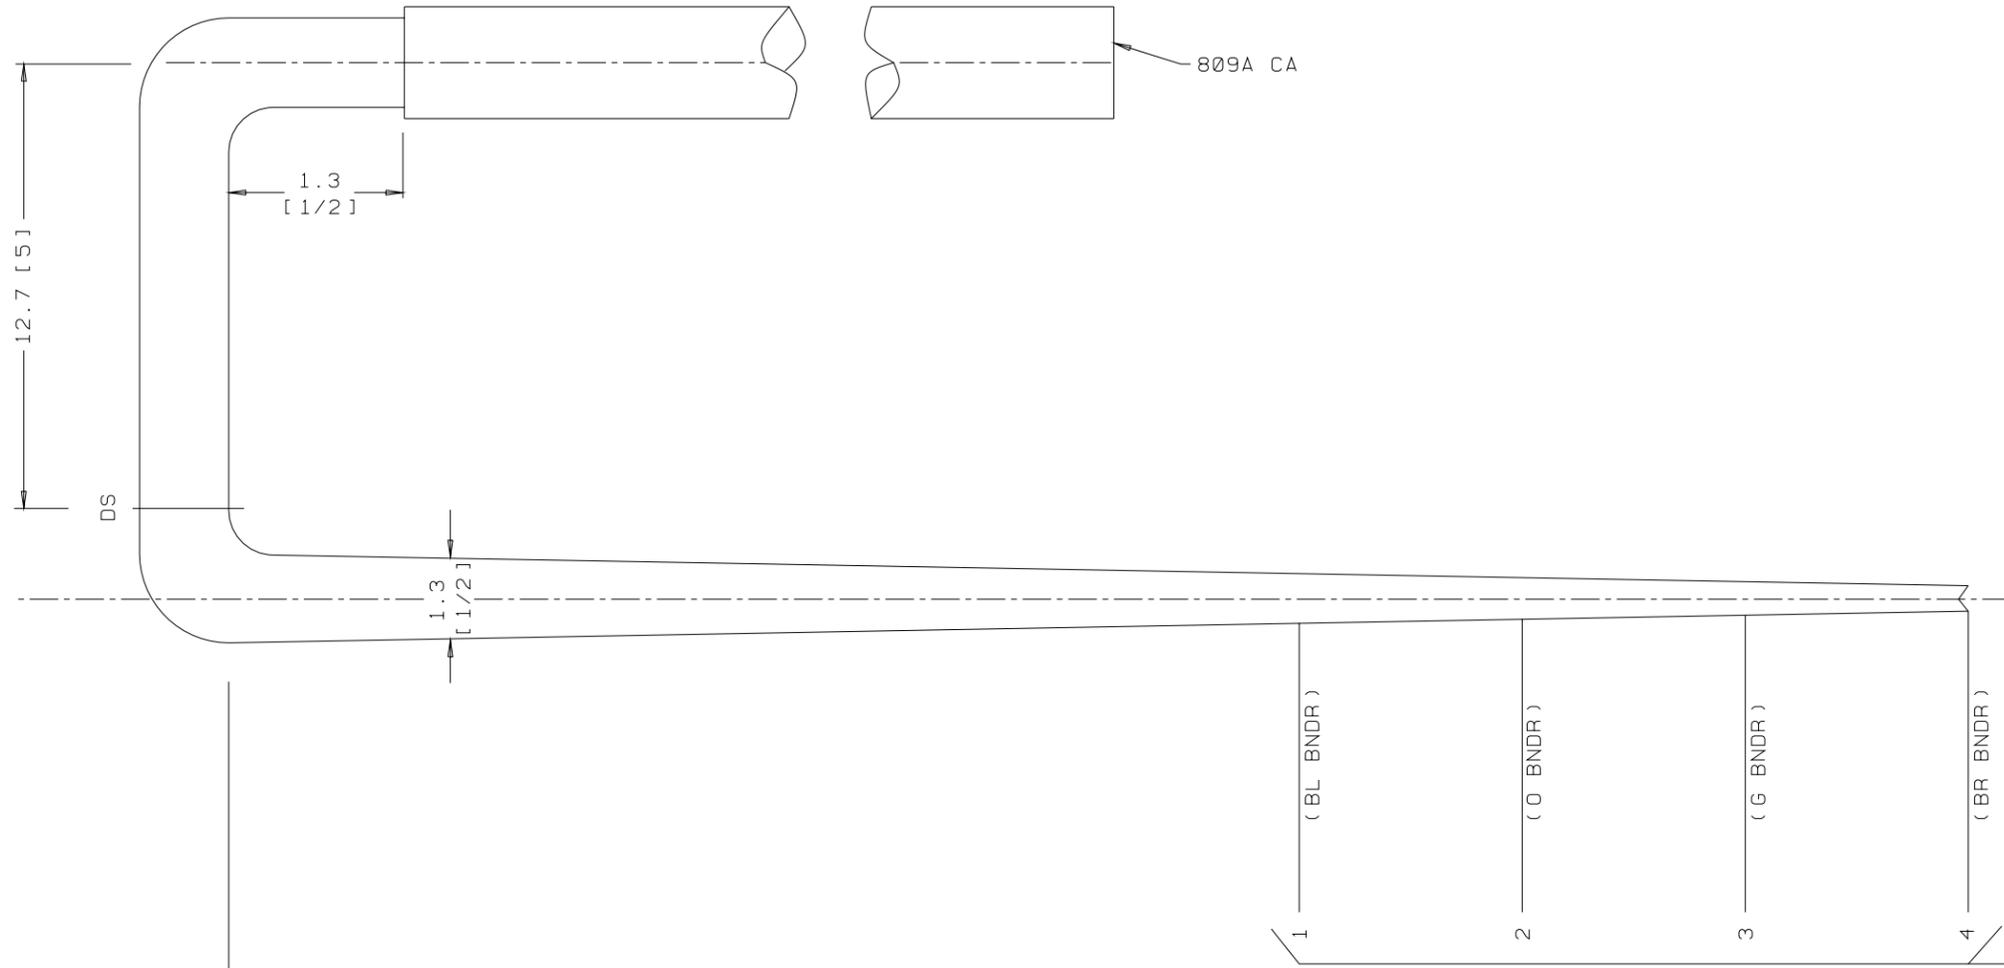


809A CA

12.7 [5]


1.3 [1/2]

DS

1.3 [1/2]

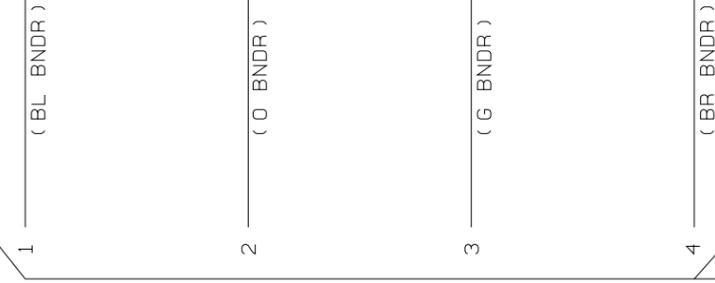

SK 26.7 [10 1/2] TO ARM C
(INCLUDES 25.4 [10] FOR MANUFACTURING PURPOSES)

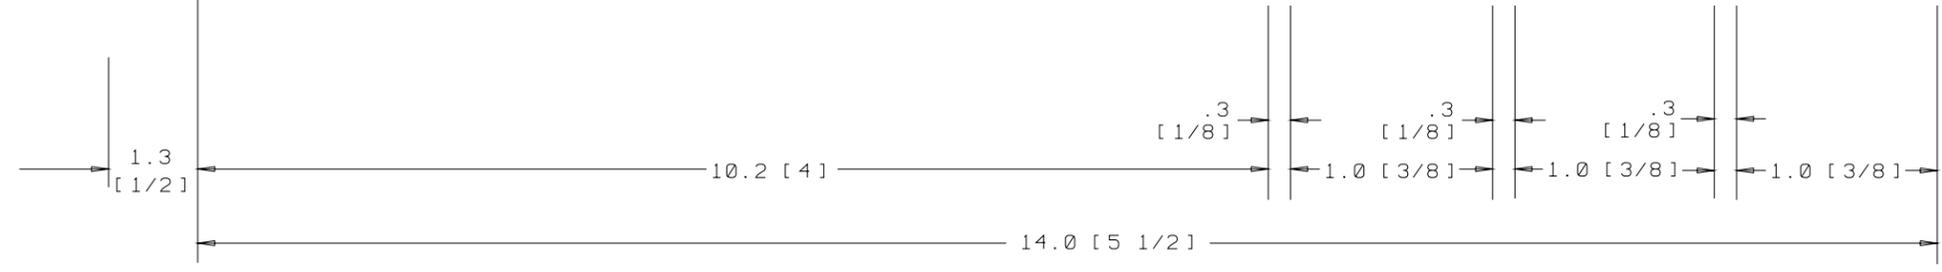

GROUP 266A
CABLE FOR INTEGRATED SERVICES LINE UNIT (4-WIRE)
LG 15
END "A"

SEE PROPRIETARY NOTICE ON SHEET ONE		
CONNECTORIZED SWITCHBOARD CABLE ASSEMBLIES		
DWG SIZE c2	ISSUE 49	
LUCENT TECHNOLOGIES INC.	ED5D621-35	SHEET c73

ED5D621-35

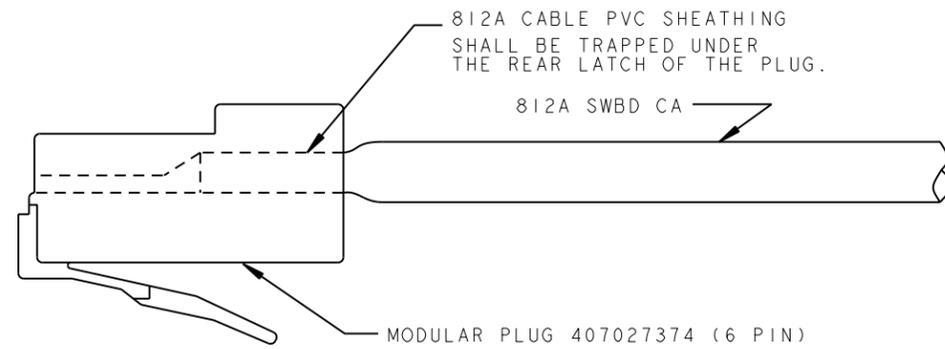
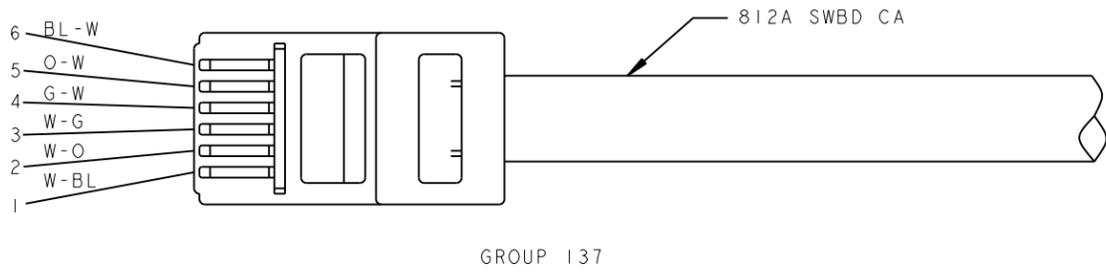
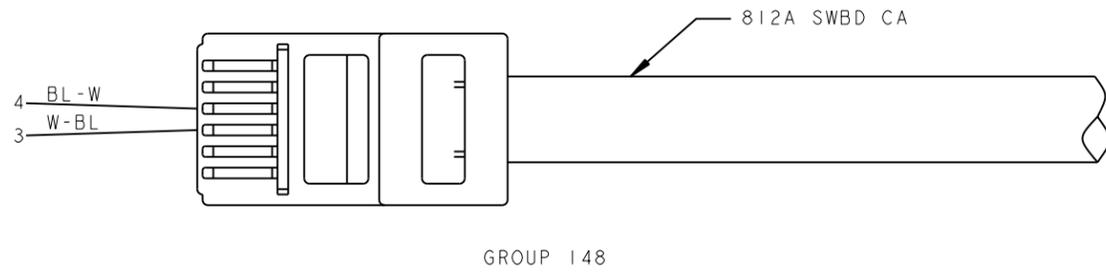


FIG.C
GROUP 137, 148
CONNECTING INFORMATION FOR MODULAR PLUG
940-SP-3066R (6 PIN)




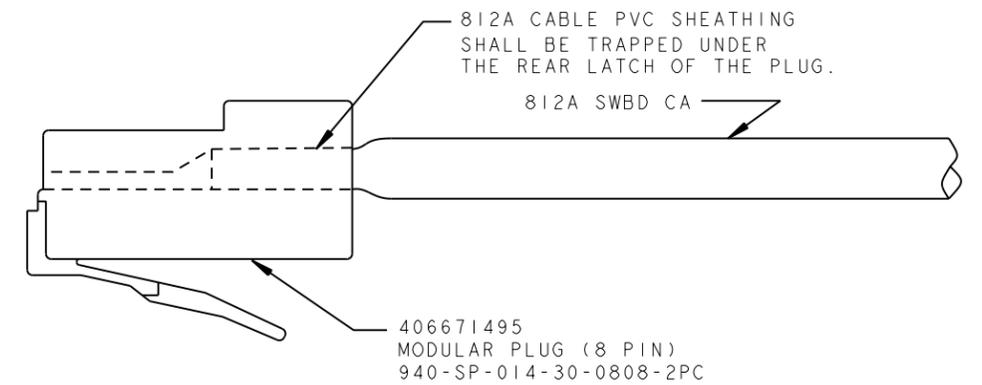


FIG.D
GROUP 138, 138B
CONNECTING INFORMATION FOR MODULAR PLUG

PROJ-EGEDFORM. FRM-FEB 96

ED5D621-35

FOR PROPRIETARY NOTICE SEE SHEET A1		THIRD ANGLE PROJ	
CONNECTORIZED SWITCHBOARD CABLE ASSEMBLIES			
DWG SIZE C2		ISSUE 53	
LUCENT TECHNOLOGIES		SHEET NO. C74	
ED5D621-35		MODEL NAME	

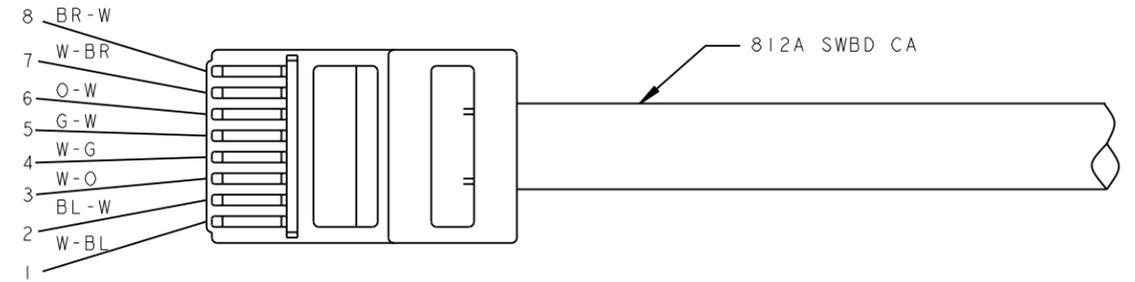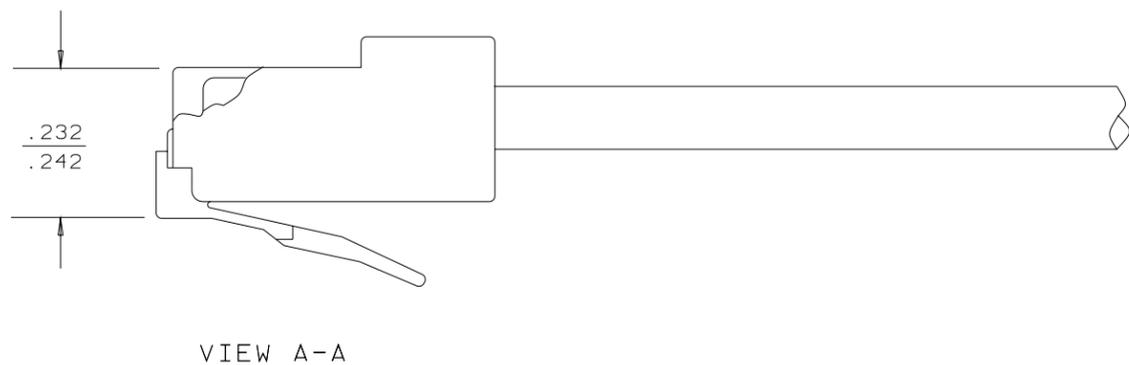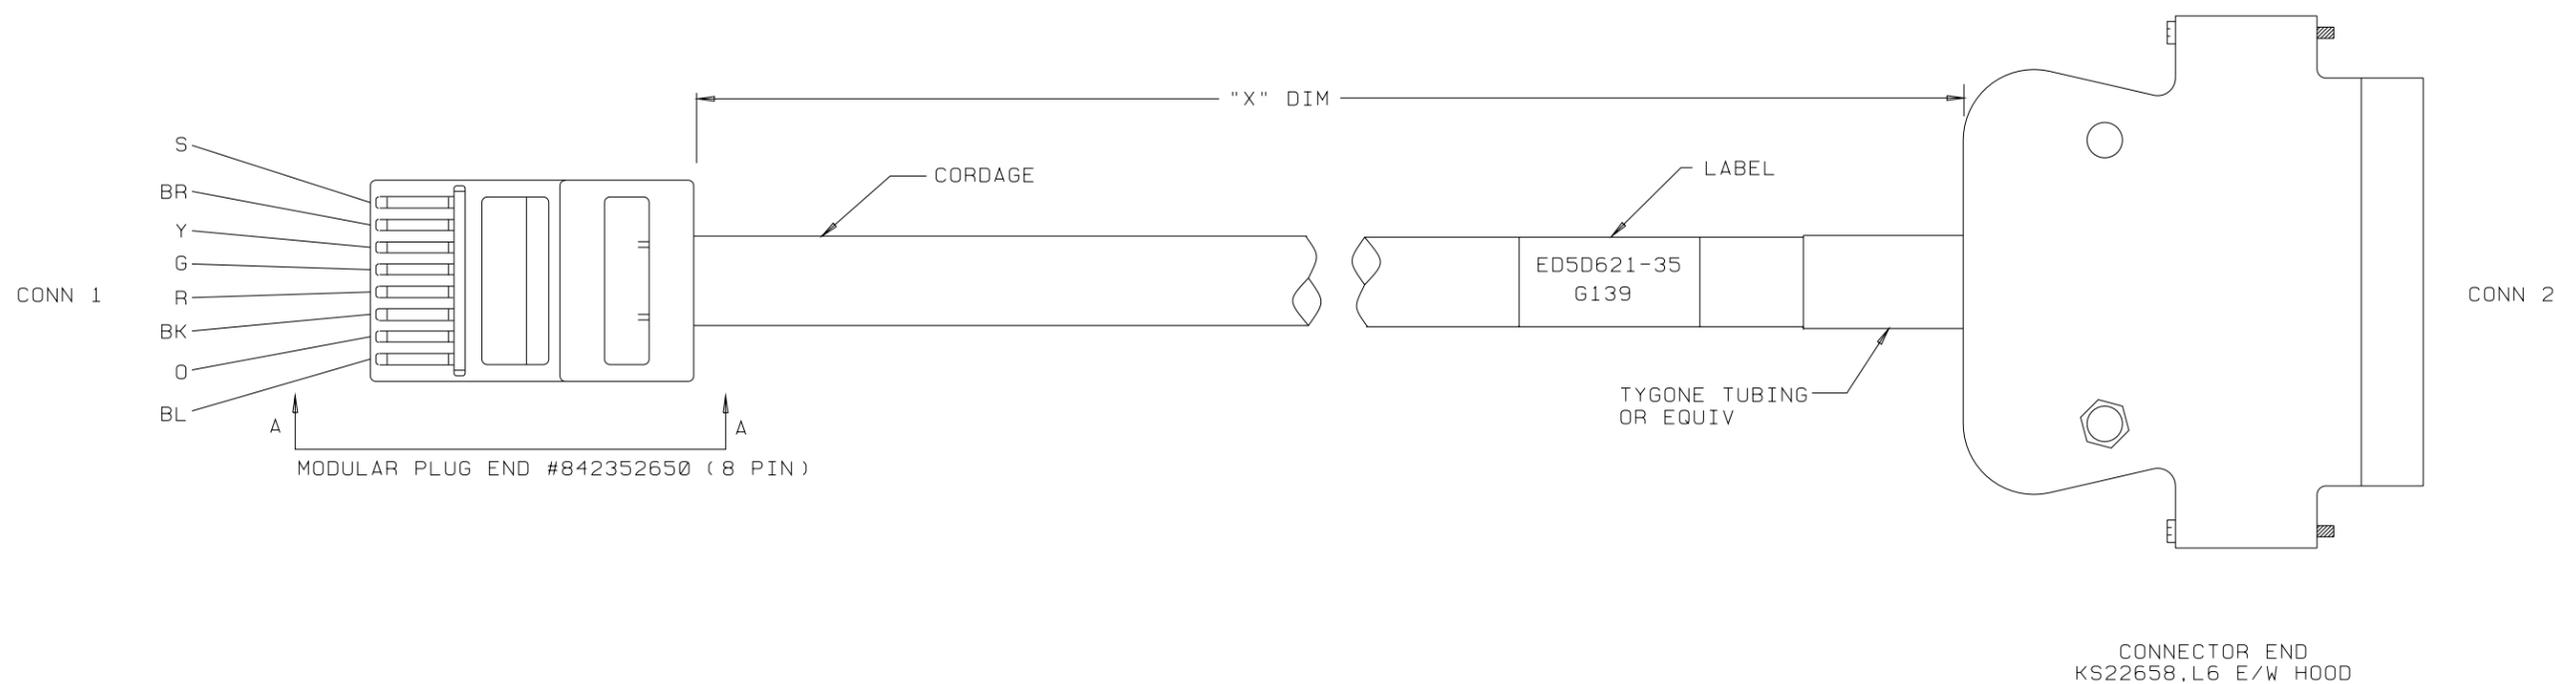

CONNECTING TABLE		
WIRE COLOR	CONNECTOR 1	CONNECTOR 2
	MOD PLUG CONNECTOR	KS22658.L6 CONNECTOR
BL		
O		
BK		
R	10.2 [4]	20.3 [8]
G	12.7 [5]	17.8 [7]
Y		
BR		
S		


GROUP 139

ED5D621-35


SEE PROPRIETARY NOTICE ON SHEET ONE		
CONNECTORIZED SWITCHBOARD CABLE ASSEMBLIES		
	DWG SIZE c2	ISSUE 49
LUCENT TECHNOLOGIES INC.	ED5D621-35	SHEET C75

NOTE: GRP 145A, 145B, AND 145C FOR USE WITH AT&T 615 TERMINAL.

GRP 146A, 146B, AND 146C FOR USE WITH AT&T MODEM.

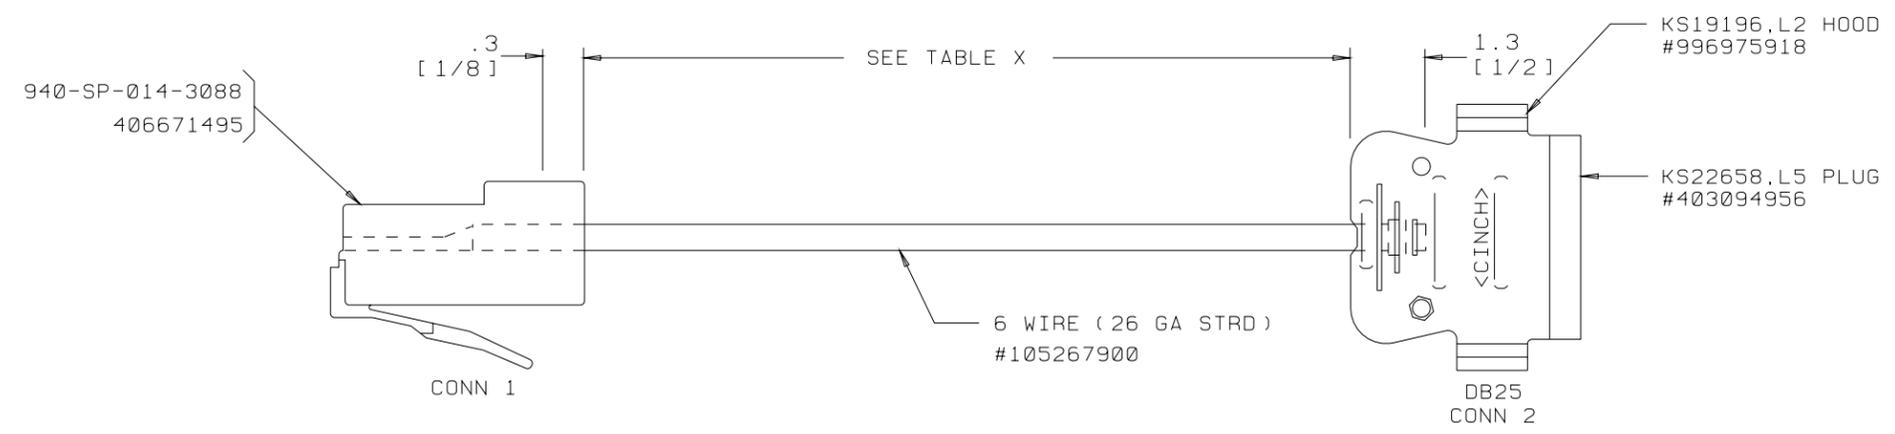

CONN 1	
TERM	COLOR
1	BK
2	W
3	R
4	NC
5	G
6	BR
7	BL
8	NC

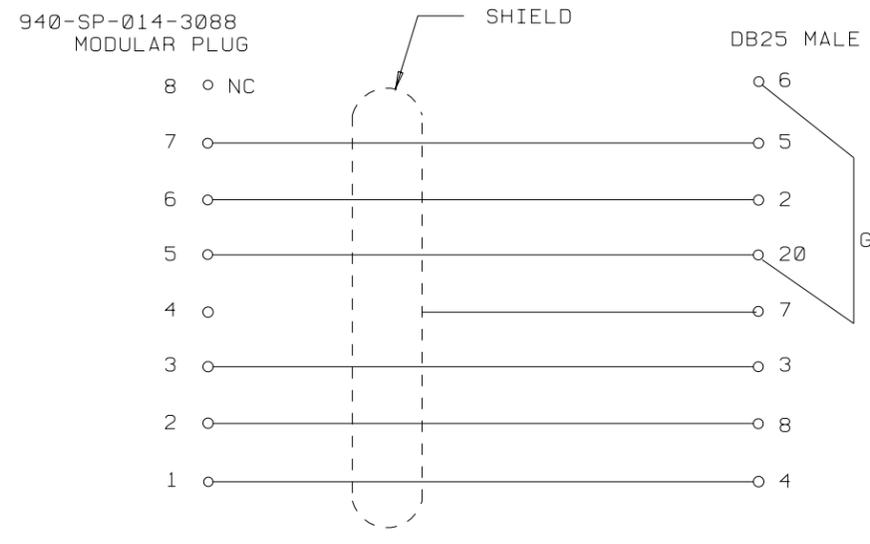


GROUP 145A, 145B, 145C

CONN 2 DB25			
TERM	COLOR	TERM	COLOR
1		14	
2	BR	15	
3	R	16	
4	BK	17	
5	BL	18	
6		19	
7	SH GRD	20	G
8	W	21	
9		22	
10		23	
11		24	
12		25	
13			

TABLE X	
GROUP	LENGTH
145A & 146A	213.4 [7 FT]
145B & 146B	762.0 [25 FT]
145C & 146C	1524.0 [50 FT]





CONN 1	
TERM	COLOR
1	BK
2	W
3	R
4	NC
5	G
6	BR
7	BL
8	NC

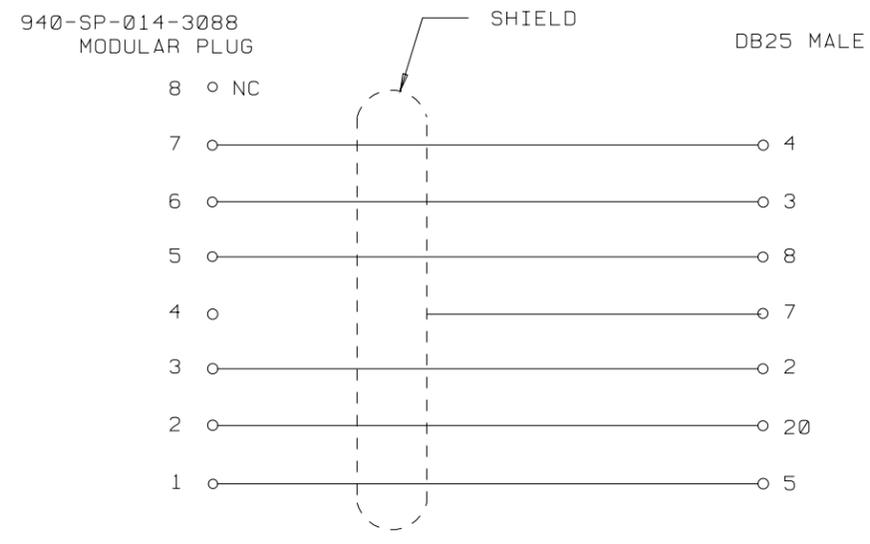

GROUP 146A, 146B, 146C

CONN 2 DB25			
TERM	COLOR	TERM	COLOR
1		14	
2	R	15	
3	BR	16	
4	BL	17	
5	BK	18	
6		19	
7	SH GRD	20	W
8	G	21	
9		22	
10		23	
11		24	
12		25	
13			

SEE PROPRIETARY NOTICE ON SHEET ONE		
CONNECTORIZED SWITCHBOARD CABLE ASSEMBLIES		DWG SIZE C2
LUCENT TECHNOLOGIES INC.		ISSUE 49
ED5D621-35		SHEET C76

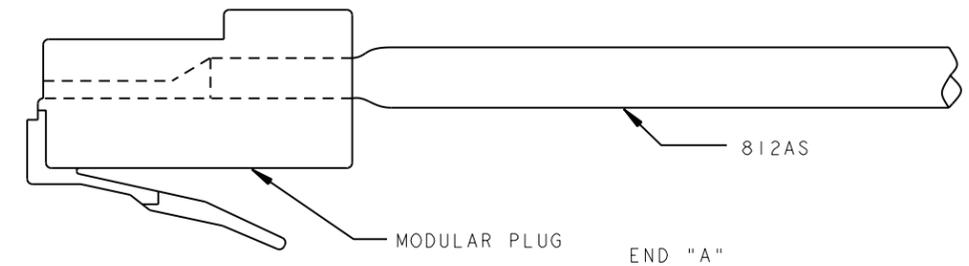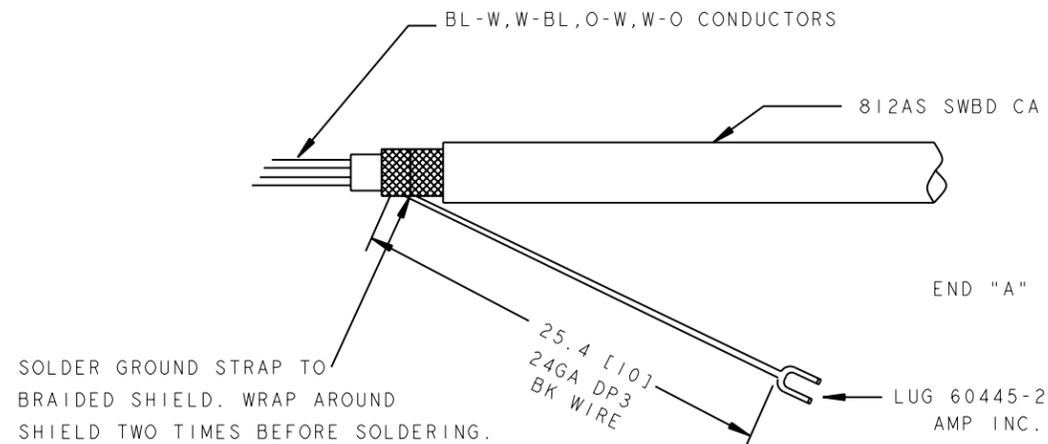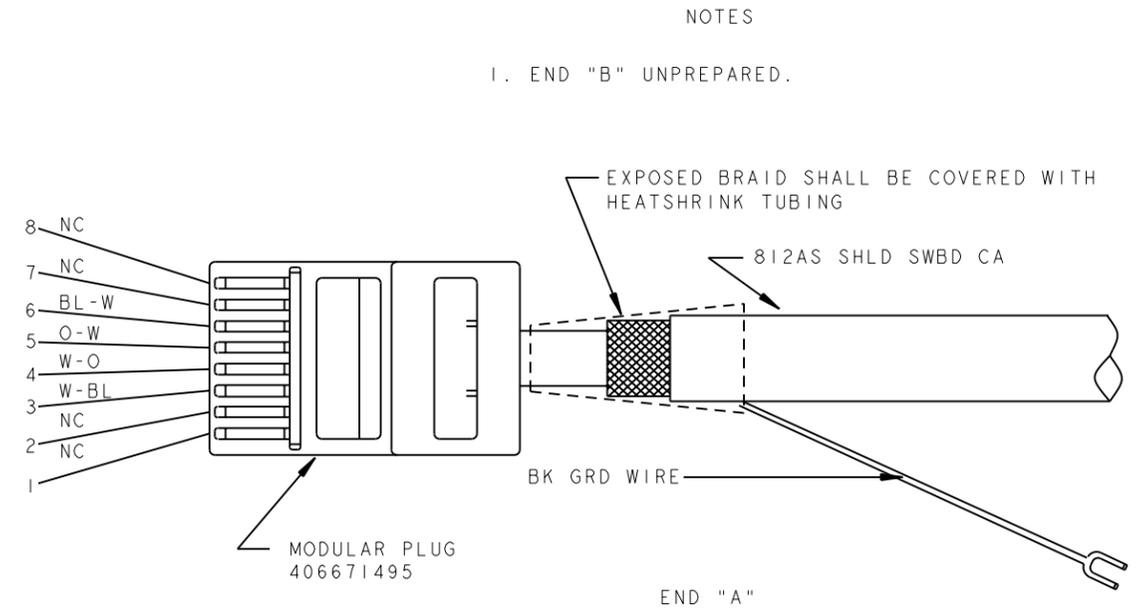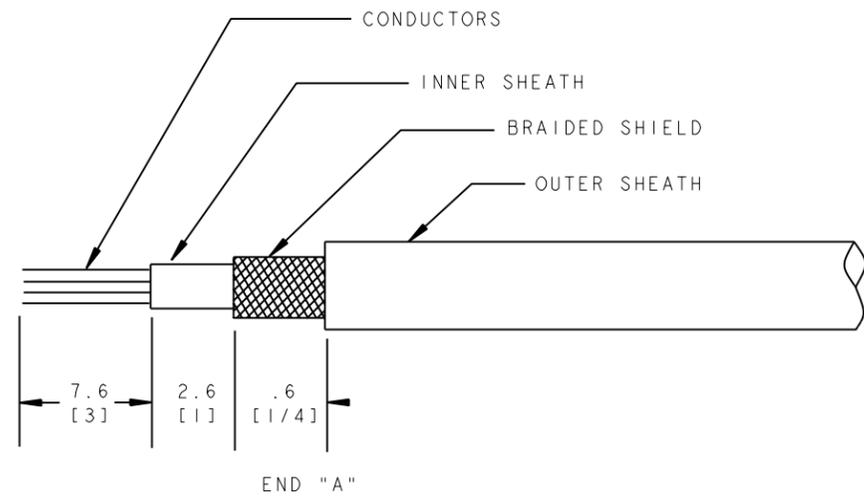

812AS CABLE PREPARATION
812AS CABLE SHALL BE STRIPPED AND GRD WIRE E/W FORKED LUG ATTACHED AS SHOWN. WIRE COLOR NOT INDICATED SHALL BE CUT BACK TO CABLE BUTT.

TABLE S			
GROUP	CABLE LENGTH	PREPARED CABLE LENGTH	NOTES
138A	"X" DIM	"X" DIM + 2.5 [1]	1


FIG. E
GROUP 138A

FOR PROPRIETARY NOTICE SEE SHEET A1		THIRD ANGLE PROJ	
CONNECTORIZED SWITCHBOARD CABLE ASSEMBLIES			
DWG SIZE C2		ISSUE 53	
LUCENT TECHNOLOGIES		ED5D621-35	SHEET NO. C77
MODEL NAME			

ED5D621-35

PROJ-EGEDFORM. FRM-FEB 96


SK 26.7 [10 1/2] TO ARM ϕ (INCLUDES 25.4 [10] FOR MANUFACTURING PURPOSES)

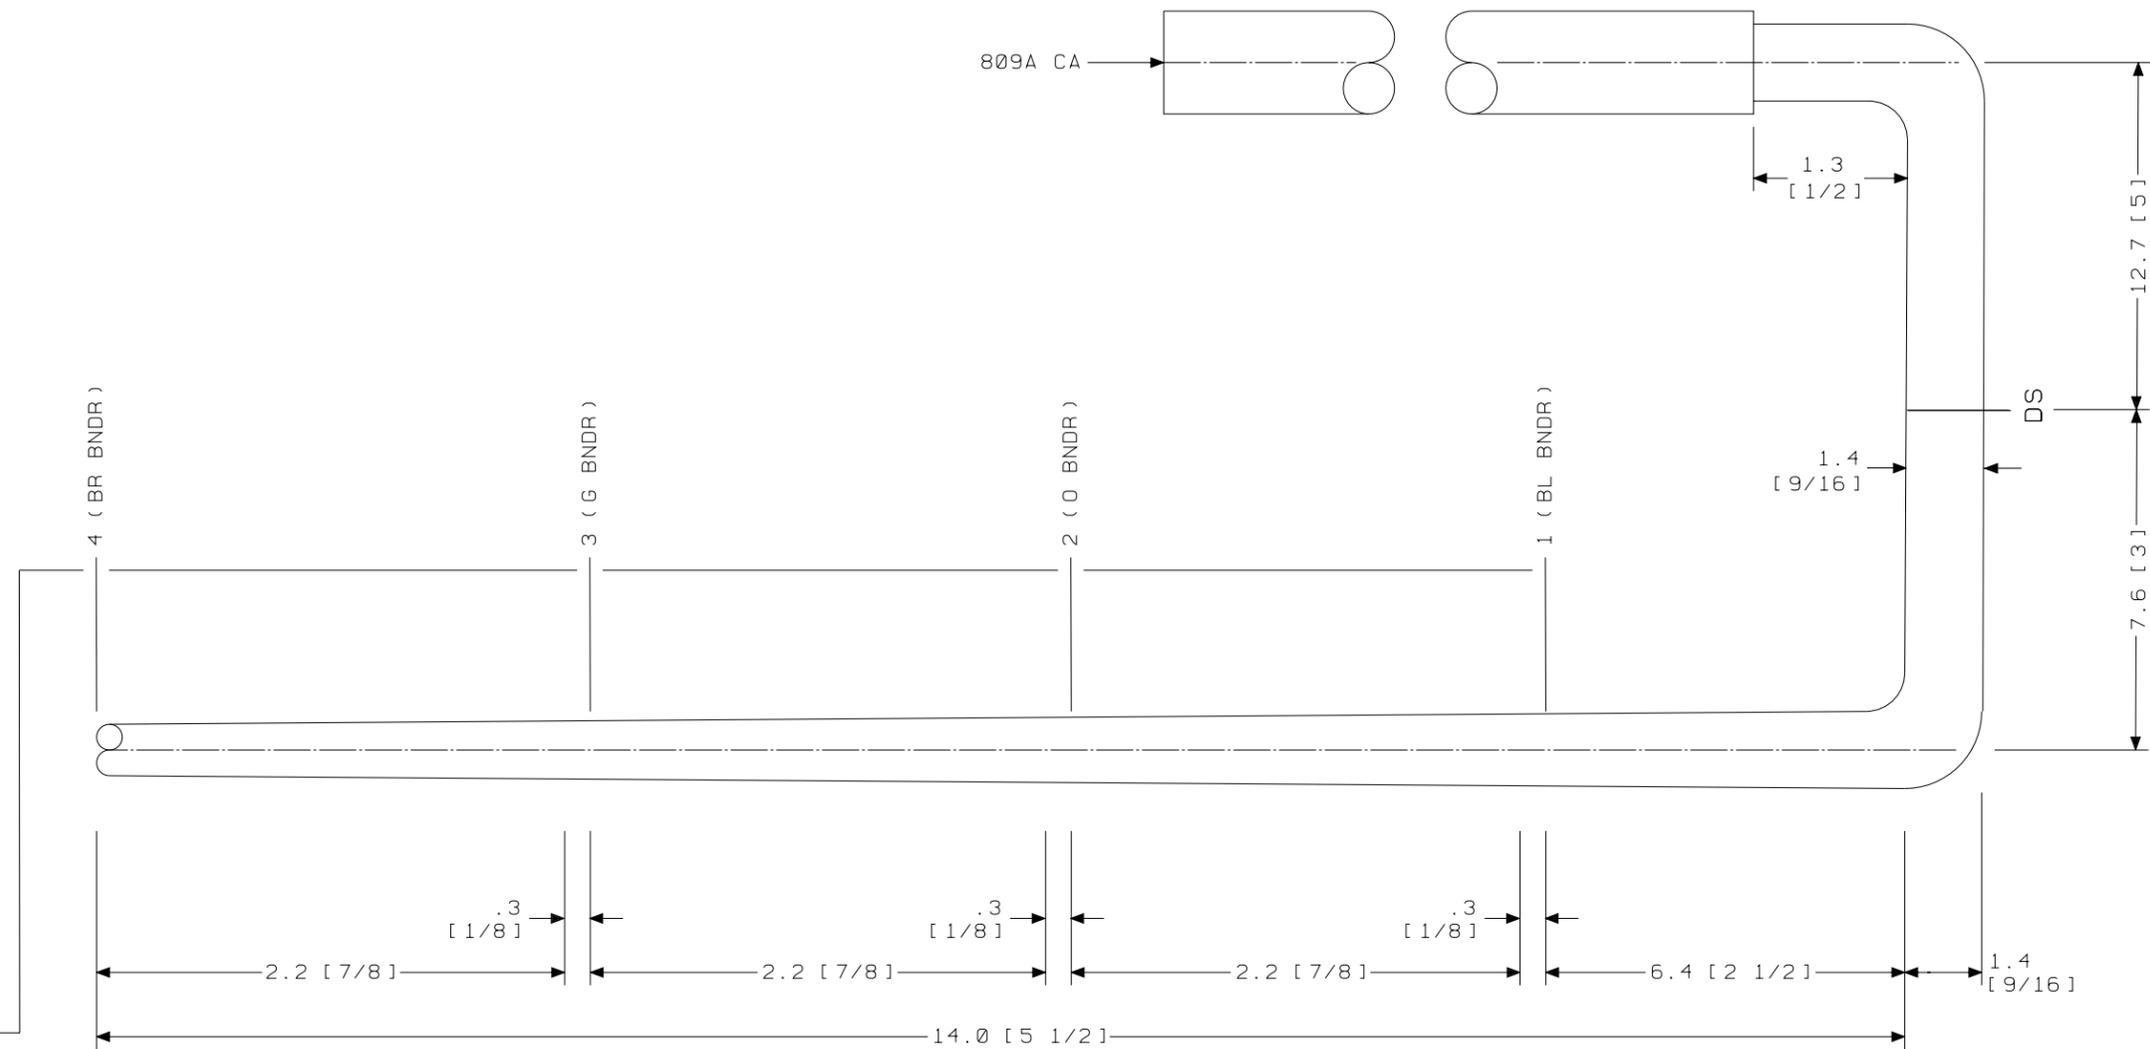

GROUP 221C
 CABLE FOR INTEGRATED SERVICES LINE UNIT (2-WIRE)
 LG 0.1
 END " A "

SEE PROPRIETARY NOTICE ON SHEET ONE		
CONNECTORIZED SWITCHBOARD CABLE ASSEMBLIES		
	DWG SIZE c2	ISSUE 49
LUCENT TECHNOLOGIES INC.	ED5D621-35	SHEET c78


SK 26.7 [10 1/2] TO ARM C (INCLUDES 25.4 [10] FOR MANUFACTURING PURPOSES)

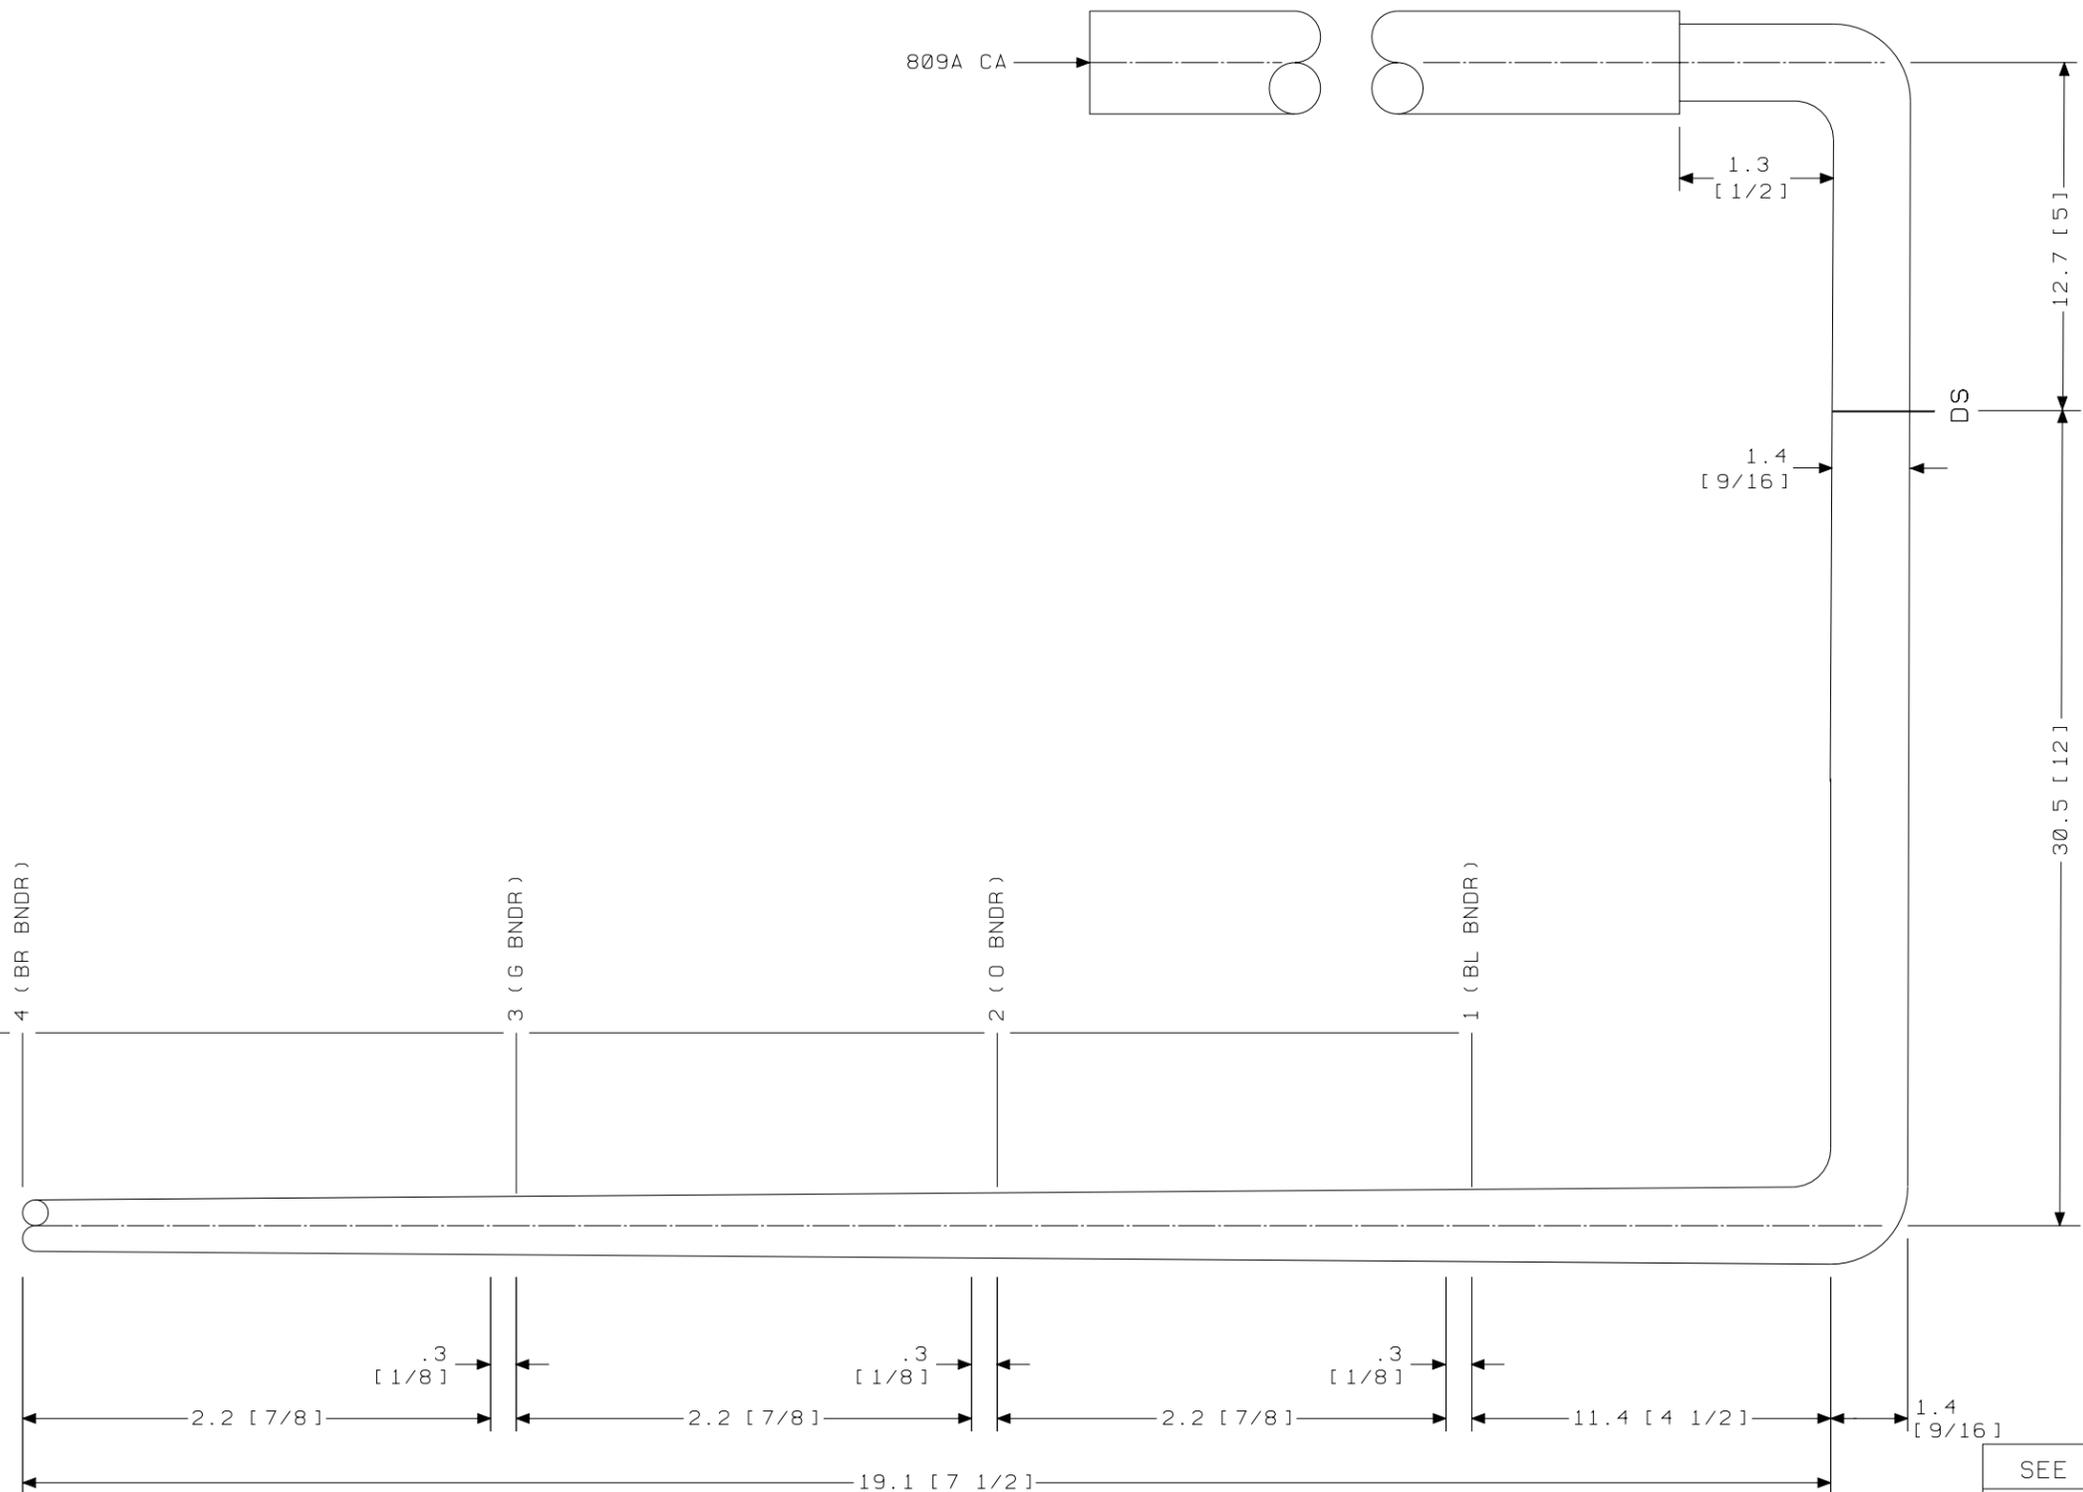

GROUP 223D
 CABLE FOR INTEGRATED SERVICES LINE UNIT (2-WIRE)
 LG 6.7
 END "A"

SEE PROPRIETARY NOTICE ON SHEET ONE		
CONNECTORIZED SWITCHBOARD CABLE ASSEMBLIES		
DWG SIZE C2	ISSUE 49	
LUCENT TECHNOLOGIES INC.	ED5D621-35	SHEET C81

ED5D621-35

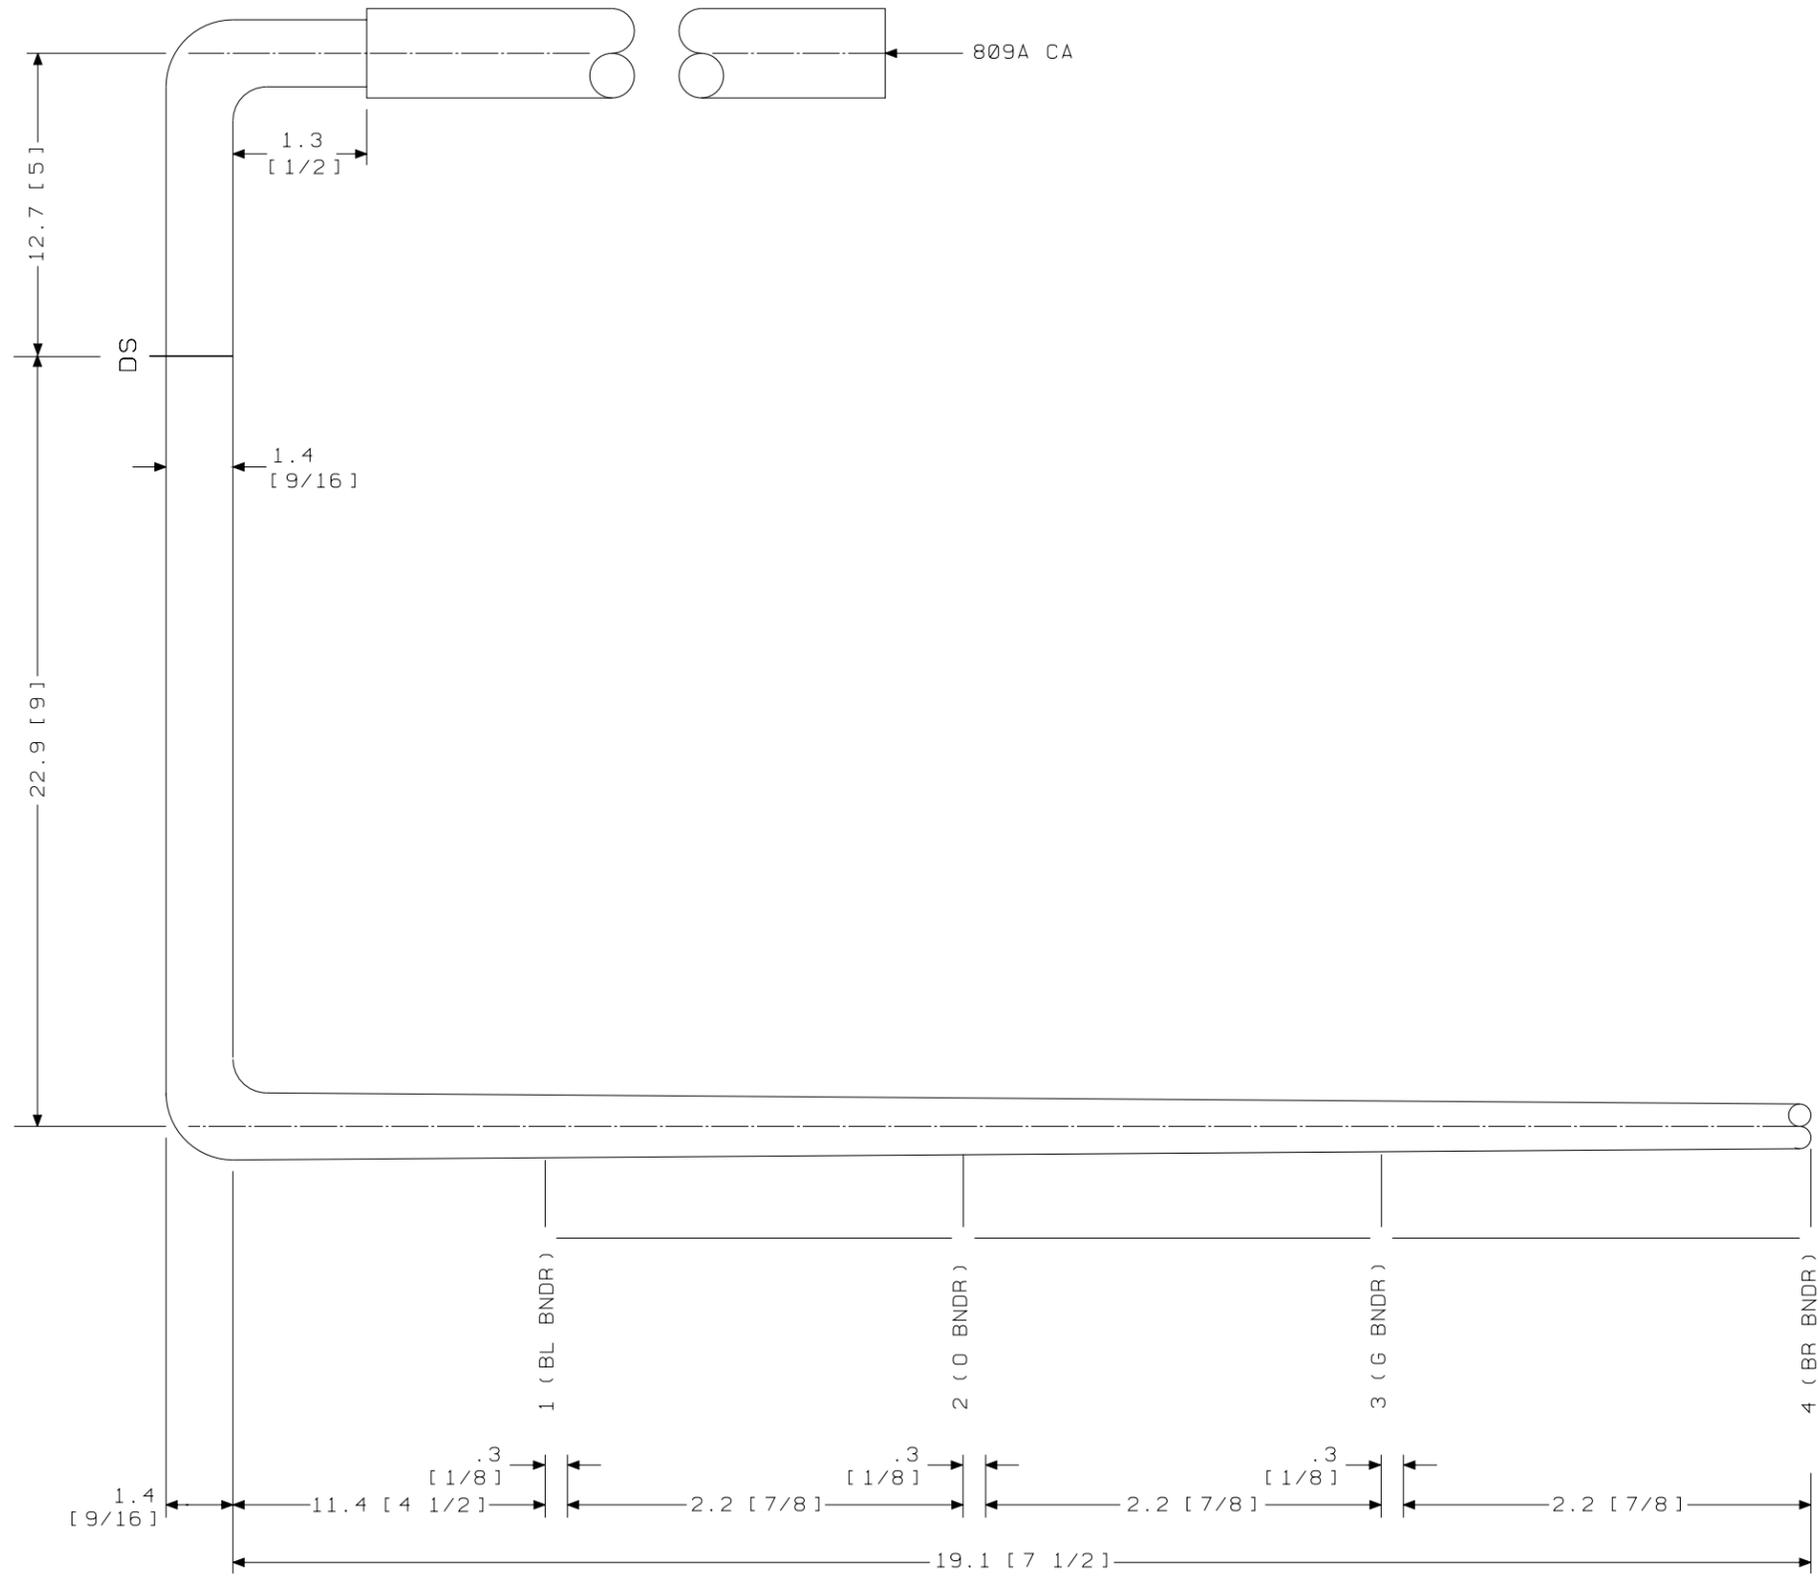

809A CA

DS

SK 26.7 [10 1/2] TO ARM C
(INCLUDES 25.4 [10] FOR MANUFACTURING PURPOSES)

1 (BL BNR)

2 (O BNR)

3 (G BNR)

4 (BR BNR)

1.4 [9/16]

.3 [1/8]

.3 [1/8]

.3 [1/8]

11.4 [4 1/2]

2.2 [7/8]

2.2 [7/8]

19.1 [7 1/2]

GROUP 222C
CABLE FOR INTEGRATED SERVICES LINE UNIT (2-WIRE)
LG 8.9
END "A"

SEE PROPRIETARY NOTICE ON SHEET ONE

CONNECTORIZED SWITCHBOARD
CABLE ASSEMBLIES

DWG SIZE
C2


ISSUE
49

LUCENT
TECHNOLOGIES INC.

ED5D621-35

SHEET
C82

ED5D621-35

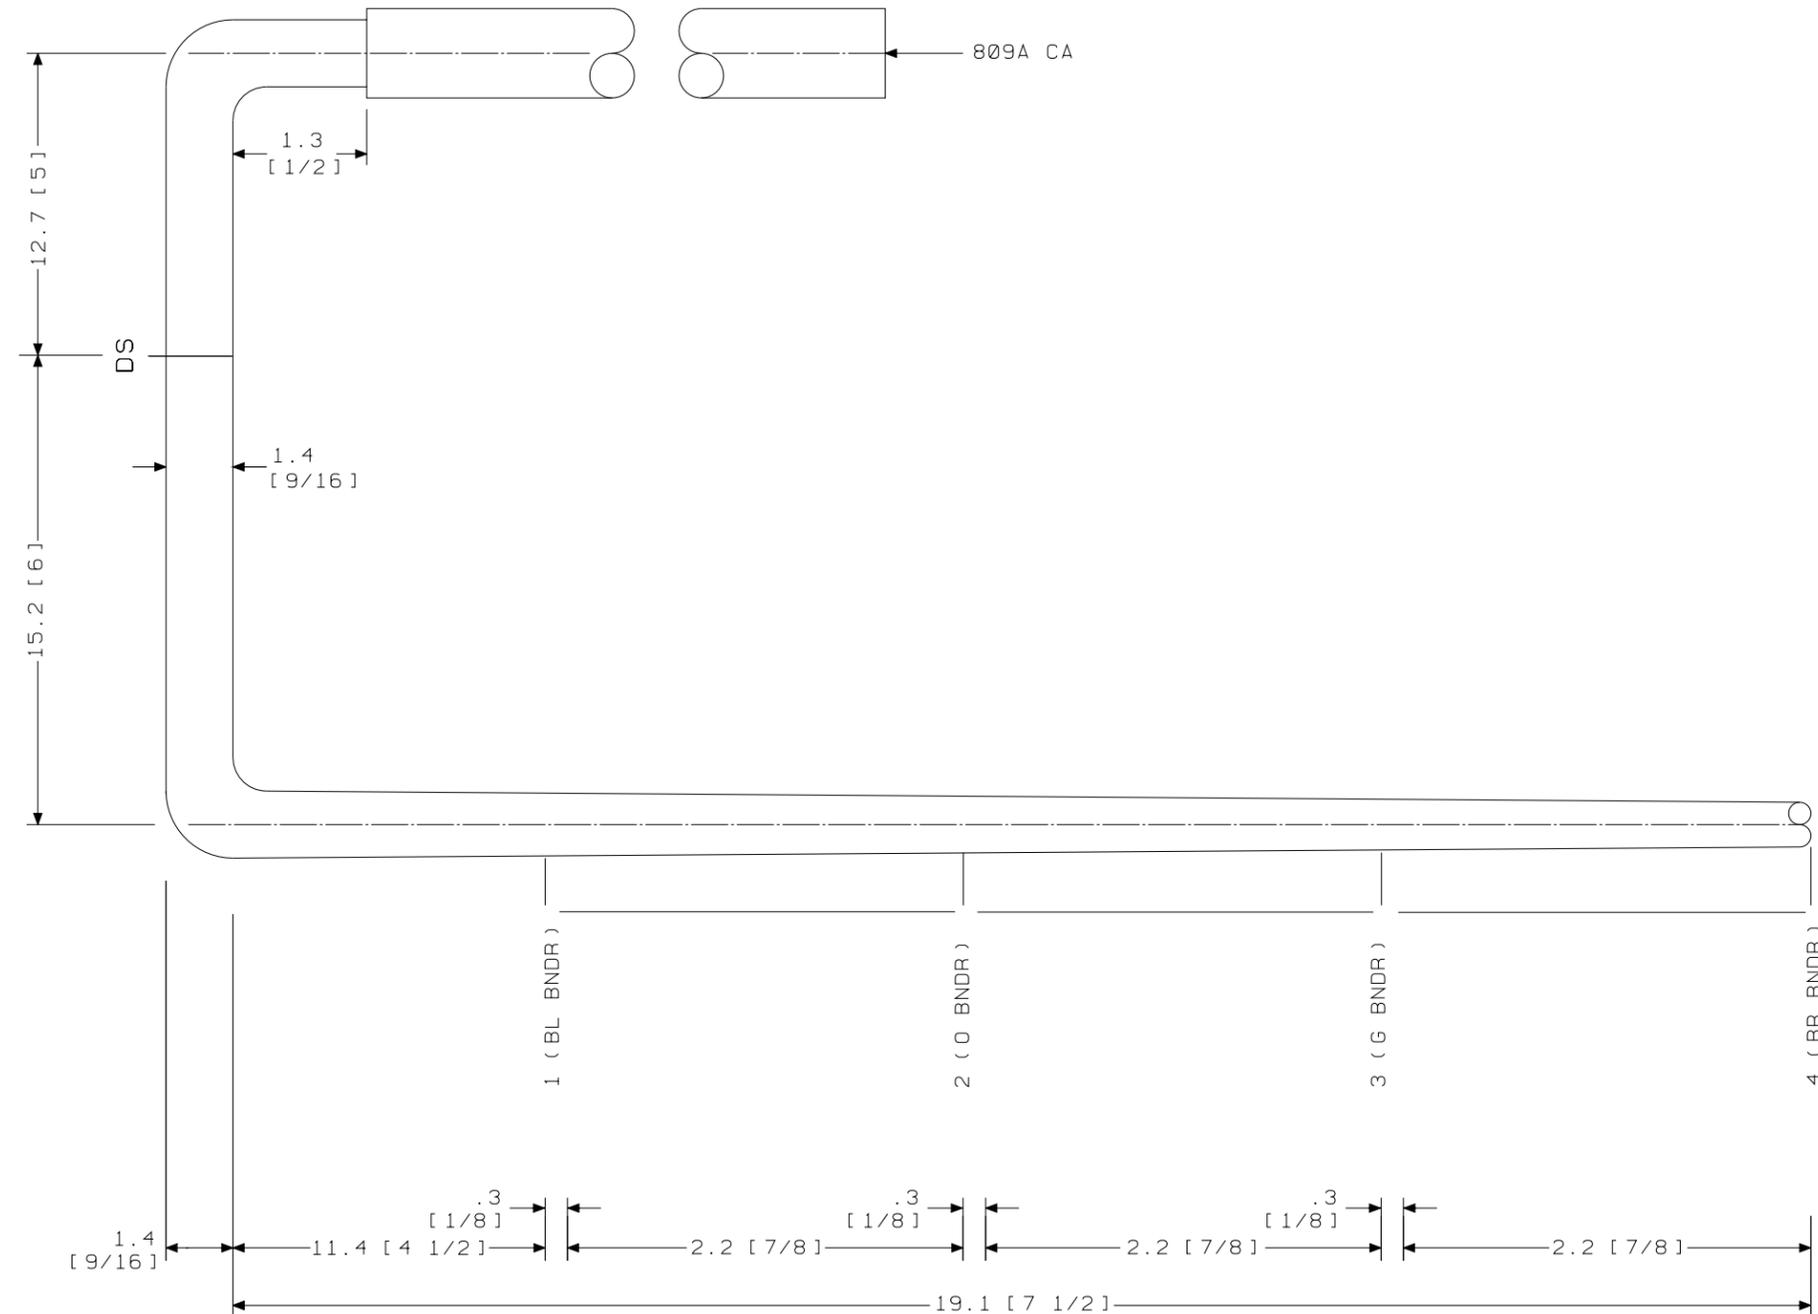

809A CA

DS

1 (BL BNR)

2 (O BNR)

3 (G BNR)


4 (BR BNR)

SK 26.7 [10 1/2] TO ARM C
(INCLUDES 25.4 [10] FOR MANUFACTURING PURPOSES)

GROUP 222D
CABLE FOR INTEGRATED SERVICES LINE UNIT (2-WIRE)
LG 10.11
END "A"

SEE PROPRIETARY NOTICE ON SHEET ONE		
CONNECTORIZED SWITCHBOARD CABLE ASSEMBLIES		
	DWG SIZE c2	ISSUE 49
LUCENT TECHNOLOGIES INC.	ED5D621-35	SHEET C83

ED5D621-35

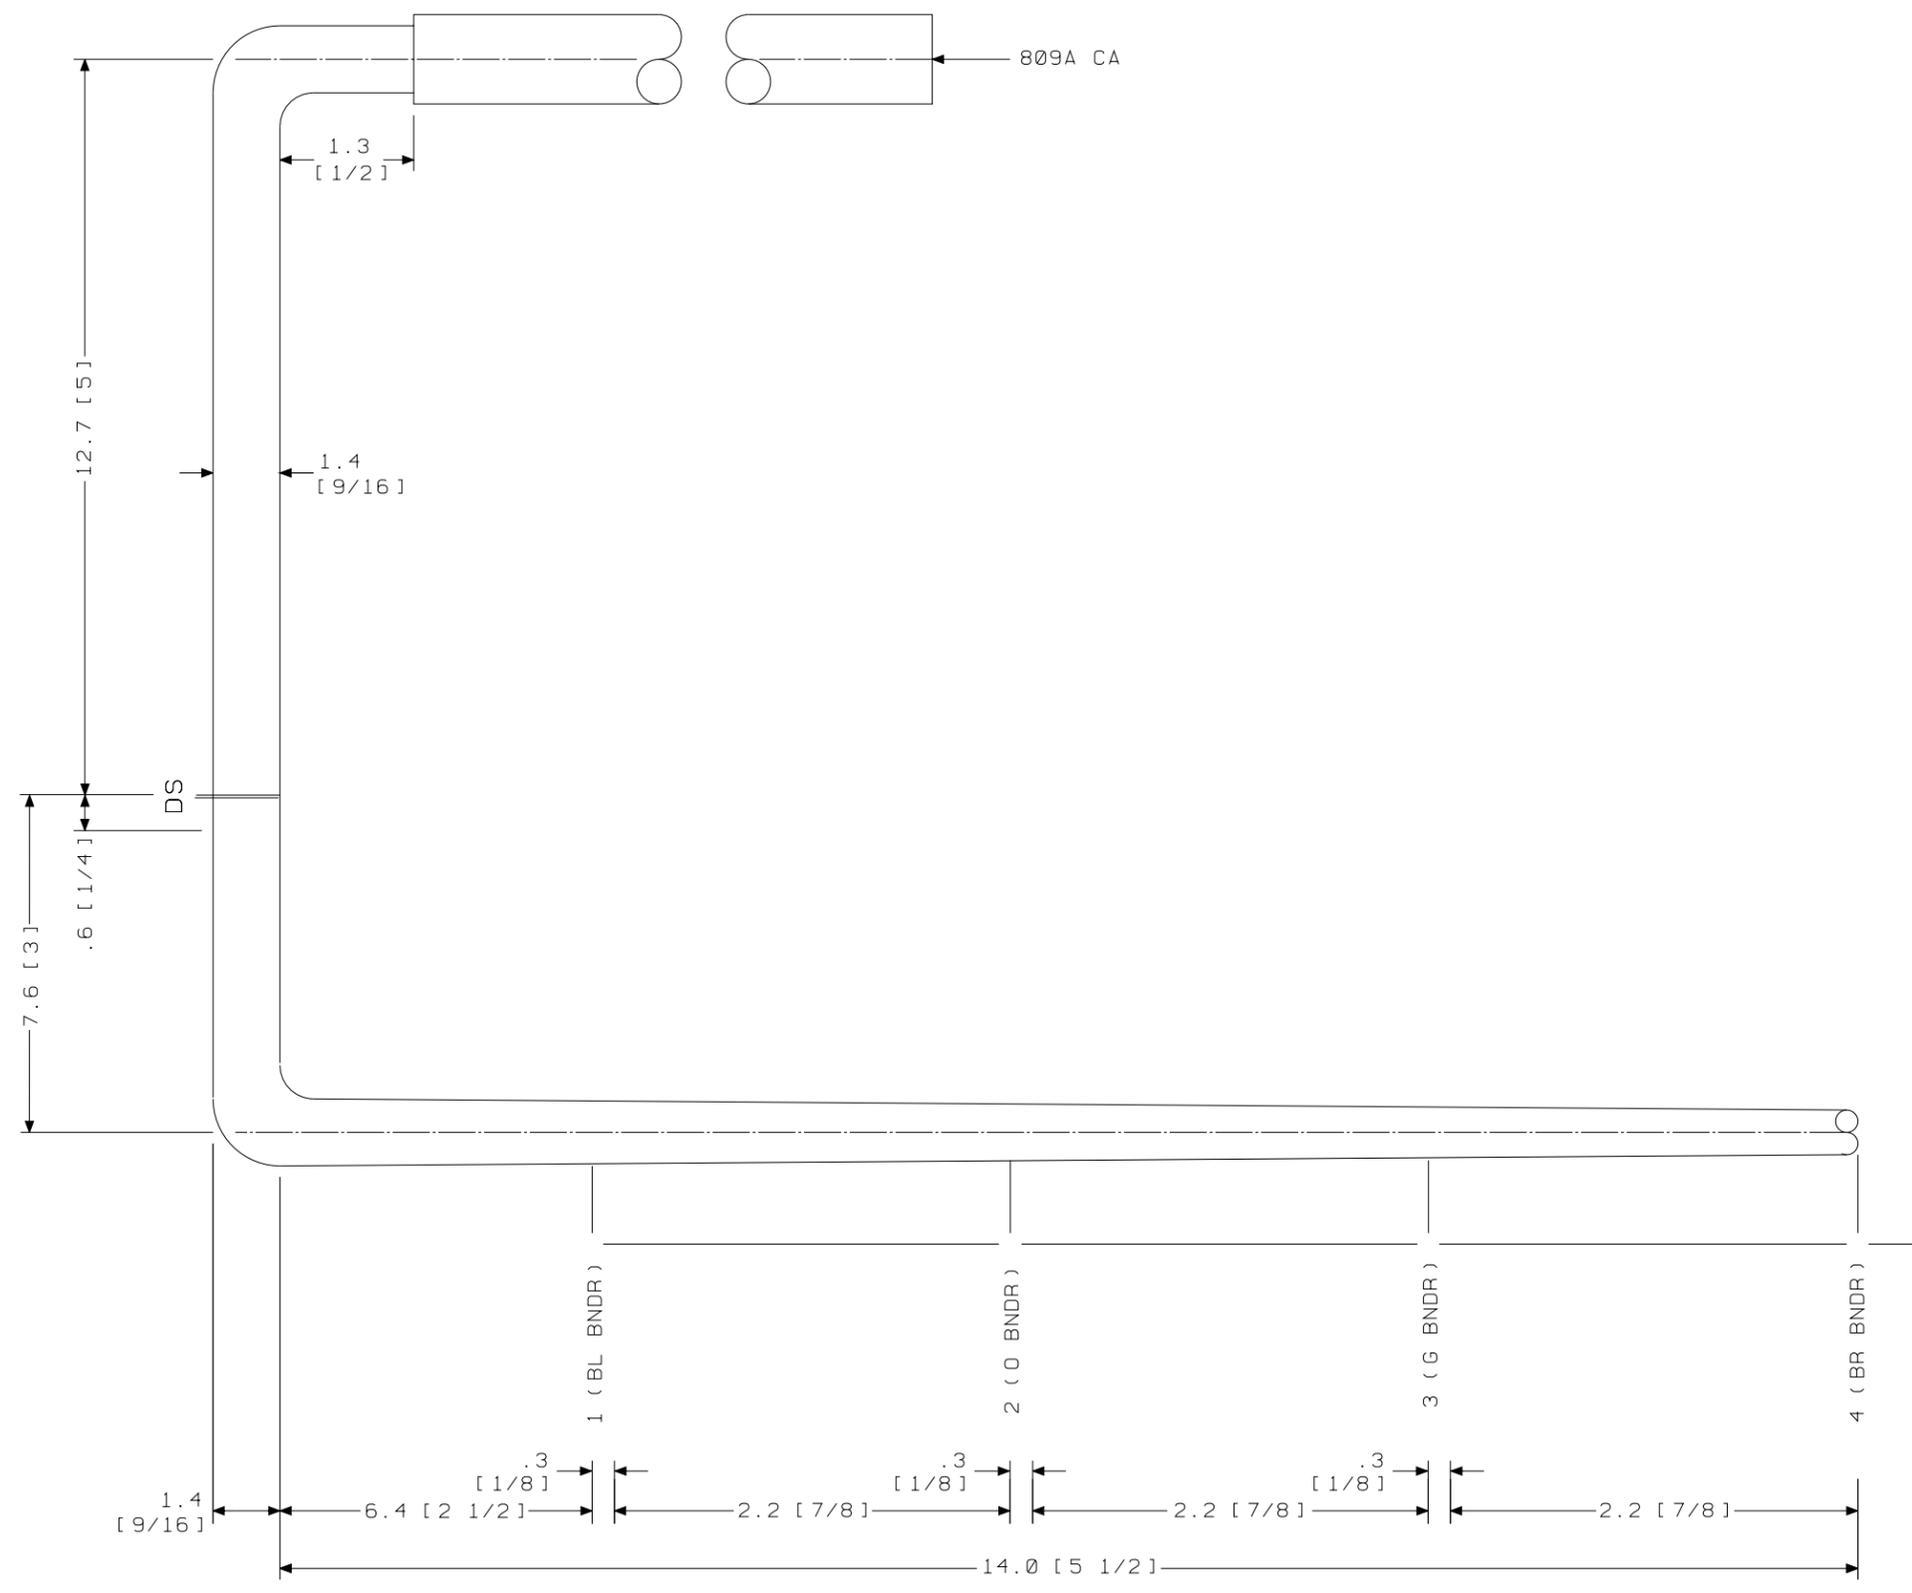


SK 26.7 [10 1/2] TO ARM C
 (INCLUDES 25.4 [10] FOR MANUFACTURING PURPOSES)

GROUP 224C
 CABLE FOR INTEGRATED SERVICES LINE UNIT (2-WIRE)
 LG 12.13
 END "A"

SEE PROPRIETARY NOTICE ON SHEET ONE		
CONNECTORIZED SWITCHBOARD CABLE ASSEMBLIES		DWG SIZE c2
LUCENT TECHNOLOGIES INC.		ISSUE 49
ED5D621-35		SHEET C84

ED5D621-35

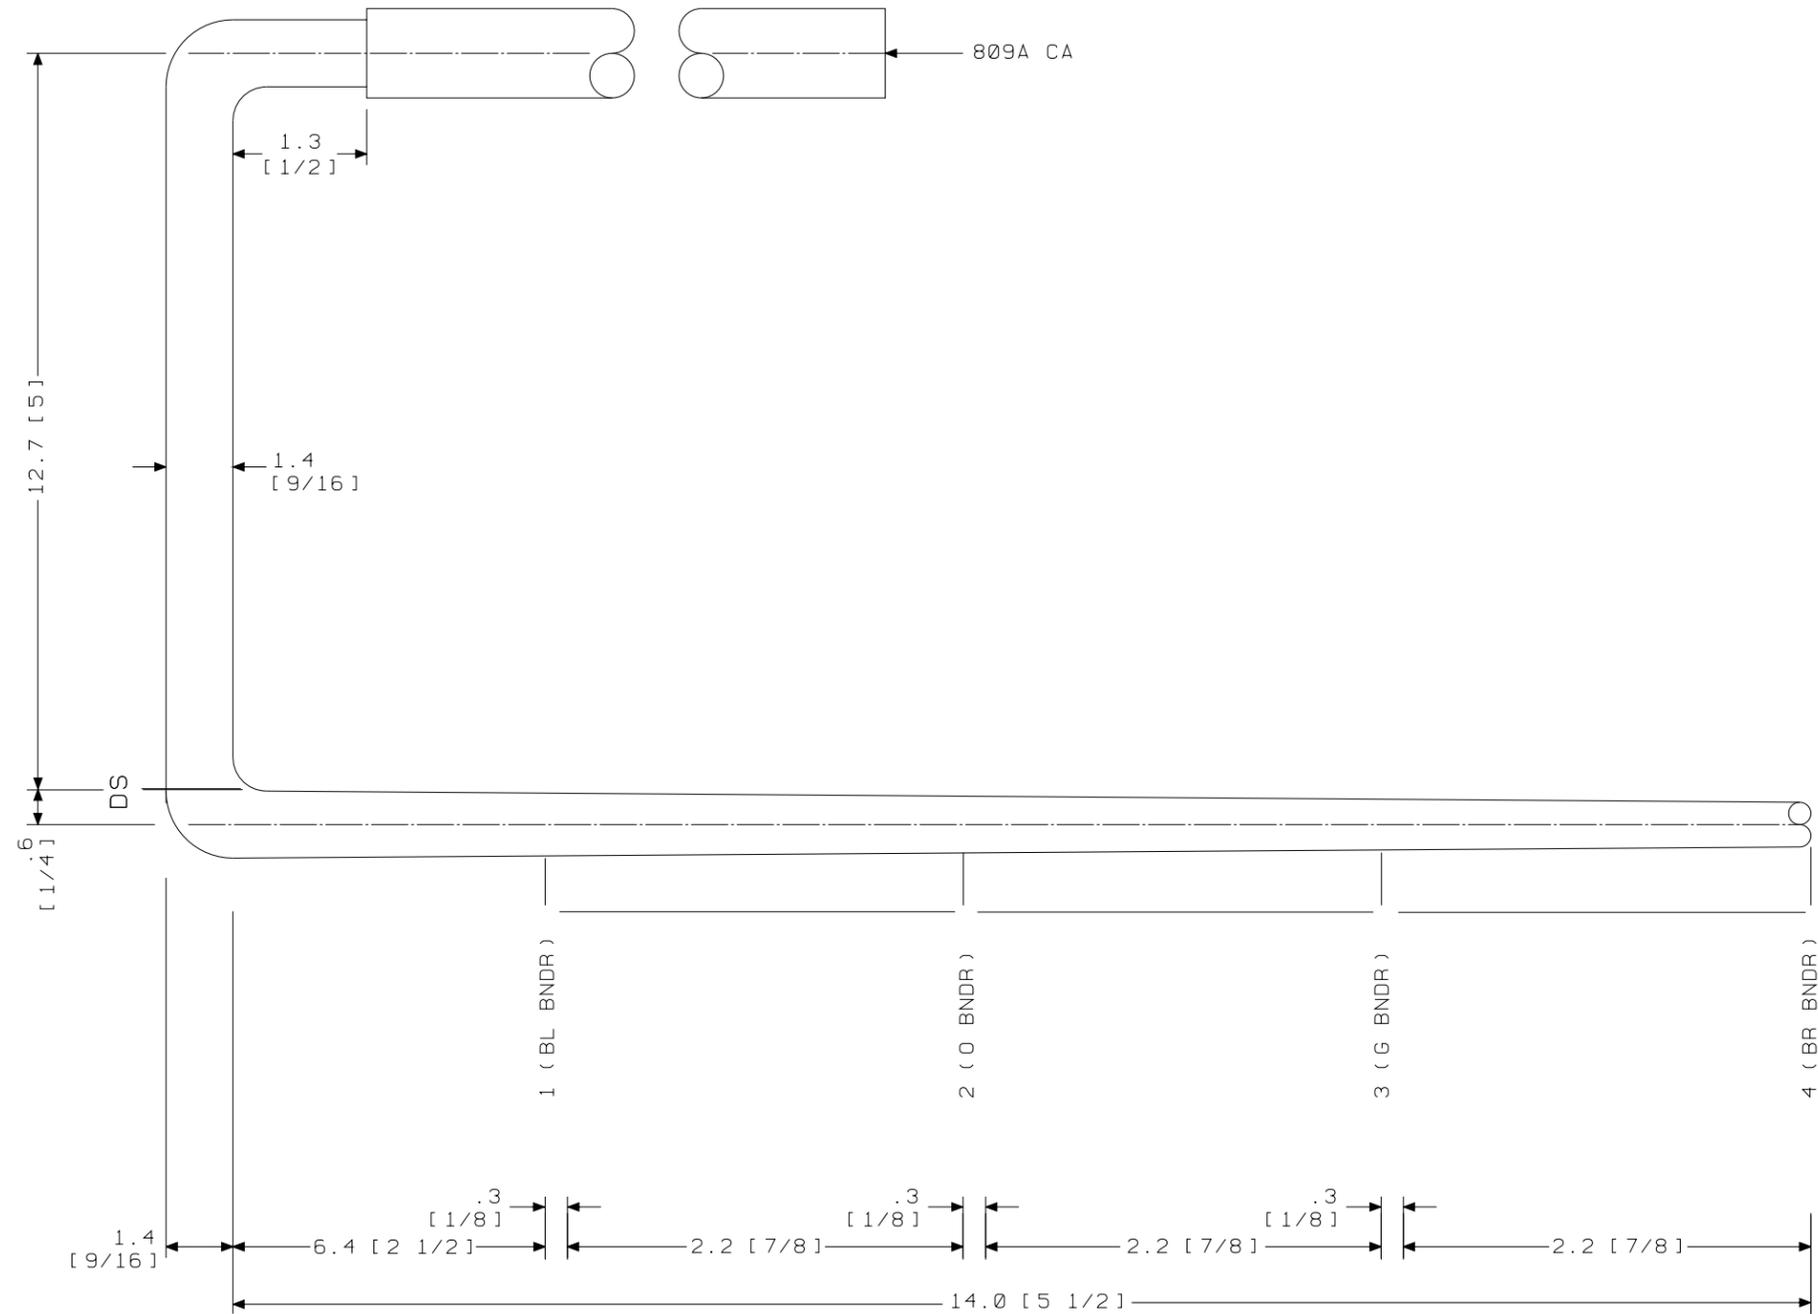



GROUP 224D
 CABLE FOR INTEGRATED SERVICES LINE UNIT (2-WIRE)
 LG 14.15
 END "A"

SK 26.7 [10 1/2] TO ARM C
 (INCLUDES 25.4 [10] FOR MANUFACTURING PURPOSES)

SEE PROPRIETARY NOTICE ON SHEET ONE		
CONNECTORIZED SWITCHBOARD CABLE ASSEMBLIES	DWG SIZE	ISSUE
	c2	49
LUCENT TECHNOLOGIES INC.	ED5D621-35	SHEET C85

ED5D621-35

* FOR BOTH ENDS CUT UNUSED LEADS DEAD AT BUTT.

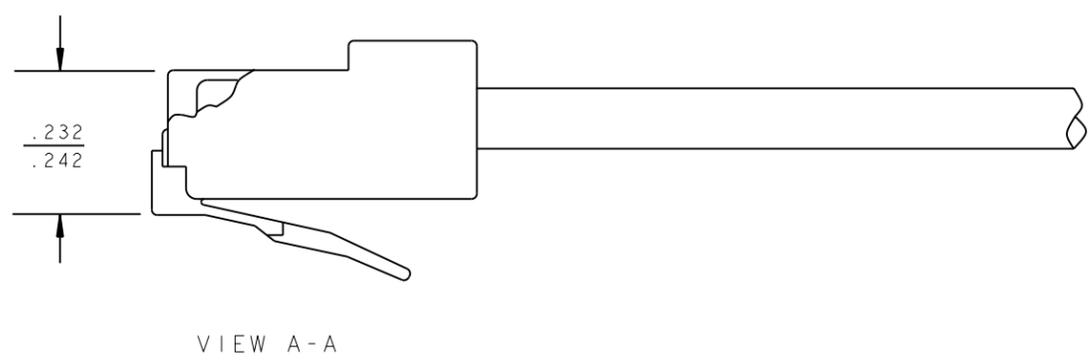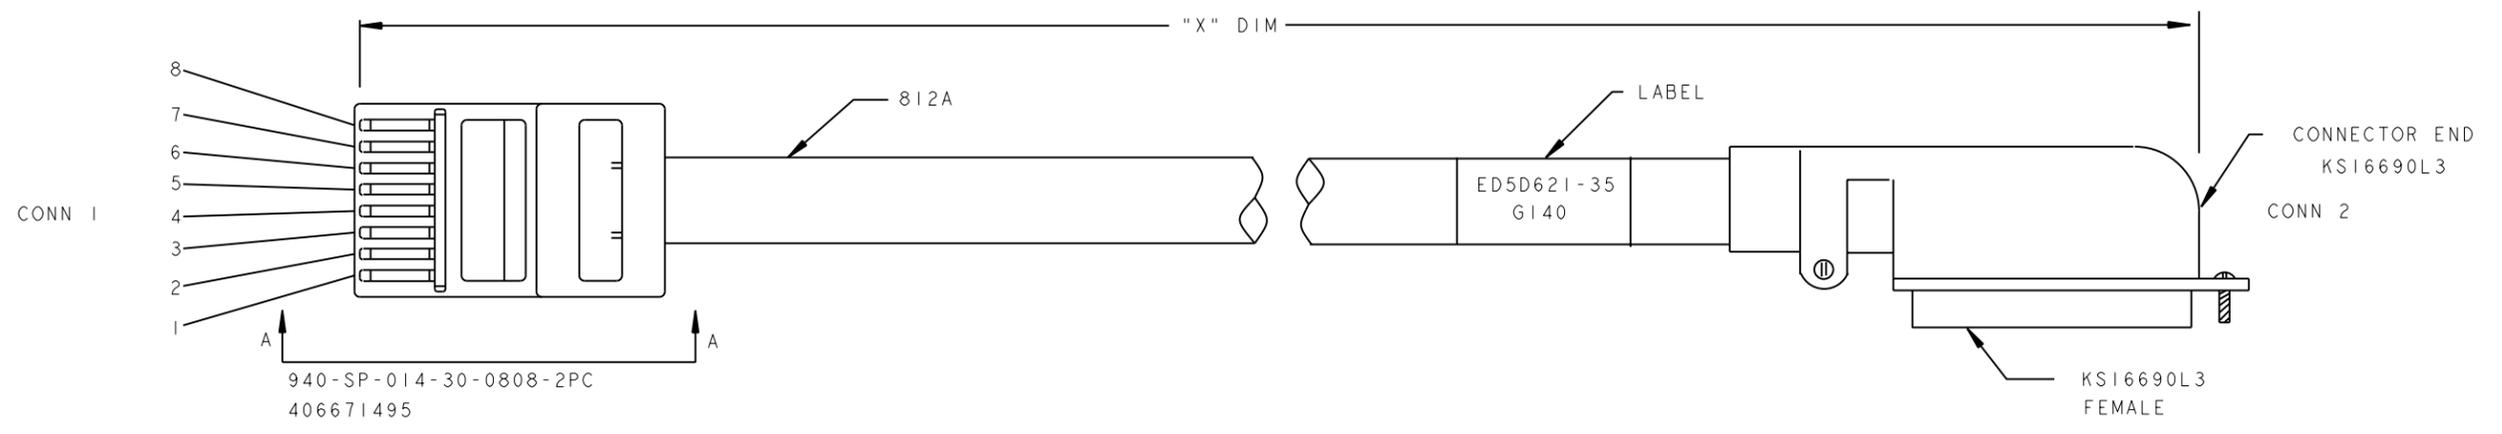


CONNECTING TABLE		
WIRE COLOR	CONNECTOR 1	CONNECTOR 2
	MOD PLUG CONNECTOR	KSI6690L3 CONNECTOR
W-BL	2	5
BL-W	1	4
W-O	8	30
O-W	7	29
W-G		
G-W		
W-BR		
BR-W		

GROUP 140

PROJ-ECEDFORM. FRM-FEB 96


ED5D621-35

FOR PROPRIETARY NOTICE SEE SHEET A1	
CONNECTORIZED SWITCHBOARD CABLE ASSEMBLIES	THIRD ANGLE PROJ
DWG SIZE C2	ISSUE 53
LUCENT TECHNOLOGIES	ED5D621-35 MODEL NAME
	SHEET NO. C86

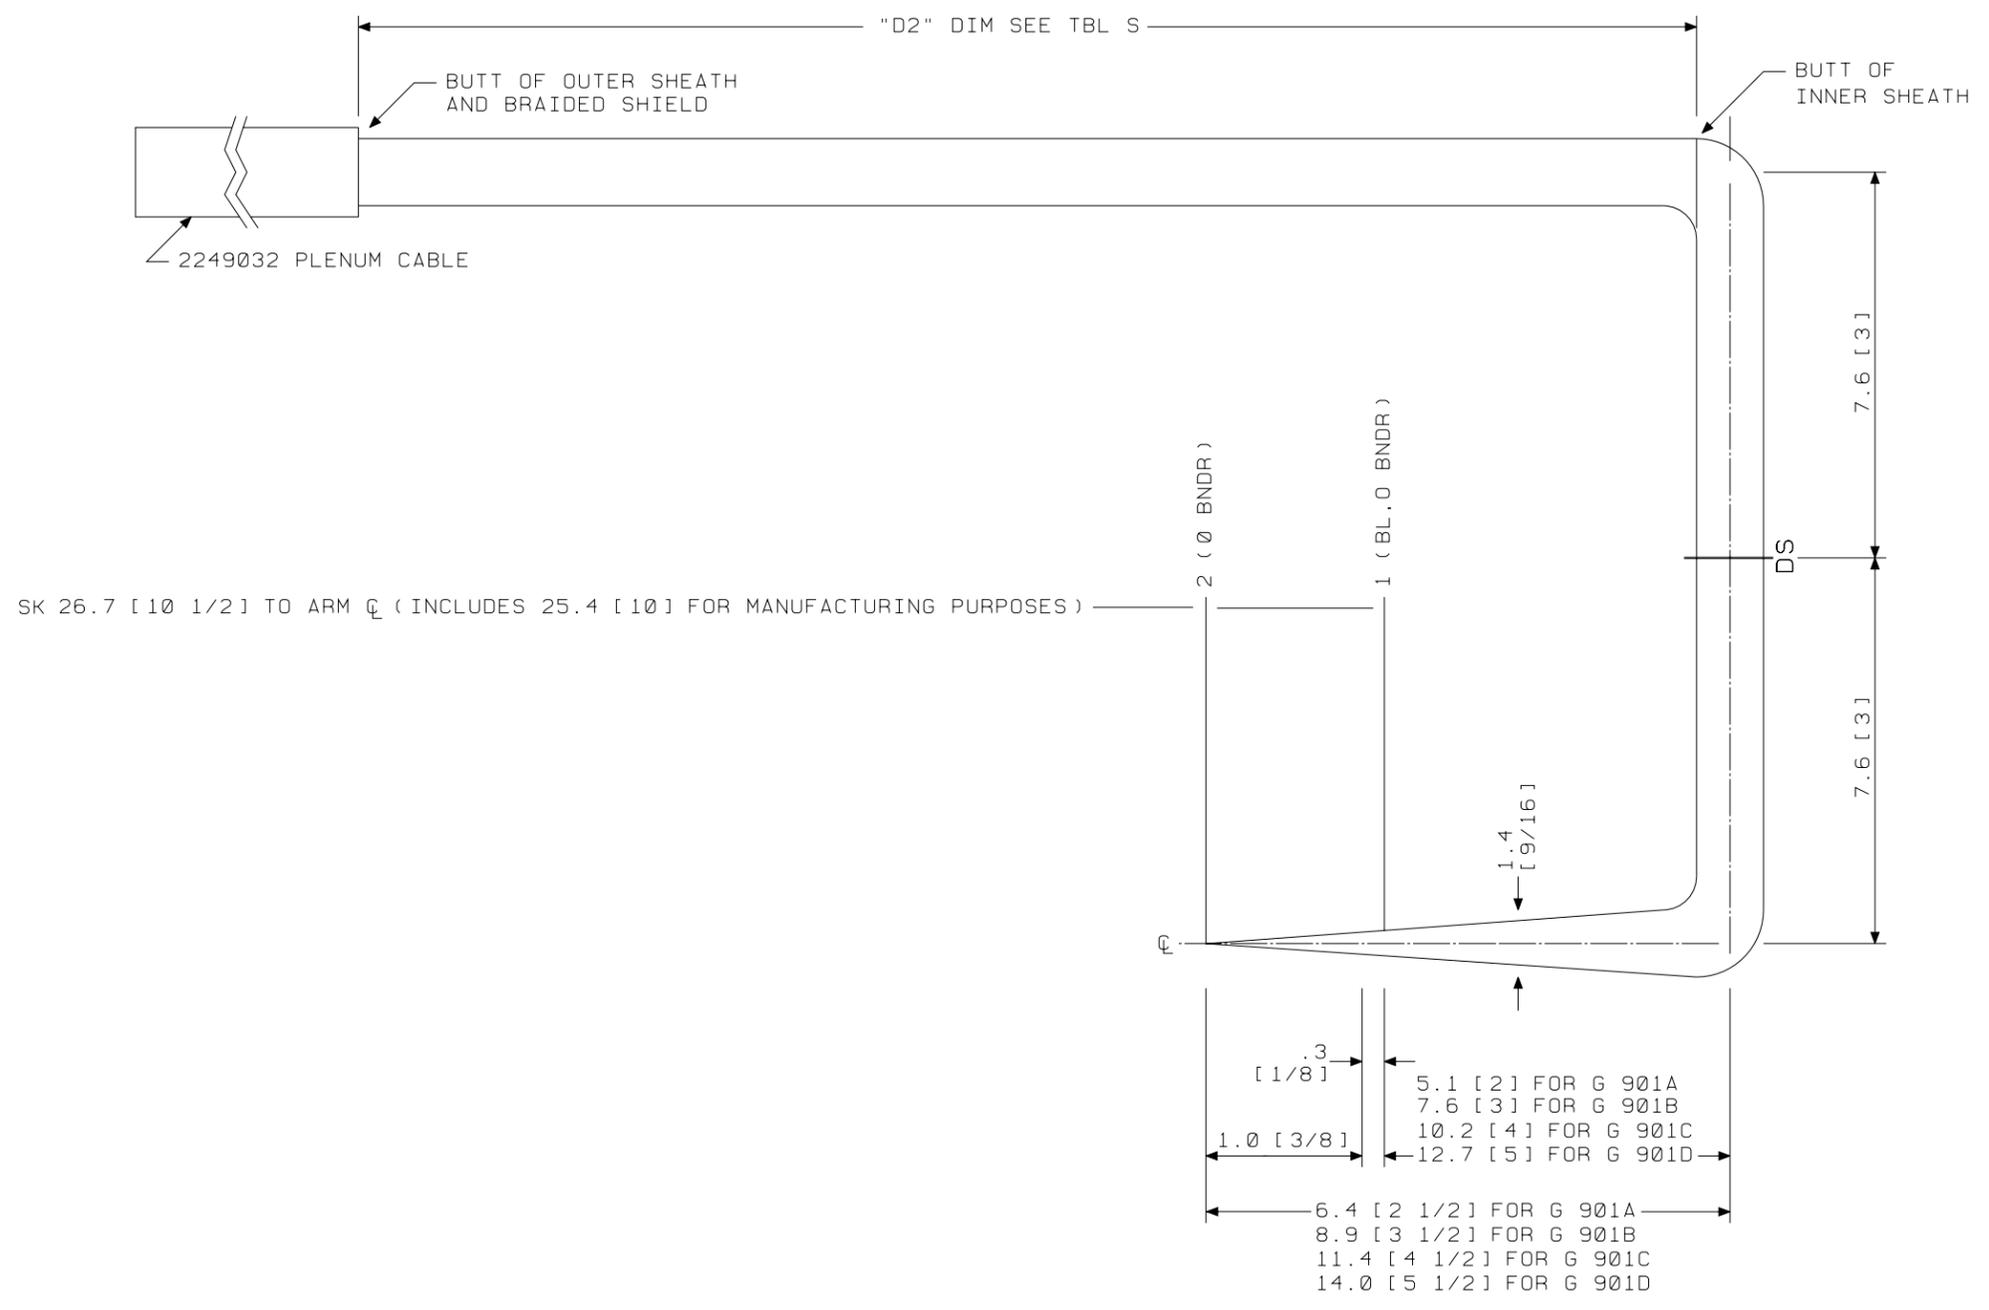


GROUP 901A, 901B, 901C, 901D
 PLENUM CABLE FOR INTERGRATED SERVICES LINE UNIT
 LG 00.01
 END "A"

SEE PROPRIETARY NOTICE ON SHEET ONE		
CONNECTORIZED SWITCHBOARD CABLE ASSEMBLIES	DWG SIZE	ISSUE
	c2	49
LUCENT TECHNOLOGIES INC.	ED5D621-35	SHEET C87

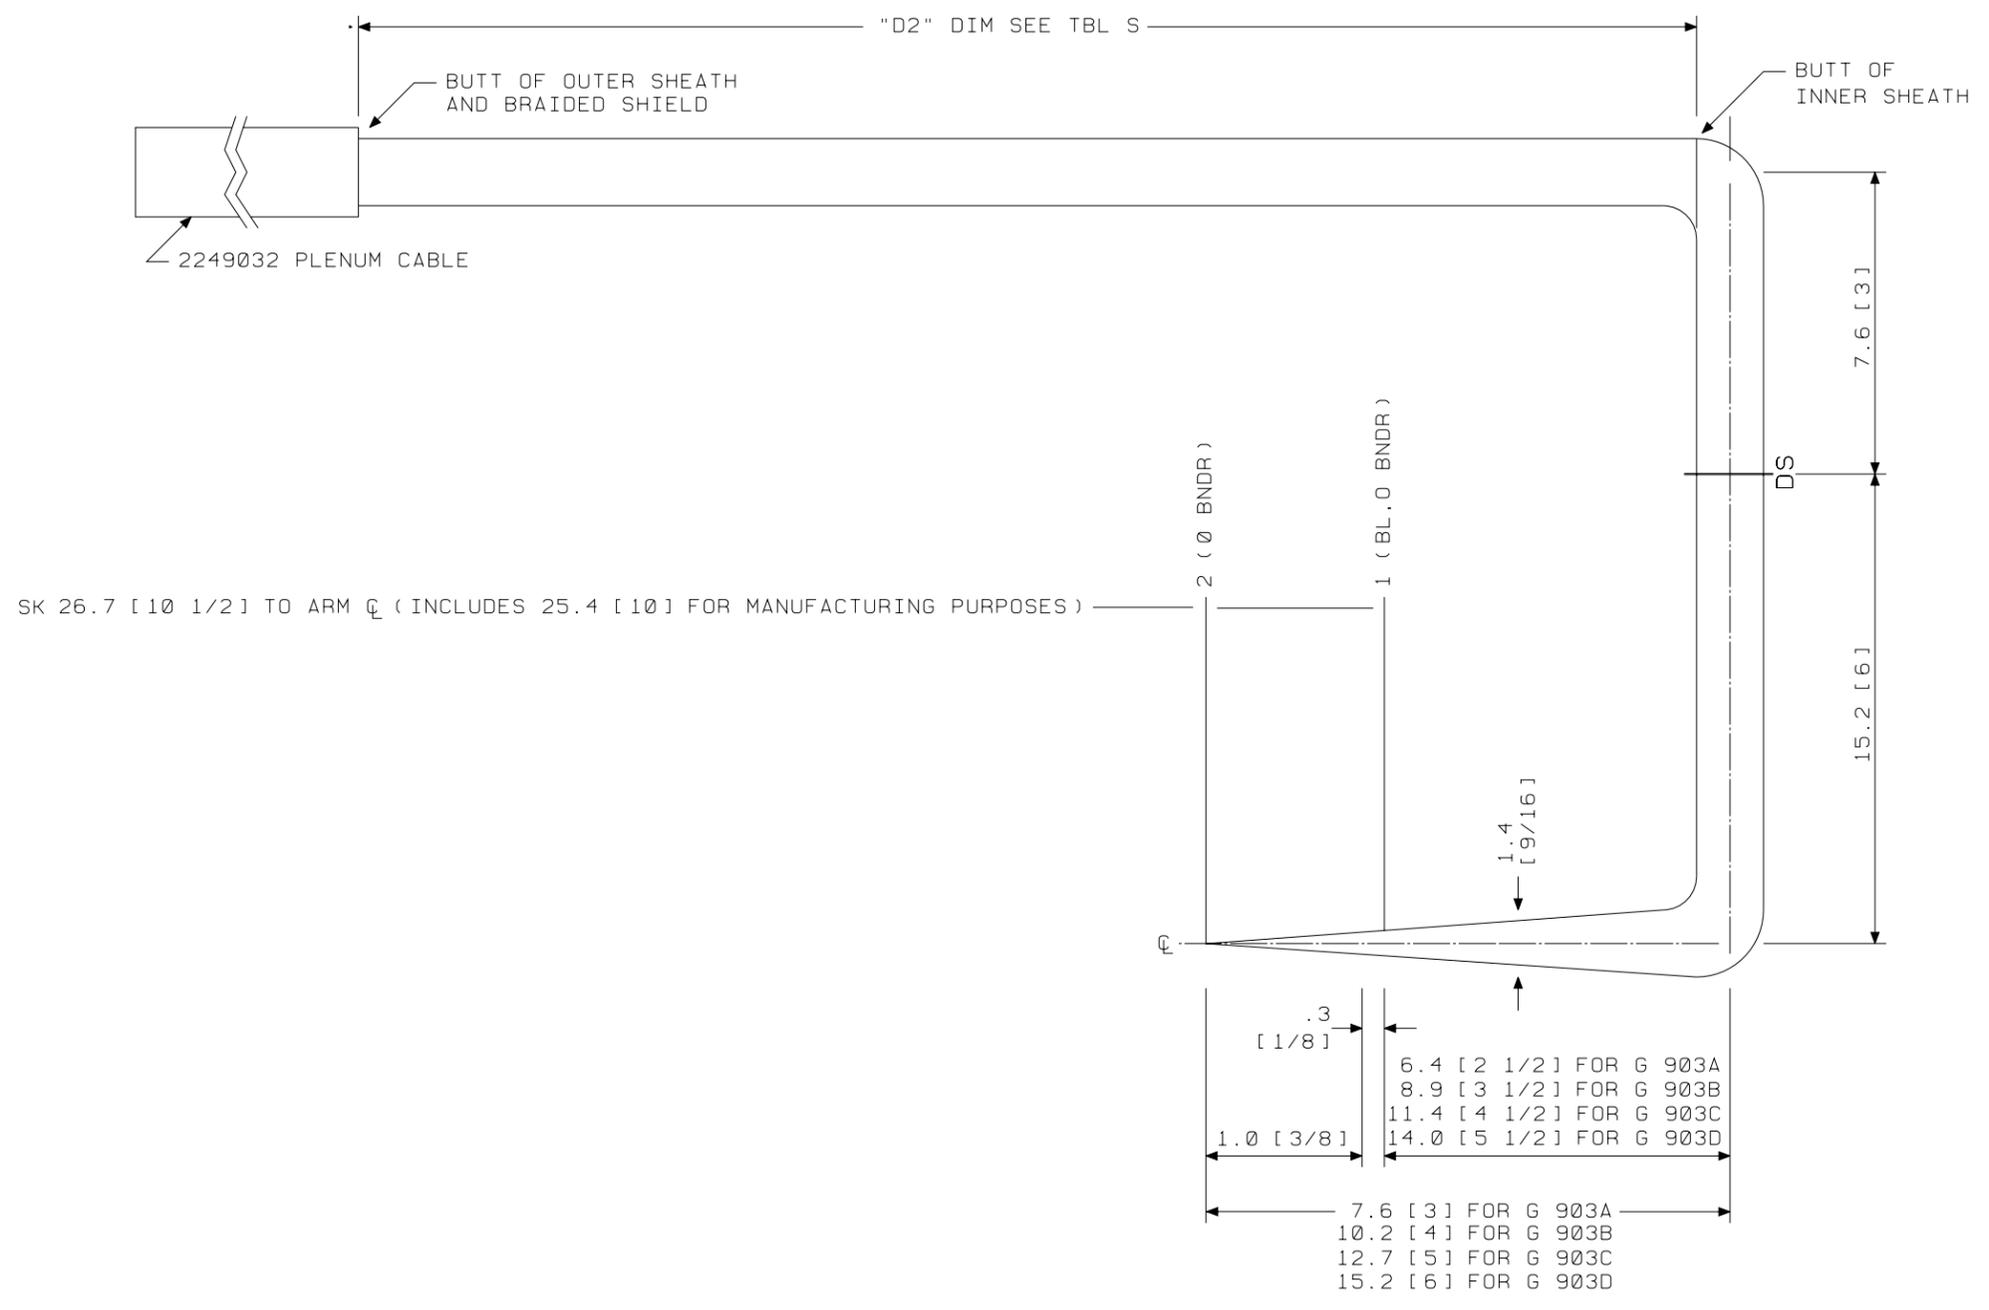


GROUP 903A, 903B, 903C, 903D
 PLENUM CABLE FOR INTERGRATED SERVICES LINE UNIT
 LG 02,03
 END "A"

SEE PROPRIETARY NOTICE ON SHEET ONE		
CONNECTORIZED SWITCHBOARD CABLE ASSEMBLIES	DWG SIZE	ISSUE
	c2	49
LUCENT TECHNOLOGIES INC.	ED5D621-35	SHEET C88

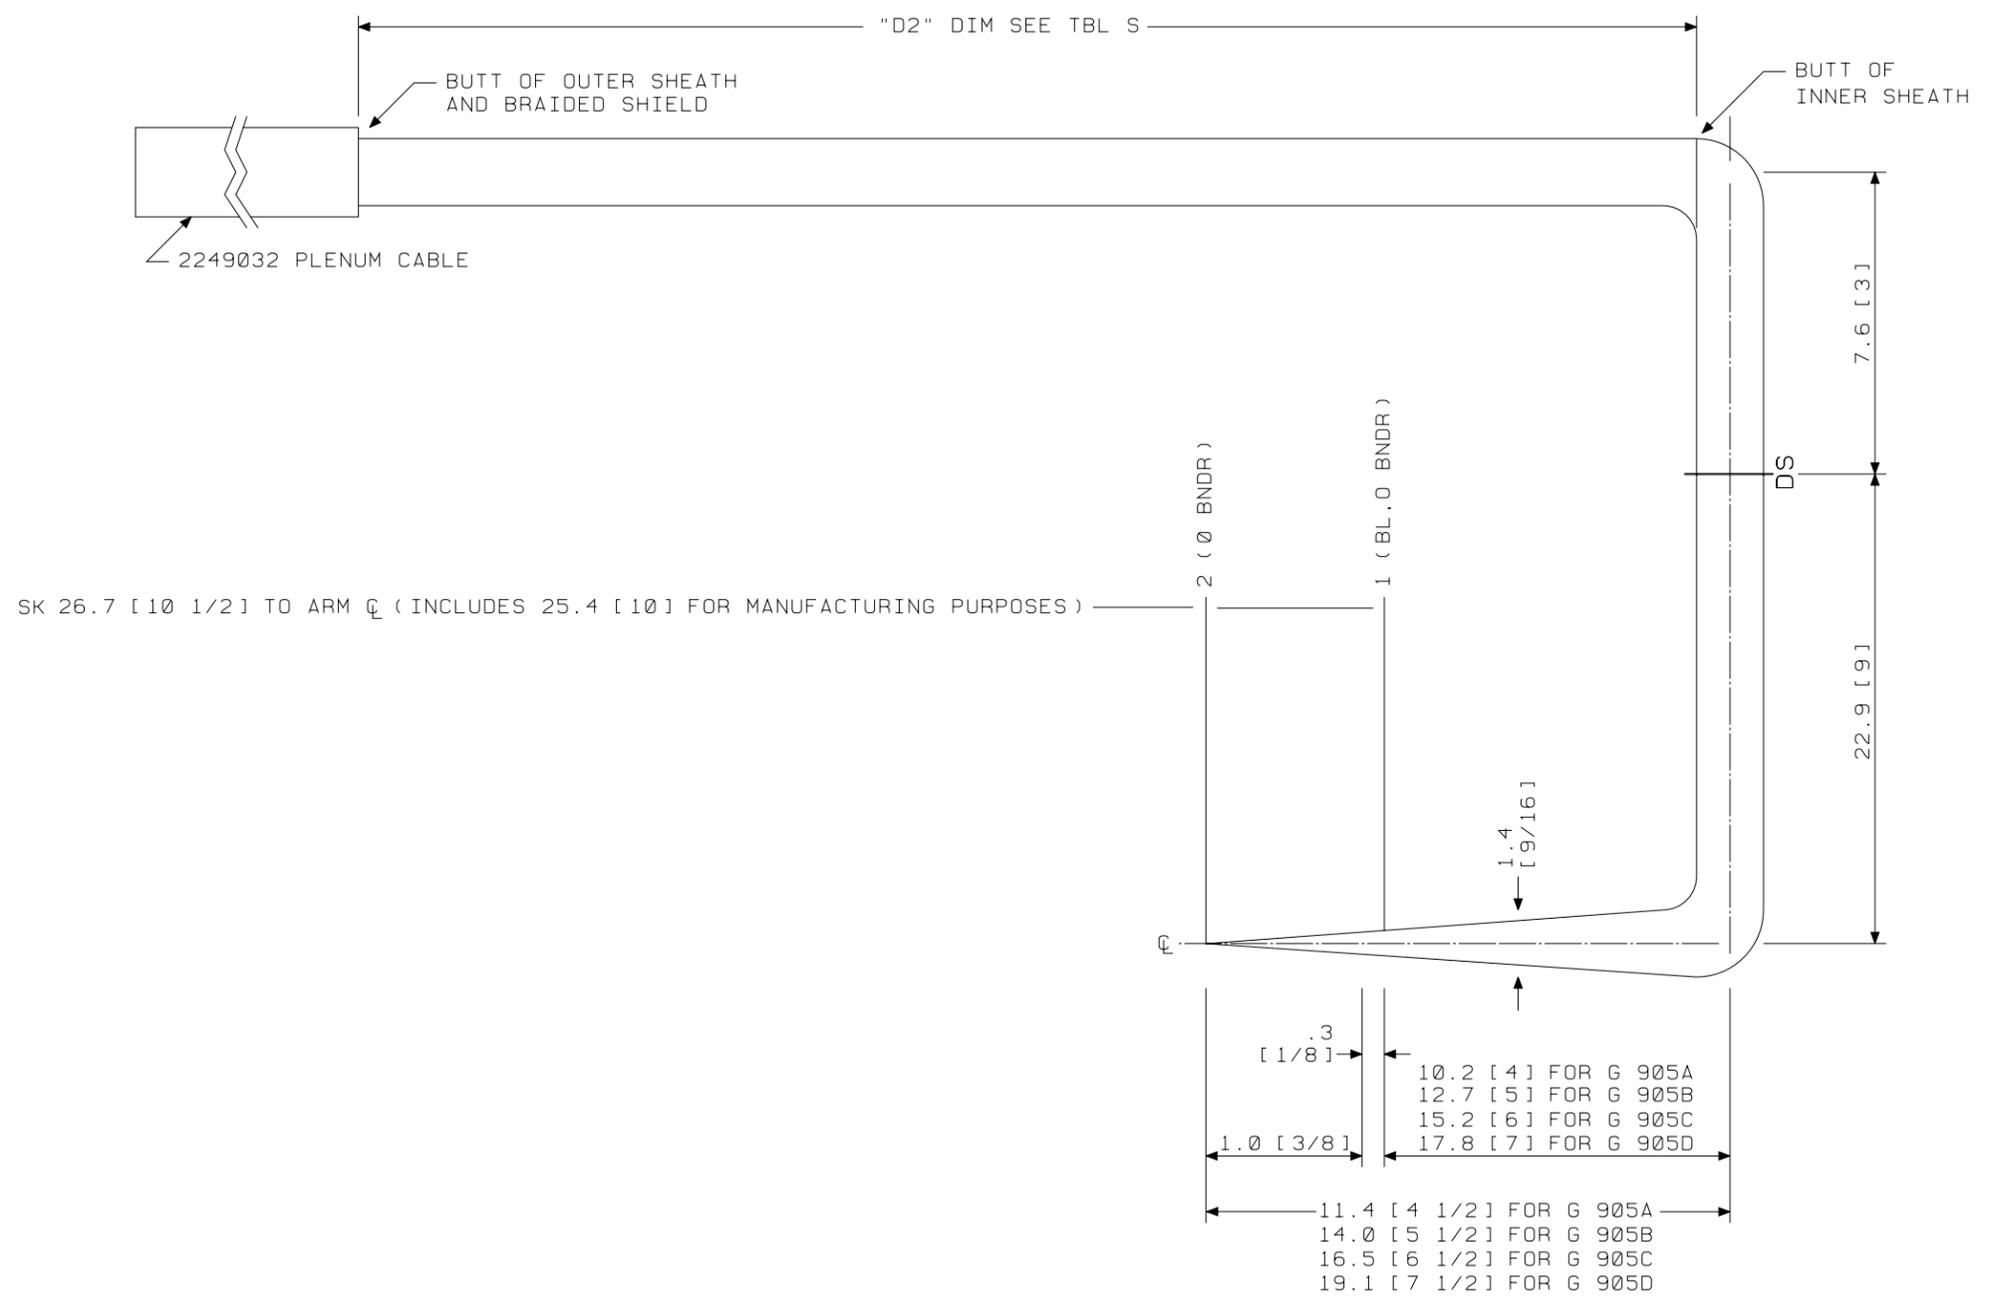


GROUP 905A, 905B, 905C, 905D
 PLENUM CABLE FOR INTERGRATED SERVICES LINE UNIT
 LG 00.01
 END "A"

SEE PROPRIETARY NOTICE ON SHEET ONE		
CONNECTORIZED SWITCHBOARD CABLE ASSEMBLIES	DWG SIZE	ISSUE
	c2	49
LUCENT TECHNOLOGIES INC.	ED5D621-35	SHEET C89

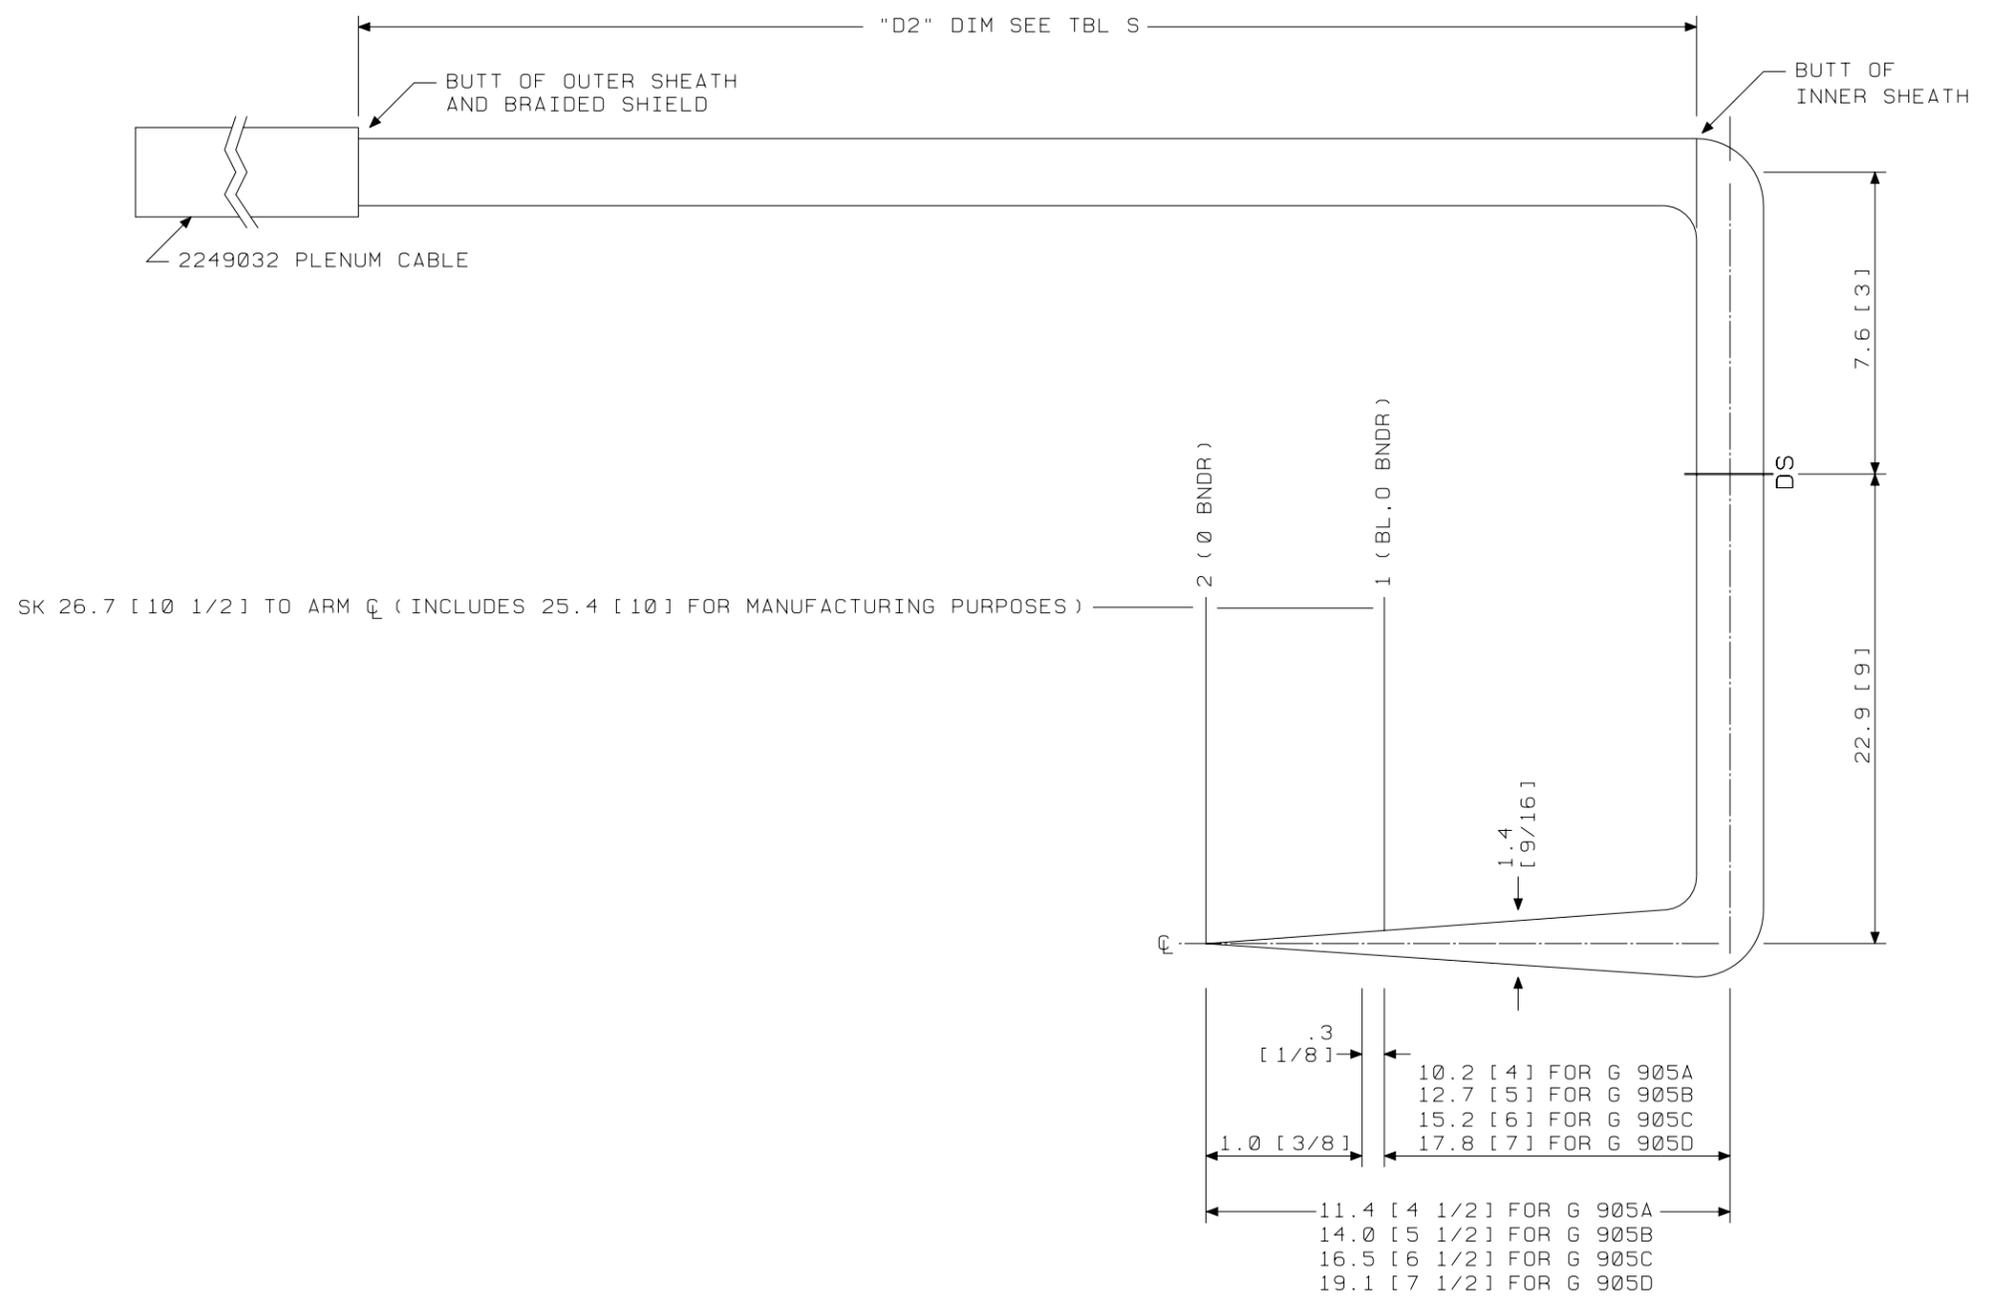


GROUP 905A, 905B, 905C, 905D
 PLENUM CABLE FOR INTERGRATED SERVICES LINE UNIT
 LG 00.01
 END "A"

SEE PROPRIETARY NOTICE ON SHEET ONE		
CONNECTORIZED SWITCHBOARD CABLE ASSEMBLIES	DWG SIZE	ISSUE
	c2	49
LUCENT TECHNOLOGIES INC.	ED5D621-35	SHEET c90

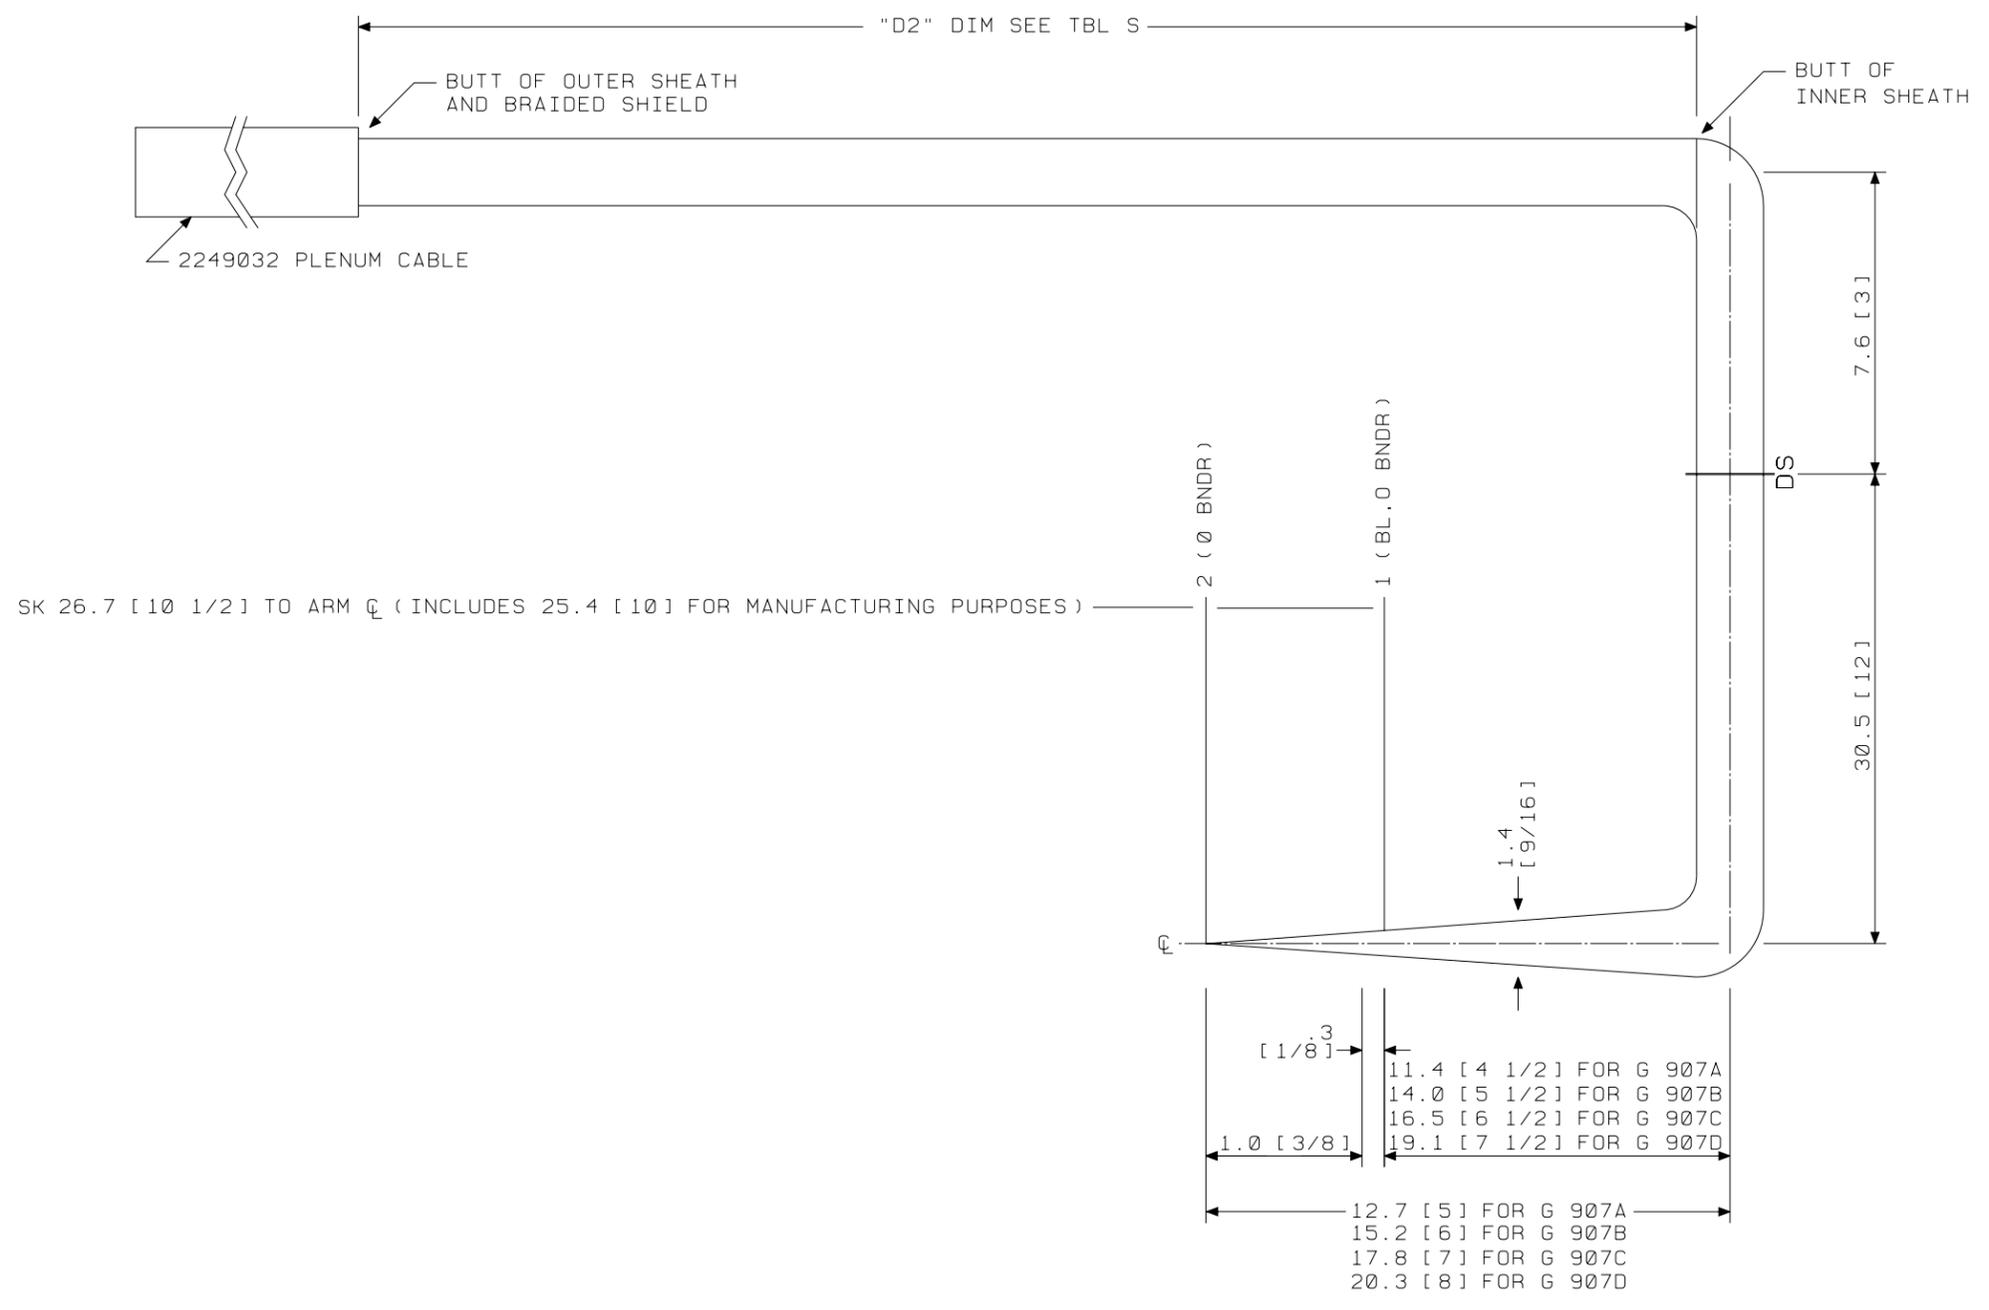


GROUP 907A, 907B, 907C, 907D
 PLENUM CABLE FOR INTERGRATED SERVICES LINE UNIT
 LG 06.07
 END "A"

SEE PROPRIETARY NOTICE ON SHEET ONE		
CONNECTORIZED SWITCHBOARD CABLE ASSEMBLIES	DWG SIZE	ISSUE
	c2	49
LUCENT TECHNOLOGIES INC.	ED5D621-35	SHEET c91

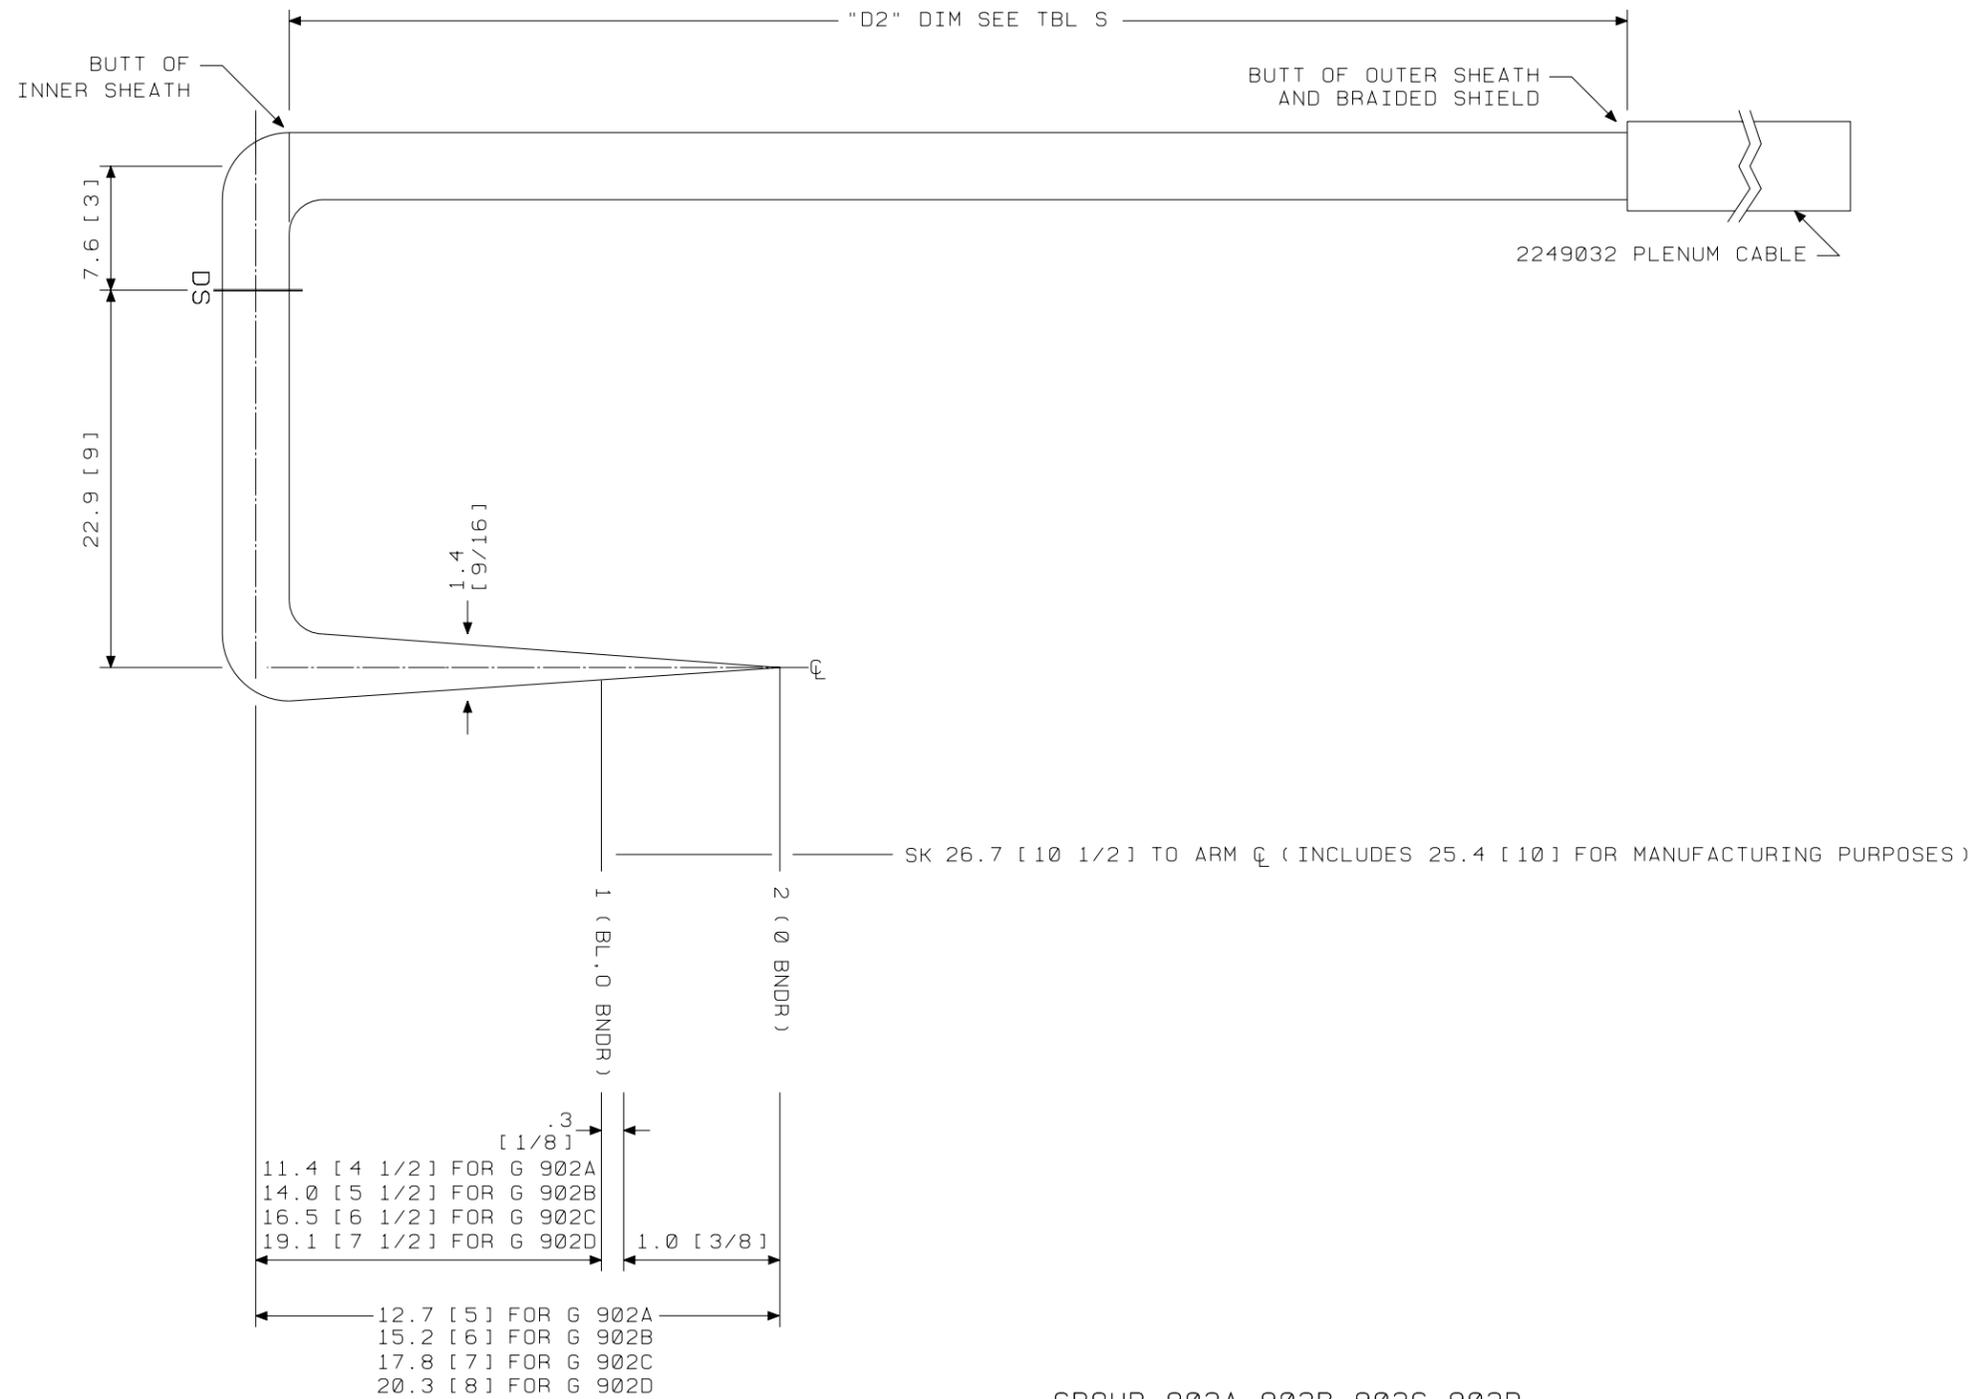


GROUP 902A, 902B, 902C, 902D
 PLENUM CABLE FOR INTERGRATED SERVICES LINE UNIT
 LG 08, 09
 END "A"

SEE PROPRIETARY NOTICE ON SHEET ONE		
CONNECTORIZED SWITCHBOARD CABLE ASSEMBLIES	DWG SIZE	ISSUE
	c2	49
LUCENT TECHNOLOGIES INC.	ED5D621-35	SHEET c92

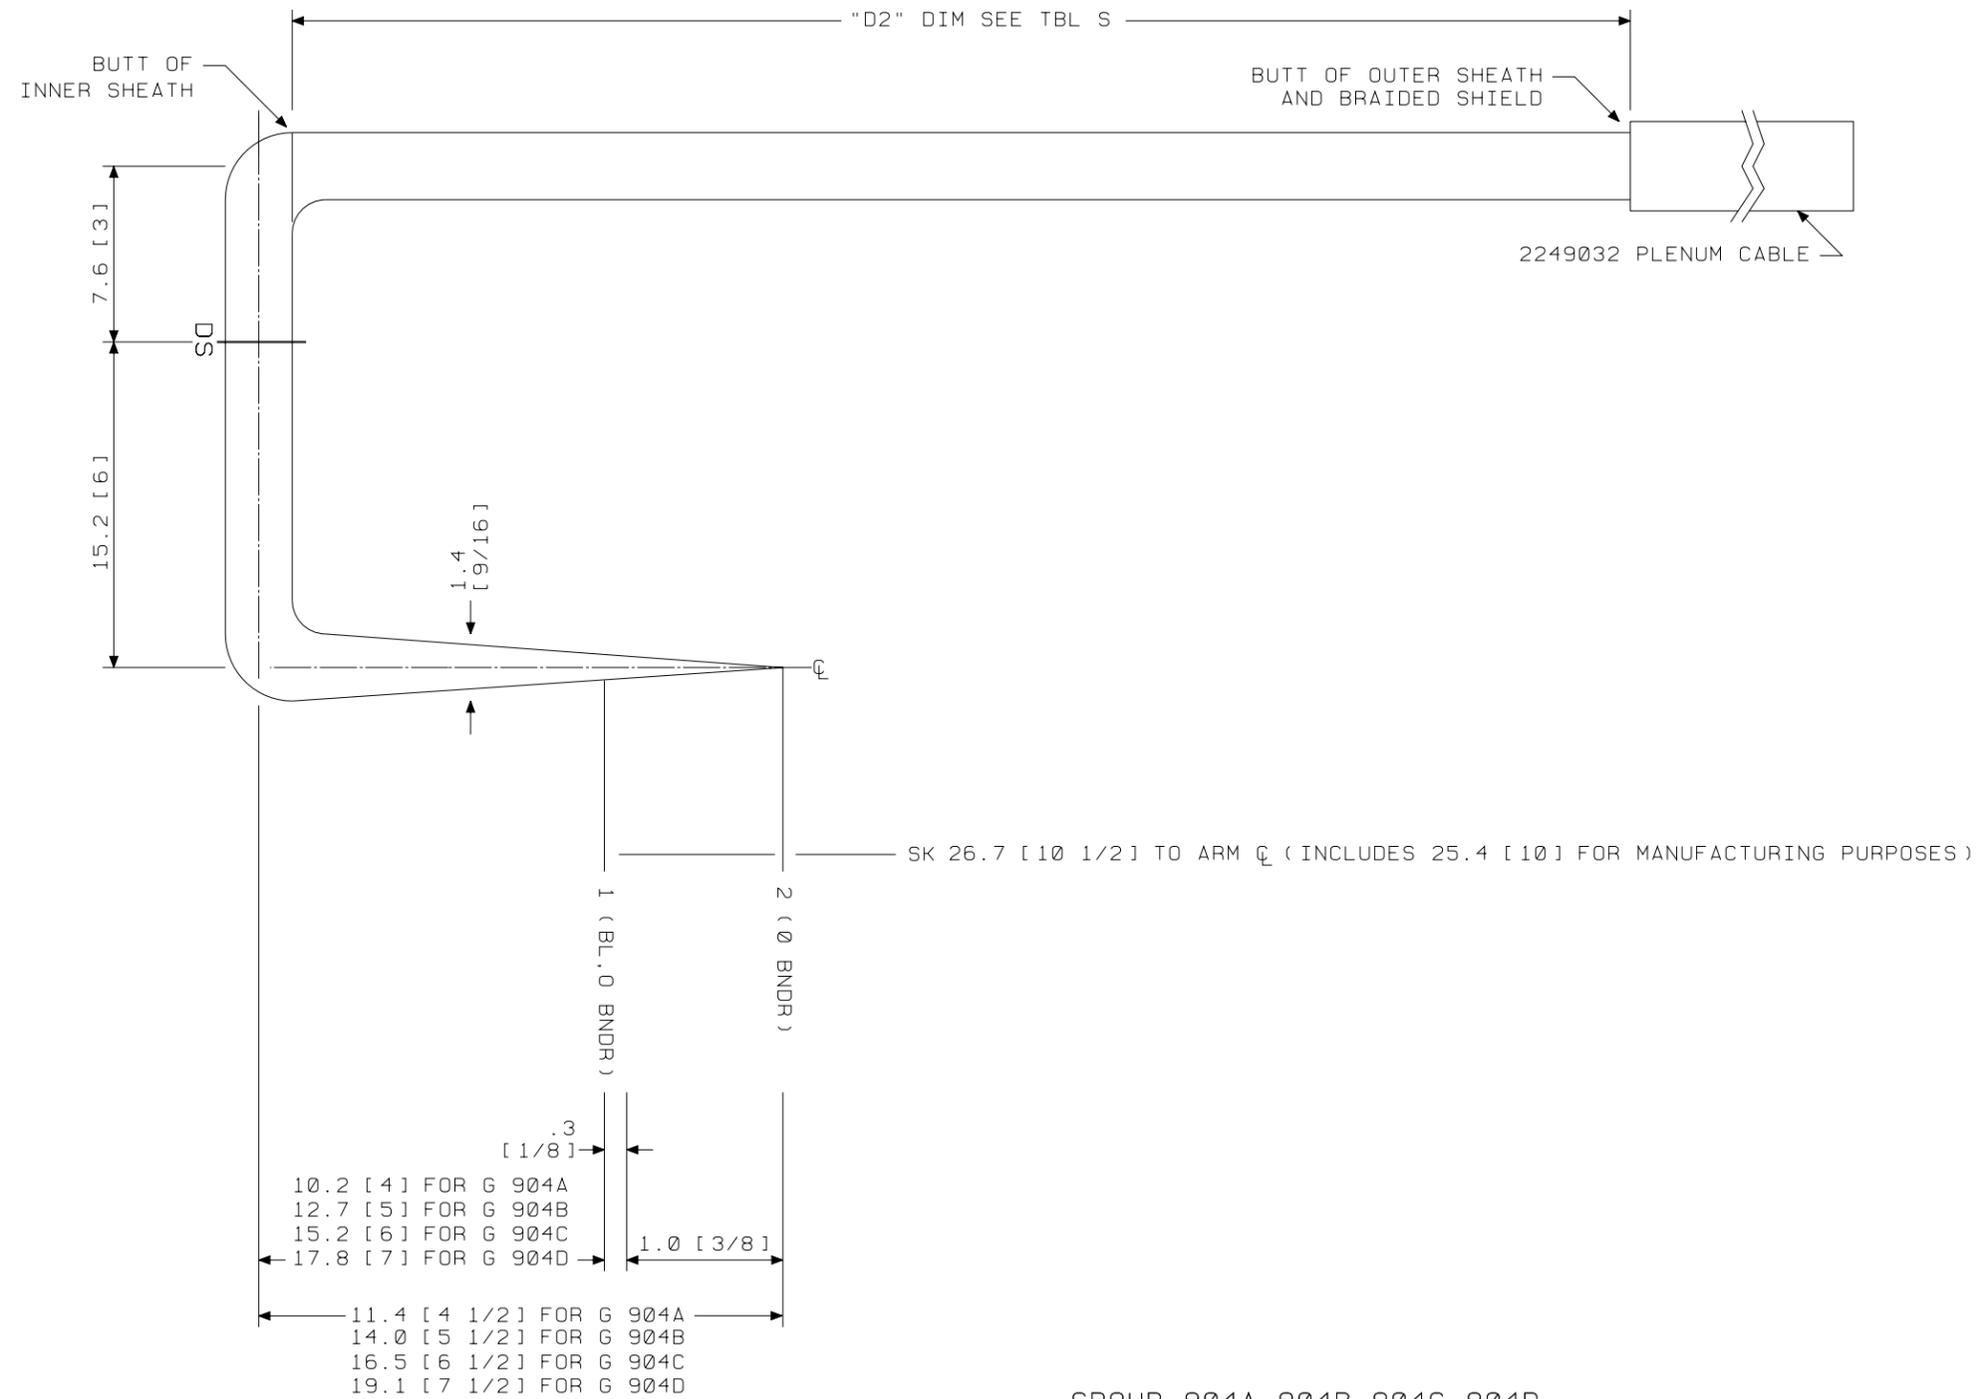


GROUP 904A, 904B, 904C, 904D
 PLENUM CABLE FOR INTERGRATED SERVICES LINE UNIT
 LG 10.11
 END "A"

SEE PROPRIETARY NOTICE ON SHEET ONE		
CONNECTORIZED SWITCHBOARD CABLE ASSEMBLIES	DWG SIZE	ISSUE
	c2	49
LUCENT TECHNOLOGIES INC.	ED5D621-35	SHEET c93

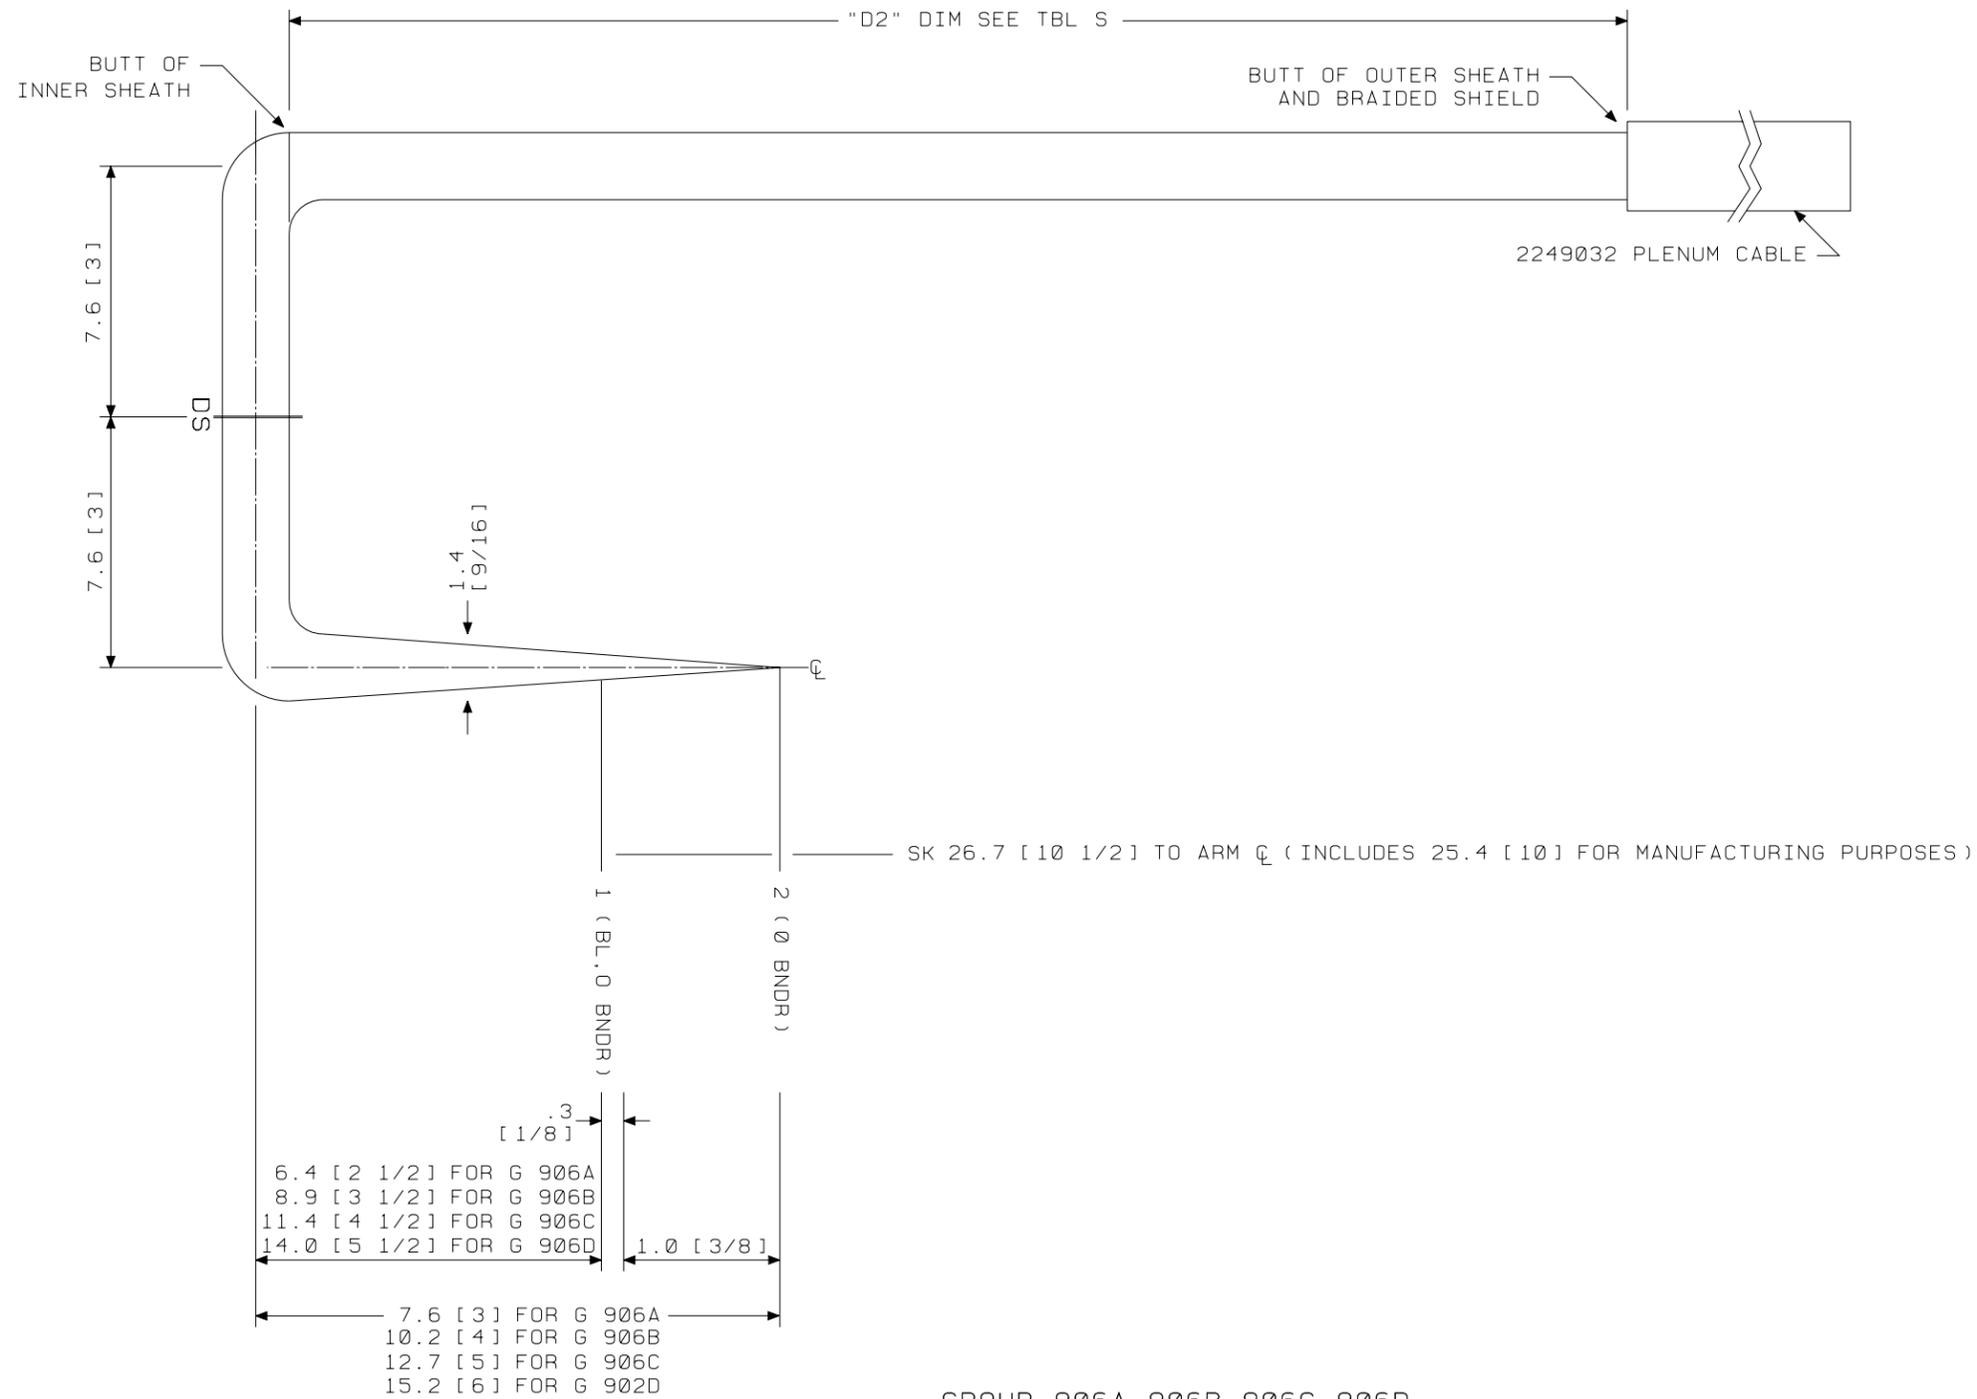

GROUP 906A, 906B, 906C, 906D
 PLENUM CABLE FOR INTERGRATED SERVICES LINE UNIT
 LG 12,13
 END "A"


SEE PROPRIETARY NOTICE ON SHEET ONE		
CONNECTORIZED SWITCHBOARD CABLE ASSEMBLIES	DWG SIZE	ISSUE
	c2	49
LUCENT TECHNOLOGIES INC.	ED5D621-35	SHEET C94

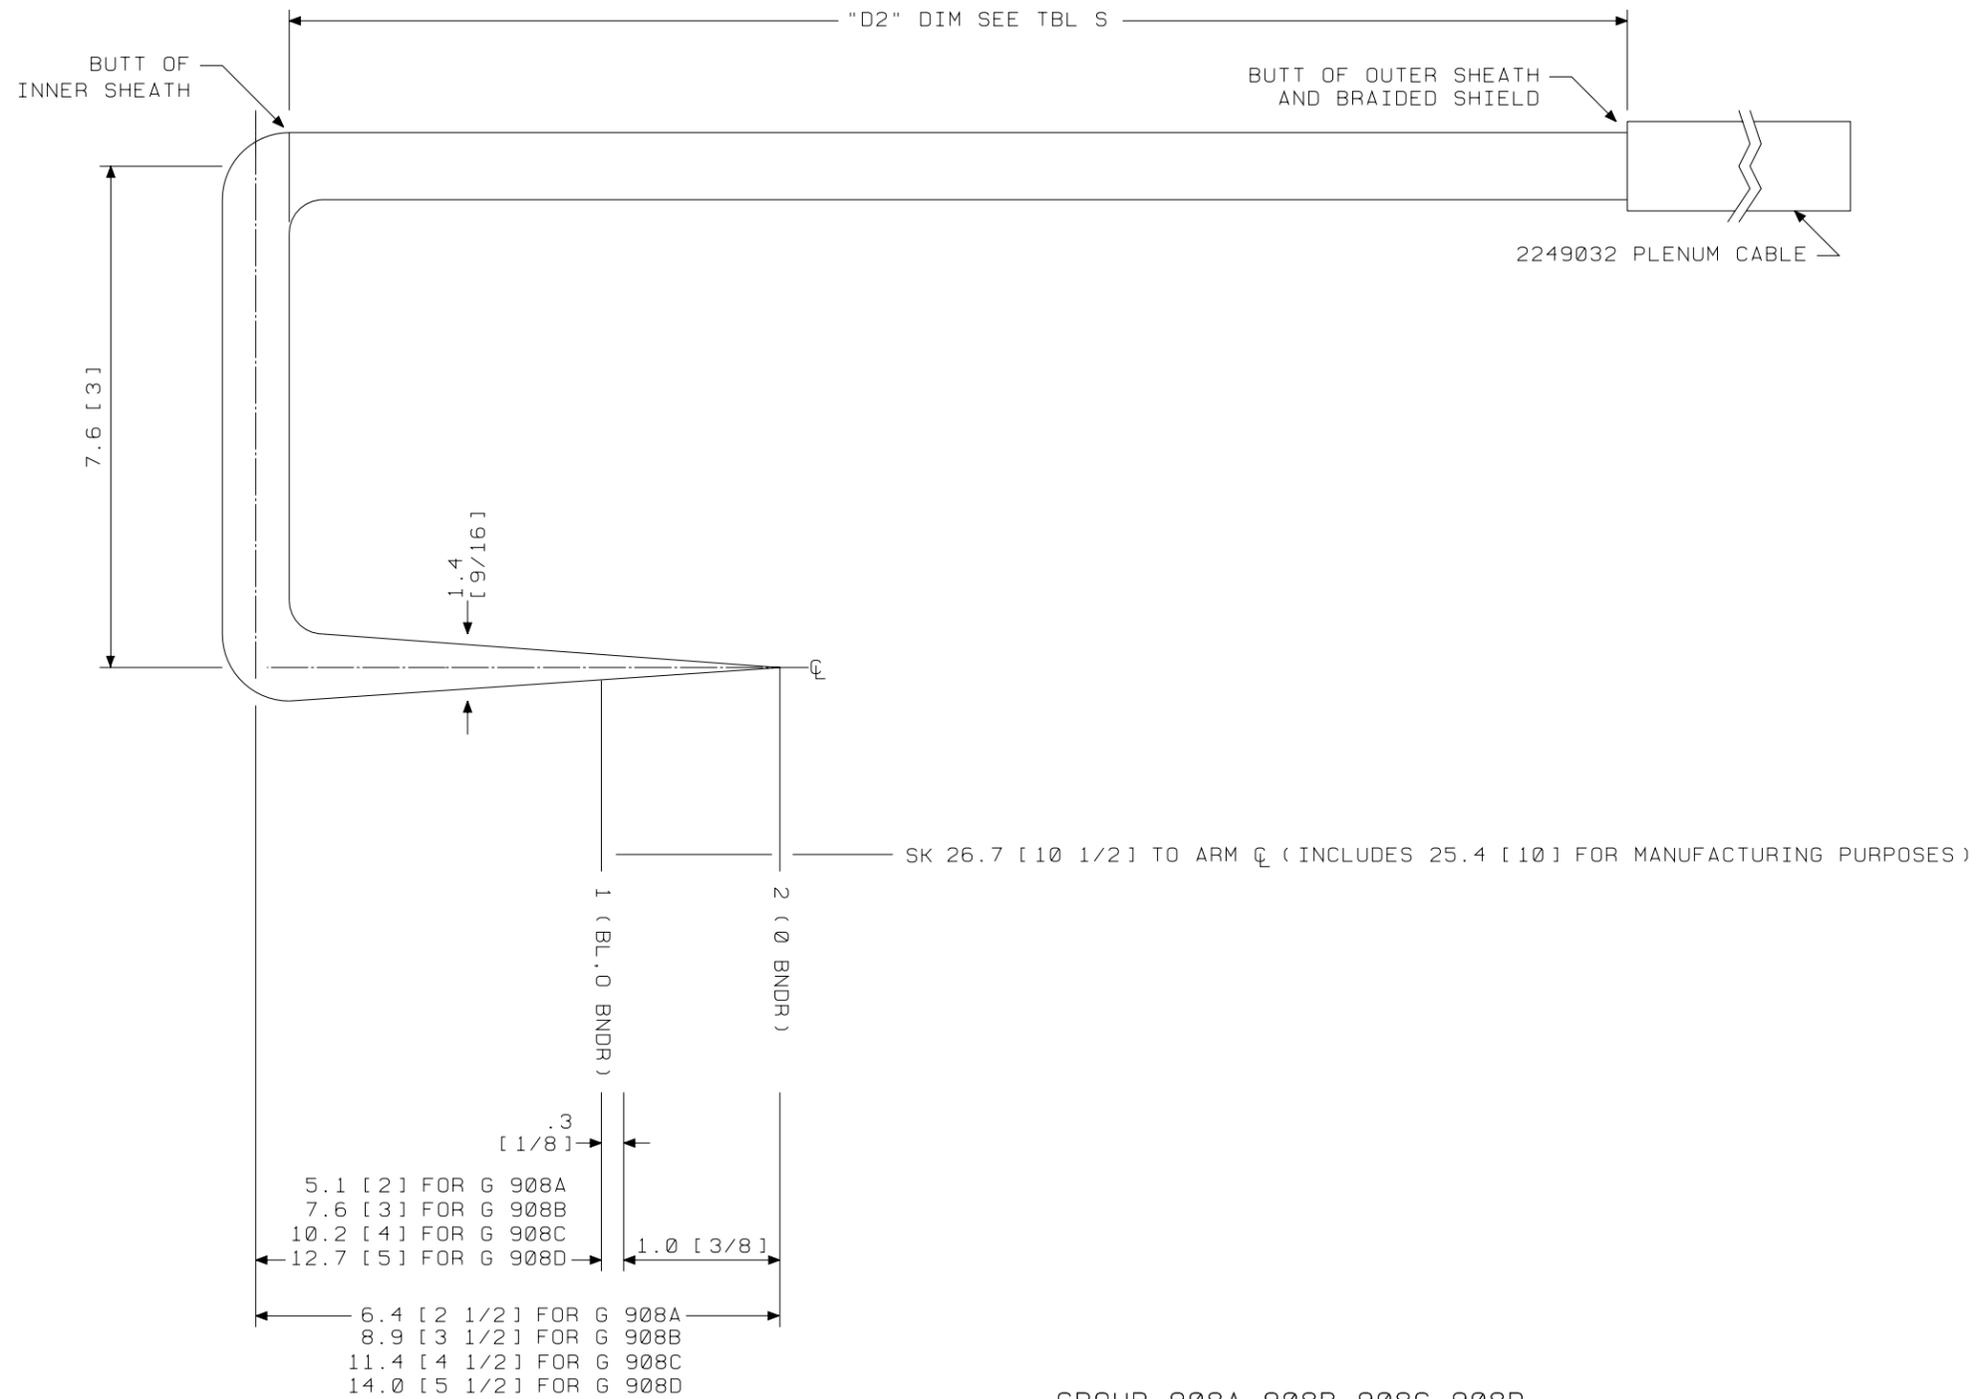

GROUP 908A, 908B, 908C, 908D
 PLENUM CABLE FOR INTERGRATED SERVICES LINE UNIT
 LG 14.15
 END "A"

SEE PROPRIETARY NOTICE ON SHEET ONE		
CONNECTORIZED SWITCHBOARD CABLE ASSEMBLIES	DWG SIZE	ISSUE
	c2	49
LUCENT TECHNOLOGIES INC.	ED5D621-35	SHEET c95



* FOR BOTH ENDS CUT UNUSED
LEADS DEAD AT BUTT.

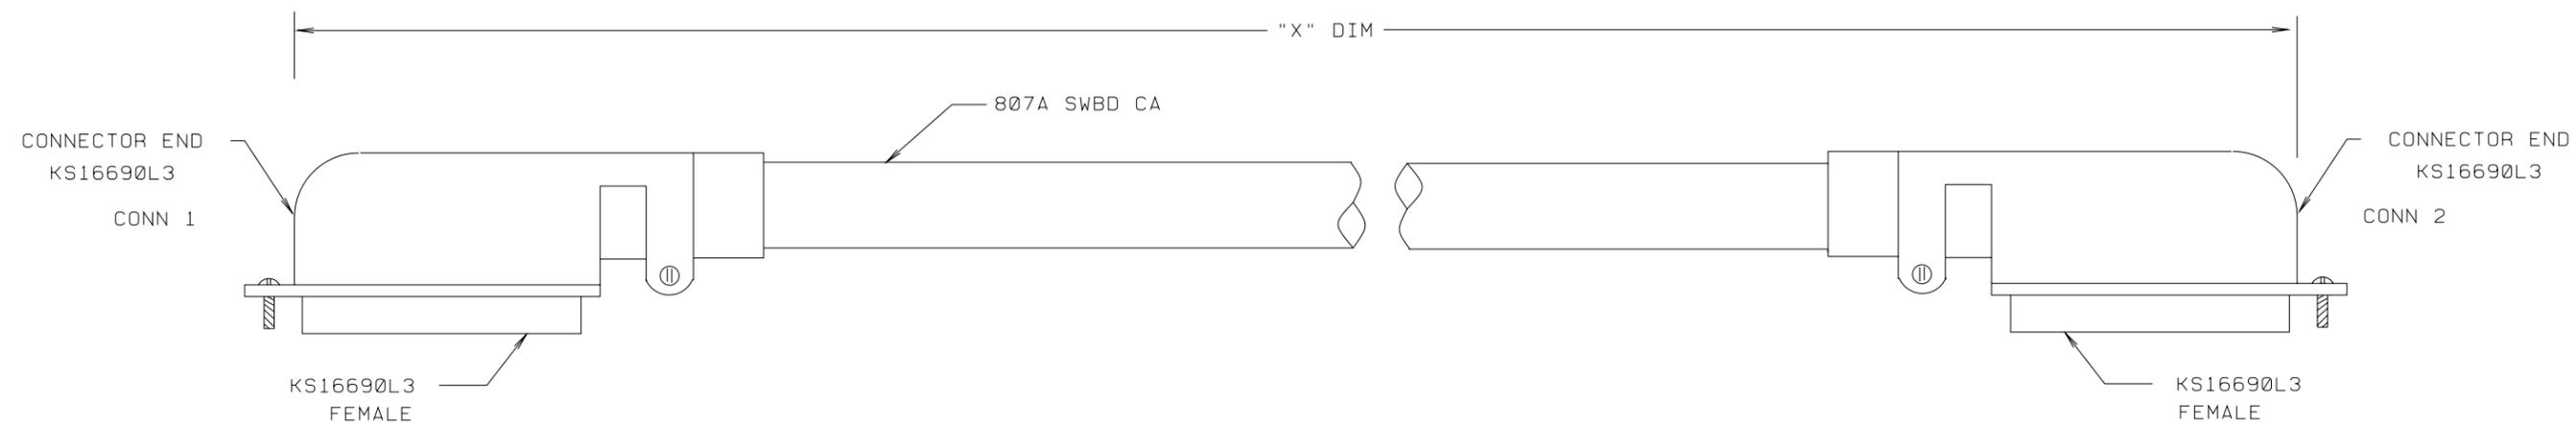

GROUP 70



SEE PROPRIETARY NOTICE ON SHEET ONE		
CONNECTORIZED SWITCHBOARD CABLE ASSEMBLIES		
DWG SIZE c2	ISSUE 49	
LUCENT TECHNOLOGIES INC.	ED5D621-35	SHEET c96

ED5D621-35

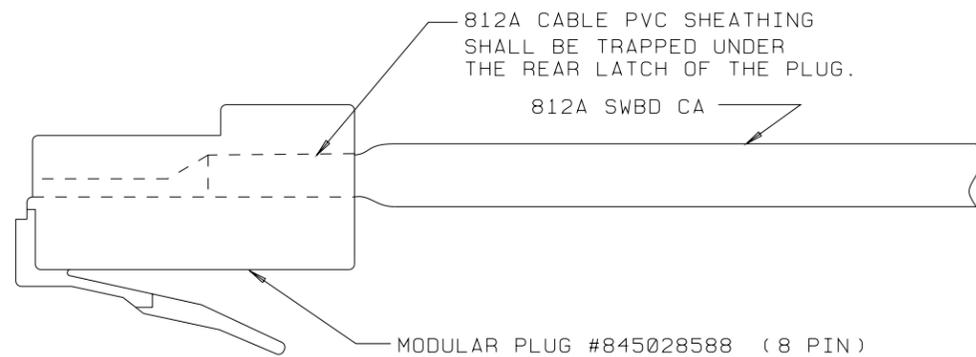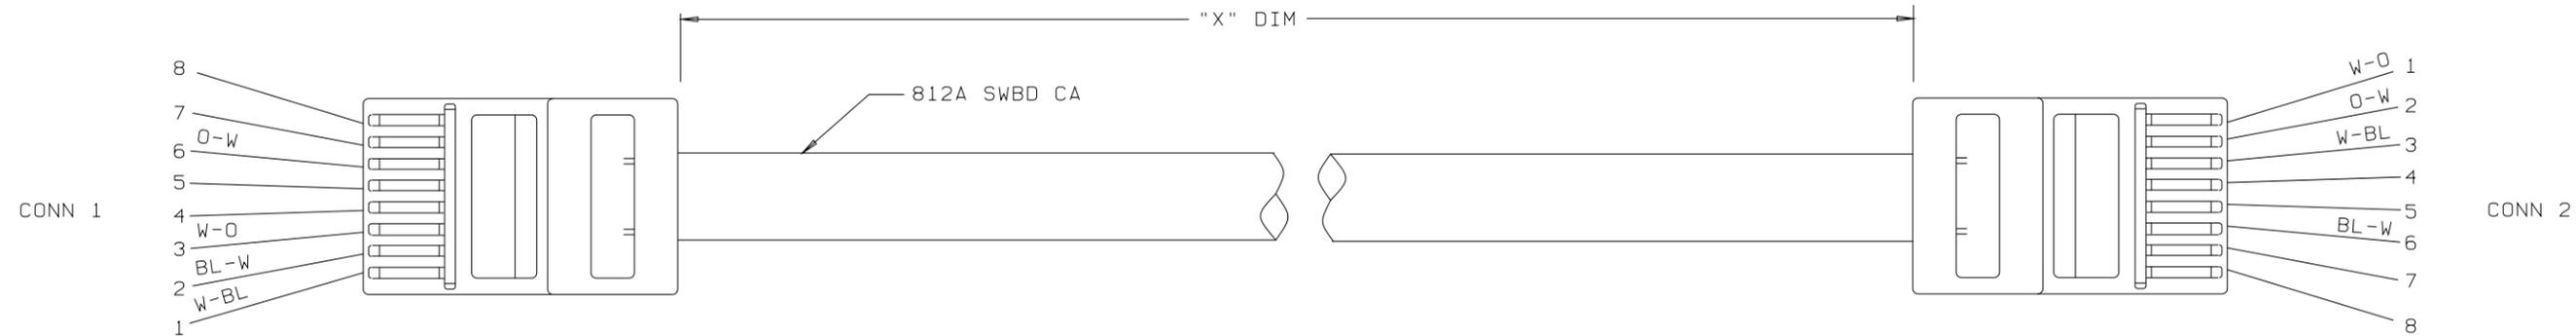

GROUP 204

SEE PROPRIETARY NOTICE ON SHEET ONE		
CONNECTORIZED SWITCHBOARD CABLE ASSEMBLIES	DWG SIZE	ISSUE
	c2	49
LUCENT TECHNOLOGIES INC.	ED5D621-35	SHEET c97

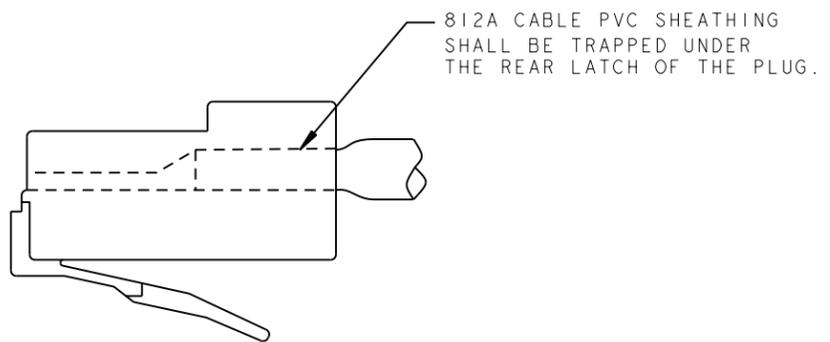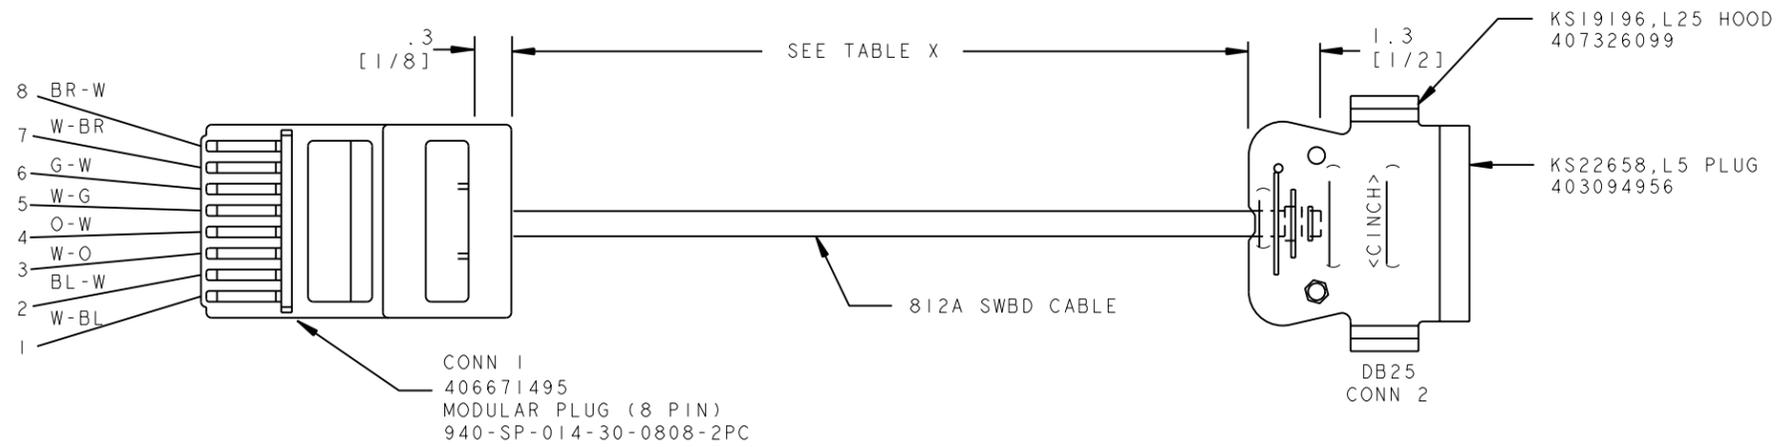

CONN 2 DB25			
TERM	COLOR	TERM	COLOR
1		14	
2	W-O	15	
3	W-G	16	
4	BR-W	17	
5	BL-W	18	
6	W-BL	19	
7	W-BR	20	O-W
8	G-W	21	
9		22	
10		23	
11		24	
12		25	
13			

TABLE X	
GROUP	LENGTH
147A	213.4 [7 FT]
147B	762.0 [25 FT]
147C	1524.0 [50 FT]

GROUP 147A, 147B, 147C

PROJ-ECEDFORM. FRM-FEB 96

ED5D621-35

FOR PROPRIETARY NOTICE SEE SHEET A1		THIRD ANGLE PROJ	
CONNECTORIZED SWITCHBOARD CABLE ASSEMBLIES			
		DWG SIZE C2	ISSUE 53
LUCENT TECHNOLOGIES	ED5D621-35	SHEET NO. C99	
MODEL NAME			

STOCKLIST								
ITEM NBR	LIST GROUP CODE	QTY PER CODE	PRODUCT IDENTIFIER	CODE	DESCRIPTION	REFERENCE POSITION	NOTE	
							SYM	NBR
1015	1	1	106556566	608C	CABLE,ELECTRICAL 22GA, 16 PAIR, 2000 FT LG			4 5
1020	1,1A	1	103125365	982AD	CONNECTOR,BACKPLANE			
1030	1,1A	2	103125373	982AE	CONNECTOR,ELECTRICAL			
1040	1,1A	2	842923765		RELIEF,STRAIN			
1075	1A,3A	1	105441638	1249016A	CABLE,ELECTRONIC 26GA			4 5
1085	3	1	106556566	608C	CABLE,ELECTRICAL 22GA, 16 PAIR, 2000 FT LG			4 5
1090	3,3A	1	103125365	982AD	CONNECTOR,BACKPLANE			
1100	3,3A	2	103125373	982AE	CONNECTOR,ELECTRICAL			
1110	3,3A	2	842923765		RELIEF,STRAIN			
1150	5	1	106557762	752A	CABLE,22 GA. 6 PAIRS			4 5
1160	5	1	103125373	982AE	CONNECTOR,ELECTRICAL			
1170	5	1	842923765		RELIEF,STRAIN			
1180	5	1	900714981		TUBING 5/8 ID X 4 IN LONG HEAT SHRINKABLE BLACK #RT876 RAYCHEM CORP. /OR EQUIV.			
1200	5	6	401194410	KS19195L1	WIRE,COPPER 20GA BK			
1205	5	6	407138718		BARRIER,HEAT #K.125 SUMITOMO ELECTRIC /OR EQUIV.			
1220	7	1	106557762	752A	CABLE,22 GA. 6 PAIRS			4 5
1230	7	1	103125373	982AE	CONNECTOR,ELECTRICAL			
1240	7	1	842923765		RELIEF,STRAIN			
1250	7	1	900714981		TUBING 5/8 ID X 4 IN LONG HEAT SHRINKABLE BLACK #RT876 RAYCHEM CORP. /OR EQUIV.			
1270	7	6	401194410	KS19195L1	WIRE,COPPER 20GA BK			
1275	7	6	407138718		BARRIER,HEAT #K.125 SUMITOMO ELECTRIC /OR EQUIV.			
1280	9	1	106557747	758A	CABLE,22 GA. 4 PAIRS			
1290	9	1	103125365	982AD	CONNECTOR,BACKPLANE			
1295	9	1	842923740		RELIEF,STRAIN			
1300	9	1	900714981		TUBING 5/8 ID X 4 IN LONG HEAT SHRINKABLE BLACK #RT876 RAYCHEM CORP.			
1301	1,3	1	843746371		WIRE 20GA DP 3 BK			
1302	1A,3A	1	843743170		WIRE 26GA DP 3 BK			
1303	1,1A,3, 3A	1	401224530	KS21256L1	SLEEVE,SPECIAL			
1310	9	4	401194410	KS19195L1	WIRE,COPPER 20GA BK			
1315	9	4	407138718		BARRIER,HEAT #K.125 SUMITOMO ELECTRIC /OR EQUIV.			

STOCKLIST CONTINUED ON SHEET D2

ED5D621-35

S H O P P I N G P O S T	MANUFACTURING NOTES																					
	X	1.	THESE CABLE ASSEMBLIES CONSIST OF 100% 26BY WIRE IN CABLE UNLESS OTHERWISE SPECIFIED.																			
X	2.	UNLESS OTHERWISE SPECIFIED, ALL DIMENSIONS ARE IN METRICS (CM). EQUIVALENT INCH DIMENSIONS ARE ENCLOSED IN BRACKETS.																				
X	3.	DIMENSIONS 12 INCHES AND OVER ARE EXPRESSED IN FEET AND INCHES. ALL OTHER DIMENSIONS ARE IN INCHES.																				
X	4.	THE "X" DIMENSIONS SHALL BE OBTAINED FROM THE JOB SPECIFICATION. UNLESS OTHERWISE SPECIFIED ALL DIMENSIONS WILL HOLD A LENGTH TOLERANCE AS FOLLOWS:																				
		<table border="0"> <tr> <td>METRIC</td> <td>TOLERANCE</td> <td>ENGLISH</td> <td>TOLERANCE</td> </tr> <tr> <td>LENGTH</td> <td>-----</td> <td>LENGTH</td> <td>-----</td> </tr> <tr> <td>0-1 M</td> <td>+/-1.5 CM</td> <td>{ZERO TO 3' 4"</td> <td>+/-0.5"} 1 M AND UP</td> </tr> <tr> <td></td> <td>+/-1.5%</td> <td>{3' 4" & UP</td> <td>+/-1.5%}</td> </tr> <tr> <td></td> <td></td> <td>ROUNDED UP TO 1 CM OR 0.5"</td> <td></td> </tr> </table>	METRIC	TOLERANCE	ENGLISH	TOLERANCE	LENGTH	-----	LENGTH	-----	0-1 M	+/-1.5 CM	{ZERO TO 3' 4"	+/-0.5"} 1 M AND UP		+/-1.5%	{3' 4" & UP	+/-1.5%}			ROUNDED UP TO 1 CM OR 0.5"	
METRIC	TOLERANCE	ENGLISH	TOLERANCE																			
LENGTH	-----	LENGTH	-----																			
0-1 M	+/-1.5 CM	{ZERO TO 3' 4"	+/-0.5"} 1 M AND UP																			
	+/-1.5%	{3' 4" & UP	+/-1.5%}																			
		ROUNDED UP TO 1 CM OR 0.5"																				
X	5.	UNLESS OTHERWISE SPECIFIED REQUIRED SHINERS TO BE DETERMINED BY INDIVIDUAL MANUFACTURING LOCATION. (SEE MANUFACTURING LAYOUT).																				
X	6.	TIE THE UNSHEATHED 'B' END WITH 3 CABLE TIES.																				
	7.	LINED-OUT 'D' AND/OR 'E' DIM IS FOR 982 TYPE OF CONN. NEW DIM IS FOR 963N3 IDC TYPE OF CONN.																				
	8.	* PARTS THAT ARE TO BE SHIPPED ATTACHED TO OR ENCLOSED IN THE SAME CONTAINER WITH THE ASSOCIATED ASSEMBLED ITEM.																				

SEE PROPRIETARY NOTICE ON SHEET ONE

XT13				
5ESS (R) SWITCHING EQUIPMENT CABLE ASSEMBLIES FOR INTEGRATED SERVICES DATA NETWORK				
DWG SIZE C2	ISSUE 53			
<table border="0"> <tr> <td>LUCENT TECHNOLOGIES INC</td> <td>ED5D621-35</td> <td style="text-align: right;">SHEET D1 OF 141</td> </tr> </table>	LUCENT TECHNOLOGIES INC	ED5D621-35	SHEET D1 OF 141	
LUCENT TECHNOLOGIES INC	ED5D621-35	SHEET D1 OF 141		

STOCKLIST								
ITEM NBR	LIST GROUP CODE	QTY PER CODE	PRODUCT IDENTIFIER	CODE	DESCRIPTION	REFERENCE POSITION	NOTE	
							SYM	NBR
1320	11	1	106557762	752A	CABLE,22 GA. 6 PAIRS			4 5
1330	11	1	103125373	982AE	CONNECTOR,ELECTRICAL			
1340	11	1	842923765		RELIEF,STRAIN			
1350	11	1	900714981		TUBING 5/8 ID X 4 IN LONG HEAT SHRINKABLE BLACK #RT876 RAYCHEM CORP.			
1360	11	6	401194410	KS19195L1	WIRE,COPPER 20GA BK			
1365	11	6	407138718		BARRIER,HEAT #K.125 SUMITOMO ELECTRIC /OR EQUIV.			
1370	13	1	106557762	752A	CABLE,22 GA. 6 PAIRS			4 5
1380	13	1	103125373	982AE	CONNECTOR,ELECTRICAL			
1390	13	1	842923765		RELIEF,STRAIN			
1400	13	1	900714981		TUBING 5/8 ID X 4 IN LONG HEAT SHRINKABLE BLACK #RT876 RAYCHEM CORP.			
1410	13	6	401194410	KS19195L1	WIRE,COPPER 20GA BK			
1415	13	6	407138718		BARRIER,HEAT #K.125 SUMITOMO ELECTRIC /OR EQUIV.			
1420	15	1	106557747	758A	CABLE,22 GA. 4 PAIRS			
1430	15	1	103125365	982AD	CONNECTOR,BACKPLANE			
1435	15	1	842923740		RELIEF,STRAIN			
1440	15	1	900714981		TUBING 5/8 ID X 4 IN LONG HEAT SHRINKABLE BLACK #RT876 RAYCHEM CORP.			
1450	15	4	401194410	KS19195L1	WIRE,COPPER 20GA BK			
1455	15	4	407138718		BARRIER,HEAT #K.125 SUMITOMO ELECTRIC /OR EQUIV.			
1460	17	1	403737109	KS19224L1	CABLE,COAXIAL 75 OHMS			4 5
1470	17	1	106197775	982SS	CONNECTOR,ELECTRICAL, ADAPTER 6 CONTACTS, FEMALE, RECTANGULAR			
1480	17	1	900225194		SLEEVE,SOLDER ORANGE INSULATING JACKET #D146-40-3 RAYCHEM CORP.			
1485	17	1	400747887		CONNECTOR #50-128-9512 SEAELECTRO CORP			
1486	17A	2	403942410		LABEL #DAT-34-292-10 BRADY CORP			
1487	17A	1	106007743	735A	CABLE,ELECTRONIC 26GA GRAY			4 5
1488	17A	2	406966747		CONNECTOR,COAXIAL #1702-1571-004 APPLIED ENGINEERING PROD			
1490	19	1	403737109	KS19224L1	CABLE,COAXIAL 75 OHMS			4 5
1500	19	1	106197775	982SS	CONNECTOR,ELECTRICAL, ADAPTER 6 CONTACTS, FEMALE, RECTANGULAR			

***** STOCKLIST CONTINUED AT RIGHT *****

ED5D621-35

STOCKLIST								
ITEM NBR	LIST GROUP CODE	QTY PER CODE	PRODUCT IDENTIFIER	CODE	DESCRIPTION	REFERENCE POSITION	NOTE	
							SYM	NBR
1510	19	1	900225194		SLEEVE,SOLDER ORANGE INSULATING JACKET #D146-40-3 RAYCHEM CORP.			
1520	19	1	400747887		CONNECTOR #50-128-9512 SEAELECTRO CORP			
1525	19A	2	403942410		LABEL #DAT-34-292-10 BRADY CORP			
1526	19A	1	106007743	735A	CABLE,ELECTRONIC 26GA GRAY			4 5
1527	19A	2	406966747		CONNECTOR,COAXIAL #1702-1571-004 APPLIED ENGINEERING PROD			
1550	65A,65B	2	403094956	KS22658L5	CONNECTOR,PLUG 25 POSITION			
1560	65A,65B	1	105412530	812A-4/26	CABLE 26 GAGE			3 4
1570	65A,65B	1	401194428	KS19195L1	WIRE,GROUND 26 GA, SOLID, BK			
1579	65A,65B	2	407326099	KS19196L25	HOOD,CONNECTOR			
1580	65A,65B	2	996975918	KS19196L2	HOOD			
1581	65A,65B	2	803382415	P-338241	STAYBAND,WING			
1590	65C	1	403094956	KS22658L5	CONNECTOR,PLUG 25 POSITION			
1600	65C	1	403094964	KS22658L6	CONNECTOR 25 POSITION D-SUBMINIATURE RECEPTACLE			
1609	65C	2	407326099	KS19196L25	HOOD,CONNECTOR			
1610	65C	2	996975918	KS19196L2	HOOD			
1611	65C	2	803382415	P-338241	STAYBAND,WING			
1620	65C	1	105412530	812A-4/26	CABLE 26 GAGE			3 4
1630	65C	2	401194428	KS19195L1	WIRE,GROUND 26 GA, SOLID, BK			
1640	65D	2	403094956	KS22658L5	CONNECTOR,PLUG 25 POSITION			
1649	65D	2	407326099	KS19196L25	HOOD,CONNECTOR			
1650	65D	2	996975918	KS19196L2	HOOD			
1651	65D	2	803382415	P-338241	STAYBAND,WING			
1660	65D	1	105412530	812A-4/26	CABLE 26 GAGE			3 4
1661	65E	2	407326099	KS19196L25	HOOD,CONNECTOR			
1662	65E	2	803382415	P-338241	STAYBAND,WING			
1663	65E	1	105412530	812A-4/26	CABLE 26 GAGE			
1664	65E	2	403094956	KS22658L5	CONNECTOR,PLUG 25 POSITION			
2500	101,300	1	105412415	800A	CABLE 26GA, VARIABLE LENGTH			4 5

STOCKLIST CONTINUED ON SHEET D3

SEE PROPRIETARY NOTICE ON SHEET ONE

XT13

5ESS (R) SWITCHING EQUIPMENT
CABLE ASSEMBLIES
FOR
INTEGRATED SERVICES DATA NETWORK

DWG SIZE
C2

ISSUE
53

LUCENT TECHNOLOGIES INC ED5D621-35

SHEET D2
OF 141

STOCKLIST								
ITEM NBR	LIST GROUP CODE	QTY PER CODE	PRODUCT IDENTIFIER	CODE	DESCRIPTION	REFERENCE POSITION	NOTE	
							SYM	NBR
2510	101	2	105772826	963T-24	CONNECTOR			
2511	101	4	106904956	TCOV-NS24G	COVER, PROTECTIVE			
2520	101	1	105772818	963T-16	CONNECTOR			
2521	101	2	106904923	TCOV-NS16G	COVER, PROTECTIVE			
2540	103,301	1	105412415	800A	CABLE 26GA, VARIABLE LENGTH			
2550	103	2	105772826	963T-24	CONNECTOR			
2551	103	4	106904956	TCOV-NS24G	COVER, PROTECTIVE			
2560	103	1	105772818	963T-16	CONNECTOR			
2561	103	2	106904923	TCOV-NS16G	COVER, PROTECTIVE			
2580	105,105A, 302,303	1	105412498	808A32/26	CABLE, ELECTRONIC 26GA CONVENIENT LENGTH PACKAGES UL LISTED CMR		4 5	
2590	105	16	105772784	963T-6	CONNECTOR			
2591	105	32	106905425	TCOV-LS6G	COVER, PROTECTIVE			
2594	105A	14	105772784	963T-6	CONNECTOR			
2595	105A	28	106905425	TCOV-LS6G	COVER, PROTECTIVE			
3020	109,304	1	105412423	801A-60C/26	CABLE, ELECTRONIC		4 5	
3030	109	2	105772826	963T-24	CONNECTOR			
3031	109	4	106904956	TCOV-NS24G	COVER, PROTECTIVE			
3050	111,304A	1	105412423	801A-60C/26	CABLE, ELECTRONIC		4 5	
3080	113,305	1	105412423	801A-60C/26	CABLE, ELECTRONIC		4 5	
3090	113	2	105772826	963T-24	CONNECTOR			
3091	113	4	106904956	TCOV-NS24G	COVER, PROTECTIVE			
3110	115,306	1	105412423	801A-60C/26	CABLE, ELECTRONIC		4 5	
3120	111,115	1	105772826	963T-24	CONNECTOR			
3121	111,115	2	106904956	TCOV-NS24G	COVER, PROTECTIVE			
3200	122	1	105412530	812A-4/26	CABLE 26 GAGE		4 5	
3210	122	1	103125340	982AB	CONNECTOR			
3225	122	1	405189168		PLUG 25 CONTACT #TBS-25PT TRW INC.			
3226	122	1	405184524		HOOD SUPER D ADAPTER SYSTEM, BLACK PLASTIC STRAIGHT WITH TWO CAPTIVE 4-40 SCREWS #SDH-25BFCS TRW INC.			
3250	122	1	996512786		GROMMET 5/32 X 7/16 X 9/32 INCHES #374 ATLANTIC INDIA RUBBER WORK /OR EQUIV.			
3260	122	A/R	401194428	KS19195L1	WIRE, GROUND 26 GA, SOLID, BK			
3261	122A, 122B	1	103125340	982AB	CONNECTOR			
3262	122A, 122B	1	405189168		PLUG 25 CONTACT #TBS-25PT TRW INC.			

***** STOCKLIST CONTINUED AT RIGHT *****

ED5D621-35

STOCKLIST								
ITEM NBR	LIST GROUP CODE	QTY PER CODE	PRODUCT IDENTIFIER	CODE	DESCRIPTION	REFERENCE POSITION	NOTE	
							SYM	NBR
3263	122A, 122B	1	405184524		HOOD SUPER D ADAPTER SYSTEM, BLACK PLASTIC STRAIGHT WITH TWO CAPTIVE 4-40 SCREWS #SDH-25BFCS TRW INC. /OR EQUIV.			
3264	122A, 122B	1	996512786		GROMMET 5/32 X 7/16 X 9/32 INCHES #374 ATLANTIC INDIA RUBBER WORK /OR EQUIV.			
3265	122A, 122B	A/R	401194428	KS19195L1	WIRE, GROUND 26 GA, SOLID, BK			
3266	122A, 122B	1	105412530	812A-4/26	CABLE 26 GAGE			
3279	123	1	105412530	812A-4/26	CABLE 26 GAGE			4 5
3280	123	1	103125357	982AC	CONNECTOR, BACKPLANE			
3290	123	1	997082144	KS19088L2	CONNECTOR, PLUG MALE			
3300	123	1	996975918	KS19196L2	HOOD			
3301	123	1	407326099	KS19196L25	HOOD, CONNECTOR			
3310	123	1	803382415	P-338241	STAYBAND, WING			
3320	123	1	996512786		GROMMET 5/32 X 7/16 X 9/32 INCHES #374 ATLANTIC INDIA RUBBER WORK /OR EQUIV.			
3330	123	A/R	401194428	KS19195L1	WIRE, GROUND 26 GA, SOLID, BK			
3335	123A	1	105772800	963T-12	CONNECTOR			
3336	123A	2	106905458	TCOV-LS12G	COVER, PROTECTIVE			
3338	123B	1	103125357	982AC	CONNECTOR, BACKPLANE			
3339	123A, 123B,307	1	105412530	812A-4/26	CABLE 26 GAGE			
3340	123A, 123B,307	1	405189168		PLUG 25 CONTACT #TBS-25PT TRW INC.			
3341	123A, 123B,307	1	405184524		HOOD SUPER D ADAPTER SYSTEM, BLACK PLASTIC STRAIGHT WITH TWO CAPTIVE 4-40 SCREWS #SDH-25BFCS TRW INC.			
3342	123A, 123B,307	1	996512786		GROMMET 5/32 X 7/16 X 9/32 INCHES #374 ATLANTIC INDIA RUBBER WORK /OR EQUIV.			
3343	123B	A/R	401194428	KS19195L1	WIRE, GROUND 26 GA, SOLID, BK			
3349	124,124B	1	104315213	1024002	CABLE, 24GA, 2000FTLG			
3350	124,124A, 124B, 124D	1	100325166	255A	JACK, MOUNTING			

STOCKLIST CONTINUED ON SHEET D4

SEE PROPRIETARY NOTICE ON SHEET ONE

XT13

5ESS (R) SWITCHING EQUIPMENT
CABLE ASSEMBLIES
FOR
INTEGRATED SERVICES DATA NETWORK

DWG SIZE
C2

ISSUE
53

LUCENT TECHNOLOGIES INC ED5D621-35

SHEET D3
OF 141

STOCKLIST									
ITEM NBR	LIST GROUP CODE	QTY PER CODE	PRODUCT IDENTIFIER	CODE	DESCRIPTION	REFERENCE POSITION	NOTE		
							SYM	NBR	
3355	124B	2	406736009		JACK, LONG FRAME #PJ318 ADC TELECOMMUNICATIONS INC				
3357	124B, 124D	1	400811519		LABEL, WIRE MARKER #WM-B-CAP W. H. BRADY CO.				
3358	124B	1	405961186		CAPACITOR 50 UF #TVAN1117 SPRAGUE				
3359	124B	1	400729695	KS20616L1A	RESISTOR 49.9 OHM				
3360	124,124A	2	100274570	223A	JACK				
3367	124A, 124D	1	102858917	M4AS-87	CORD STANDARD INDIVIDUAL PACK				
3368	124D	2	406864991		JACK, PHONE #MT332B RAYTHEON CO.				
3370	124,124B	1	402823892		PLUG #PJ7 ADC TELECOMMUNICATIONS CO.				
3371	124,124A, 124D	2	802432484	P-243248	WASHER, INTERNAL .138				
3372	126	2	105772784	963T-6	CONNECTOR				
3373	126	4	106905425	TCOV-LS6G	COVER, PROTECTIVE				
3375	126,308	1	105412530	812A-4/26	CABLE 26 GAGE				
3384	127	1	106197775	982SS	CONNECTOR, ELECTRICAL, ADAPTER 6 CONTACTS, FEMALE, RECTANGULAR				
3390	127	1	105412530	812A-4/26	CABLE 26 GAGE				
3394	127A	1	105772826	963T-24	CONNECTOR				
3395	127A	2	106904956	TCOV-NS24G	COVER, PROTECTIVE				
3400	127A,309	1	105412530	812A-4/26	CABLE 26 GAGE				
3403	128	1	403601883		CORD, POWER 14GA 3 CONDUCTOR SJT LT BL GR-Y & BR #19354 BELDEN CORP.				
3404	128	1	402993778		HOUSING #350766-1 AMP INC.				
3405	128	2	403780612		RELIEF, STRAIN NYLON #641945-1 AMP INC.				
3410	128	3	403941420		CONTACT, SOCKET #350874-1 AMP INC.				
3420	128	2	802510289	P-251028	SCREW, PAN HEAD SELF TAPPING .138-32 X 3/8				
3425	129A	1	105412530	812A-4/26	CABLE 26 GAGE				
3426	129A	8	401694997		TERMINAL #52924 AMP INC				
3430	131	1	403857774		CABLE #9505 BELDON CORP				3 5
3435	131	1	400454666		SOCKET, 2 PIN #S302CCT H.B.JONES				
3440	131	1	997650023		SOCKET, 4 PIN #S304CCT H.B.JONES				

***** STOCKLIST CONTINUED AT RIGHT *****

ED5D621-35

STOCKLIST									
ITEM NBR	LIST GROUP CODE	QTY PER CODE	PRODUCT IDENTIFIER	CODE	DESCRIPTION	REFERENCE POSITION	NOTE		
							SYM	NBR	
3445	131	1	405239484		PLUG 15 PIN #TA-15PS TRW CINCH MFG CO.				
3450	131	1	403445596		HOOD #SDH-15BL TRW INC.				
3460	131	2	900700535		TUBING, HEAT SHRINKABLE 3/16IN. ID .1875 IN. SHRINK SEMI RIGID BLACK FIT 254 FT LONG				
3465	131	2	900819699		TUBING HEATSHRINKABLE RED #RT876 RAYCHEM CORP				
3470	131	1	900293283		TUBING, HEAT SHRINKABLE 3/8 IN. X 2 IN. BLACK #RT876 RAYCHEM CORP.				
3476	131	1	900658394		TUBING, HEAT SHRINKABLE 1/8ID X 2 IN BLACK #RT876 RAYCHEM CORP. /OR EQUIV.				
3500	132	1	403857774		CABLE #9505 BELDON CORP				3 5
3505	132	1	400454666		SOCKET, 2 PIN #S302CCT H.B.JONES				
3510	132	1	402469985		SOCKET, 8 PIN #S308CCT H.B.JONES				
3515	132	1	405239484		PLUG 15 PIN #TA-15PS TRW CINCH MFG CO.				
3520	132	1	403445596		HOOD #SDH-15BL TRW INC.				
3530	132	2	900700535		TUBING, HEAT SHRINKABLE 3/16IN. ID .1875 IN. SHRINK SEMI RIGID BLACK FIT 254 FT LONG				
3535	132	2	900819699		TUBING HEATSHRINKABLE RED #RT876 RAYCHEM CORP				
3540	132	1	900293283		TUBING, HEAT SHRINKABLE 3/8 IN. X 2 IN. BLACK #RT876 RAYCHEM CORP.				
3546	132	1	900658394		TUBING, HEAT SHRINKABLE 1/8ID X 2 IN BLACK #RT876 RAYCHEM CORP. /OR EQUIV.				
3570	133	1	403857774		CABLE #9505 BELDON CORP				3 5
3575	133	1	400454666		SOCKET, 2 PIN #S302CCT H.B.JONES				

STOCKLIST CONTINUED ON SHEET D5

SEE PROPRIETARY NOTICE ON SHEET ONE

XT13

5ESS (R) SWITCHING EQUIPMENT
CABLE ASSEMBLIES
FOR
INTEGRATED SERVICES DATA NETWORK

DWG SIZE
C2

ISSUE
53

LUCENT TECHNOLOGIES INC ED5D621-35

SHEET D4
OF 141

PRINTED IN U.S.A.

STOCKLIST									
ITEM NBR	LIST GROUP CODE	QTY PER CODE	PRODUCT IDENTIFIER	CODE	DESCRIPTION	REFERENCE POSITION	NOTE		
							SYM	NBR	
3580	133	1	997650023		SOCKET,4 PIN #S304CCT H.B.JONES				
3585	133	1	405239484		PLUG 15 PIN #TA-15PS TRW CINCH MFG CO.				
3590	133	1	403445596		HOOD #SDH-15BL TRW INC.				
3600	133	2	900700535		TUBING,HEAT SHRINKABLE 3/16IN. ID .1875 IN. SHRINK SEMI RIGID BLACK FIT 254 FT LONG				
3605	133	2	900819699		TUBING HEATSHRINKABLE RED #RT876 RAYCHEM CORP				
3610	133	1	900293283		TUBING,HEAT SHRINKABLE 3/8 IN.X 2 IN. BLACK #RT876 RAYCHEM CORP.				
3616	133	1	900658394		TUBING,HEAT SHRINKABLE 1/8ID X 2 IN BLACK #RT876 RAYCHEM CORP. /OR EQUIV.				
3617	134	2	406671495		PLUG,ELECTRONIC MODULAR 8-2PC, 8 CONTACTS, LOAD BAR PROVIDED FOR WIRETERMIN ATION #940-SP-014-308 STEWART STAMPING CORP.				
3618	134	1	107193435	#1061COR 4/24 R	CABLE,ELECTRICAL 1000				
3620	135	1	105412530	812A-4/26	CABLE 26 GAGE				
3630	135	1	403868839		PLUG,MODULAR 4 PRONG FIELD INSTALLED #TCAP8 THOMAS & BETTS CORP. /OR EQUIV.				
3640	136	1	105412530	812A-4/26	CABLE 26 GAGE				
3645	136	1	403971526		PLUG #TCAP4 THOMAS & BETTS CO. /OR EQUIV.				
3650	137	1	407027374		CONNECTOR,CABLE #940-SP-3066R STEWART CONNECTOR SYS INC.				
3652	137	1	105412530	812A-4/26	CABLE 26 GAGE				4 5
3655	138,138B	1	406671495		PLUG,ELECTRONIC MODULAR 8-2PC, 8 CONTACTS, LOAD BAR PROVIDED FOR WIRETERMIN ATION #940-SP-014-308 STEWART STAMPING CORP.				
3657	138,138B	1	105412530	812A-4/26	CABLE 26 GAGE				4 5
3660	139	1	842352650		PLUG (RJ45)				
3661	139	1	403094964	KS22658L6	CONNECTOR 25 POSITION D-SUBMINIATURE RECEPTACLE				
3662	139	1	845029503		HOOD,CONNECTOR BOTTOM HALF				
3663	139	1	845029495		HOOD,CONNECTOR TOP HALF				
3664	139	1	996512786		GROMMET 5/32 X 7/16 X 9/32 INCHES #374 ATLANTIC INDIA RUBBER WORK				

***** STOCKLIST CONTINUED AT RIGHT *****

ED5D621-35

STOCKLIST									
ITEM NBR	LIST GROUP CODE	QTY PER CODE	PRODUCT IDENTIFIER	CODE	DESCRIPTION	REFERENCE POSITION	NOTE		
							SYM	NBR	
3665	139	1	845033075		CORDAGE,JACKETED				
3666	139	2	901079517		SCREW,PAN HEAD .112-40 X 11/16				
3668	139	1	403256381		LABEL,SELF LAMINATION #B292 BRADY CO.				
3670	140	1	406671495		PLUG,ELECTRONIC MODULAR 8-2PC, 8 CONTACTS, LOAD BAR PROVIDED FOR WIRETERMIN ATION #940-SP-014-308 STEWART STAMPING CORP.				
3674	140	1	105412530	812A-4/26	CABLE 26 GAGE				
3676	140	1	997259890	KS16690L3	CONNECTOR,RECEPTACLE				
3710	141	1	105412530	812A-4/26	CABLE 26 GAGE				
3720	141	1	403868839		PLUG,MODULAR 4 PRONG FIELD INSTALLED #TCAP8 THOMAS & BETTS CORP.				
3730	142	1	105412530	812A-4/26	CABLE 26 GAGE				
3740	142	1	403868839		PLUG,MODULAR 4 PRONG FIELD INSTALLED #TCAP8 THOMAS & BETTS CORP.				
3750	143	1	105412530	812A-4/26	CABLE 26 GAGE				
3755	143	2	403094956	KS22658L5	CONNECTOR,PLUG 25 POSITION				
3766	143,144	2	996975918	KS19196L2	HOOD				
3767	143,144	2	407326099	KS19196L25	HOOD,CONNECTOR				
3770	143	4	401194428	KS19195L1	WIRE,GROUND 26 GA, SOLID, BK				
3780	144	1	105412530	812A-4/26	CABLE 26 GAGE				
3781	143,144	2	803382415	P-338241	STAYBAND,WING				
3785	145A, 145B, 145C, 146A, 146B, 146C	1	406671495		PLUG,ELECTRONIC MODULAR 8-2PC, 8 CONTACTS, LOAD BAR PROVIDED FOR WIRETERMIN ATION #940-SP-014-308 STEWART STAMPING CORP.				
3790	144,145A, 145B, 145C, 146A, 146B, 146C	1	403094956	KS22658L5	CONNECTOR,PLUG 25 POSITION				
3800	144	1	403094964	KS22658L6	CONNECTOR 25 POSITION D-SUBMINIATURE RECEPTACLE				
3811	145,145D, 170,170A, 310,311, 312	1	105412530	812A-4/26	CABLE 26 GAGE				4 5

STOCKLIST CONTINUED ON SHEET D6

SEE PROPRIETARY NOTICE ON SHEET ONE

XT13

5ESS (R) SWITCHING EQUIPMENT
CABLE ASSEMBLIES
FOR
INTEGRATED SERVICES DATA NETWORK

DWG SIZE
C2

ISSUE
53

LUCENT TECHNOLOGIES INC ED5D621-35

SHEET D5
OF 141

PRINTED IN U.S.A.

STOCKLIST								
ITEM NBR	LIST GROUP CODE	QTY PER CODE	PRODUCT IDENTIFIER	CODE	DESCRIPTION	REFERENCE POSITION	NOTE	
							SYM	NBR
3812	145,145D,170,170A	1	105772784	963T-6	CONNECTOR			
3813	145,145D,170,170A	2	106905425	TCOV-LS6G	COVER,PROTECTIVE			
3815	172	A/R	105412563	816A-6/26	CABLE UL LISTED TYPE CMR 26GA			
3817	172	2	103125340	982AB	CONNECTOR			
3819	172	2	106197775	982SS	CONNECTOR,ELECTRICAL, ADAPTER 6 CONTACTS, FEMALE, RECTANGULAR			
3822	174	A/R	105412530	812A-4/26	CABLE 26 GAGE			
3824	174	4	106197775	982SS	CONNECTOR,ELECTRICAL, ADAPTER 6 CONTACTS, FEMALE, RECTANGULAR			
3830	145A,145B,145C,146A,146B,146C	1	105267900	1844006A	CABLE,ELECTRONIC 26GA, 6 PAIR SHIELDED			
3845	145A,145B,145C,146A,146B,146C	1	996975918	KS19196L2	HOOD			
3846	145A,145B,145C,146A,146B,146C	1	407326099	KS19196L25	HOOD,CONNECTOR			
3850	147A,147B,147C	1	406671495		PLUG,ELECTRONIC MODULAR 8-2PC, 8 CONTACTS, LOAD BAR PROVIDED FOR WIRETERMINATION #940-SP-014-308 STEWART STAMPING CORP.			
3855	147A,147B,147C	1	403094956	KS22658L5	CONNECTOR,PLUG 25 POSITION			
3865	147A	1	105412530	812A-4/26	CABLE 26 GAGE A DIMENSION = 7 FEET 0 INCH			
3870	147B	1	105412530	812A-4/26	CABLE 26 GAGE A DIMENSION = 25 FEET 0 INCH			
3875	147C	1	105412530	812A-4/26	CABLE 26 GAGE A DIMENSION = 50 FEET 0 INCH			
3982	143,144	2	996512786		GROMMET 5/32 X 7/16 X 9/32 INCHES #374 ATLANTIC INDIA RUBBER WORK			
4000	204	1	105412530	812A-4/26	CABLE 26 GAGE			
4002	204	2	845028588		PLUG,MOD			
4004	204	16	844041442		BLADE,PLATE SWAGED			
4010	211A	1	105412514	810A128/26	CABLE			
4020	211A	8	406569376		CONNECTOR,ELECTRICAL PIN, 34 CONTACTS, FEMALE, RECTANGULAR #104800-1 AMP INC.			
4030	211A	8	406567966		COVER,CONNECTOR COV HALF AMP MODU E/W CENTER BAR #104813-1 AMP INC			
4040	211A	8	406567974		COVER,CONNECTOR COVER HALF AMP MODU E/W CENTER BAR #91-5435-2 AMP INC			

***** STOCKLIST CONTINUED AT RIGHT *****

STOCKLIST								
ITEM NBR	LIST GROUP CODE	QTY PER CODE	PRODUCT IDENTIFIER	CODE	DESCRIPTION	REFERENCE POSITION	NOTE	
							SYM	NBR
4050	212A	1	105412514	810A128/26	CABLE			4 5
4060	212A	8	406569376		CONNECTOR,ELECTRICAL PIN, 34 CONTACTS, FEMALE, RECTANGULAR #104800-1 AMP INC.			
4070	212A	8	406567966		COVER,CONNECTOR COV HALF AMP MODU E/W CENTER BAR #104813-1 AMP INC			
4080	212A	8	406567974		COVER,CONNECTOR COVER HALF AMP MODU E/W CENTER BAR #91-5435-2 AMP INC			
4090	213A	1	105412514	810A128/26	CABLE			
4100	213A	8	406569376		CONNECTOR,ELECTRICAL PIN, 34 CONTACTS, FEMALE, RECTANGULAR #104800-1 AMP INC.			
4110	213A	8	406567966		COVER,CONNECTOR COV HALF AMP MODU E/W CENTER BAR #104813-1 AMP INC			
4120	213A	8	406567974		COVER,CONNECTOR COVER HALF AMP MODU E/W CENTER BAR #91-5435-2 AMP INC			
4130	214A	1	105412514	810A128/26	CABLE			4 5
4140	214A	8	406569376		CONNECTOR,ELECTRICAL PIN, 34 CONTACTS, FEMALE, RECTANGULAR #104800-1 AMP INC.			
4150	214A	8	406567966		COVER,CONNECTOR COV HALF AMP MODU E/W CENTER BAR #104813-1 AMP INC			
4160	214A	8	406567974		COVER,CONNECTOR COVER HALF AMP MODU E/W CENTER BAR #91-5435-2 AMP INC			
4170	215A	1	105412514	810A128/26	CABLE			4 5
4180	215A	8	406569376		CONNECTOR,ELECTRICAL PIN, 34 CONTACTS, FEMALE, RECTANGULAR #104800-1 AMP INC.			
4190	215A	8	406567966		COVER,CONNECTOR COV HALF AMP MODU E/W CENTER BAR #104813-1 AMP INC			
4200	215A	8	406567974		COVER,CONNECTOR COVER HALF AMP MODU E/W CENTER BAR #91-5435-2 AMP INC			
4210	216A	1	105412514	810A128/26	CABLE			4 5

STOCKLIST CONTINUED ON SHEET D7

SEE PROPRIETARY NOTICE ON SHEET ONE

XT13

5ESS (R) SWITCHING EQUIPMENT
CABLE ASSEMBLIES
FOR
INTEGRATED SERVICES DATA NETWORK

DWG SIZE
C2

ISSUE
53

STOCKLIST									
ITEM NBR	LIST GROUP CODE	QTY PER CODE	PRODUCT IDENTIFIER	CODE	DESCRIPTION	REFERENCE POSITION	NOTE		
							SYM	NBR	
4220	216A	8	406569376		CONNECTOR,ELECTRICAL PIN, 34 CONTACTS, FEMALE, RECTANGULAR #104800-1 AMP INC.				
4230	216A	8	406567966		COVER,CONNECTOR COV HALF AMP MODU E/W CENTER BAR #104813-1 AMP INC				
4240	216A	8	406567974		COVER,CONNECTOR COVER HALF AMP MODU E/W CENTER BAR #91-5435-2 AMP INC				
4250	217A	1	105412514	810A128/26	CABLE			4	5
4260	217A	8	406569376		CONNECTOR,ELECTRICAL PIN, 34 CONTACTS, FEMALE, RECTANGULAR #104800-1 AMP INC.				
4270	217A	8	406567966		COVER,CONNECTOR COV HALF AMP MODU E/W CENTER BAR #104813-1 AMP INC				
4280	217A	8	406567974		COVER,CONNECTOR COVER HALF AMP MODU E/W CENTER BAR #91-5435-2 AMP INC				
4290	218A	1	105412514	810A128/26	CABLE			4	5
4300	218A	8	406569376		CONNECTOR,ELECTRICAL PIN, 34 CONTACTS, FEMALE, RECTANGULAR #104800-1 AMP INC.				
4310	218A	8	406567966		COVER,CONNECTOR COV HALF AMP MODU E/W CENTER BAR #104813-1 AMP INC				
4320	218A	8	406567974		COVER,CONNECTOR COVER HALF AMP MODU E/W CENTER BAR #91-5435-2 AMP INC				
4330	219, 219A, 219B	1	105412910	285A-4/22	CABLE,ELECTRONIC 22 GA			4	5
4340	219, 219A, 219B	4	106787385	963T2-6	CONNECTOR,CABLE				
4341	219, 219A, 219B	8	106905425	TCOV-LS6G	COVER,PROTECTIVE				
4350	220, 220A, 220B	1	105412910	285A-4/22	CABLE,ELECTRONIC 22 GA			4	5
4360	220, 220A, 220B	4	106787385	963T2-6	CONNECTOR,CABLE				
4361	220, 220A, 220B	8	106905425	TCOV-LS6G	COVER,PROTECTIVE				
4400	219N, 220N	1	105412910	285A-4/22	CABLE,ELECTRONIC 22 GA			4	5
4410	219N, 220N	4	406922161		CONNECTOR #966061-6 AMP INC.				
4420	219N, 220N	8	406885673		COVER,CONNECTOR #2-964393-3 AMP INC.			4	5
4430	219N, 220N	4	901250928		SLEEVE,PROTECTIVE				
4440	219N, 220N	4	400890067		TIE,CABLE #PLT1.5M-C PANDUIT CORP.				
4500	221A	1	105412514	810A128/26	CABLE			4	5

***** STOCKLIST CONTINUED AT RIGHT *****

ED5D621-35

STOCKLIST									
ITEM NBR	LIST GROUP CODE	QTY PER CODE	PRODUCT IDENTIFIER	CODE	DESCRIPTION	REFERENCE POSITION	NOTE		
							SYM	NBR	
4510	221A	8	406569376		CONNECTOR,ELECTRICAL PIN, 34 CONTACTS, FEMALE, RECTANGULAR #104800-1 AMP INC.				
4520	221A	8	406567966		COVER,CONNECTOR COV HALF AMP MODU E/W CENTER BAR #104813-1 AMP INC				
4530	221A	8	406567974		COVER,CONNECTOR COVER HALF AMP MODU E/W CENTER BAR #91-5435-2 AMP INC				
4535	221C, 221D	1	105412506	809A-64/26	CABLE 26GA., CONVENIENT LENGTH PACKAGES				
4536	221C, 221D	4	406569376		CONNECTOR,ELECTRICAL PIN, 34 CONTACTS, FEMALE, RECTANGULAR #104800-1 AMP INC.				
4537	221C, 221D	4	406567966		COVER,CONNECTOR COV HALF AMP MODU E/W CENTER BAR #104813-1 AMP INC				
4538	221C, 221D	4	406567974		COVER,CONNECTOR COVER HALF AMP MODU E/W CENTER BAR #91-5435-2 AMP INC				
4540	222A	1	105412514	810A128/26	CABLE			4	5
4550	222A	8	406569376		CONNECTOR,ELECTRICAL PIN, 34 CONTACTS, FEMALE, RECTANGULAR #104800-1 AMP INC.				
4560	222A	8	406567966		COVER,CONNECTOR COV HALF AMP MODU E/W CENTER BAR #104813-1 AMP INC				
4570	222A	8	406567974		COVER,CONNECTOR COVER HALF AMP MODU E/W CENTER BAR #91-5435-2 AMP INC				
4575	222C, 222D	1	105412506	809A-64/26	CABLE 26GA., CONVENIENT LENGTH PACKAGES				
4576	222C, 222D	4	406569376		CONNECTOR,ELECTRICAL PIN, 34 CONTACTS, FEMALE, RECTANGULAR #104800-1 AMP INC.				
4577	222C, 222D	4	406567966		COVER,CONNECTOR COV HALF AMP MODU E/W CENTER BAR #104813-1 AMP INC				
4578	222C, 222D	4	406567974		COVER,CONNECTOR COVER HALF AMP MODU E/W CENTER BAR #91-5435-2 AMP INC				
4580	223A	1	105412514	810A128/26	CABLE			4	5
4590	223A	8	406569376		CONNECTOR,ELECTRICAL PIN, 34 CONTACTS, FEMALE, RECTANGULAR #104800-1 AMP INC.				

STOCKLIST CONTINUED ON SHEET D8

SEE PROPRIETARY NOTICE ON SHEET ONE

XT13

5ESS (R) SWITCHING EQUIPMENT
CABLE ASSEMBLIES
FOR
INTEGRATED SERVICES DATA NETWORK

DWG SIZE
C2

ISSUE
53

LUCENT TECHNOLOGIES INC ED5D621-35

SHEET D7
OF 141

STOCKLIST								
ITEM NBR	LIST GROUP CODE	QTY PER CODE	PRODUCT IDENTIFIER	CODE	DESCRIPTION	REFERENCE POSITION	NOTE	
							SYM	NBR
4600	223A	8	406567966		COVER,CONNECTOR COV HALF AMP MODU E/W CENTER BAR #104813-1 AMP INC			
4610	223A	8	406567974		COVER,CONNECTOR COVER HALF AMP MODU E/W CENTER BAR #91-5435-2 AMP INC			
4615	223C, 223D	1	105412506	809A-64/26	CABLE 26GA., CONVENIENT LENGTH PACKAGES			
4616	223C, 223D	4	406569376		CONNECTOR,ELECTRICAL PIN, 34 CONTACTS, FEMALE, RECTANGULAR #104800-1 AMP INC.			
4617	223C, 223D	4	406567966		COVER,CONNECTOR COV HALF AMP MODU E/W CENTER BAR #104813-1 AMP INC			
4618	223C, 223D	4	406567974		COVER,CONNECTOR COVER HALF AMP MODU E/W CENTER BAR #91-5435-2 AMP INC			
4620	224A	1	105412514	810A128/26	CABLE			4 5
4630	224A	8	406569376		CONNECTOR,ELECTRICAL PIN, 34 CONTACTS, FEMALE, RECTANGULAR #104800-1 AMP INC.			
4640	224A	8	406567966		COVER,CONNECTOR COV HALF AMP MODU E/W CENTER BAR #104813-1 AMP INC			
4650	224A	8	406567974		COVER,CONNECTOR COVER HALF AMP MODU E/W CENTER BAR #91-5435-2 AMP INC			
4655	224C, 224D	1	105412506	809A-64/26	CABLE 26GA., CONVENIENT LENGTH PACKAGES			
4656	224C, 224D	4	406569376		CONNECTOR,ELECTRICAL PIN, 34 CONTACTS, FEMALE, RECTANGULAR #104800-1 AMP INC.			
4657	224C, 224D	4	406567966		COVER,CONNECTOR COV HALF AMP MODU E/W CENTER BAR #104813-1 AMP INC			
4658	224C, 224D	4	406567974		COVER,CONNECTOR COVER HALF AMP MODU E/W CENTER BAR #91-5435-2 AMP INC			
4660	231A	1	105412498	808A32/26	CABLE,ELECTRONIC 26GA CONVENIENT LENGTH PACKAGES UL LISTED CMR			4 5
4670	231A	8	406569376		CONNECTOR,ELECTRICAL PIN, 34 CONTACTS, FEMALE, RECTANGULAR #104800-1 AMP INC.			
4680	231A	8	406567966		COVER,CONNECTOR COV HALF AMP MODU E/W CENTER BAR #104813-1 AMP INC			
4690	231A	8	406567974		COVER,CONNECTOR COVER HALF AMP MODU E/W CENTER BAR #91-5435-2 AMP INC			
4700	232A	1	105412498	808A32/26	CABLE,ELECTRONIC 26GA CONVENIENT LENGTH PACKAGES UL LISTED CMR			4 5
4710	232A	8	406569376		CONNECTOR,ELECTRICAL PIN, 34 CONTACTS, FEMALE, RECTANGULAR #104800-1 AMP INC.			

***** STOCKLIST CONTINUED AT RIGHT *****

ED5D621-35

STOCKLIST								
ITEM NBR	LIST GROUP CODE	QTY PER CODE	PRODUCT IDENTIFIER	CODE	DESCRIPTION	REFERENCE POSITION	NOTE	
							SYM	NBR
4720	232A	8	406567966		COVER,CONNECTOR COV HALF AMP MODU E/W CENTER BAR #104813-1 AMP INC			
4730	232A	8	406567974		COVER,CONNECTOR COVER HALF AMP MODU E/W CENTER BAR #91-5435-2 AMP INC			
4740	233A	1	105412498	808A32/26	CABLE,ELECTRONIC 26GA CONVENIENT LENGTH PACKAGES UL LISTED CMR			4 5
4750	233A	8	406569376		CONNECTOR,ELECTRICAL PIN, 34 CONTACTS, FEMALE, RECTANGULAR #104800-1 AMP INC.			
4760	233A	8	406567966		COVER,CONNECTOR COV HALF AMP MODU E/W CENTER BAR #104813-1 AMP INC			
4770	233A	8	406567974		COVER,CONNECTOR COVER HALF AMP MODU E/W CENTER BAR #91-5435-2 AMP INC			
4780	234A	1	105412498	808A32/26	CABLE,ELECTRONIC 26GA CONVENIENT LENGTH PACKAGES UL LISTED CMR			4 5
4790	234A	8	406569376		CONNECTOR,ELECTRICAL PIN, 34 CONTACTS, FEMALE, RECTANGULAR #104800-1 AMP INC.			
4800	234A	8	406567966		COVER,CONNECTOR COV HALF AMP MODU E/W CENTER BAR #104813-1 AMP INC			
4810	234A	8	406567974		COVER,CONNECTOR COVER HALF AMP MODU E/W CENTER BAR #91-5435-2 AMP INC			
4820	235A	1	105412514	810A128/26	CABLE			4 5
4825	235A	16	406569376		CONNECTOR,ELECTRICAL PIN, 34 CONTACTS, FEMALE, RECTANGULAR #104800-1 AMP INC.			
4830	235A	16	406567966		COVER,CONNECTOR COV HALF AMP MODU E/W CENTER BAR #104813-1 AMP INC			
4840	235A	16	406567974		COVER,CONNECTOR COVER HALF AMP MODU E/W CENTER BAR #91-5435-2 AMP INC			
4845	236A	1	105412514	810A128/26	CABLE			4 5
4850	236A	16	406569376		CONNECTOR,ELECTRICAL PIN, 34 CONTACTS, FEMALE, RECTANGULAR #104800-1 AMP INC.			
4855	236A	16	406567966		COVER,CONNECTOR COV HALF AMP MODU E/W CENTER BAR #104813-1 AMP INC			

STOCKLIST CONTINUED ON SHEET D9

SEE PROPRIETARY NOTICE ON SHEET ONE

XT13

5ESS (R) SWITCHING EQUIPMENT
CABLE ASSEMBLIES
FOR
INTEGRATED SERVICES DATA NETWORK

DWG SIZE
C2

ISSUE
53

LUCENT TECHNOLOGIES INC ED5D621-35

SHEET D8
OF 141

STOCKLIST								
ITEM NBR	LIST GROUP CODE	QTY PER CODE	PRODUCT IDENTIFIER	CODE	DESCRIPTION	REFERENCE POSITION	NOTE	
							SYM	NBR
4860	236A	16	406567974		COVER,CONNECTOR COVER HALF AMP MODU E/W CENTER BAR #91-5435-2 AMP INC			
4865	237A	1	105412514	810A128/26	CABLE		4 5	
4870	237A	16	406569376		CONNECTOR,ELECTRICAL PIN, 34 CONTACTS, FEMALE, RECTANGULAR #104800-1 AMP INC.			
4875	237A	16	406567966		COVER,CONNECTOR COV HALF AMP MODU E/W CENTER BAR #104813-1 AMP INC			
4880	237A	16	406567974		COVER,CONNECTOR COVER HALF AMP MODU E/W CENTER BAR #91-5435-2 AMP INC			
4885	238A	1	105412514	810A128/26	CABLE		4 5	
4890	238A	16	406569376		CONNECTOR,ELECTRICAL PIN, 34 CONTACTS, FEMALE, RECTANGULAR #104800-1 AMP INC.			
4895	238A	16	406567966		COVER,CONNECTOR COV HALF AMP MODU E/W CENTER BAR #104813-1 AMP INC			
4900	238A	16	406567974		COVER,CONNECTOR COVER HALF AMP MODU E/W CENTER BAR #91-5435-2 AMP INC			
4910	241A	1	105412506	809A-64/26	CABLE 26GA., CONVENIENT LENGTH PACKAGES		4 5	
4911	241A	8	406569376		CONNECTOR,ELECTRICAL PIN, 34 CONTACTS, FEMALE, RECTANGULAR #104800-1 AMP INC.			
4912	241A	8	406567966		COVER,CONNECTOR COV HALF AMP MODU E/W CENTER BAR #104813-1 AMP INC			
4913	241A	8	406567974		COVER,CONNECTOR COVER HALF AMP MODU E/W CENTER BAR #91-5435-2 AMP INC			
4920	242A	1	105412506	809A-64/26	CABLE 26GA., CONVENIENT LENGTH PACKAGES		4 5	
4921	242A	8	406569376		CONNECTOR,ELECTRICAL PIN, 34 CONTACTS, FEMALE, RECTANGULAR #104800-1 AMP INC.			
4922	242A	8	406567966		COVER,CONNECTOR COV HALF AMP MODU E/W CENTER BAR #104813-1 AMP INC			
4923	242A	8	406567974		COVER,CONNECTOR COVER HALF AMP MODU E/W CENTER BAR #91-5435-2 AMP INC			
4930	243A	1	105412506	809A-64/26	CABLE 26GA., CONVENIENT LENGTH PACKAGES		4 5	
4931	243A	8	406569376		CONNECTOR,ELECTRICAL PIN, 34 CONTACTS, FEMALE, RECTANGULAR #104800-1 AMP INC.			
4932	243A	8	406567966		COVER,CONNECTOR COV HALF AMP MODU E/W CENTER BAR #104813-1 AMP INC			

***** STOCKLIST CONTINUED AT RIGHT *****

ED5D621-35

STOCKLIST								
ITEM NBR	LIST GROUP CODE	QTY PER CODE	PRODUCT IDENTIFIER	CODE	DESCRIPTION	REFERENCE POSITION	NOTE	
							SYM	NBR
4933	243A	8	406567974		COVER,CONNECTOR COVER HALF AMP MODU E/W CENTER BAR #91-5435-2 AMP INC			
4940	244A	1	105412506	809A-64/26	CABLE 26GA., CONVENIENT LENGTH PACKAGES		4 5	
4941	244A	8	406569376		CONNECTOR,ELECTRICAL PIN, 34 CONTACTS, FEMALE, RECTANGULAR #104800-1 AMP INC.			
4942	244A	8	406567966		COVER,CONNECTOR COV HALF AMP MODU E/W CENTER BAR #104813-1 AMP INC			
4943	244A	8	406567974		COVER,CONNECTOR COVER HALF AMP MODU E/W CENTER BAR #91-5435-2 AMP INC			
4950	245A	1	105412506	809A-64/26	CABLE 26GA., CONVENIENT LENGTH PACKAGES		4 5	
4951	245A	8	406569376		CONNECTOR,ELECTRICAL PIN, 34 CONTACTS, FEMALE, RECTANGULAR #104800-1 AMP INC.			
4952	245A	8	406567966		COVER,CONNECTOR COV HALF AMP MODU E/W CENTER BAR #104813-1 AMP INC			
4953	245A	8	406567974		COVER,CONNECTOR COVER HALF AMP MODU E/W CENTER BAR #91-5435-2 AMP INC			
4960	246A	1	105412506	809A-64/26	CABLE 26GA., CONVENIENT LENGTH PACKAGES		4 5	
4961	246A	8	406569376		CONNECTOR,ELECTRICAL PIN, 34 CONTACTS, FEMALE, RECTANGULAR #104800-1 AMP INC.			
4962	246A	8	406567966		COVER,CONNECTOR COV HALF AMP MODU E/W CENTER BAR #104813-1 AMP INC			
4963	246A	8	406567974		COVER,CONNECTOR COVER HALF AMP MODU E/W CENTER BAR #91-5435-2 AMP INC			
4970	247A	1	105412506	809A-64/26	CABLE 26GA., CONVENIENT LENGTH PACKAGES		4 5	
4971	247A	8	406569376		CONNECTOR,ELECTRICAL PIN, 34 CONTACTS, FEMALE, RECTANGULAR #104800-1 AMP INC.			
4972	247A	8	406567966		COVER,CONNECTOR COV HALF AMP MODU E/W CENTER BAR #104813-1 AMP INC			
4973	247A	8	406567974		COVER,CONNECTOR COVER HALF AMP MODU E/W CENTER BAR #91-5435-2 AMP INC			

STOCKLIST CONTINUED ON SHEET D10

SEE PROPRIETARY NOTICE ON SHEET ONE	
XT13	
5ESS (R) SWITCHING EQUIPMENT CABLE ASSEMBLIES FOR INTEGRATED SERVICES DATA NETWORK	
DWG SIZE C2	ISSUE 53
LUCENT TECHNOLOGIES INC ED5D621-35	
SHEET D9 OF 141	

STOCKLIST									
ITEM NBR	LIST GROUP CODE	QTY PER CODE	PRODUCT IDENTIFIER	CODE	DESCRIPTION	REFERENCE POSITION	NOTE		
							SYM	NBR	
4980	248A	1	105412506	809A-64/26	CABLE 26GA., CONVENIENT LENGTH PACKAGES			4	5
4981	248A	8	406569376		CONNECTOR,ELECTRICAL PIN, 34 CONTACTS, FEMALE, RECTANGULAR #104800-1 AMP INC.				
4982	248A	8	406567966		COVER,CONNECTOR COV HALF AMP MODU E/W CENTER BAR #104813-1 AMP INC				
4983	248A	8	406567974		COVER,CONNECTOR COVER HALF AMP MODU E/W CENTER BAR #91-5435-2 AMP INC				
4985	251A, 252A, 253A, 254A, 255A, 256A, 257A, 258A, 259A, 260A, 261A, 262A, 263A, 264A, 265A, 266A	4	406569376		CONNECTOR,ELECTRICAL PIN, 34 CONTACTS, FEMALE, RECTANGULAR #104800-1 AMP INC.				
4987	251A, 252A, 253A, 254A, 255A, 256A, 257A, 258A, 259A, 260A, 261A, 262A, 263A, 264A, 265A, 266A	4	406567966		COVER,CONNECTOR COV HALF AMP MODU E/W CENTER BAR #104813-1 AMP INC				
4990	251A, 252A, 253A, 254A, 255A, 256A, 257A, 258A, 259A, 260A, 261A, 262A, 263A, 264A, 265A, 266A	4	406567974		COVER,CONNECTOR COVER HALF AMP MODU E/W CENTER BAR #91-5435-2 AMP INC				
4995	251A, 252A, 253A, 254A, 255A, 256A, 257A, 258A, 259A, 260A, 261A, 262A, 263A, 264A, 265A, 266A	1	105412506	809A-64/26	CABLE 26GA., CONVENIENT LENGTH PACKAGES			4	5
5000	501A, 511A, 551A	1	105419451	810AS-128/26	CABLE VARIABLE LENGTH			4	

***** STOCKLIST CONTINUED AT RIGHT *****

ED5D621-35

STOCKLIST									
ITEM NBR	LIST GROUP CODE	QTY PER CODE	PRODUCT IDENTIFIER	CODE	DESCRIPTION	REFERENCE POSITION	NOTE		
							SYM	NBR	
5010	501A, 511A, 551A	8	406569376		CONNECTOR,ELECTRICAL PIN, 34 CONTACTS, FEMALE, RECTANGULAR #104800-1 AMP INC.				
5020	501A, 511A, 551A	8	406567966		COVER,CONNECTOR COV HALF AMP MODU E/W CENTER BAR #104813-1 AMP INC				
5030	501A, 511A, 551A	8	406567974		COVER,CONNECTOR COVER HALF AMP MODU E/W CENTER BAR #91-5435-2 AMP INC				
5040	501A, 511A, 551A	1	400366332	AT8544	CLAMP,BOND B SIZE 1 INCH				
5050	501A, 511A, 551A	1	845312529		CABLE ASSEMBLY				
5060	501A, 511A, 551A	1	804236388	P-423638	WASHER,LOCK EXTERNAL TOOTH STEEL .375 289A FINISH			*	
5070	502A, 512A, 552A	1	105419451	810AS-128/26	CABLE VARIABLE LENGTH				4
5080	502A, 512A, 552A	8	406569376		CONNECTOR,ELECTRICAL PIN, 34 CONTACTS, FEMALE, RECTANGULAR #104800-1 AMP INC.				
5090	502A, 512A, 552A	8	406567966		COVER,CONNECTOR COV HALF AMP MODU E/W CENTER BAR #104813-1 AMP INC				
5100	502A, 512A, 552A	8	406567974		COVER,CONNECTOR COVER HALF AMP MODU E/W CENTER BAR #91-5435-2 AMP INC				
5110	502A, 512A, 552A	1	400366332	AT8544	CLAMP,BOND B SIZE 1 INCH				
5120	502A, 512A, 552A	1	845312529		CABLE ASSEMBLY				
5130	502A, 512A, 552A	1	804236388	P-423638	WASHER,LOCK EXTERNAL TOOTH STEEL .375 289A FINISH			*	
5140	503A, 513A, 553A	1	105419451	810AS-128/26	CABLE VARIABLE LENGTH				4
5150	503A, 513A, 553A	8	406569376		CONNECTOR,ELECTRICAL PIN, 34 CONTACTS, FEMALE, RECTANGULAR #104800-1 AMP INC.				
5160	503A, 513A, 553A	8	406567966		COVER,CONNECTOR COV HALF AMP MODU E/W CENTER BAR #104813-1 AMP INC				

STOCKLIST CONTINUED ON SHEET D11

SEE PROPRIETARY NOTICE ON SHEET ONE	
XT13	
5ESS (R) SWITCHING EQUIPMENT CABLE ASSEMBLIES FOR INTEGRATED SERVICES DATA NETWORK	
DWG SIZE C2	ISSUE 53
LUCENT TECHNOLOGIES INC ED5D621-35	
SHEET D10 OF 141	

STOCKLIST								
ITEM NBR	LIST GROUP CODE	QTY PER CODE	PRODUCT IDENTIFIER	CODE	DESCRIPTION	REFERENCE POSITION	NOTE	
							SYM	NBR
5170	503A, 513A, 553A	8	406567974		COVER,CONNECTOR COVER HALF AMP MODU E/W CENTER BAR #91-5435-2 AMP INC			
5180	503A, 513A, 553A	1	400366332	AT8544	CLAMP,BOND B SIZE 1 INCH			
5190	503A, 513A, 553A	1	845312529		CABLE ASSEMBLY			
5200	503A, 513A, 553A	1	804236388	P-423638	WASHER,LOCK EXTERNAL TOOTH STEEL .375 289A FINISH		*	
5210	504A, 514A, 554A	1	105419451	810AS-128/26	CABLE VARIABLE LENGTH			4
5220	504A, 514A, 554A	8	406569376		CONNECTOR,ELECTRICAL PIN, 34 CONTACTS, FEMALE, RECTANGULAR #104800-1 AMP INC.			
5230	504A, 514A, 554A	8	406567966		COVER,CONNECTOR COV HALF AMP MODU E/W CENTER BAR #104813-1 AMP INC			
5240	504A, 514A, 554A	8	406567974		COVER,CONNECTOR COVER HALF AMP MODU E/W CENTER BAR #91-5435-2 AMP INC			
5250	504A, 514A, 554A	1	400366332	AT8544	CLAMP,BOND B SIZE 1 INCH			
5260	504A, 514A, 554A	1	845312529		CABLE ASSEMBLY			
5270	504A, 514A, 554A	1	804236388	P-423638	WASHER,LOCK EXTERNAL TOOTH STEEL .375 289A FINISH		*	
5280	505A, 515A, 555A	1	105419451	810AS-128/26	CABLE VARIABLE LENGTH			4
5290	505A, 515A, 555A	8	406569376		CONNECTOR,ELECTRICAL PIN, 34 CONTACTS, FEMALE, RECTANGULAR #104800-1 AMP INC.			
5300	505A, 515A, 555A	8	406567966		COVER,CONNECTOR COV HALF AMP MODU E/W CENTER BAR #104813-1 AMP INC			
5310	505A, 515A, 555A	8	406567974		COVER,CONNECTOR COVER HALF AMP MODU E/W CENTER BAR #91-5435-2 AMP INC			
5320	505A, 515A, 555A	1	400366332	AT8544	CLAMP,BOND B SIZE 1 INCH			
5330	505A, 515A, 555A	1	845312529		CABLE ASSEMBLY			
5340	505A, 515A, 555A	1	804236388	P-423638	WASHER,LOCK EXTERNAL TOOTH STEEL .375 289A FINISH		*	
5350	506A, 516A, 556A	1	105419451	810AS-128/26	CABLE VARIABLE LENGTH			4

STOCKLIST								
ITEM NBR	LIST GROUP CODE	QTY PER CODE	PRODUCT IDENTIFIER	CODE	DESCRIPTION	REFERENCE POSITION	NOTE	
							SYM	NBR
5360	506A, 516A, 556A	8	406569376		CONNECTOR,ELECTRICAL PIN, 34 CONTACTS, FEMALE, RECTANGULAR #104800-1 AMP INC.			
5370	506A, 516A, 556A	8	406567966		COVER,CONNECTOR COV HALF AMP MODU E/W CENTER BAR #104813-1 AMP INC			
5380	506A, 516A, 556A	8	406567974		COVER,CONNECTOR COVER HALF AMP MODU E/W CENTER BAR #91-5435-2 AMP INC			
5390	506A, 516A, 556A	1	400366332	AT8544	CLAMP,BOND B SIZE 1 INCH			
5400	506A, 516A, 556A	1	845312529		CABLE ASSEMBLY			
5410	506A, 516A, 556A	1	804236388	P-423638	WASHER,LOCK EXTERNAL TOOTH STEEL .375 289A FINISH		*	
5420	507A, 517A, 557A	1	105419451	810AS-128/26	CABLE VARIABLE LENGTH			4
5430	507A, 517A, 557A	8	406569376		CONNECTOR,ELECTRICAL PIN, 34 CONTACTS, FEMALE, RECTANGULAR #104800-1 AMP INC.			
5440	507A, 517A, 557A	8	406567966		COVER,CONNECTOR COV HALF AMP MODU E/W CENTER BAR #104813-1 AMP INC			
5450	507A, 517A, 557A	8	406567974		COVER,CONNECTOR COVER HALF AMP MODU E/W CENTER BAR #91-5435-2 AMP INC			
5460	507A, 517A, 557A	1	400366332	AT8544	CLAMP,BOND B SIZE 1 INCH			
5470	507A, 517A, 557A	1	845312529		CABLE ASSEMBLY			
5480	507A, 517A, 557A	1	804236388	P-423638	WASHER,LOCK EXTERNAL TOOTH STEEL .375 289A FINISH		*	
5490	508A, 518A, 558A	1	105419451	810AS-128/26	CABLE VARIABLE LENGTH			4
5500	508A, 518A, 558A	8	406569376		CONNECTOR,ELECTRICAL PIN, 34 CONTACTS, FEMALE, RECTANGULAR #104800-1 AMP INC.			
5510	508A, 518A, 558A	8	406567966		COVER,CONNECTOR COV HALF AMP MODU E/W CENTER BAR #104813-1 AMP INC			

STOCKLIST CONTINUED ON SHEET D12

***** STOCKLIST CONTINUED AT RIGHT *****

SEE PROPRIETARY NOTICE ON SHEET ONE	
XT13	
5ESS (R) SWITCHING EQUIPMENT CABLE ASSEMBLIES FOR INTEGRATED SERVICES DATA NETWORK	
DWG SIZE C2	ISSUE 53
LUCENT TECHNOLOGIES INC	ED5D621-35
SHEET OF	D11 141

STOCKLIST								
ITEM NBR	LIST GROUP CODE	QTY PER CODE	PRODUCT IDENTIFIER	CODE	DESCRIPTION	REFERENCE POSITION	NOTE	
							SYM	NBR
5520	508A, 518A, 558A	8	406567974		COVER,CONNECTOR COVER HALF AMP MODU E/W CENTER BAR #91-5435-2 AMP INC			
5530	508A, 518A, 558A	1	400366332	AT8544	CLAMP,BOND B SIZE 1 INCH			
5540	508A, 518A, 558A	1	845312529		CABLE ASSEMBLY			
5550	508A, 518A, 558A	1	804236388	P-423638	WASHER,LOCK EXTERNAL TOOTH STEEL .375 289A FINISH		*	
5560	521A, 531A, 561A	1	105419451	810AS-128/26	CABLE VARIABLE LENGTH			4
5570	521A, 531A, 561A	8	406569376		CONNECTOR,ELECTRICAL PIN, 34 CONTACTS, FEMALE, RECTANGULAR #104800-1 AMP INC.			
5580	521A, 531A, 561A	8	406567966		COVER,CONNECTOR COV HALF AMP MODU E/W CENTER BAR #104813-1 AMP INC			
5590	521A, 531A, 561A	8	406567974		COVER,CONNECTOR COVER HALF AMP MODU E/W CENTER BAR #91-5435-2 AMP INC			
5600	521A, 531A, 561A	1	400366332	AT8544	CLAMP,BOND B SIZE 1 INCH			
5610	521A, 531A, 561A	1	845312529		CABLE ASSEMBLY			
5620	521A, 531A, 561A	1	804236388	P-423638	WASHER,LOCK EXTERNAL TOOTH STEEL .375 289A FINISH		*	
5630	522A, 532A, 562A	1	105419451	810AS-128/26	CABLE VARIABLE LENGTH			4
5640	522A, 532A, 562A	8	406569376		CONNECTOR,ELECTRICAL PIN, 34 CONTACTS, FEMALE, RECTANGULAR #104800-1 AMP INC.			
5650	522A, 532A, 562A	8	406567966		COVER,CONNECTOR COV HALF AMP MODU E/W CENTER BAR #104813-1 AMP INC			
5660	522A, 532A, 562A	8	406567974		COVER,CONNECTOR COVER HALF AMP MODU E/W CENTER BAR #91-5435-2 AMP INC			
5670	522A, 532A, 562A	1	400366332	AT8544	CLAMP,BOND B SIZE 1 INCH			
5680	522A, 532A, 562A	1	845312529		CABLE ASSEMBLY			
5690	522A, 532A, 562A	1	804236388	P-423638	WASHER,LOCK EXTERNAL TOOTH STEEL .375 289A FINISH		*	
5710	523A, 533A, 563A	1	105419451	810AS-128/26	CABLE VARIABLE LENGTH			4

***** STOCKLIST CONTINUED AT RIGHT *****

ED5D621-35

STOCKLIST								
ITEM NBR	LIST GROUP CODE	QTY PER CODE	PRODUCT IDENTIFIER	CODE	DESCRIPTION	REFERENCE POSITION	NOTE	
							SYM	NBR
5720	523A, 533A, 563A	8	406569376		CONNECTOR,ELECTRICAL PIN, 34 CONTACTS, FEMALE, RECTANGULAR #104800-1 AMP INC.			
5730	523A, 533A, 563A	8	406567966		COVER,CONNECTOR COV HALF AMP MODU E/W CENTER BAR #104813-1 AMP INC			
5740	523A, 533A, 563A	8	406567974		COVER,CONNECTOR COVER HALF AMP MODU E/W CENTER BAR #91-5435-2 AMP INC			
5750	523A, 533A, 563A	1	400366332	AT8544	CLAMP,BOND B SIZE 1 INCH			
5760	523A, 533A, 563A	1	845312529		CABLE ASSEMBLY			
5770	523A, 533A, 563A	1	804236388	P-423638	WASHER,LOCK EXTERNAL TOOTH STEEL .375 289A FINISH		*	
5780	524A, 534A, 564A	1	105419451	810AS-128/26	CABLE VARIABLE LENGTH			4
5790	524A, 534A, 564A	8	406569376		CONNECTOR,ELECTRICAL PIN, 34 CONTACTS, FEMALE, RECTANGULAR #104800-1 AMP INC.			
5800	524A, 534A, 564A	8	406567966		COVER,CONNECTOR COV HALF AMP MODU E/W CENTER BAR #104813-1 AMP INC			
5810	524A, 534A, 564A	8	406567974		COVER,CONNECTOR COVER HALF AMP MODU E/W CENTER BAR #91-5435-2 AMP INC			
5820	524A, 534A, 564A	1	400366332	AT8544	CLAMP,BOND B SIZE 1 INCH			
5830	524A, 534A, 564A	1	845312529		CABLE ASSEMBLY			
5840	524A, 534A, 564A	1	804236388	P-423638	WASHER,LOCK EXTERNAL TOOTH STEEL .375 289A FINISH		*	
5850	541A	1	105419436	808AS-32/26	CABLE 26GA 16 PR SHIELDED UL LISTED TYPE CMR			4
5860	541A	8	406569376		CONNECTOR,ELECTRICAL PIN, 34 CONTACTS, FEMALE, RECTANGULAR #104800-1 AMP INC.			
5870	541A	8	406567966		COVER,CONNECTOR COV HALF AMP MODU E/W CENTER BAR #104813-1 AMP INC			

STOCKLIST CONTINUED ON SHEET D13

SEE PROPRIETARY NOTICE ON SHEET ONE

XT13

5ESS (R) SWITCHING EQUIPMENT
CABLE ASSEMBLIES
FOR
INTEGRATED SERVICES DATA NETWORK

DWG SIZE C2 ISSUE 53

LUCENT TECHNOLOGIES INC ED5D621-35

SHEET D12 OF 141

STOCKLIST								
ITEM NBR	LIST GROUP CODE	QTY PER CODE	PRODUCT IDENTIFIER	CODE	DESCRIPTION	REFERENCE POSITION	NOTE	
							SYM	NBR
5880	541A	8	406567974		COVER,CONNECTOR COVER HALF AMP MODU E/W CENTER BAR #91-5435-2 AMP INC			
5890	541A	1	400366332	AT8544	CLAMP,BOND B SIZE 1 INCH			
5900	541A	1	845312529		CABLE ASSEMBLY			
5910	541A	1	804236388	P-423638	WASHER,LOCK EXTERNAL TOOTH STEEL .375 289A FINISH		*	
5920	542A	1	105419436	808AS-32/26	CABLE 26GA 16 PR SHIELDED UL LISTED TYPE CMR			4
5930	542A	8	406569376		CONNECTOR,ELECTRICAL PIN, 34 CONTACTS, FEMALE, RECTANGULAR #104800-1 AMP INC.			
5940	542A	8	406567966		COVER,CONNECTOR COV HALF AMP MODU E/W CENTER BAR #104813-1 AMP INC			
5950	542A	8	406567974		COVER,CONNECTOR COVER HALF AMP MODU E/W CENTER BAR #91-5435-2 AMP INC			
5960	542A	1	400366332	AT8544	CLAMP,BOND B SIZE 1 INCH			
5970	542A	1	845312529		CABLE ASSEMBLY			
5980	542A	1	804236388	P-423638	WASHER,LOCK EXTERNAL TOOTH STEEL .375 289A FINISH		*	
5990	543A	1	105419436	808AS-32/26	CABLE 26GA 16 PR SHIELDED UL LISTED TYPE CMR			4
6000	543A	8	406569376		CONNECTOR,ELECTRICAL PIN, 34 CONTACTS, FEMALE, RECTANGULAR #104800-1 AMP INC.			
6010	543A	8	406567966		COVER,CONNECTOR COV HALF AMP MODU E/W CENTER BAR #104813-1 AMP INC			
6020	543A	8	406567974		COVER,CONNECTOR COVER HALF AMP MODU E/W CENTER BAR #91-5435-2 AMP INC			
6030	543A	1	400366332	AT8544	CLAMP,BOND B SIZE 1 INCH			
6040	543A	1	845312529		CABLE ASSEMBLY			
6050	543A	1	804236388	P-423638	WASHER,LOCK EXTERNAL TOOTH STEEL .375 289A FINISH		*	
6060	544A	1	105419436	808AS-32/26	CABLE 26GA 16 PR SHIELDED UL LISTED TYPE CMR			4
6070	544A	8	406569376		CONNECTOR,ELECTRICAL PIN, 34 CONTACTS, FEMALE, RECTANGULAR #104800-1 AMP INC.			
6080	544A	8	406567966		COVER,CONNECTOR COV HALF AMP MODU E/W CENTER BAR #104813-1 AMP INC			
6090	544A	8	406567974		COVER,CONNECTOR COVER HALF AMP MODU E/W CENTER BAR #91-5435-2 AMP INC			
6100	544A	1	400366332	AT8544	CLAMP,BOND B SIZE 1 INCH			
6110	544A	1	845312529		CABLE ASSEMBLY			

***** STOCKLIST CONTINUED AT RIGHT *****

ED5D621-35

STOCKLIST								
ITEM NBR	LIST GROUP CODE	QTY PER CODE	PRODUCT IDENTIFIER	CODE	DESCRIPTION	REFERENCE POSITION	NOTE	
							SYM	NBR
6120	544A	1	804236388	P-423638	WASHER,LOCK EXTERNAL TOOTH STEEL .375 289A FINISH		*	
6150	545A	1	105419451	810AS-128/26	CABLE VARIABLE LENGTH			4 6
6160	545A	16	406569376		CONNECTOR,ELECTRICAL PIN, 34 CONTACTS, FEMALE, RECTANGULAR #104800-1 AMP INC.			
6170	545A	16	406567966		COVER,CONNECTOR COV HALF AMP MODU E/W CENTER BAR #104813-1 AMP INC			
6180	545A	16	406567974		COVER,CONNECTOR COVER HALF AMP MODU E/W CENTER BAR #91-5435-2 AMP INC			
6190	545A	1	400366332	AT8544	CLAMP,BOND B SIZE 1 INCH			
6200	545A	1	845312529		CABLE ASSEMBLY			
6210	545A	1	804236388	P-423638	WASHER,LOCK EXTERNAL TOOTH STEEL .375 289A FINISH		*	
6220	546A	1	105419451	810AS-128/26	CABLE VARIABLE LENGTH			4 6
6230	546A	16	406569376		CONNECTOR,ELECTRICAL PIN, 34 CONTACTS, FEMALE, RECTANGULAR #104800-1 AMP INC.			
6240	546A	16	406567966		COVER,CONNECTOR COV HALF AMP MODU E/W CENTER BAR #104813-1 AMP INC			
6250	546A	16	406567974		COVER,CONNECTOR COVER HALF AMP MODU E/W CENTER BAR #91-5435-2 AMP INC			
6260	546A	1	400366332	AT8544	CLAMP,BOND B SIZE 1 INCH			
6270	546A	1	845312529		CABLE ASSEMBLY			
6280	546A	1	804236388	P-423638	WASHER,LOCK EXTERNAL TOOTH STEEL .375 289A FINISH		*	
6290	547A	1	105419451	810AS-128/26	CABLE VARIABLE LENGTH			4 6
6300	547A	16	406569376		CONNECTOR,ELECTRICAL PIN, 34 CONTACTS, FEMALE, RECTANGULAR #104800-1 AMP INC.			
6310	547A	16	406567966		COVER,CONNECTOR COV HALF AMP MODU E/W CENTER BAR #104813-1 AMP INC			
6320	547A	16	406567974		COVER,CONNECTOR COVER HALF AMP MODU E/W CENTER BAR #91-5435-2 AMP INC			

STOCKLIST CONTINUED ON SHEET D14

SEE PROPRIETARY NOTICE ON SHEET ONE

XT13

5ESS (R) SWITCHING EQUIPMENT
CABLE ASSEMBLIES
FOR
INTEGRATED SERVICES DATA NETWORK

DWG SIZE C2 ISSUE 53

LUCENT TECHNOLOGIES INC ED5D621-35

SHEET D13 OF 141

STOCKLIST								
ITEM NBR	LIST GROUP CODE	QTY PER CODE	PRODUCT IDENTIFIER	CODE	DESCRIPTION	REFERENCE POSITION	NOTE	
							SYM	NBR
6330	547A	1	400366332	AT8544	CLAMP,BOND B SIZE 1 INCH			
6340	547A	1	845312529		CABLE ASSEMBLY			
6350	547A	1	804236388	P-423638	WASHER,LOCK EXTERNAL TOOTH STEEL .375 289A FINISH		*	
6360	548A	1	105419451	810AS-128/26	CABLE VARIABLE LENGTH			4 6
6370	548A	16	406569376		CONNECTOR,ELECTRICAL PIN, 34 CONTACTS, FEMALE, RECTANGULAR #104800-1 AMP INC.			
6380	548A	16	406567966		COVER,CONNECTOR COV HALF AMP MODU E/W CENTER BAR #104813-1 AMP INC			
6390	548A	16	406567974		COVER,CONNECTOR COVER HALF AMP MODU E/W CENTER BAR #91-5435-2 AMP INC			
6400	548A	1	400366332	AT8544	CLAMP,BOND B SIZE 1 INCH			
6410	548A	1	845312529		CABLE ASSEMBLY			
6420	548A	1	804236388	P-423638	WASHER,LOCK EXTERNAL TOOTH STEEL .375 289A FINISH		*	
7130	601	1	106556780	608B	CABLE 16 PAIR 22 GA SINGLE JACKET POLYVINYL CHLORIDE GRAY			4
7140	601	1	103125365	982AD	CONNECTOR,BACKPLANE			
7150	601	2	103125373	982AE	CONNECTOR,ELECTRICAL			
7160	601	2	842923773		RELIEF,STRAIN			
7170	601	1	400366332	AT8544	CLAMP,BOND B SIZE 1 INCH			
7180	601	1	845312529		CABLE ASSEMBLY			
7190	601	1	804236388	P-423638	WASHER,LOCK EXTERNAL TOOTH STEEL .375 289A FINISH		*	
7200	603	1	106556780	608B	CABLE 16 PAIR 22 GA SINGLE JACKET POLYVINYL CHLORIDE GRAY			4
7210	603	1	103125365	982AD	CONNECTOR,BACKPLANE			
7220	603	2	103125373	982AE	CONNECTOR,ELECTRICAL			
7230	603	2	842923773		RELIEF,STRAIN			
7240	603	1	400366332	AT8544	CLAMP,BOND B SIZE 1 INCH			
7250	603	1	845312529		CABLE ASSEMBLY			
7260	603	1	804236388	P-423638	WASHER,LOCK EXTERNAL TOOTH STEEL .375 289A FINISH		*	
7270	605	1	106556780	608B	CABLE 16 PAIR 22 GA SINGLE JACKET POLYVINYL CHLORIDE GRAY			4
7280	605	1	103125365	982AD	CONNECTOR,BACKPLANE			
7290	605	2	103125373	982AE	CONNECTOR,ELECTRICAL			
7300	605	2	842923773		RELIEF,STRAIN			
7310	605	1	400366332	AT8544	CLAMP,BOND B SIZE 1 INCH			
7320	605	1	845312529		CABLE ASSEMBLY			
7330	605	1	804236388	P-423638	WASHER,LOCK EXTERNAL TOOTH STEEL .375 289A FINISH		*	
7340	607	1	106556780	608B	CABLE 16 PAIR 22 GA SINGLE JACKET POLYVINYL CHLORIDE GRAY			4

***** STOCKLIST CONTINUED AT RIGHT *****

ED5D621-35

STOCKLIST								
ITEM NBR	LIST GROUP CODE	QTY PER CODE	PRODUCT IDENTIFIER	CODE	DESCRIPTION	REFERENCE POSITION	NOTE	
							SYM	NBR
7350	607	1	103125365	982AD	CONNECTOR,BACKPLANE			
7360	607	2	103125373	982AE	CONNECTOR,ELECTRICAL			
7370	607	2	842923773		RELIEF,STRAIN			
7380	607	1	400366332	AT8544	CLAMP,BOND B SIZE 1 INCH			
7390	607	1	845312529		CABLE ASSEMBLY			
7400	607	1	804236388	P-423638	WASHER,LOCK EXTERNAL TOOTH STEEL .375 289A FINISH		*	
7410	609	1	106556780	608B	CABLE 16 PAIR 22 GA SINGLE JACKET POLYVINYL CHLORIDE GRAY			4
7420	609	1	103125365	982AD	CONNECTOR,BACKPLANE			
7430	609	2	103125373	982AE	CONNECTOR,ELECTRICAL			
7440	609	2	842923773		RELIEF,STRAIN			
7450	609	1	400366332	AT8544	CLAMP,BOND B SIZE 1 INCH			
7460	609	1	845312529		CABLE ASSEMBLY			
7470	609	1	804236388	P-423638	WASHER,LOCK EXTERNAL TOOTH STEEL .375 289A FINISH		*	
7480	611	1	106556780	608B	CABLE 16 PAIR 22 GA SINGLE JACKET POLYVINYL CHLORIDE GRAY			4
7490	611	1	103125365	982AD	CONNECTOR,BACKPLANE			
7500	611	2	103125373	982AE	CONNECTOR,ELECTRICAL			
7510	611	2	842923773		RELIEF,STRAIN			
7520	611	1	400366332	AT8544	CLAMP,BOND B SIZE 1 INCH			
7530	611	1	845312529		CABLE ASSEMBLY			
7540	611	1	804236388	P-423638	WASHER,LOCK EXTERNAL TOOTH STEEL .375 289A FINISH		*	
7550	613	1	106556780	608B	CABLE 16 PAIR 22 GA SINGLE JACKET POLYVINYL CHLORIDE GRAY			4
7560	613	1	103125365	982AD	CONNECTOR,BACKPLANE			
7570	613	2	103125373	982AE	CONNECTOR,ELECTRICAL			
7580	613	2	842923773		RELIEF,STRAIN			
7590	613	1	400366332	AT8544	CLAMP,BOND B SIZE 1 INCH			
7600	613	1	845312529		CABLE ASSEMBLY			
7610	613	1	804236388	P-423638	WASHER,LOCK EXTERNAL TOOTH STEEL .375 289A FINISH		*	
7620	615	1	106556780	608B	CABLE 16 PAIR 22 GA SINGLE JACKET POLYVINYL CHLORIDE GRAY			4
7630	615	1	103125365	982AD	CONNECTOR,BACKPLANE			
7640	615	2	103125373	982AE	CONNECTOR,ELECTRICAL			
7650	615	2	842923773		RELIEF,STRAIN			

STOCKLIST CONTINUED ON SHEET D15

SEE PROPRIETARY NOTICE ON SHEET ONE

XT13

5ESS (R) SWITCHING EQUIPMENT
CABLE ASSEMBLIES
FOR
INTEGRATED SERVICES DATA NETWORK

DWG SIZE C2 ISSUE 53

LUCENT TECHNOLOGIES INC ED5D621-35

SHEET D14 OF 141

STOCKLIST								
ITEM NBR	LIST GROUP CODE	QTY PER CODE	PRODUCT IDENTIFIER	CODE	DESCRIPTION	REFERENCE POSITION	NOTE	
							SYM	NBR
7660	615	1	400366332	AT8544	CLAMP,BOND B SIZE 1 INCH			
7670	615	1	845312529		CABLE ASSEMBLY			
7680	615	1	804236388	P-423638	WASHER,LOCK EXTERNAL TOOTH STEEL .375 289A FINISH		*	
7690	617	1	106556780	608B	CABLE 16 PAIR 22 GA SINGLE JACKET POLYVINYL CHLORIDE GRAY			4
7700	617	1	103125365	982AD	CONNECTOR,BACKPLANE			
7710	617	2	103125373	982AE	CONNECTOR,ELECTRICAL			
7720	617	2	842923773		RELIEF,STRAIN			
7730	617	1	400366332	AT8544	CLAMP,BOND B SIZE 1 INCH			
7740	617	1	845312529		CABLE ASSEMBLY			
7750	617	1	804236388	P-423638	WASHER,LOCK EXTERNAL TOOTH STEEL .375 289A FINISH		*	
7760	619	1	106556780	608B	CABLE 16 PAIR 22 GA SINGLE JACKET POLYVINYL CHLORIDE GRAY			4
7770	619	1	103125365	982AD	CONNECTOR,BACKPLANE			
7780	619	2	103125373	982AE	CONNECTOR,ELECTRICAL			
7790	619	2	842923773		RELIEF,STRAIN			
7800	619	1	400366332	AT8544	CLAMP,BOND B SIZE 1 INCH			
7810	619	1	845312529		CABLE ASSEMBLY			
7820	619	1	804236388	P-423638	WASHER,LOCK EXTERNAL TOOTH STEEL .375 289A FINISH		*	
7830	621	1	106556780	608B	CABLE 16 PAIR 22 GA SINGLE JACKET POLYVINYL CHLORIDE GRAY			4
7840	621	1	103125365	982AD	CONNECTOR,BACKPLANE			
7850	621	2	103125373	982AE	CONNECTOR,ELECTRICAL			
7860	621	2	842923773		RELIEF,STRAIN			
7870	621	1	400366332	AT8544	CLAMP,BOND B SIZE 1 INCH			
7880	621	1	845312529		CABLE ASSEMBLY			
7890	621	1	804236388	P-423638	WASHER,LOCK EXTERNAL TOOTH STEEL .375 289A FINISH		*	
7900	623	1	106556780	608B	CABLE 16 PAIR 22 GA SINGLE JACKET POLYVINYL CHLORIDE GRAY			4
7910	623	1	103125365	982AD	CONNECTOR,BACKPLANE			
7920	623	2	103125373	982AE	CONNECTOR,ELECTRICAL			
7930	623	2	842923773		RELIEF,STRAIN			
7940	623	1	400366332	AT8544	CLAMP,BOND B SIZE 1 INCH			
7950	623	1	845312529		CABLE ASSEMBLY			
7960	623	1	804236388	P-423638	WASHER,LOCK EXTERNAL TOOTH STEEL .375 289A FINISH		*	
8200	701	1	105419436	808AS-32/26	CABLE 26GA 16 PR SHIELDED UL LISTED TYPE CMR			
8210	701	16	105772784	963T-6	CONNECTOR			
8211	701	32	106905425	TCOV-LS6G	COVER,PROTECTIVE			
8240	313,701	1	400366332	AT8544	CLAMP,BOND B SIZE 1 INCH			
8250	313,701	1	845312529		CABLE ASSEMBLY			

***** STOCKLIST CONTINUED AT RIGHT *****

ED5D621-35

STOCKLIST								
ITEM NBR	LIST GROUP CODE	QTY PER CODE	PRODUCT IDENTIFIER	CODE	DESCRIPTION	REFERENCE POSITION	NOTE	
							SYM	NBR
8260	313,701	1	804236388	P-423638	WASHER,LOCK EXTERNAL TOOTH STEEL .375 289A FINISH		*	
8270	138A	A/R	105419477	812AS-4/26	CABLE 4 PR SHIELDED UL LISTED TYPE CMR 26GA			
8280	138A	1	900293283		TUBING,HEAT SHRINKABLE 3/8 IN.X 2 IN. BLACK #RT876 RAYCHEM CORP.			
8290	138A	1	843743485		WIRE 24GA DP 3 BK			
8310	138A	1	406949594		LUG,TERMINAL SPADE TONGUE #60445-3 AMP INC.			
8320	138A	1	406671495		PLUG,ELECTRONIC MODULAR 8-2PC, 8 CONTACTS, LOAD BAR PROVIDED FOR WIRETERMIN ATION #940-SP-014-308 STEWART STAMPING CORP.			
8400	650,652	A/R	105412530	812A-4/26	CABLE 26 GAGE			
8410	650	2	997082144	KS19088L2	CONNECTOR,PLUG MALE			
8415	652	2	403694664	KS23146L5	PLUG			
8420	650,652	2	405184524		HOOD SUPER D ADAPTER SYSTEM, BLACK PLASTIC STRAIGHT WITH TWO CAPTIVE 4-40 SCREWS #SDH-25BFCS TRW INC.			
8430	650,652	2	996512786		GROMMET 5/32 X 7/16 X 9/32 INCHES #374 ATLANTIC INDIA RUBBER WORK			
8440	651	A/R	105412530	812A-4/26	CABLE 26 GAGE			
8450	651,653	2	407123058		CONNECTOR,D-SUBMINIATURE PLUG #TC-37P-TS CINCH			
8460	651,653	2	403955719		HOOD,BLACK PLASTIC STRAIGHT #SDH37BFCS TRW CINCH INC.			
8470	651,653	2	996512786		GROMMET 5/32 X 7/16 X 9/32 INCHES #374 ATLANTIC INDIA RUBBER WORK			
8475	653	A/R	105412522	#811A 8/26	CABLE 26GA			

STOCKLIST CONTINUED ON SHEET D16

SEE PROPRIETARY NOTICE ON SHEET ONE

XT13

5ESS (R) SWITCHING EQUIPMENT
CABLE ASSEMBLIES
FOR
INTEGRATED SERVICES DATA NETWORK

DWG SIZE C2 ISSUE 53

LUCENT TECHNOLOGIES INC ED5D621-35

SHEET D15 OF 141

STOCKLIST								
ITEM NBR	LIST GROUP CODE	QTY PER CODE	PRODUCT IDENTIFIER	CODE	DESCRIPTION	REFERENCE POSITION	NOTE	
							SYM	NBR
8500	901A, 901B, 901C, 901D, 902A, 902B, 902C, 902D, 903A, 903B, 903C, 903D, 904A, 904B, 904C, 904D, 905A, 905B, 905C, 905D, 906A, 906B, 906C, 906D, 907A, 907B, 907C, 907D, 908A, 908B, 908C, 908D	A/R	106078405	2249032C	CABLE 26GA, 32 PAIR			
8510	901A, 901B, 901C, 901D, 902A, 902B, 902C, 902D, 903A, 903B, 903C, 903D, 904A, 904B, 904C, 904D, 905A, 905B, 905C, 905D, 906A, 906B, 906C, 906D, 907A, 907B, 907C, 907D, 908A, 908B, 908C, 908D	2	406569376		CONNECTOR, ELECTRICAL PIN, 34 CONTACTS, FEMALE, RECTANGULAR #104800-1 AMP INC.			

***** STOCKLIST CONTINUED AT RIGHT *****

STOCKLIST								
ITEM NBR	LIST GROUP CODE	QTY PER CODE	PRODUCT IDENTIFIER	CODE	DESCRIPTION	REFERENCE POSITION	NOTE	
							SYM	NBR
8520	901A, 901B, 901C, 901D, 902A, 902B, 902C, 902D, 903A, 903B, 903C, 903D, 904A, 904B, 904C, 904D, 905A, 905B, 905C, 905D, 906A, 906B, 906C, 906D, 907A, 907B, 907C, 907D, 908A, 908B, 908C, 908D	2	406567966		COVER, CONNECTOR COV HALF AMP MODU E/W CENTER BAR #104813-1 AMP INC			
8530	901A, 901B, 901C, 901D, 902A, 902B, 902C, 902D, 903A, 903B, 903C, 903D, 904A, 904B, 904C, 904D, 905A, 905B, 905C, 905D, 906A, 906B, 906C, 906D, 907A, 907B, 907C, 907D, 908A, 908B, 908C, 908D	2	406567974		COVER, CONNECTOR COVER HALF AMP MODU E/W CENTER BAR #91-5435-2 AMP INC			

STOCKLIST CONTINUED ON SHEET D17

SEE PROPRIETARY NOTICE ON SHEET ONE	
XT13	
5ESS (R) SWITCHING EQUIPMENT CABLE ASSEMBLIES FOR INTEGRATED SERVICES DATA NETWORK	
DWG SIZE C2	ISSUE 53
LUCENT TECHNOLOGIES INC ED5D621-35	
SHEET D16 OF 141	

STOCKLIST								
ITEM NBR	LIST GROUP CODE	QTY PER CODE	PRODUCT IDENTIFIER	CODE	DESCRIPTION	REFERENCE POSITION	NOTE	
							SYM	NBR
8540	901A, 901B, 901C, 901D, 902A, 902B, 902C, 902D, 903A, 903B, 903C, 903D, 904A, 904B, 904C, 904D, 905A, 905B, 905C, 905D, 906A, 906B, 906C, 906D, 907A, 907B, 907C, 907D, 908A, 908B, 908C, 908D	1	400366332	AT8544	CLAMP,BOND B SIZE 1 INCH			
8550	901A, 901B, 901C, 901D, 902A, 902B, 902C, 902D, 903A, 903B, 903C, 903D, 904A, 904B, 904C, 904D, 905A, 905B, 905C, 905D, 906A, 906B, 906C, 906D, 907A, 907B, 907C, 907D, 908A, 908B, 908C, 908D	1	845312529		CABLE ASSEMBLY			

***** STOCKLIST CONTINUED AT RIGHT *****

STOCKLIST								
ITEM NBR	LIST GROUP CODE	QTY PER CODE	PRODUCT IDENTIFIER	CODE	DESCRIPTION	REFERENCE POSITION	NOTE	
							SYM	NBR
8560	901A, 901B, 901C, 901D, 902A, 902B, 902C, 902D, 903A, 903B, 903C, 903D, 904A, 904B, 904C, 904D, 905A, 905B, 905C, 905D, 906A, 906B, 906C, 906D, 907A, 907B, 907C, 907D, 908A, 908B, 908C, 908D	1	804236388	P-423638	WASHER,LOCK			
9000	300	2	406922286		CONNECTOR,MINI RIBBON #2-966061-4 AMP INC			
9005	300	4	406884635		COVER,CONNECTOR #1-964393-2 AMP INC.			
9010	300	1	406922260		CONNECTOR,MINI RIBBON #1-966061-6 AMP INC.			
9015	300	2	406884510		COVER,CONNECTOR #964393-8 AMP INC.			
9020	301	2	406922286		CONNECTOR,MINI RIBBON #2-966061-4 AMP INC			
9025	301	4	406884635		COVER,CONNECTOR #1-964393-2 AMP INC.			
9030	301	1	406922260		CONNECTOR,MINI RIBBON #1-966061-6 AMP INC.			
9035	301	2	406884510		COVER,CONNECTOR #964393-8 AMP INC.			
9040	302	16	406922161		CONNECTOR #966061-6 AMP INC.			
9045	302	32	406884312		COVER,CONNECTOR #964393-3 AMP INC.			
9050	303	16	406922161		CONNECTOR #966061-6 AMP INC.			

STOCKLIST CONTINUED ON SHEET D18

SEE PROPRIETARY NOTICE ON SHEET ONE	
XT13	
5ESS (R) SWITCHING EQUIPMENT CABLE ASSEMBLIES FOR INTEGRATED SERVICES DATA NETWORK	
DWG SIZE C2	ISSUE 53
LUCENT TECHNOLOGIES INC	ED5D621-35
SHEET D17 OF 141	

STOCKLIST

ITEM NBR	LIST GROUP CODE	QTY PER CODE	PRODUCT IDENTIFIER	CODE	DESCRIPTION	REFERENCE POSITION	NOTE	
							SYM	NBR
9055	303	32	406884312		COVER, CONNECTOR #964393-3 AMP INC.			
9060	304	2	406922286		CONNECTOR, MINI RIBBON #2-966061-4 AMP INC			
9065	304	4	406884635		COVER, CONNECTOR #1-964393-2 AMP INC.			
9067	304A	1	406922286		CONNECTOR, MINI RIBBON #2-966061-4 AMP INC			
9068	304A	2	406884635		COVER, CONNECTOR #1-964393-2 AMP INC.			
9070	305	2	406922286		CONNECTOR, MINI RIBBON #2-966061-4 AMP INC			
9075	305	4	406884635		COVER, CONNECTOR #1-964393-2 AMP INC.			
9080	306	1	406922286		CONNECTOR, MINI RIBBON #2-966061-4 AMP INC			
9085	306	2	406884635		COVER, CONNECTOR #1-964393-2 AMP INC.			
9090	307	1	406922252		CONNECTOR #1-966061-2 AMP INC.			
9095	307	2	406884502		COVER, CONNECTOR #964393-6 AMP INC.			
9100	308	2	406922161		CONNECTOR #966061-6 AMP INC.			
9105	308	4	406885673		COVER, CONNECTOR #2-964393-3 AMP INC.			
9110	309	1	406922286		CONNECTOR, MINI RIBBON #2-966061-4 AMP INC			
9115	309	2	406885731		COVER, CONNECTOR #3-964393-2 AMP INC.			
9120	310, 311, 312	1	406922161		CONNECTOR #966061-6 AMP INC.			
9125	310, 311, 312	2	406884312		COVER, CONNECTOR #964393-3 AMP INC.			
9130	313	16	406922161		CONNECTOR #966061-6 AMP INC.			
9135	313	32	406884312		COVER, CONNECTOR #964393-3 AMP INC.			
9140	70	2	997259890	KS16690L3	CONNECTOR, RECEPTACLE SOCKET			
9145	70	1	105412480	#807A 16/26	CABLE 26 GA UL LISTED TYPE CMR			

***** END OF STOCKLIST *****

SEE PROPRIETARY NOTICE ON SHEET ONE

XT13

5ESS (R) SWITCHING EQUIPMENT
CABLE ASSEMBLIES
FOR
INTEGRATED SERVICES DATA NETWORK

DWG SIZE C2 ISSUE 53

ED5D621-35

LUCENT TECHNOLOGIES INC ED5D621-35

SHEET D18 OF 141